




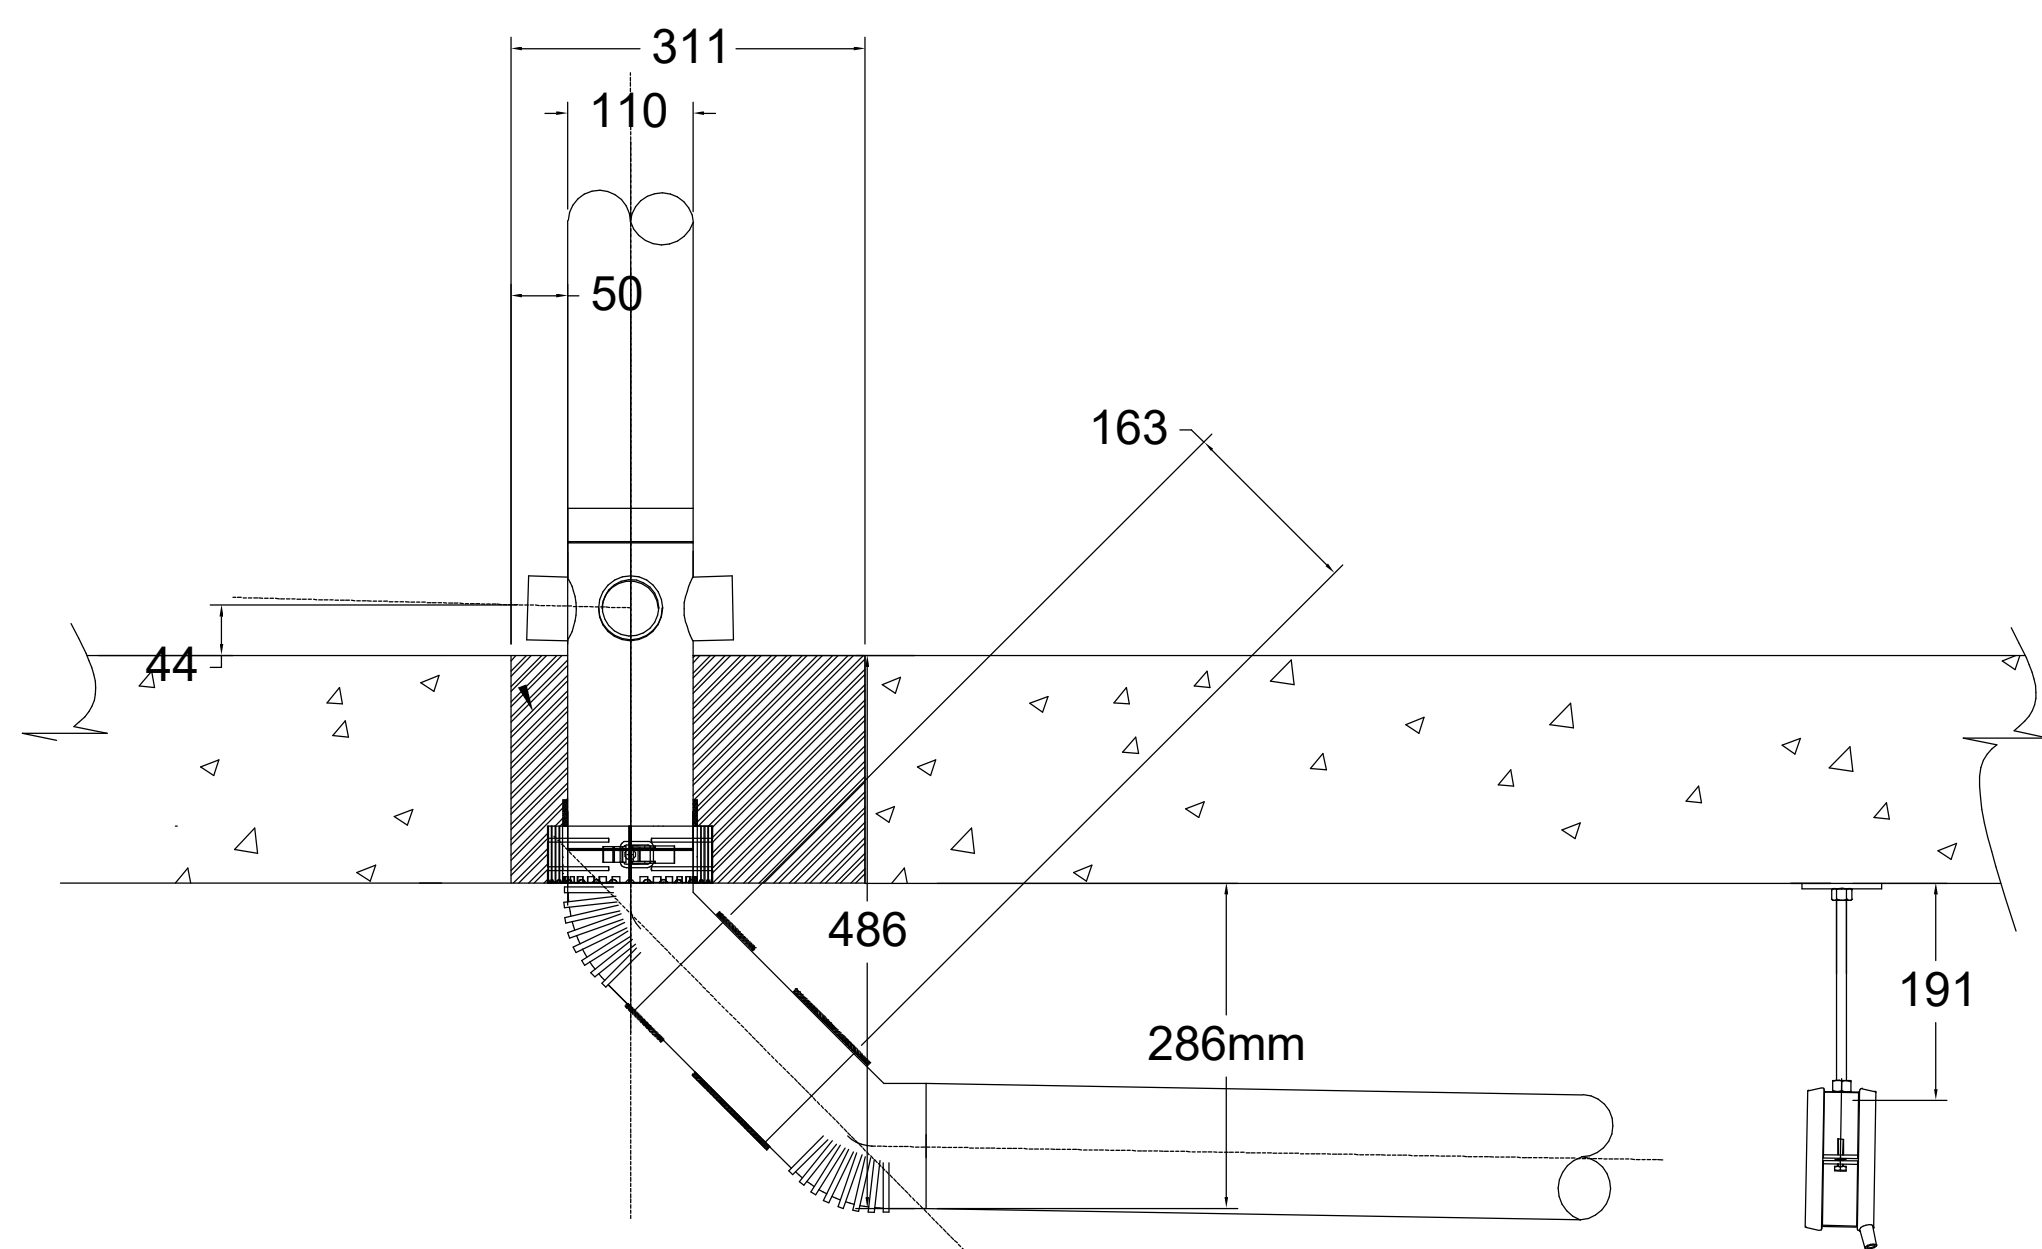


1 : 100

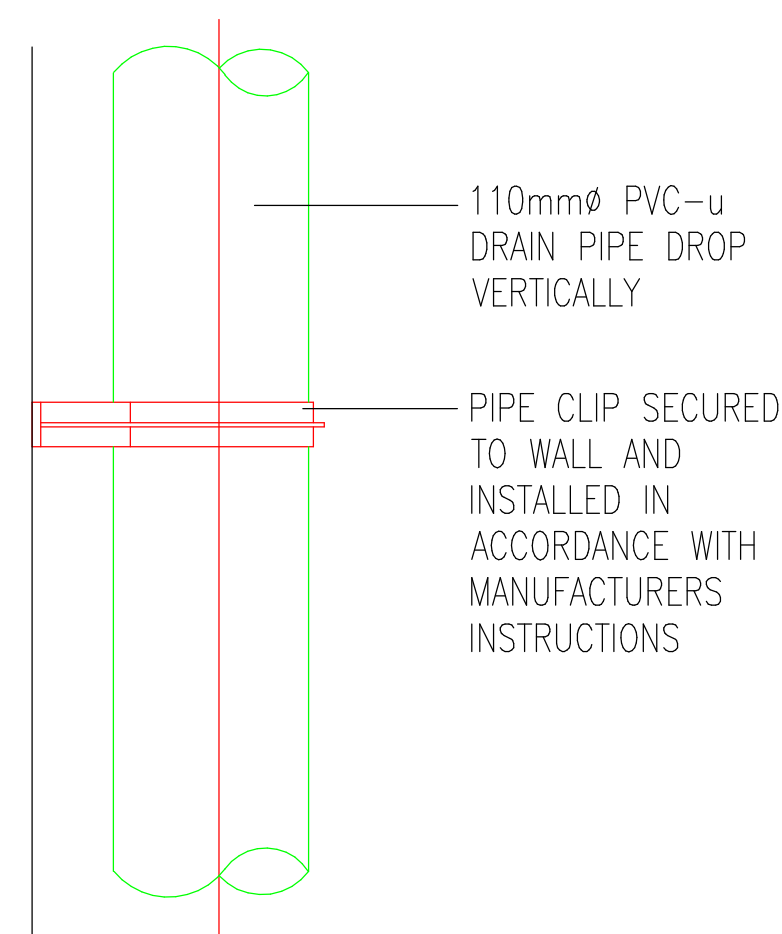


TYPICAL FIXING DETAIL – INTERMEDIATE PIPE CLIP

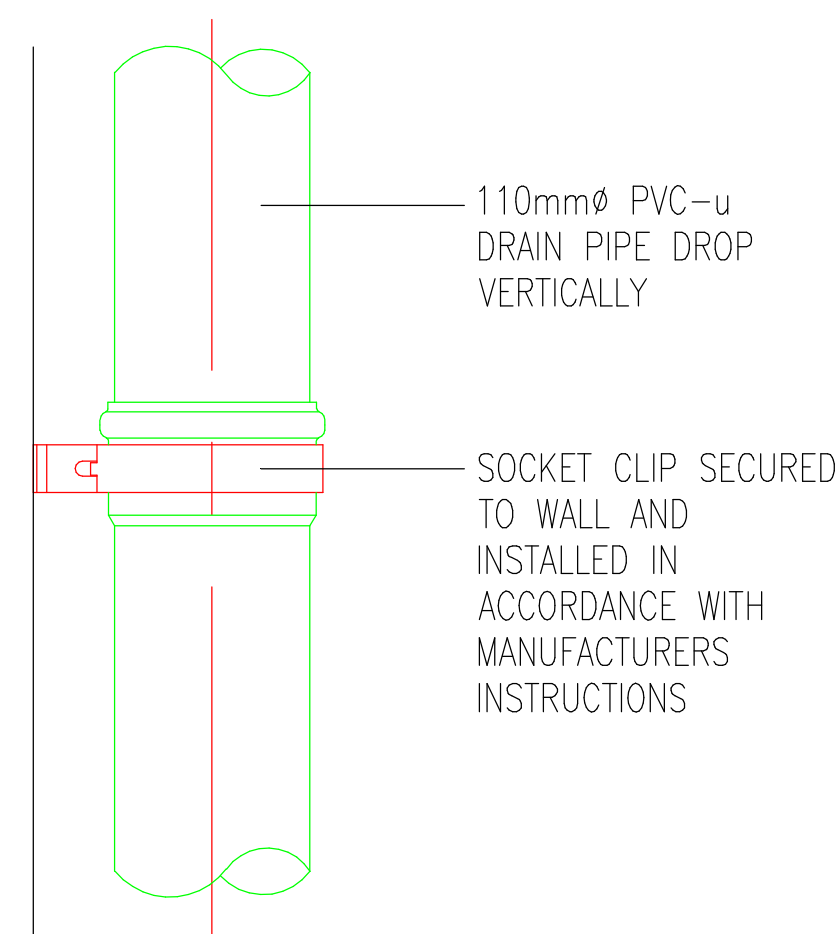

TYPICAL FIXING DETAIL – SOCKET PIPE CLIP

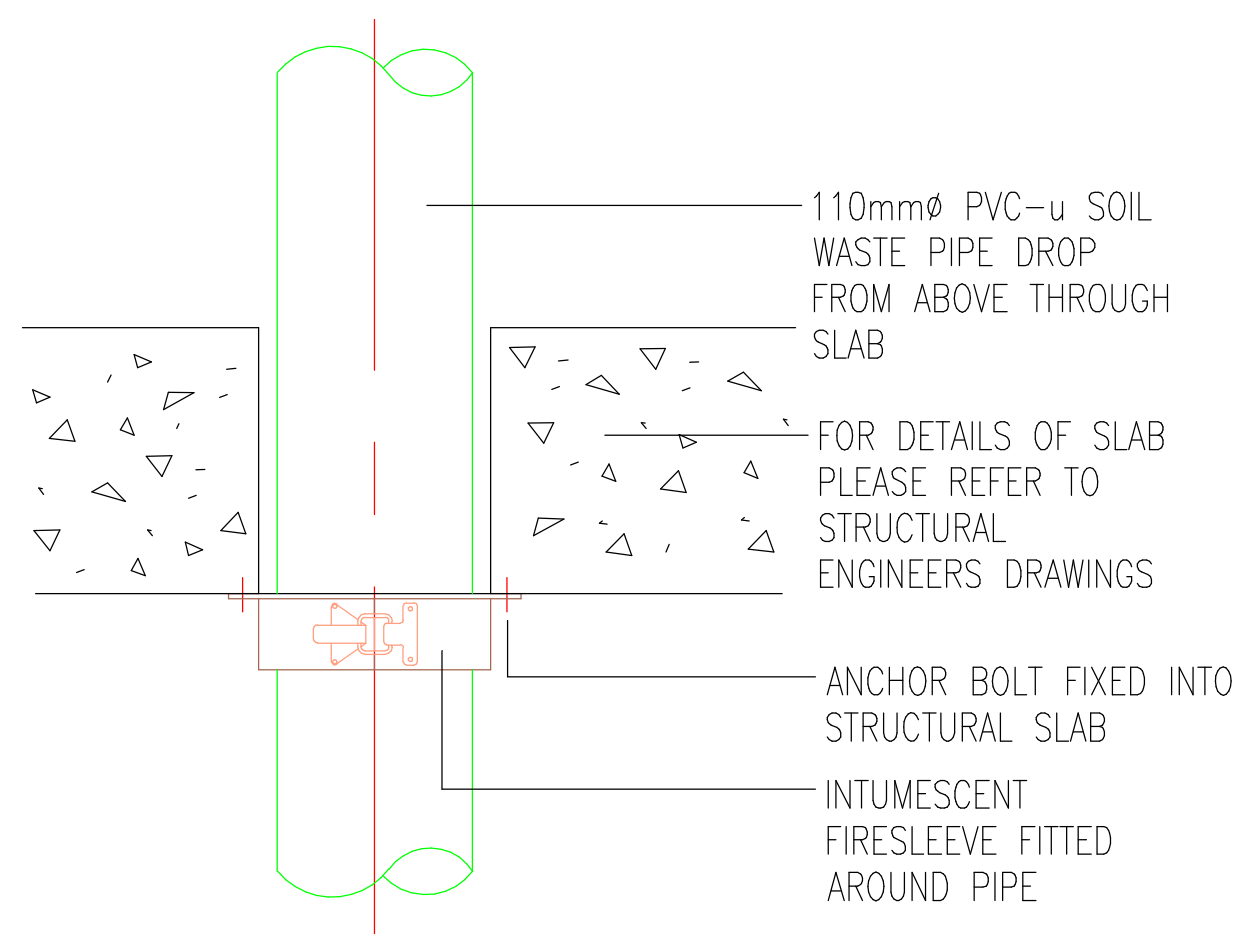

TYPICAL DETAIL FOR DRAIN PIPE PENETRATION THROUGH FIRE COMPARTMENT

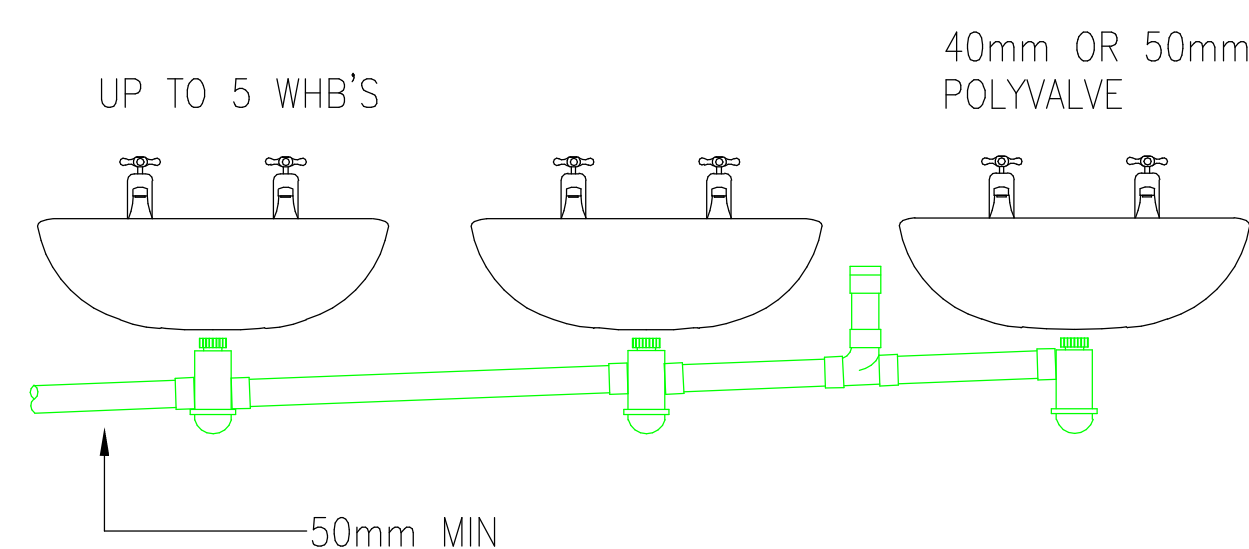

TYPICAL INSTALLATION OF WHB'S
TO PREVENT SIPHONAGE
(NOT TO SCALE)

ARCHITECTURE IS BASED ON ANOMALY DESIGN
CHITECTS DRAWING NO. SLH-JNO-PO-(6-DR-A-05105)C01
LEVEL 06 PLAN
RECEIVED 03.06.2024

DRAMA TENSE	
11	DRAWING TO BE READ IN CONJUNCTION WITH SPECIFICATIONS.
12	READ ALL REFERENCES TO THE DRAWING ORIGINATOR IMMEDIATELY.
13	ALL DIMS ARE IN UNLESS STATED OTHERWISE.
14	ALL DIMENSIONS MUST COMPLY WITH THE FOLLOWING REQUIREMENTS PART H.
15	ALL DIMENSIONS SHALL COMPLY WITH BS EN 12055 (SYSTEM II).
16	ALL FIBROGLASS WASTE PIPES TO HAVE 140 GRADE W/STAIN RESISTANT FINISH.
17	PREWORK MUST BE SUPPORTED W/ LINE WITH MINIMUM 100MM CLEARANCE.
18	ALL PREWORK TO BE SUBMITTED W/ PUSH/FIT TO FINAL DIMENSIONS FOR S&P.
19	INSTALLATION OF ALLOW FOR EXPANSION WITH SLP JOINTS TO SUIT.
20	ALL CONNECTIONS SHALL BE FITTED AT GRADE OR ABOVE LEVEL, AT THE END OF HORIZONTAL BRANCHES. ALL CONNECTIONS TO EVERY RUN ON STRAIGHT SECTIONS.
21	ALL CONNECTIONS SHALL HAVE JEWEL (STANDARD RODDING POINTS) ABOVE LEVEL TO SUIT.
22	ALL NEW VENT PIPE TERMINATIONS TO BE FITTED WITH AN ARCHITECTURAL FINISH.
23	ALL PENETRATIONS SHALL BE WEATHERED IN ACCORDANCE WITH THE ROOF SPECIALISTS REQUIREMENTS.
24	ALL CONNECTIONS CONNECTING TO A RUN WHICH DOES NOT CONNECT TO A VENT PIPE MUST USE ANTSYPHON TRAP.
25	PLASTIC PIPES PENETRATING A FIRE COMPARTMENT SHALL BE PENETRATED WITH A FIRE RATED PENETRATOR SHALL BE FITTED WITH A (STANDARD) INSTALLABLE FIRE COLLAR.
26	ALL PIPES TO BE LONG RUND SWIPT BENDS. BEADLYS USING 1/2" SIDS TO FORM A BEND. USE OF BENDS SHALL BE MINIMISED.
27	ALL DRAINAGE PIPES PASSING THROUGH ROOF SHALL BE PENETRATED WITH A FIRE RATED PENETRATOR.
28	ALL EXPOSED DRAINAGE PIPES TO BE WHITE IN COLOR. HEPD WASTELINE TRAPS SHALL BE INSTALLED ON ALL HORIZONTAL CONNECTIONS.
29	ALL FLOOR GULLIES SHALL BE PROVIDED AS PART OF THE UNDERFLOOR DRAINAGE DROCKERS LOCATION SHOWN FOR INFORMATION ONLY.
30	KITCHENETTE AREA TERMINATION POINTS TO BE AGREED WITH THE CLIENT.

P03	27.08.24	ALL EXISTING STACKS REPLACED WITH NEW, DRAINAGE ROUTES THROUGH L04 & L05 RATIONALISED.	DB	SH
P02	27.08.24	DRAINAGE PIPES ROUTED IN PARTITIONS AS REQUESTED AND MAIN EXISTING STACKS DETAILD AT 6"	DB	SH
P01	13.06.24	ISSUED FOR COMMENT & APPROVAL	DB	SH
REV	DATE	AMENDMENTS	BY	CHKD

**FOR COMMENT
& APPROVAL**

Commercial Services Design Ltd
Unit 5
Woodside Court
Clayton Wood Rise
Leeds
LS18 8RF
Tel: 0113 3223190
Web: www.csdesign.uk.com



G&H
GROUP OF COMPANIES

CLIENT		G&H BUILDING SERVICES	
PROJECT			
SUNLIGHT HOUSE LITTLE QUAY STREET MANCHESTER M3 3HP			
TITLE			
MECHANICAL SERVICES ABOVE GROUND DRAINAGE LAYOUT LEVEL 05			
SCALE 1/4" = 1'-0"		CSD REF	CSD 1298
DRAWN: MMW		ENGINEER:	DB
STARTED: JUNE 24		ISSUED:	AUGUST 24
CHECKED: DB		APPROVED:	BW
DRAWING NO.			REV.
1298-CSD-VX-05-DR-M-5206			P03
Project Originator: JAMES WINE DESIGN/Consultant/Supplier			