

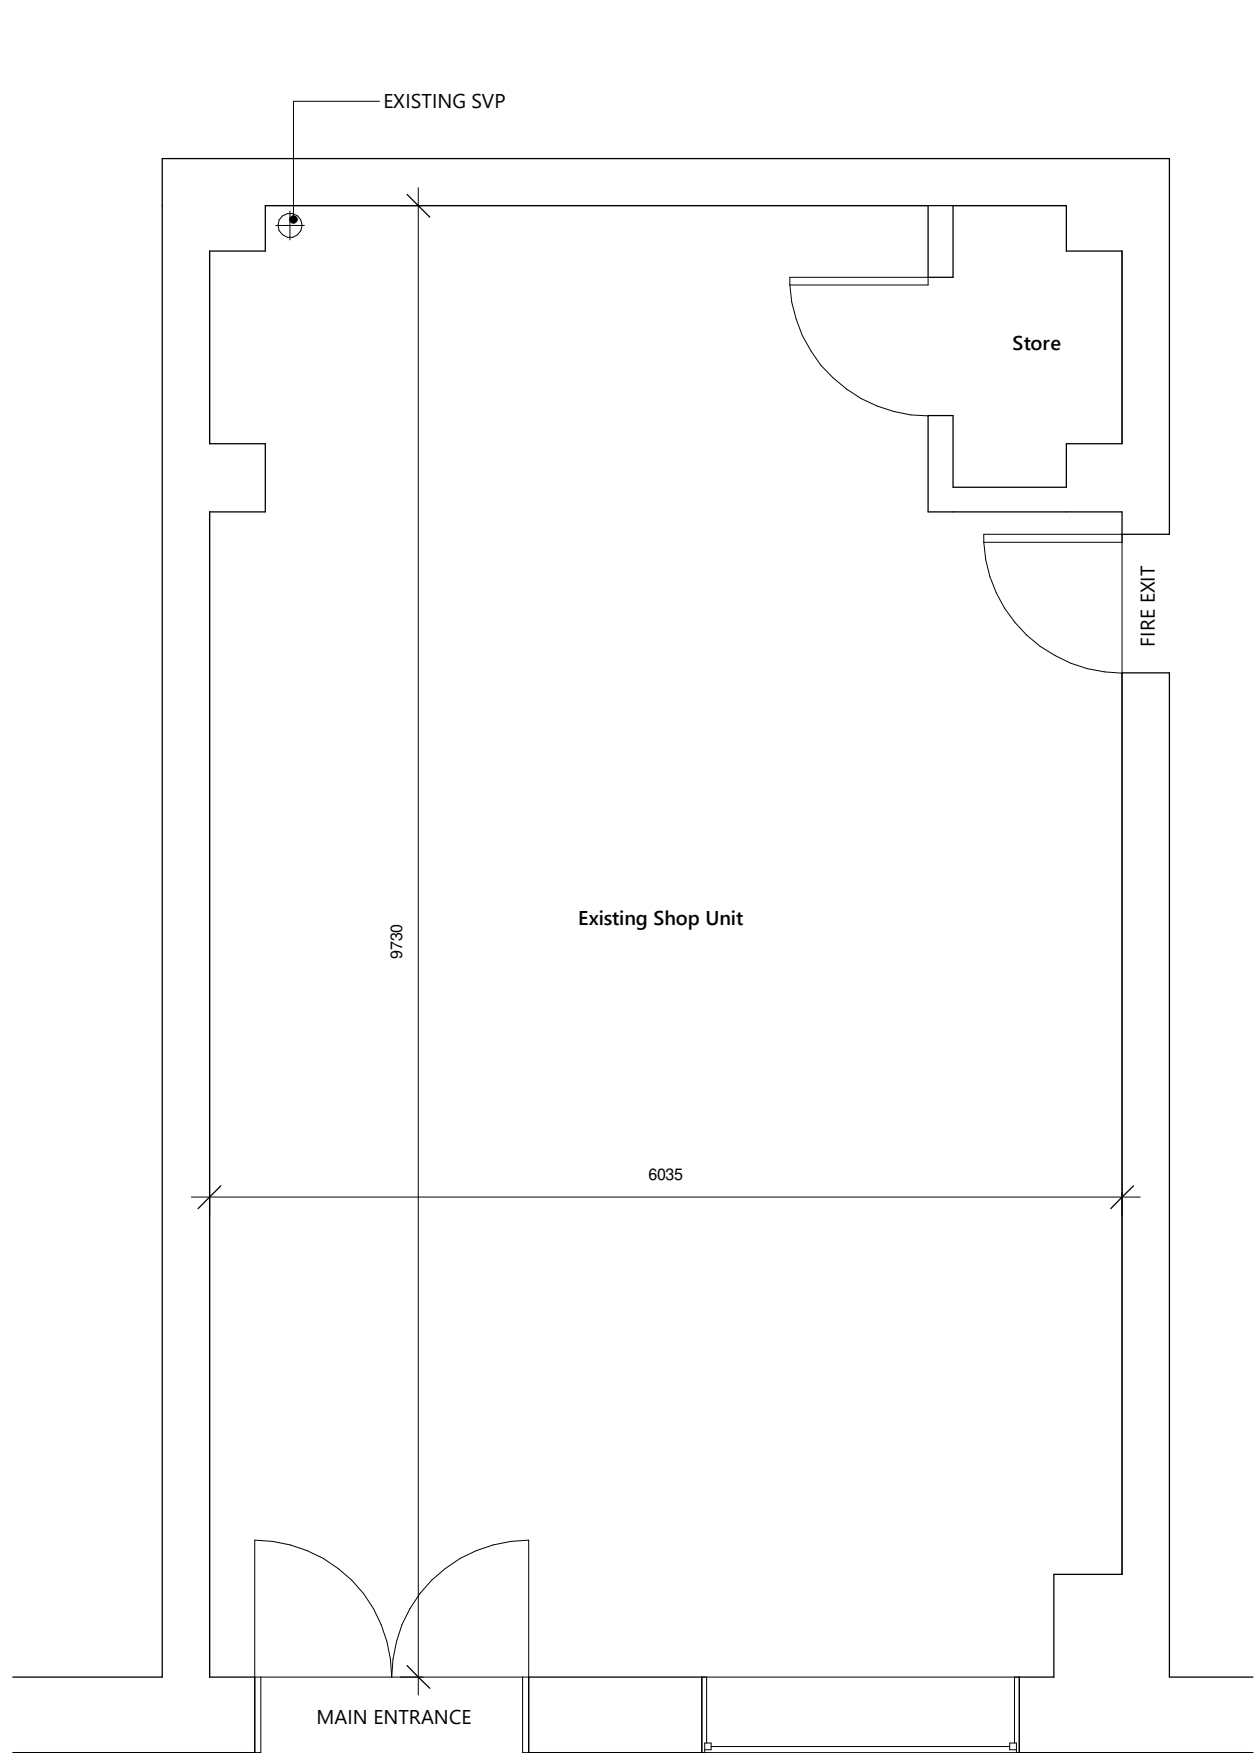


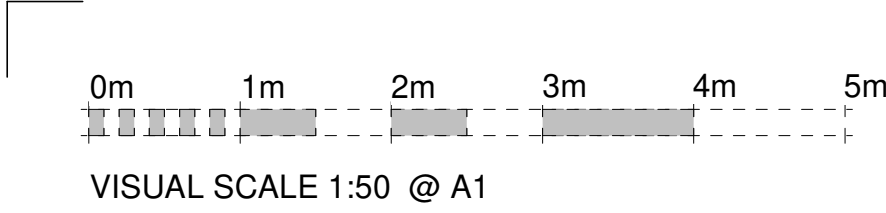

1 EXISTING FLOOR PLAN
1 : 50

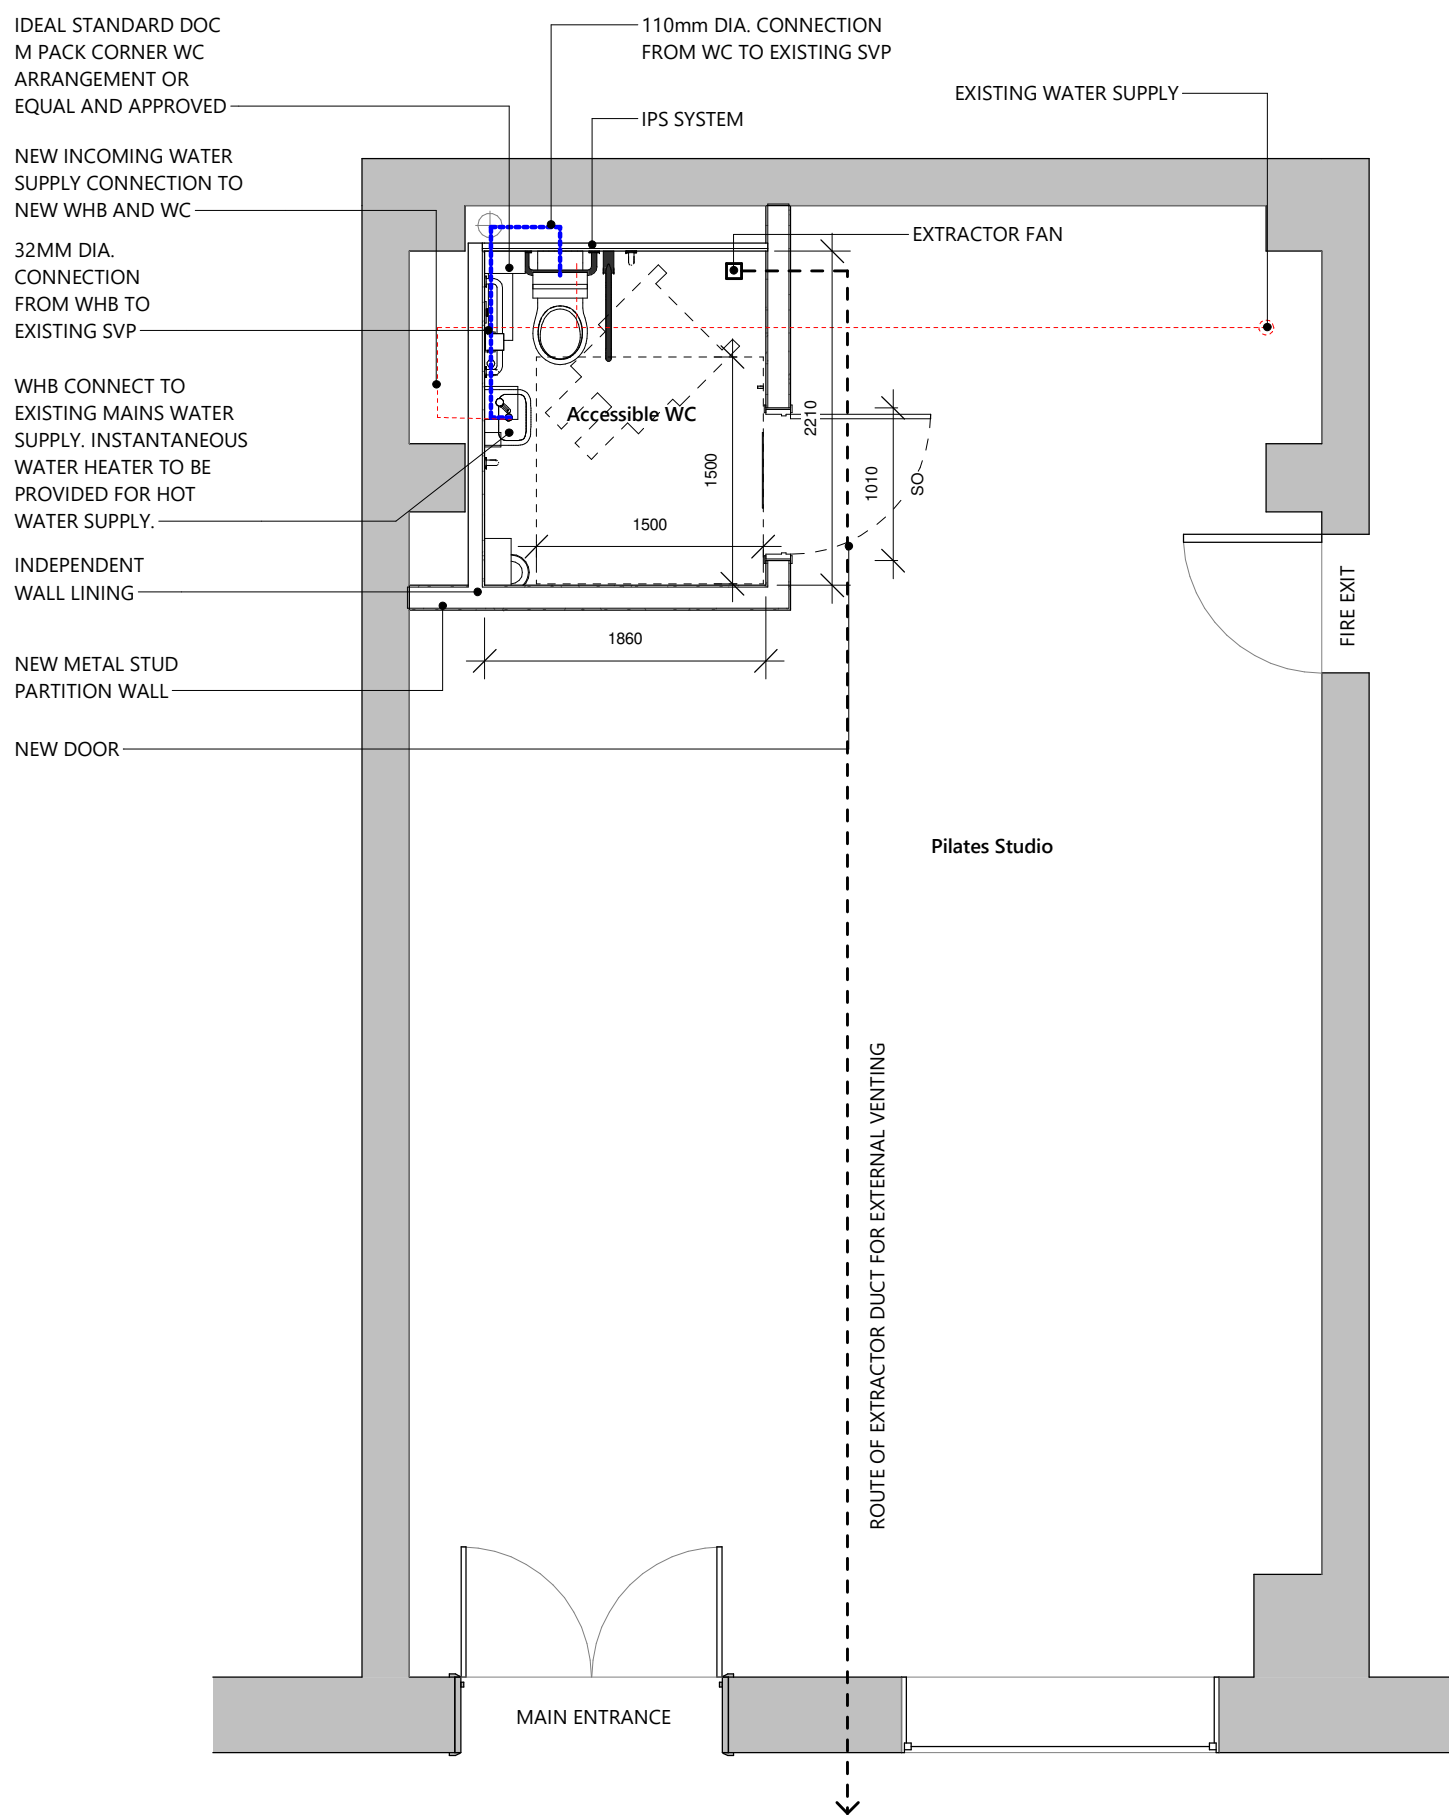

2 PROPOSED FLOOR PLAN
1 : 50

NOTES:				
Copyright DO NOT SCALE: Use figured dimensions only. All dimensions on this drawing is given with good faith and believed to be correct. IF IN DOUBT ASK. The author accepts responsibility for this document only to the commissioning party and not to any other. The author does not accept liability for accuracy or veracity of survey information provided by others and used in the preparation of this drawing. All dimensions and levels provided by others must be checked and verified on site before commencement of works.				
WALL REMOVALS SHOWN ARE ASSUMED TO BE NON-LOAD BEARING. CONTRACTOR MUST CHECK ASSUMED NON-LOAD BEARING WALLS ON SITE PRIOR TO REMOVALS AND REPORT ON FINDINGS BEFORE COMMENCEMENT OF WORKS. FOR LINTEL DETAILS REFER TO SE DRAWINGS AND DETAILS.				
ELECTRIC SOCKETS TO BE POSITIONED 300MM FROM ANY INTERNAL CORNER AND NOT MORE THAN 450MM ABOVE FINISHED FLOOR LEVEL. LIGHT SWITCHES TO BE POSITIONED BETWEEN 900MM AND 1100MM ABOVE FINISHED FLOOR LEVEL. CARBON MONOXIDE DETECTORS SHOULD COMPLY WITH BS EN 50291-1:2010 AND BE POWERED BY A BATTERY DESIGNED TO OPERATE FOR THE WORKING LIFE OF THE DETECTOR. THE DETECTOR SHOULD INCORPORATE A WARNING DEVICE TO ALERT THE USERS WHEN ITS WORKING LIFE IS DUE TO EXPIRE. HARD WIRED MAINS OPERATED CARBON MONOXIDE DETECTORS COMPLYING WITH BS EN 50291-1:2010 (TYPE A) WITH FIXED WIRING (NOT PLUG IN TYPES) MAY BE USED AS AN ALTERNATIVE, PROVIDED THEY ARE FITTED WITH A SENSOR FAILURE WARNING DEVICE. ALL ELECTRICAL INSTALLATIONS TO COMPLY WITH BS 7671:2008				
A	First Issue	YZ	01.07.24	
Rev	Revision Description	Drawn	Date	
Client -				
Project LC CIRCLE SQUARE, MANCHESTER				
Title EXISTING & PROPOSED PLANS				
Scale @ A1 1 : 50	Drawn By yz	Date 04.07.24		
Sheet No. A100			Rev. A	