


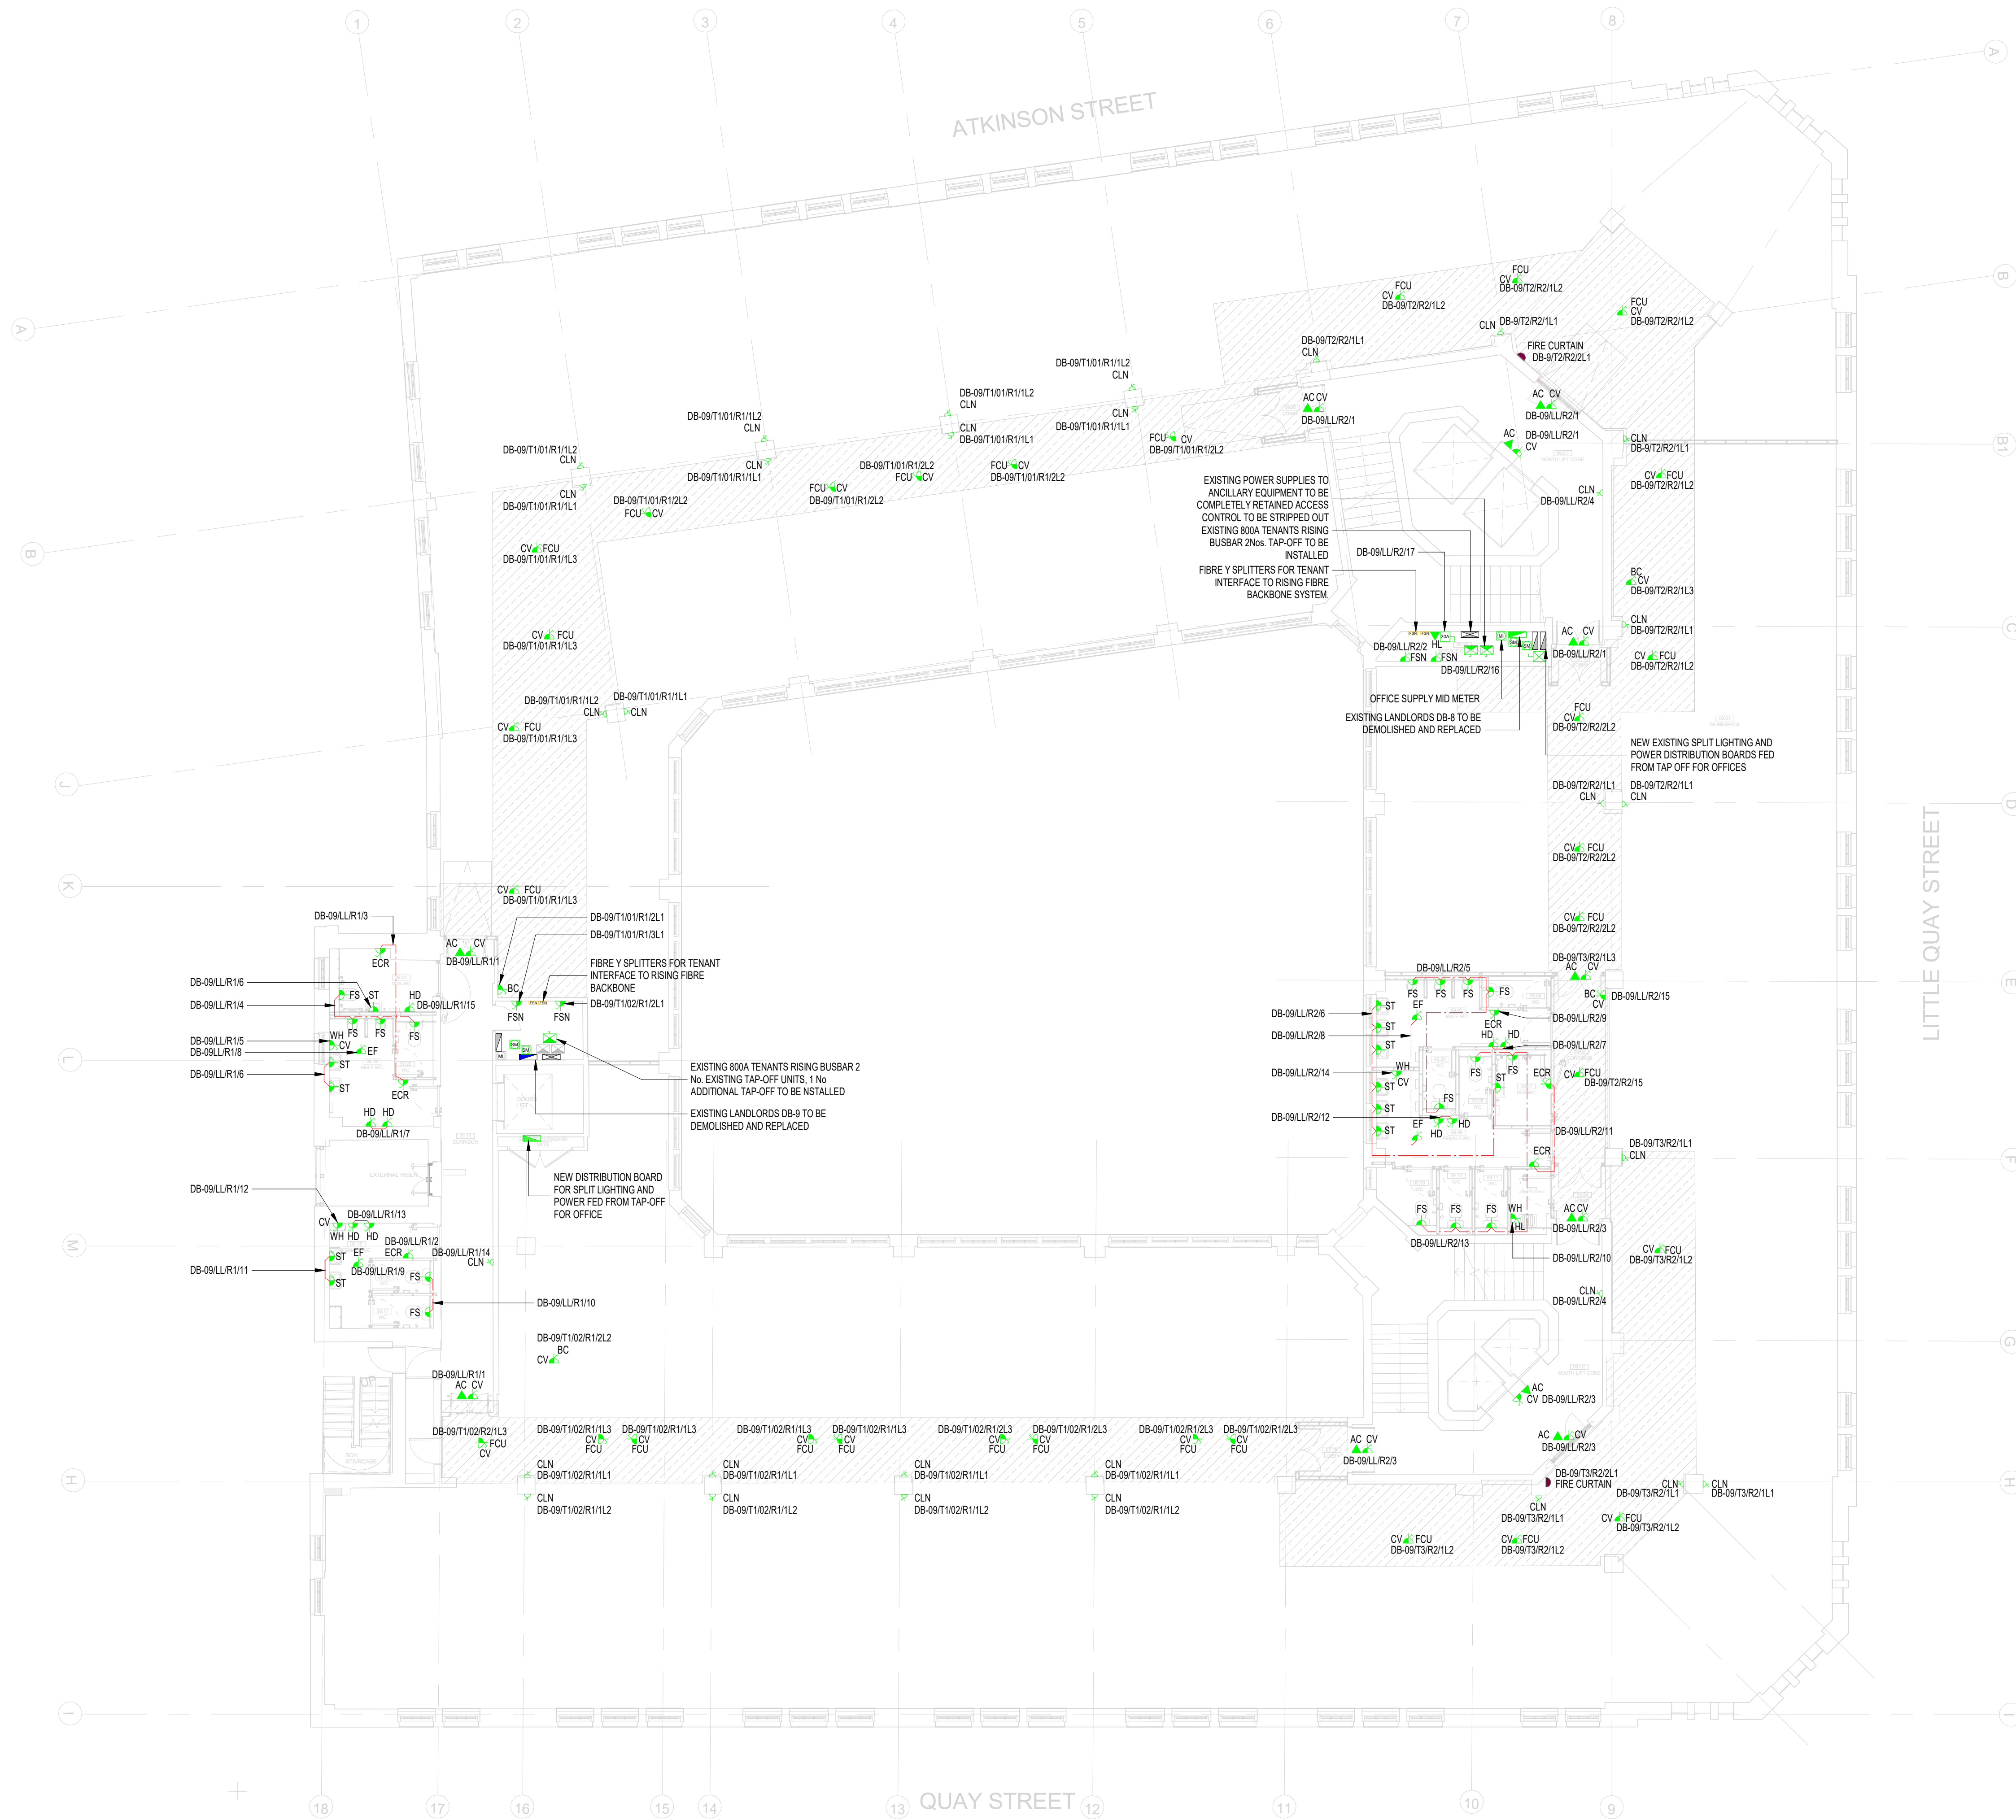

ABBREVIATIONS:

HD	HAND DRYER
EF	EXTRACT FAN
CV	CEILING VOID
EPH	ELECTRIC PANEL HEATER
ST	SENSOR TRAP
CLN	CLEANERS SOCKET
FS	FLOW SWITCH
FCU	FAN COIL UNIT
AC	ACCESS CONTROL
ECR	ELECTRIC CONTROL RADIATOR
WH	WATER HEATER
DP	DRAIN PUMP
LL	MOUNTED AT LOW LEVEL
ML	MOUNTED AT MID LEVEL
HL	MOUNTED AT HIGH LEVEL
DAS	DISABLE ALARM SYSTEM
EAC	ELECTRIC AIR CURTAIN
HT	HOT WATER TAP
FSN	FIBRE SPLITTER NODE
BC	BRANCH CONTROLLER
FR	FRIDGE
MW	MICROWAVE
WT	WORK TOP (FOR KITCHENETTES)
BWT	BELOW WORK TOP (FOR KITCHENETTES)
DW	DISH WASHER

THIS DRAWING IS FOR INFORMATION ONLY DO NOT SCALE

CDM REGULATIONS

NUMBER	DATE ISSUED	DATE INITIATED	DATE ASSESSMENT

LEGEND:

- SPAN DISTRIBUTION BOARD
- TPAN DISTRIBUTION BOARD
- MAIN SWITCH BOARD/OLY PANEL
- UNSWITCHED 13A SINGLE SOCKET OUTLET
- SWITCHED 13A SINGLE SOCKET OUTLET
- TWIN 13A SWITCHED SOCKET OUTLET
- UNSWITCHED FUSED CONNECTION UNIT
- SWITCHED FUSED CONNECTION UNIT
- RED DP 13A FUSED CONNECTION UNIT
- COMMAND SOCKET
- DOUBLE POLE ISOLATING SWITCH (20A)
- THREE POLE ISOLATING SWITCH
- 3 POLE ISOLATOR
- TPAN ISOLATOR
- RJ45 DATA OUTLET POINT
- TELEPHONE OUTLET POINT
- COOKER CONNECTION UNIT
- AUDIOVISUAL PLATE
- DADO TRUNKING
- HDMI PORT
- DADO DROPPERS
- EMERGENCY STOP BUTTON
- 13A TWIN SWITCHED SOCKET & 2x 13A DATA OUTLETS (2 COMPARTMENT FLOORBOX)
- DISABLED ALARM PULL CORO SWITCH
- RESET PUSH BUTTON
- DISABLED ALARM INDICATOR LAMP
- 3 COMPARTMENT DADO DROPPER
| DADO DROPPERS | DISTRIBUTION UNIT BOX | CLEANERS SOCKET FLOOR GORMET | SOCKET & 2x 13A DATA OUTLETS (4 COMPARTMENT FLOORBOX) |
| UNSWITCHED FUSE SPUR FOR FIRE CURTAIN | CLG-131 SUSPENDED PLASTERBOARD | CLG-131 SUSPENDED PLASTERBOARD | CLG-131 SUSPENDED PLASTERBOARD |
| 63A UNDERFLOOR BUS BAR POWER TRACK | FIBRE SPLITTER NODE | SMART METER | MID METER |
| WIFI AP | BOOSTER PUMP | INVERTER | |

REV 28.08.24 ISSUED FOR COMMENT & APPROVAL

DATE AMENDMENTS BY CRO

FOR COMMENT & APPROVAL

Commercial Services Design Ltd
Unit 5
Woodside Court
Clayton Wood Rise
Leeds LS15 8HF
Tel: 0113 3223190
Web: www.csdesign.uk.com

G&H
GROUP OF COMPANIES

G&H BUILDING SERVICES

SUNLIGHT HOUSE
LITTLE QUAY STREET
MANCHESTER M3 3HP

ELECTRICAL SERVICES SMALL POWER AND DATA LAYOUT
LEVEL 09

SCALE 1:100

DATE 24 JUN 24

DATE 24 AUG 24

DATE 24 AUG 24

1298-CSD-XX-09-DR-E-6210

P01

ARCHITECTURE IS BASED ON ANIMALLY DESIGN
ARCHITECTS DRAWING NO. SJ-HAND-PO-09-DR-A-00100
(001) LEVEL 09 PLAN
REV 28.08.24