


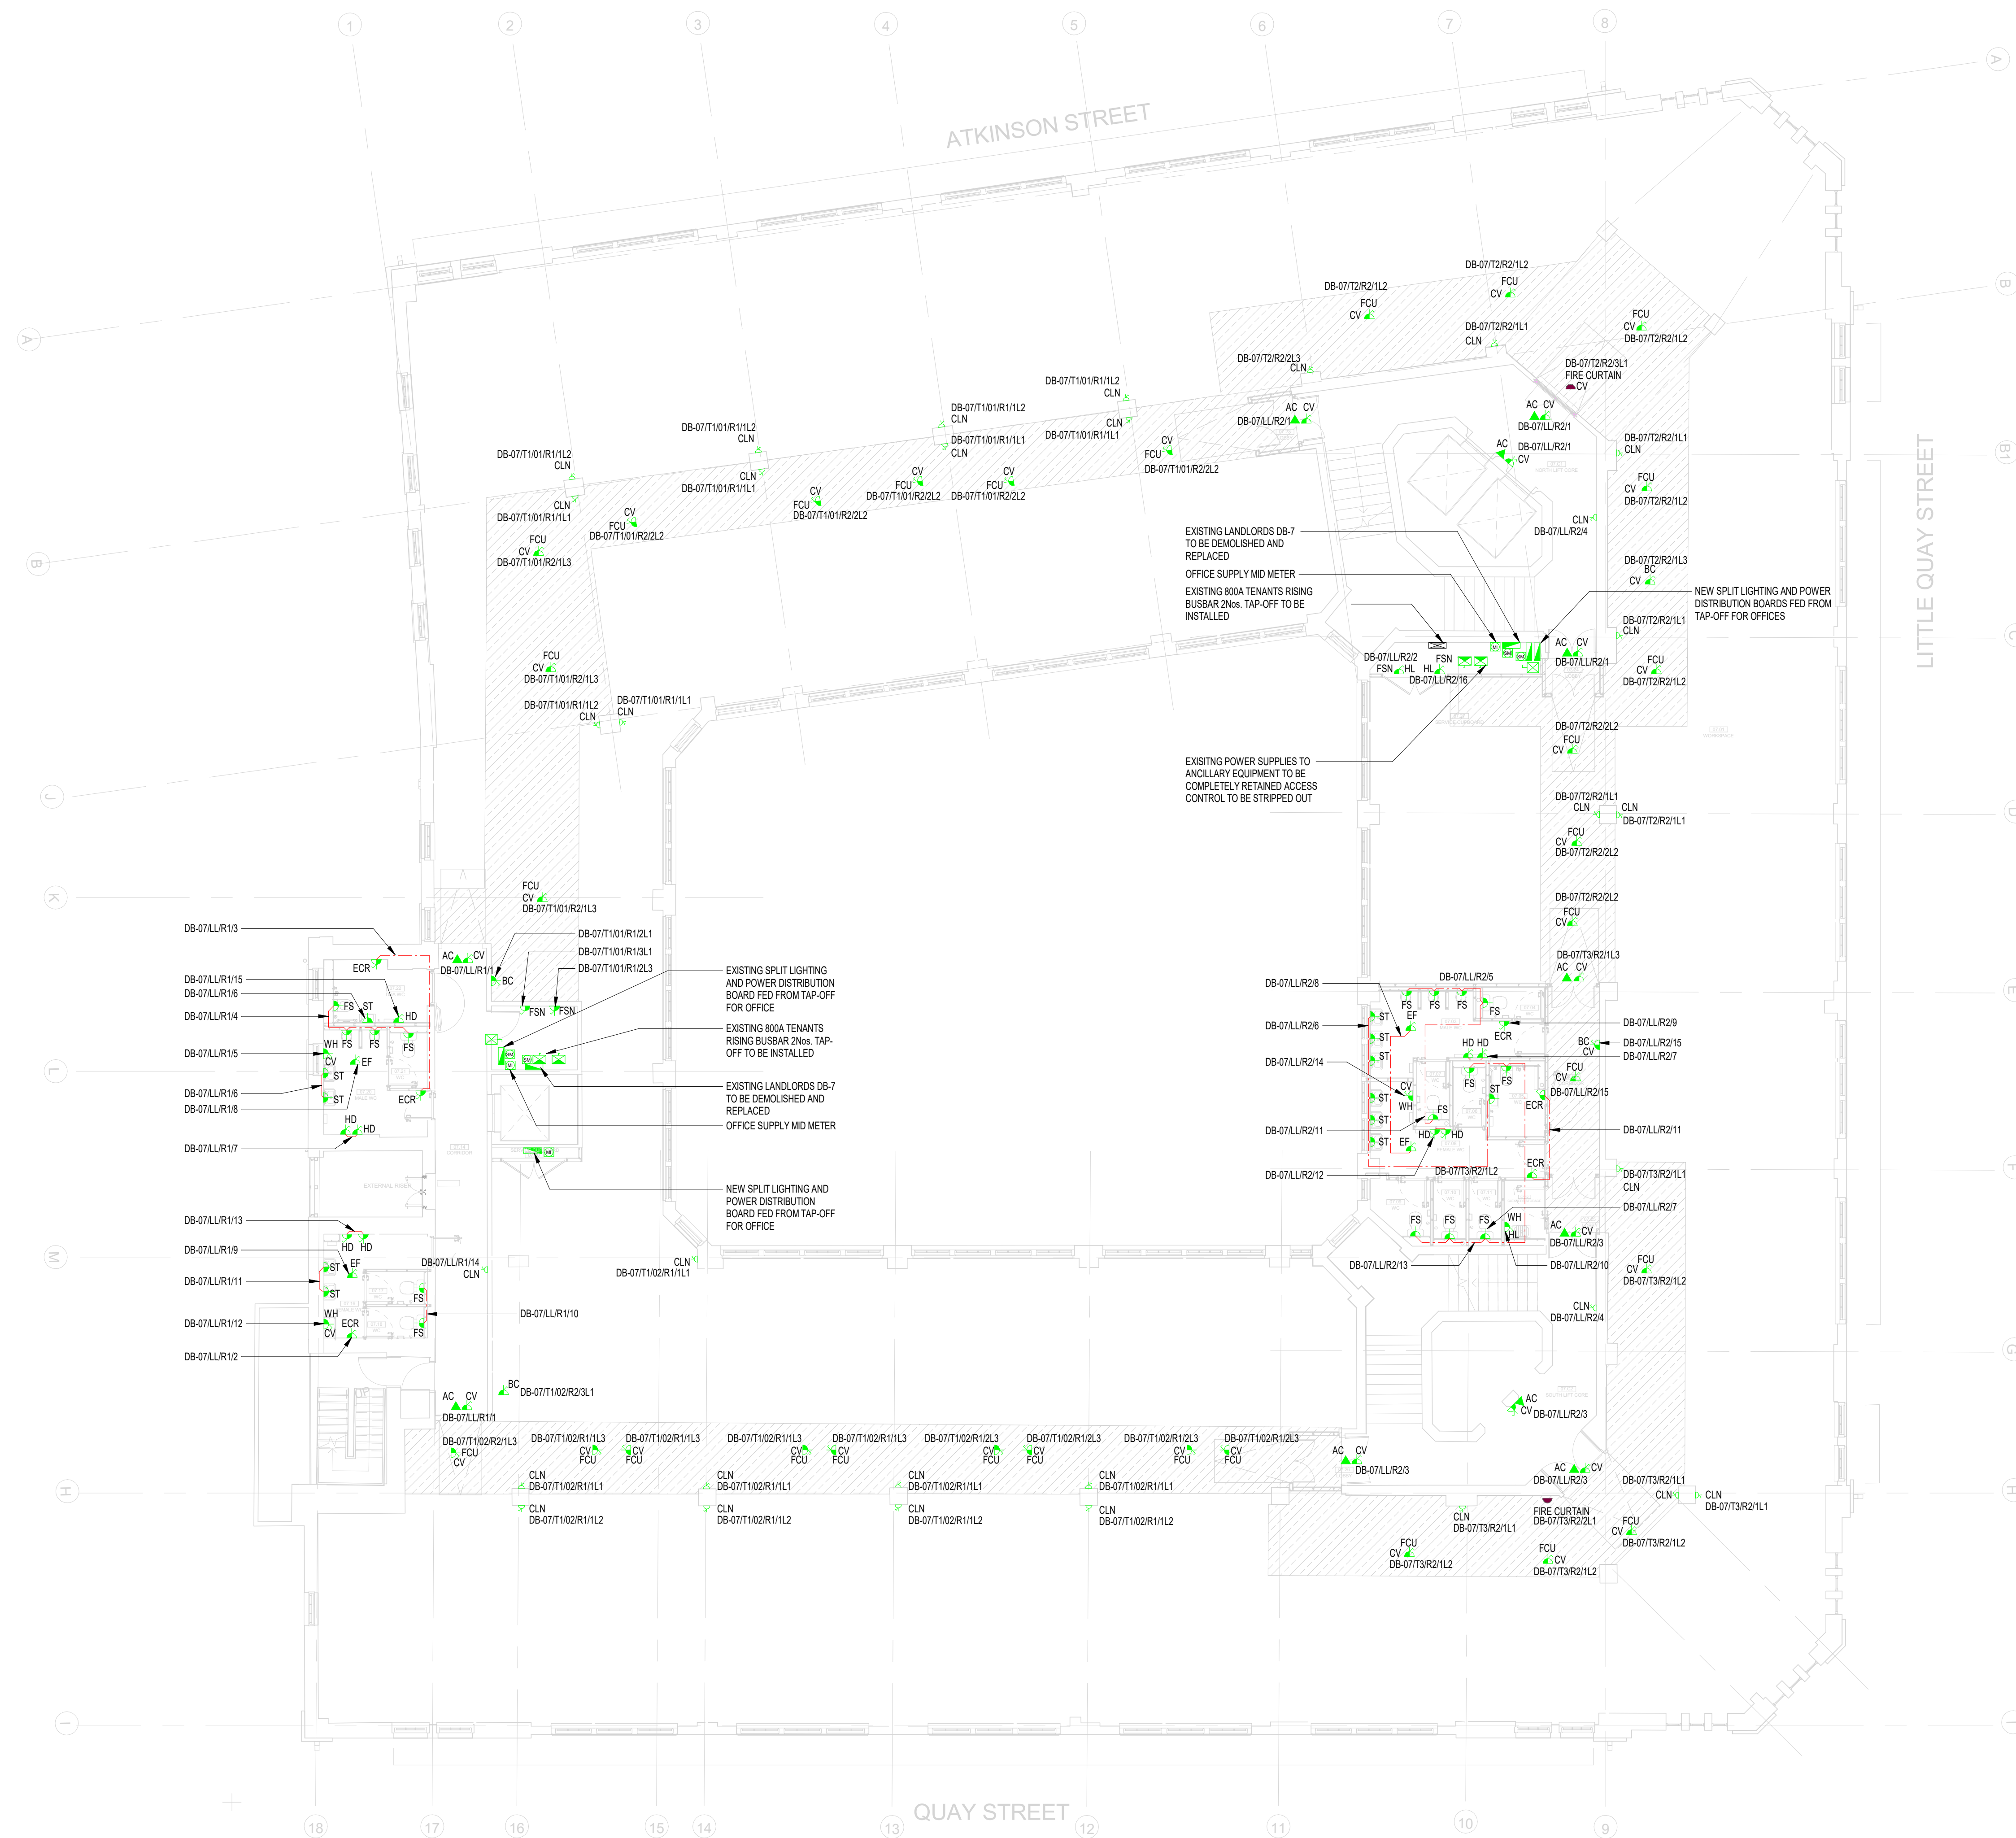

ABBREVIATIONS:

HD	HAND DRYER
EF	EXTRACT FAN
CV	CEILING VOID
EPH	ELECTRIC PANEL HEATER
ST	SENSOR TRAP
CLN	CLEANERS SOCKET
FS	FLOW SWITCH
FCU	FAN COIL UNIT
AC	ACCESS CONTROL
ECR	ELECTRIC CONTROL RADIATOR
WH	WATER HEATER
DP	DRAIN PUMP
LL	MOUNTED AT LOW LEVEL
HL	MOUNTED AT HIGH LEVEL
DAS	DISABLE ALARM SYSTEM
EAC	ELECTRIC AIR CURTAIN
HT	HOT WATER TAP
FSN	FIBRE SPLITTER NODE

THIS DRAWING IS FOR INFORMATION ONLY DO NOT SCALE

CDM REGULATIONS

HAZARD	DATE ASSESSED	DATE INITIATED	DATE ASSESSMENT

LEGEND

- SPIN DISTRIBUTION BOARD
- TPAN DISTRIBUTION BOARD
- MAIN SWITCH BOARD/DPV PANEL
- UNSWITCHED 13A SINGLE SOCKET OUTLET
- SWITCHED 13A SINGLE SOCKET OUTLET
- SWITCHED 13A SINGLE SOCKET OUTLET - CLN DENOTES CLEANERS SOCKET
- TWIN 13A SWITCHED SOCKET OUTLET
- UNSWITCHED FUSED CONNECTION UNIT
- SWITCHED FUSED CONNECTION UNIT
- SWITCHED FUSED CONNECTION UNIT w/ NEON INDICATOR
- RED DP 13A FUSED CONNECTION UNIT w/ NEON INDICATOR & BARREL LOCK
- COMMANDO SOCKET
- DOUBLE POLE ISOLATING SWITCH (20A)
- THREE POLE ISOLATING SWITCH
- 3 POLE ISOLATOR
- SPIN ISOLATOR
- TPAN ISOLATOR
- RJ45 DATA OUTLET POINT
- TELEPHONE OUTLET POINT
- COOKER CONNECTION UNIT
- AUDIOVISUAL PLATE
- DADO TRUNKING
- HDMI PORT
- DADO DROPPERS
- EMERGENCY STOP BUTTON
- 1 No. TWIN SWITCHED SOCKET & 2 No. DATA OUTLETS (2 COMPARTMENT FLOORBOX)
- DISABLED ALARM PULL CORD SWITCH w/ INTEGRAL REASSURANCE LAMP
- RESET PUSH BUTTON
- DISABLED ALARM INDICATOR LAMP w/ INTEGRAL SOUNDER
- 3 COMPARTMENT DADO DROPPER
- DISTRIBUTION UNIT BOX
- CLEANERS SOCKET FLOOR GORMET
- SOCKET & 2No. DATA OUTLETS (4 COMPARTMENT FLOORBOX)
- UNSWITCHED FUSE SPUR FOR FIRE CURTAIN (N COMPLIANCE WITH BS28)
- CLG-131 SUSPENDED PLASTERBOARD BULKHEAD FINISHED IN PINT-101, INCLUDE CLG-811 ACCESS PANELS
- UNDERFLOOR BUS BAR POWER TRACK

REV	DATE	AMENDMENTS	BY	CHK
001	14.08.24	ISSUED FOR COMMENT & APPROVAL	SB	SH

FOR COMMENT & APPROVAL

Commercial Services Design Ltd
Unit 5
Woodside Court
Clayton Wood Rise
Little Hulton
Leeds LS18 5HP
Tel: 0113 3223190
Web: www.csdesign.uk.com

G&H
GROUP OF COMPANIES

CLIENT
G&H BUILDING SERVICES

PROJECT
**SUNLIGHT HOUSE
LITTLE QUAY STREET
MANCHESTER M3 3HP**

TITLE
**ELECTRICAL SERVICES SMALL POWER AND DATA LAYOUT
LEVEL 07**

SCALE @ A1: 1:100

CD REF: CSD 1298

DRAWN: MW

ENGINEER: DB

ISSUED: JUNE 24

ISSUED: AUGUST 24

REVISION: DB

APPROVED: BW

1298-CSD-XX-07-DR-E-6208

P01

ARCHITECTURE IS BASED ON ANIMALLY DESIGN
ARCHITECTS DRAWING NO. SJ-HAND-PO-OUT-DR-AUG-2024
(001) LEVEL 07 PLAN
REVISED 01.08.2024