


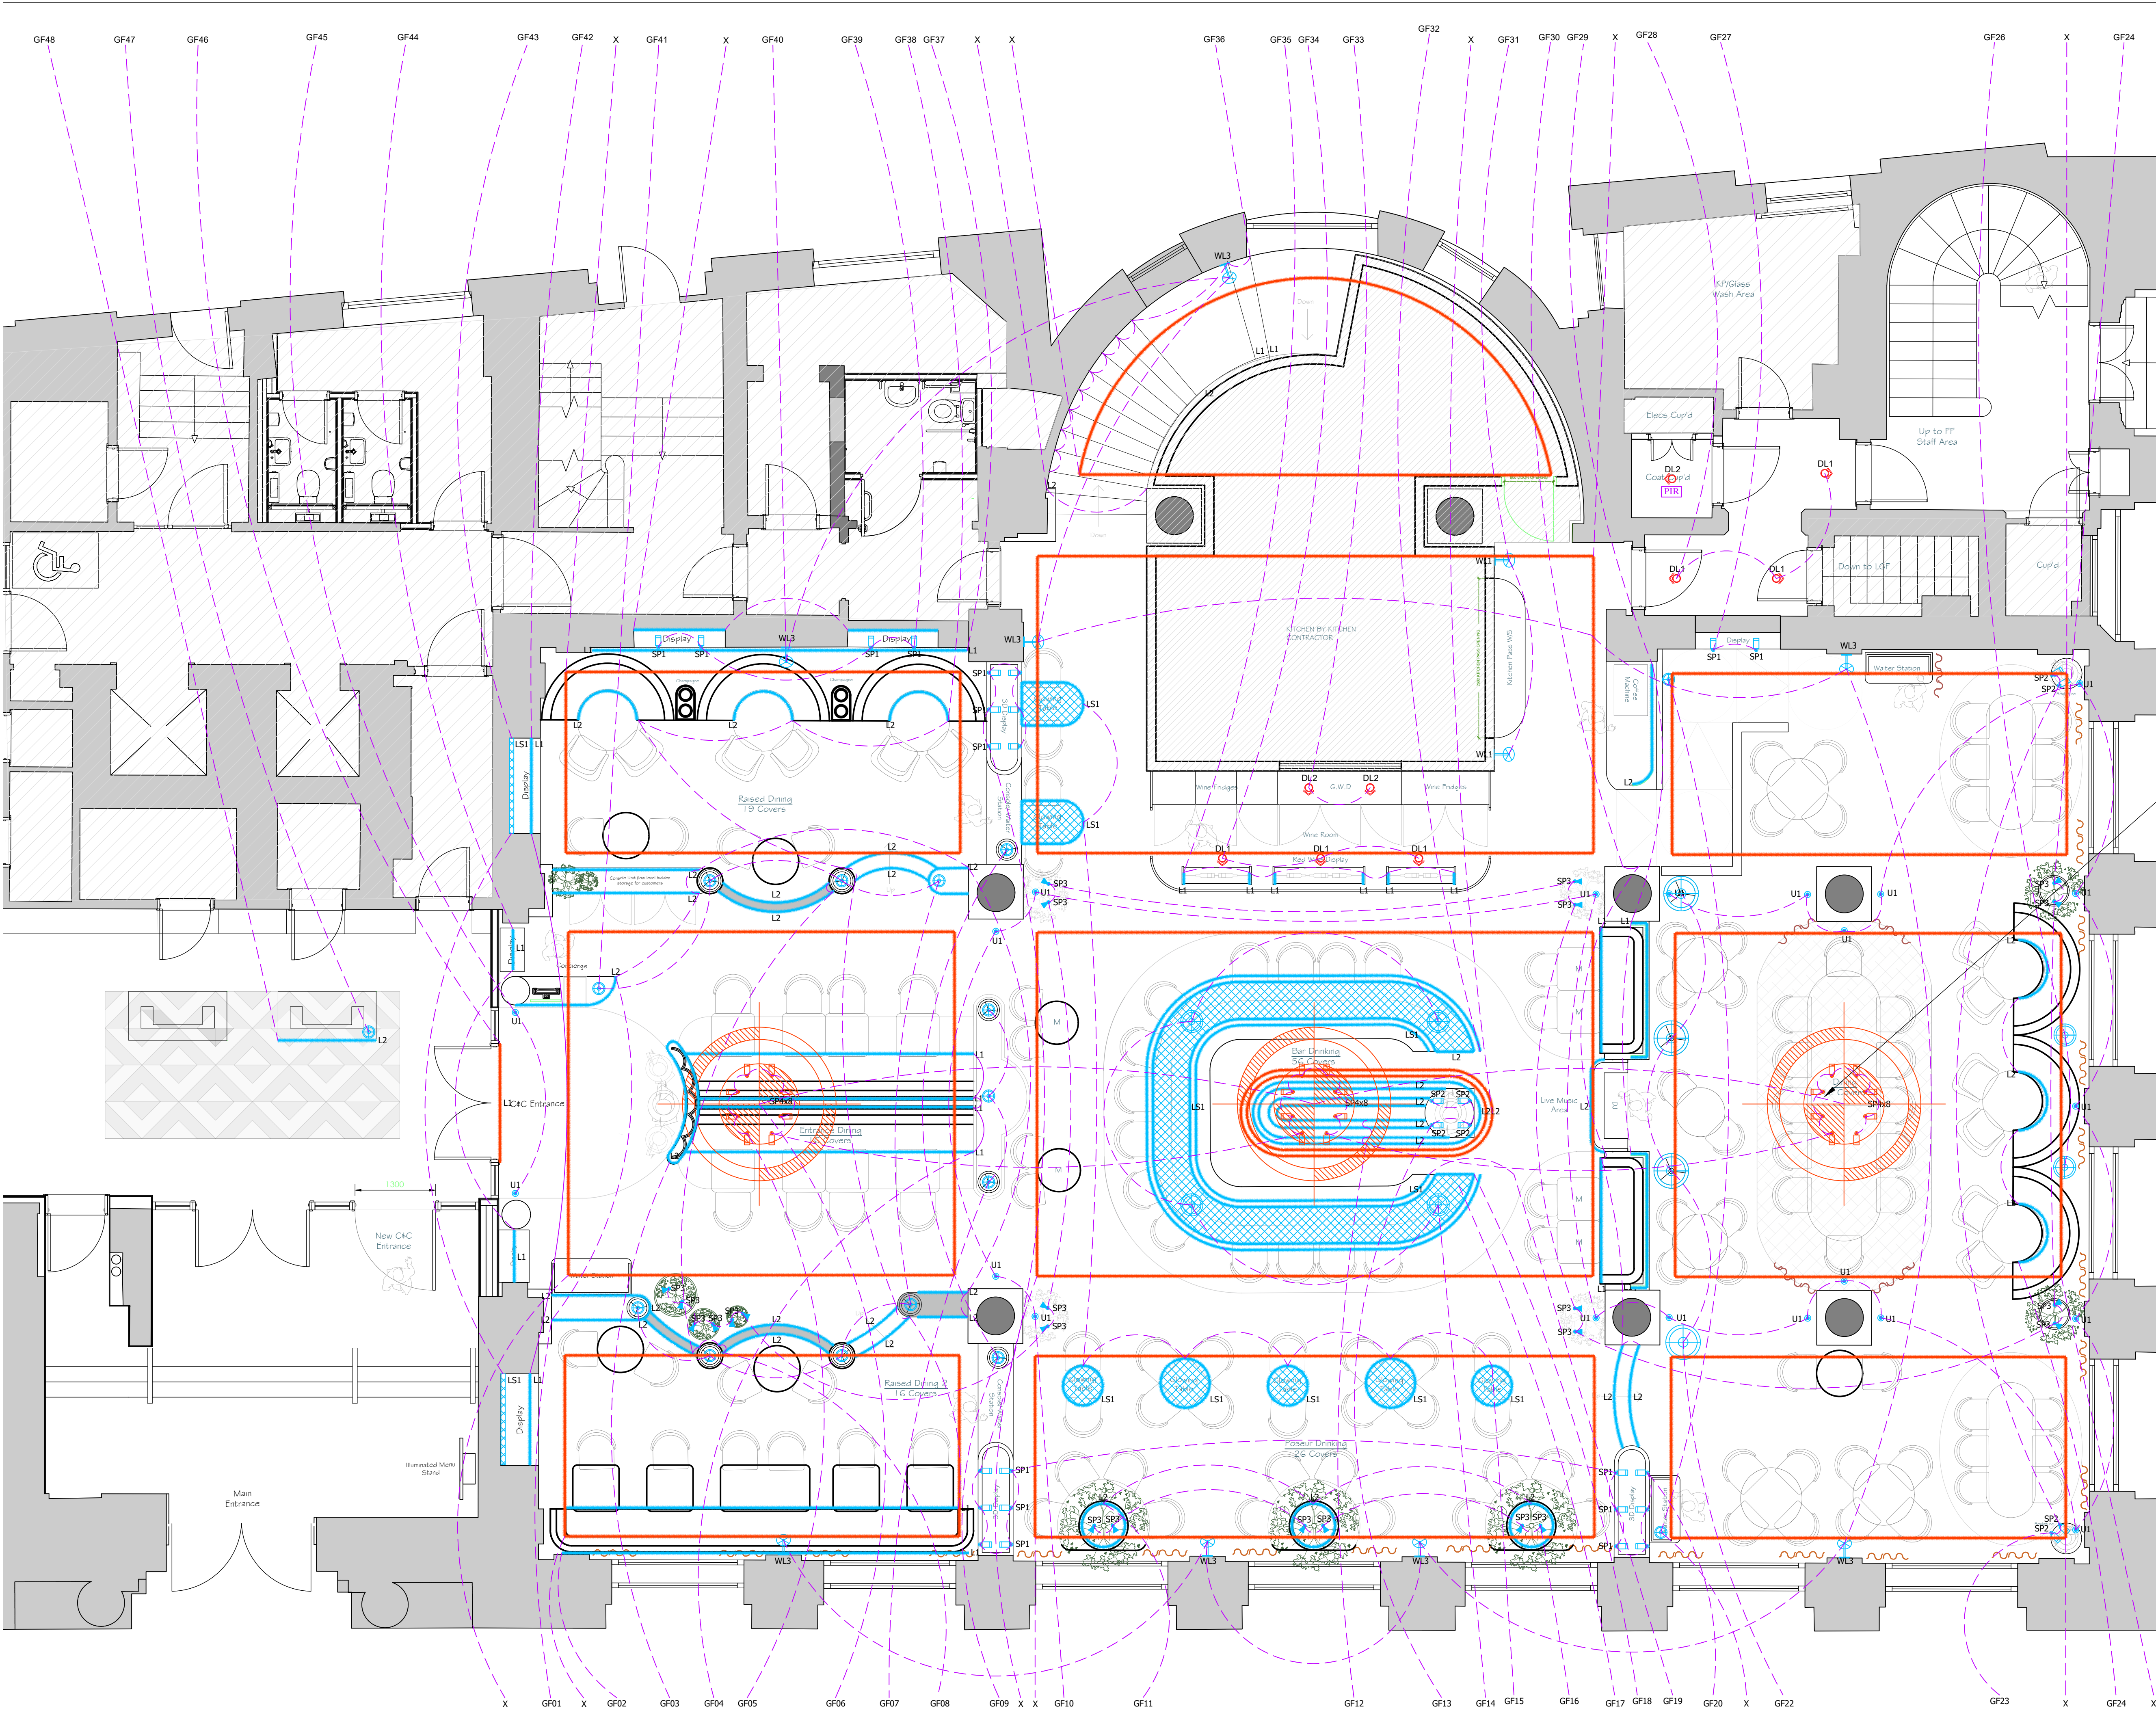

ALL WALL LIGHT POSITIONS TO UTILISE EXISTING POSITIONS ONLY.

3NO. PENDANT LIGHTS ON CEILING TO USE EXISTING POSITIONS.

ALL NEW LIGHTING POSITIONS ARE IN NEW JOINERY PIECES AND FED THROUGH THE FLOOR.
1960'S / 1970'S CONCRETE FLOOR

3NO. PENDANT LIGHTS ON CEILING TO USE EXISTING POSITIONS.

B Lighting scheme confirmed to suit new layout 14.10.24 MM
A Lighting scheme confirmed to suit new layout 22.07.24 BW



JOB TITLE
Cut & Craft
Manchester

DRAWING TITLE
Proposed Ground Floor Lighting Layout

SCALE 1: 50 @ A1	DRAWING No AC 23- P24B
DATE October 2024	

DO NOT SCALE. ALL DIMENSIONS TO BE CHECKED ON SITE BY CONTRACTOR.
ALL MEASUREMENTS ARE IN MM UNLESS OTHERWISE SPECIFIED. WRITTEN DIMENSIONS TO BE USED IN PREFERENCE TO SCALED DIMENSIONS & ALL DISCREPANCIES TO BE REPORTED TO STUDIO TWO. THE DESIGN SHOWN ON THIS DRAWING IS THE PROPERTY OF STUDIO TWO AND IS NOT TO BE USED OR ITS CONTENTS COPIED, COMMUNICATED OR DISCLOSED, IN WHOLE OR IN PART.