


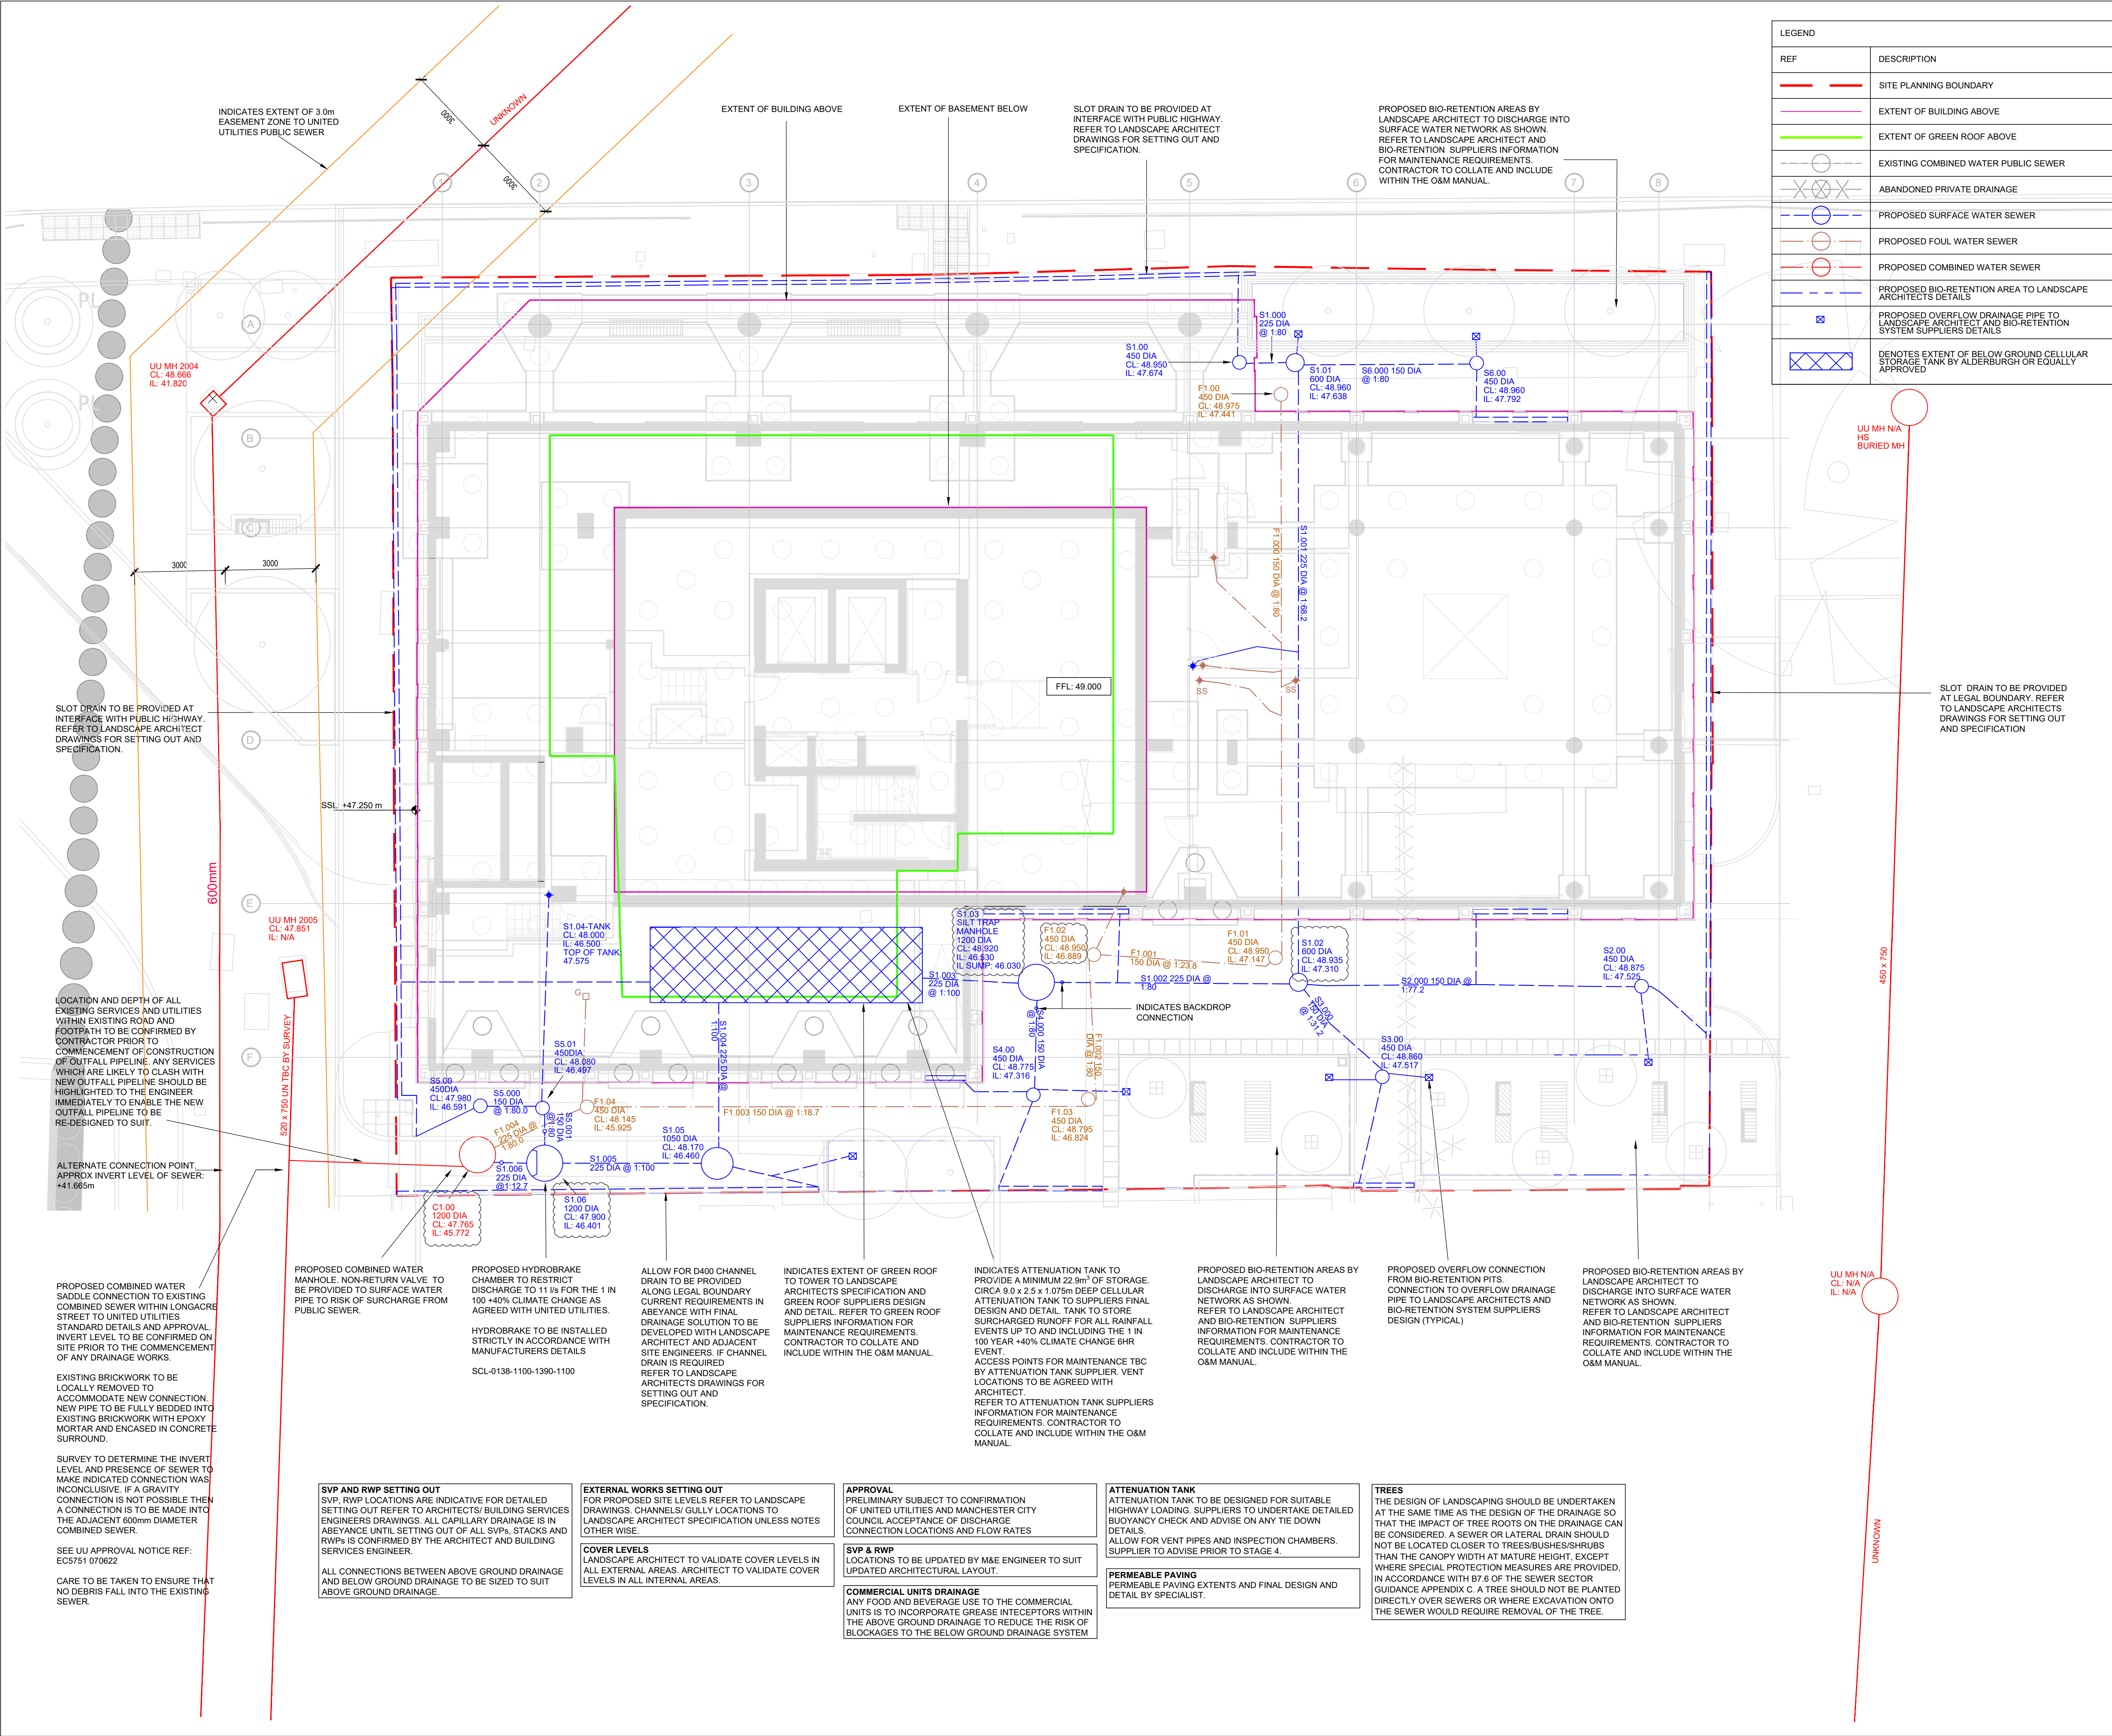

renaissance

Renaissance Associates Ltd
Carvers Warehouse
77 Dale Street
Manchester
M1 2HG

Project: **VICTORIA HOUSE MANCHESTER**

Drawing Title: **BELOW GROUND DRAINAGE PLAN**

Status: **FINAL CONSTRUCTION**

Size:	Date:	Drawn by:	Designed by:	Checked by:
A1	JUN'22	HW	HW	PW

Scale:	1:100	Project No:	2007-04
Project - Originator - Volume - Level - Type - Role - Number: Revision:			

VHM-REN-00-FN-DR-C-01100 **FC03**