



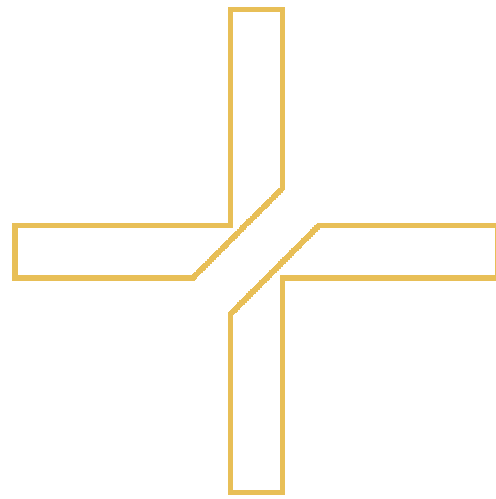

WORK IN PROGRESS | PRELIMINARY ISSUE ONLY | SUBJECT TO LISTED BUILDING CONSENT

Do not scale from this drawing. It is the contractor's responsibility to report any drawing inaccuracies and request clarification from the design team before proceeding. All measurements are indicative and should be checked on site by individual contractors prior to commencement of construction or procurement of materials of components. This drawing is copyright to Select Interiors and may not be copied or reproduced in any form without written prior consent.

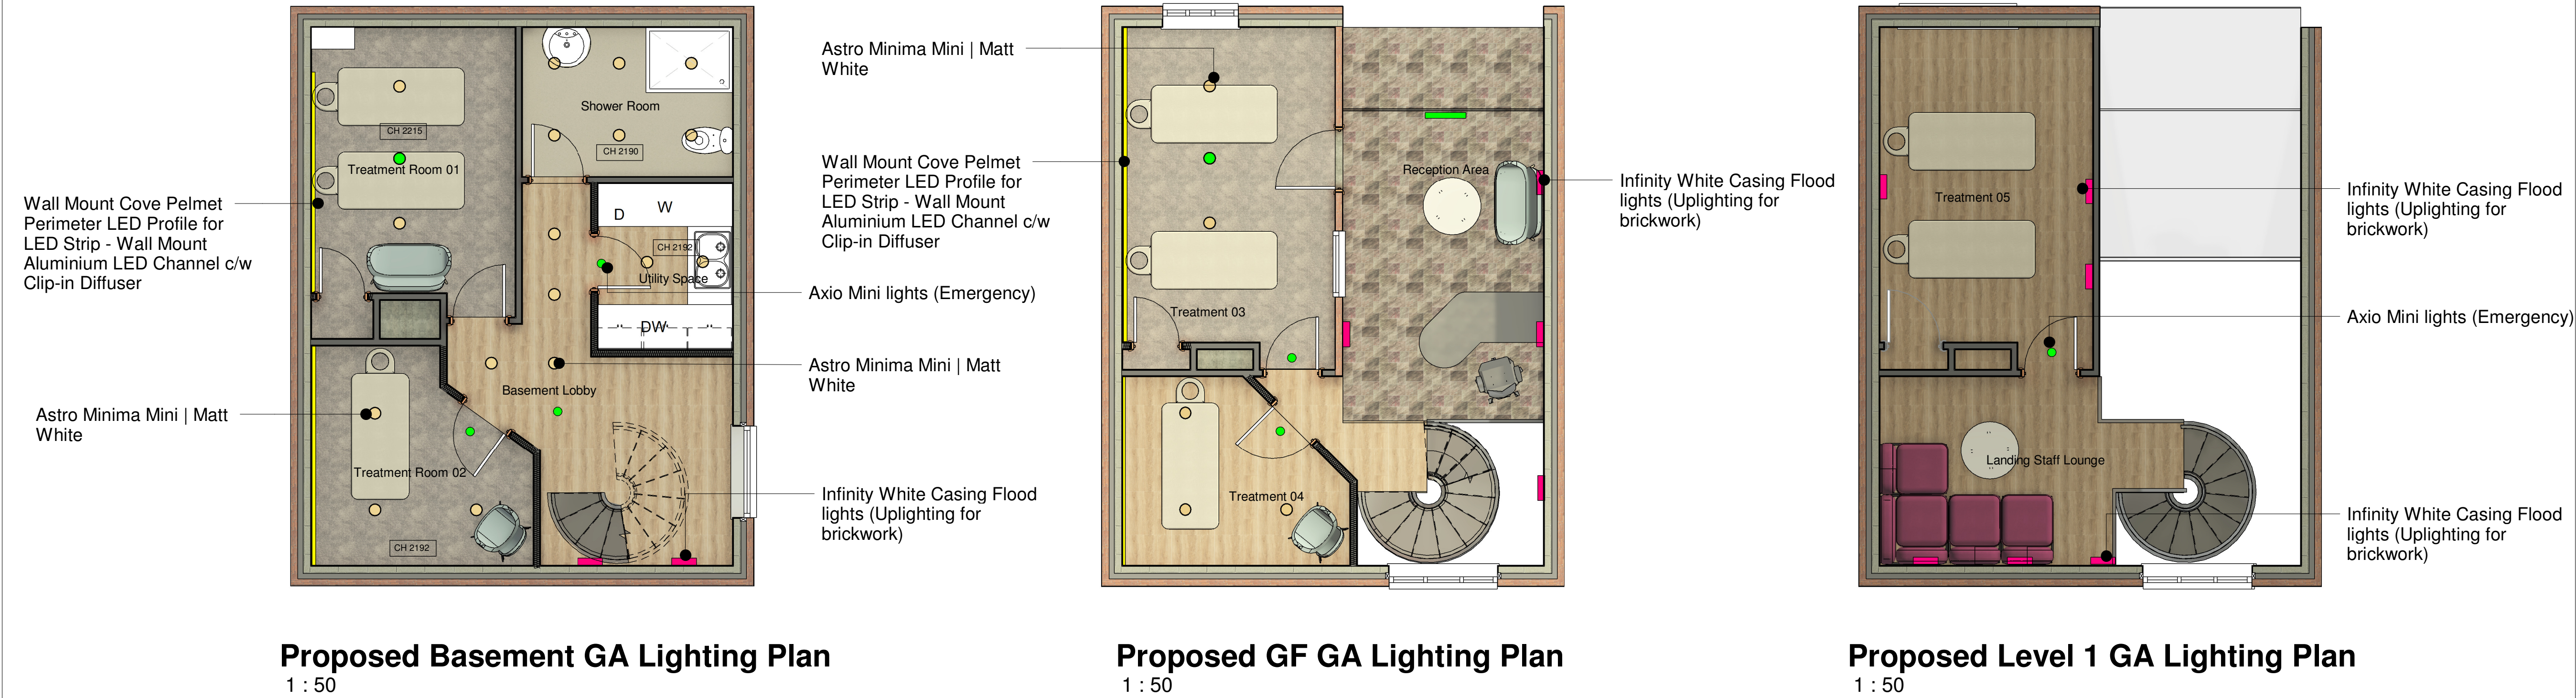

Lighting Schedule: (*Lighting shown is for illustrative purposes only and is subject to changes*)



- Fire Protection & Safety:**
- Fire Alarm to BS5839 Part 1: 2017, Category L1.
 - Emergency lighting to escape routes and windowless areas to BS5266 Part 1: 2016.
 - Fire exit and safety signage to BS5499 Part 4: 2013.
 - 30 Minute Fire doors with Smoke Seals (Self closing mechanism & Safety glazing).

Electrical Installation:

Generally electrical installation is to comply with the IEE regulations and any bylaws or statutory authorities' rules and regulations applicable. All electrical work is required to meet Part P of the Building Regulations. The electrical installations are to be designed, installed and tested by a person competent to do so. The electrical installer is also required to be Part P registered and to provide appropriate electrical certification to show compliance with BS 7671 when the works has been completed.

The electrician should ensure all PVC covered cables are not in contact with any insulation. The electrician is to discuss and confirm with the client any additional sockets that maybe required.

Regulation M Switches & Sockets :

Switches and socket outlets for lighting and other equipment in habitable rooms should be set at between 450mm and 1200mm from finished floor level.

Smoke Detectors:

A mains operated interconnected smoke alarm detection system to be provided throughout the building. All to comply with the fire officers and building control requirements.


Fire detection system installation to comply with BS 5839 Part 1 2017, Category L1

Detectors to be fitted with 7.5m of the door to every habitable room. Ceiling mounted fittings to be at least 300 mm from any wall or light fitting. A wiring certificate is required for the mains operated smoke alarms once the installation is completed.

- Light Switches:**
- White MK Twin Rocker Switches adjacent to doorways.
 - PIR Sensors for Kitchenettes, WC's and Landings only with 15 min over run.

All electrical switchboards and mains to be inspected prior to installation.

New replacement consumer units subject to investigation

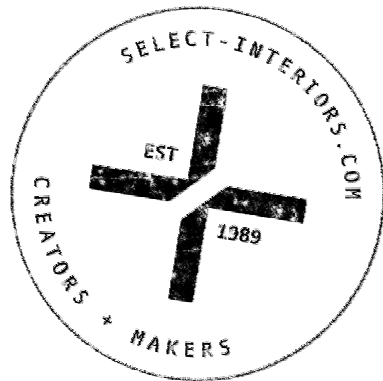

B	06.07.24	JK	Layout updated following client meeting
A	02.07.24	JK	Lighting Updated
Rev	Date	By	Detail

Revision Note:

Project Name:8 Bradley Street

Project No: 2241

Drawing title: Proposed Lighting Plan

DWG No: 2241-XX-XX-XX-DR-A-0102	Rev No: B	Date: 02/07/24
------------------------------------	--------------	-------------------