



Orangery Section B-B Scale 1:50 @ AO

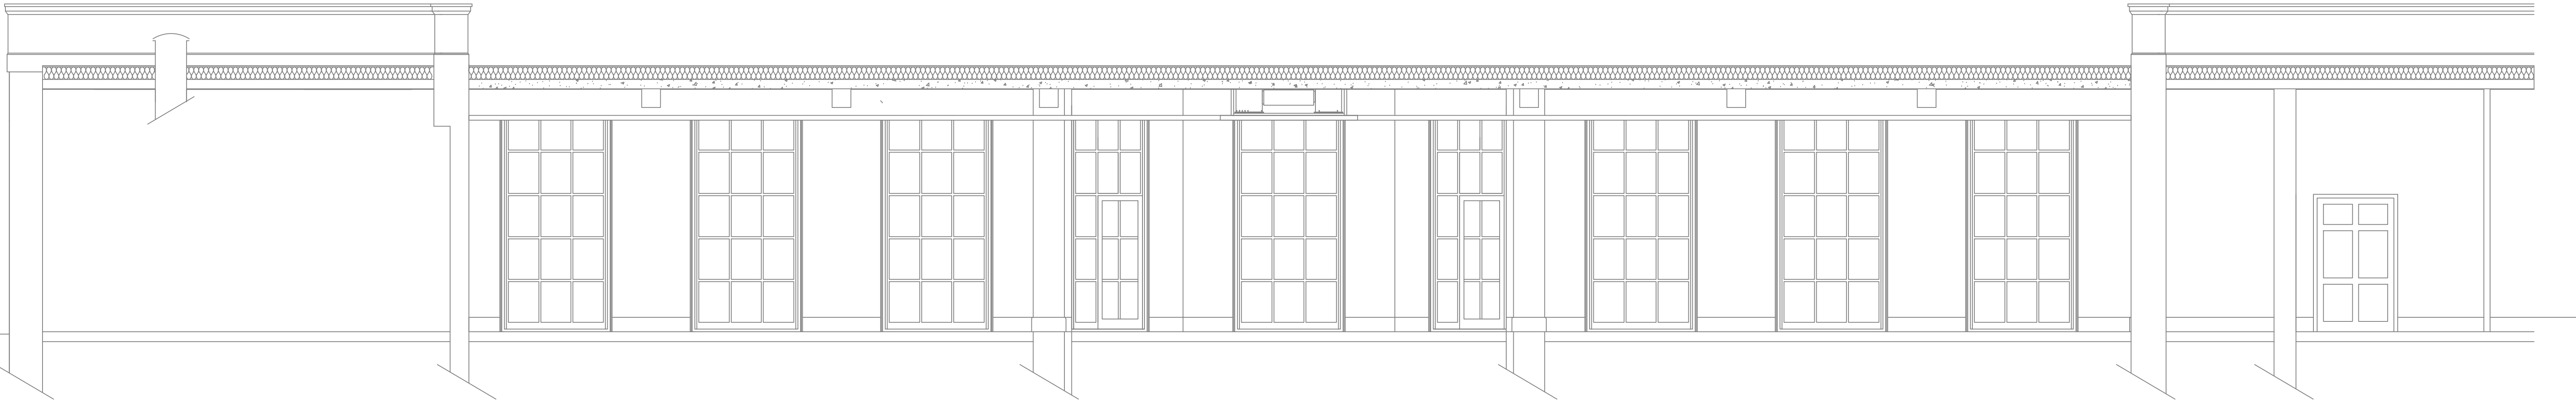

Orangery Section A-A Scale 1:50 @ AO



Orangery Section D-D

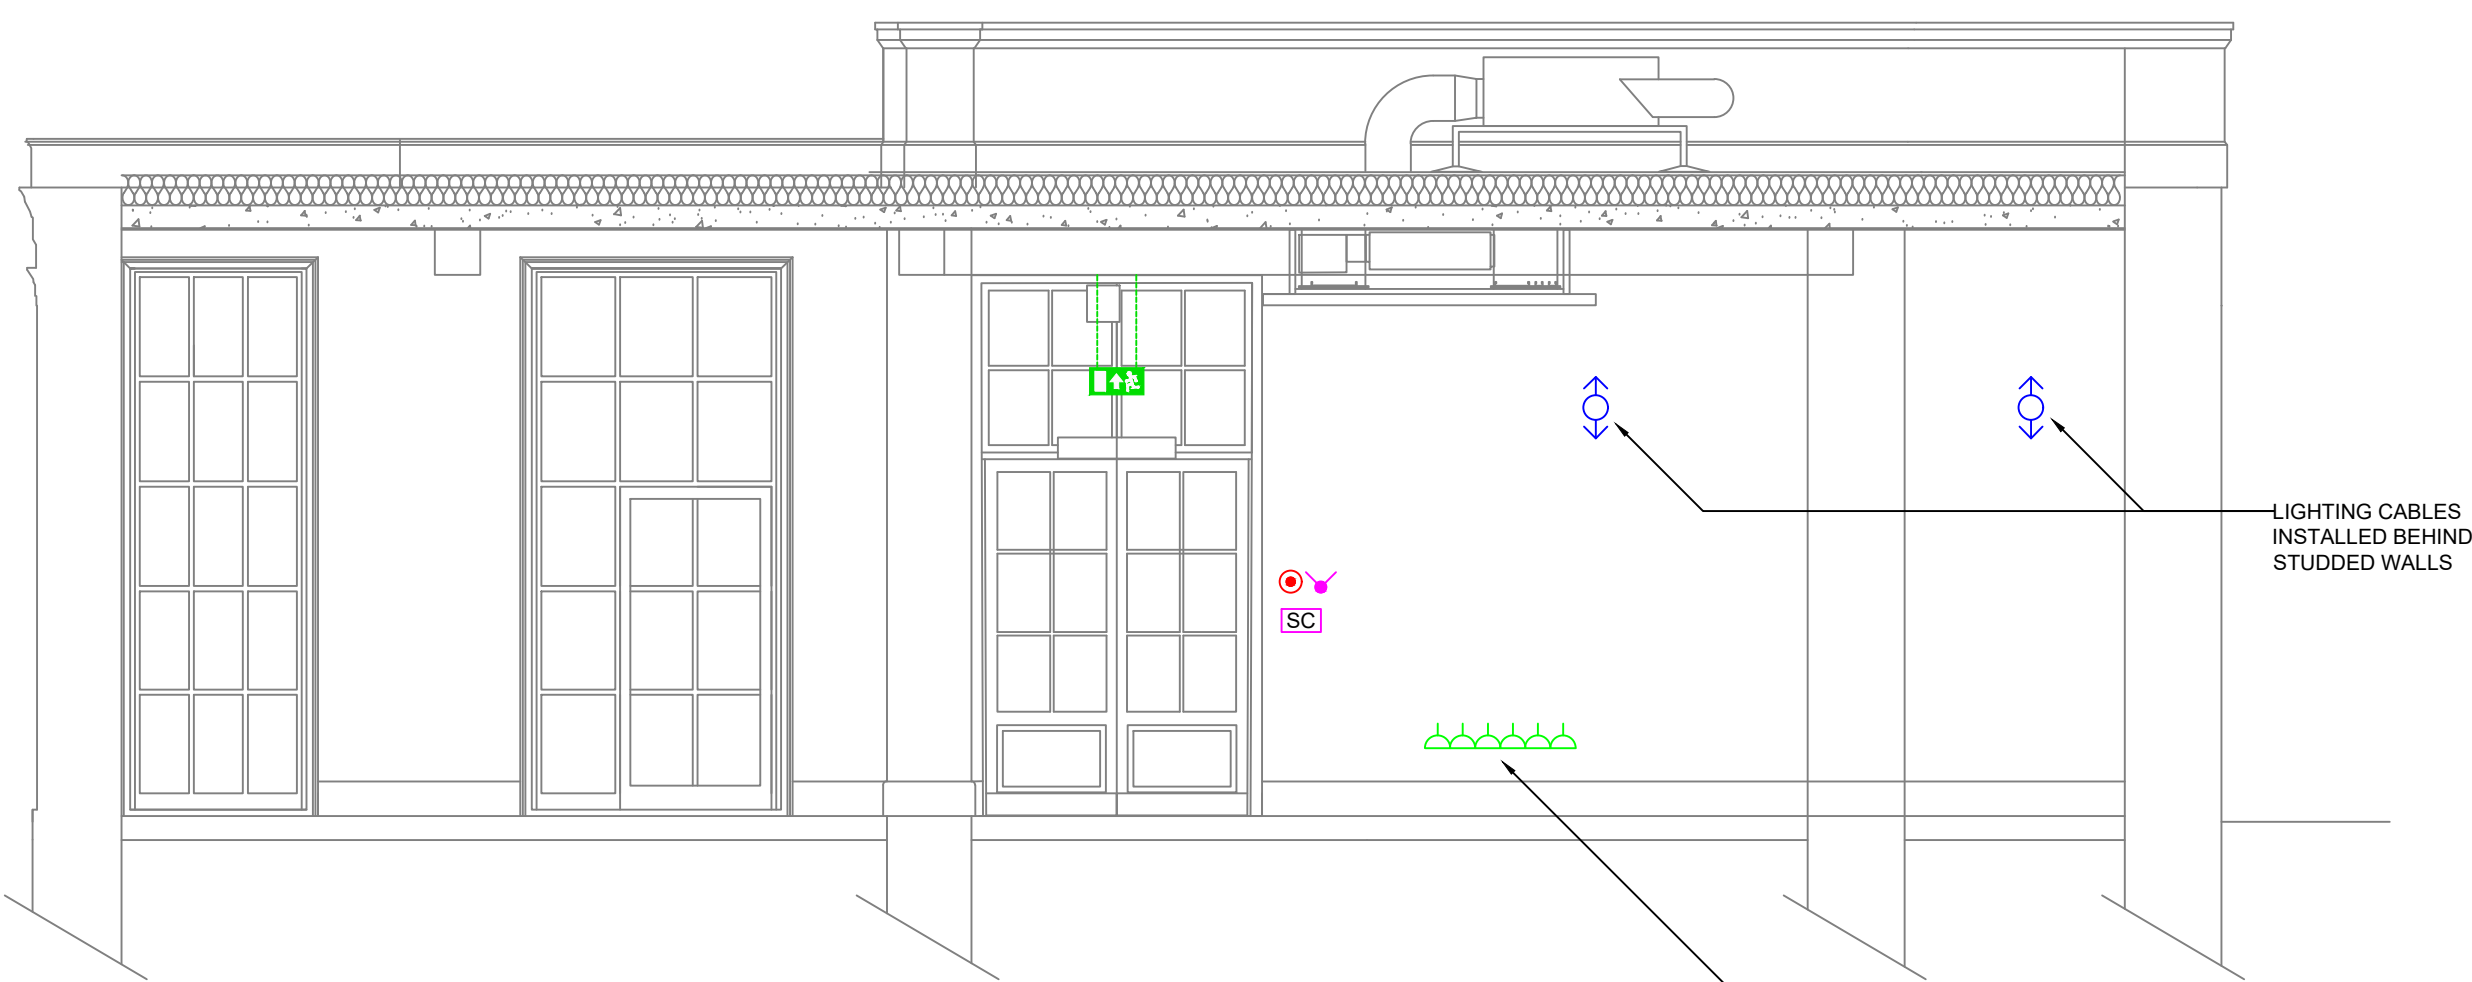

Orangery Section C-C

25 x 230mm profiled timber softwood skirting on 30 x 50mm softwood grounds fixed through new rendering plaster drill plug and screwed to wall.
NOTE: Electrical cables to run behind skirting with vertical connection in plaster to 25mm deep x 86mm high back box with 100mm high x 150mm wide double plug faceplate.

LIGHTING LEGEND		GENERAL NOTES	
SYMBOL	DESCRIPTION	1	THIS DRAWING SHALL BE READ IN CONJUNCTION WITH THE ECS ELECTRICAL ENGINEERING SPECIFICATIONS.
	WALL LIGHT	2	THIS DRAWING IS INDICATIVE AND IS INTENDED TO HIGHLIGHT THE PROPOSED LOCATION FOR ELECTRICAL SERVICES. THE CONTRACTOR SHALL NOTE THESE DRAWINGS SHALL NOT BE USED FOR CONSTRUCTION PURPOSES.
	ESCAPE ROUTE SIGN SUSPENDED IN CEILING. CABLE FED FROM RAFT	3	THE CONTRACTOR SHALL INCLUDE TO PRODUCE THEIR OWN WORKING DRAWINGS. TAKE DETAILED SITE MEASUREMENTS, INDICATE THE PROVISION OF BUILDERS WORKS AND COORDINATE THE INSTALLATION OF ALL SERVICES.
FIRE ALARM LEGEND		4	THE CONTRACTOR SHALL NOTE THIS DRAWING HAS BEEN PRODUCED USING LIMITED SITE SURVEY INFORMATION. THE CONTRACTOR SHALL INCLUDE TO CARRY OUT AN INTRUSIVE SURVEY AND TO PRODUCE DRAWINGS THAT REFLECT THE INSTALLATION.
SYMBOL	DESCRIPTION	5	ALL EQUIPMENT SHALL BE INSTALLED & LOCATED TO MAINTAIN SPATIAL REQUIREMENTS TO FACILITATE ACCESS & MAINTENANCE IN LINE WITH MANUFACTURERS RECOMMENDATIONS AND GOOD PRACTICE GUIDES.
	FIRE ALARM PANEL "CONVENTIONAL / ANALOGUE ADDRESSABLE" "SINGLE LOOP / TWIN LOOP"	6	ALL EQUIPMENT SHALL BE INSTALLED IN ACCORDANCE WITH MANUFACTURERS GUIDELINES.
	MANUAL CALL POINT	7	DO NOT SCALE FROM THIS DRAWING.
SMALL POWER LEGEND		8	ALL DETAILS ARE APPLICABLE TO EVERY DRAWING UNLESS INDICATED OTHERWISE.
SYMBOL	DESCRIPTION	THE CONTRACTOR SHALL INCLUDE TO IDENTIFY THE COMPLETE EXISTING ELECTRICAL INSTALLATION, EXTEND AND ADAPT TO FACILITATE THE PROPOSED WORKS.	
	TWIN SWITCHED SOCKET OUTLET MOUNTED AT 450mm AFPL		
	13 AMP SWITCHED FUSED SPUR CONNECTION UNIT		
PLANT CONTROL LEGEND			
SYMBOL	DESCRIPTION		
	HEATING VENT MAIN CONTROLLER		
LIGHTING CONTROLS LEGEND			
SYMBOL	DESCRIPTION		
	TWO WAY GRID SWITCH (" DENOTES NO. OF GANGS)		
	LIGHTING SCENE CONTROLLER PANEL		