


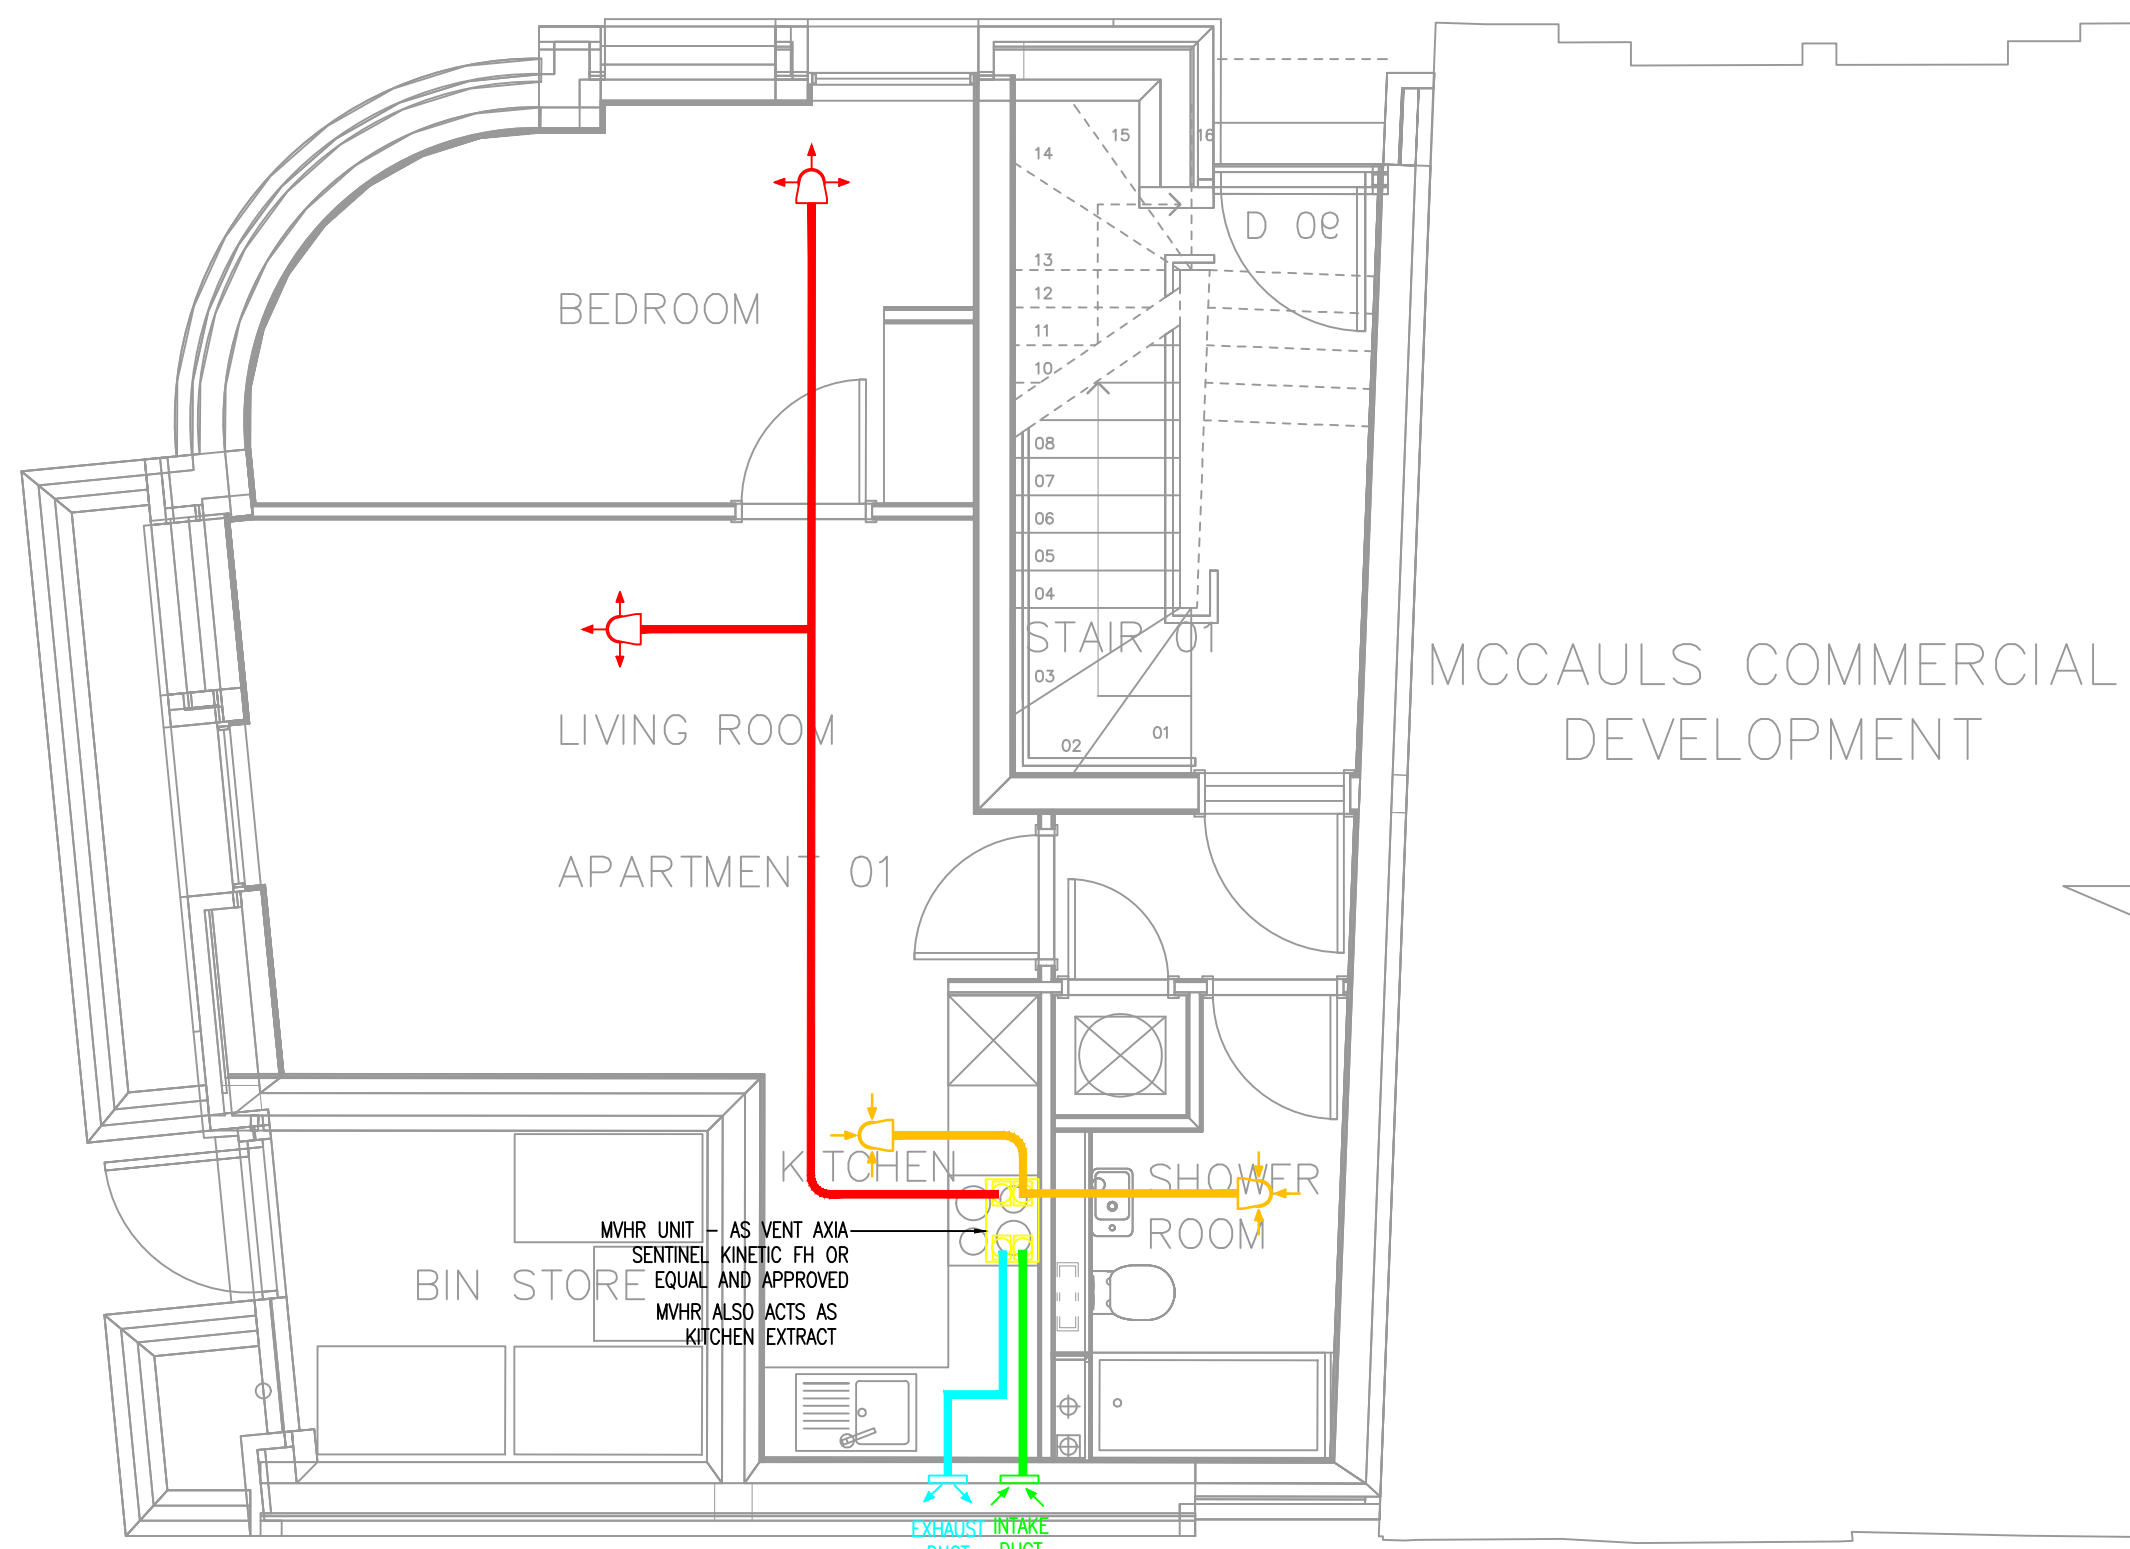


VENTILATION LAYOUT

VENTILATION LEGEND

- SUPPLY DIFFUSER (CEILING MOUNTED)
- EXTRACT VALVE (CEILING MOUNTED)
- EXTRACT VALVE (WALL MOUNTED)
- SUPPLY DIFFUSER
- EXTRACT GRILLE
- EXTRACT FAN AS VENT AXIA LO-CARBON MULTIVENT MVDC-MS OR EQUAL AND APPROVED
- RE-CIRCULATION OVER HOB EXTRACT WITH LOCAL SPEED CONTROLLER AND CARBON FILTRATION
- VENTILATION BOOST SWITCH
- UNDERCUT DOOR
- 300 X 300 ACCESS HATCH
- EXHAUST TERMINAL IN ROOF
- ATTENUATOR
- EXTRACT FAN
- FIRE DAMPER
- VOLUME CONTROL DAMPER
- SUPPLY DIFFUSER
- EXTRACT DIFFUSER

HEATING LEGEND

- THERMOSTAT
- THERMOSTAT WITH FLOOR PROBE
- HEATING PROGRAMMER/ WIRING CENTRE
- HEATING MANIFOLD
- HEATING PIPEWORK AT HIGH LEVEL
- HEATING PIPEWORK AT LOW LEVEL
- PIPEWORK RISE/DROP
- TOWEL RAIL
- ELECTRIC PANEL HEATERS

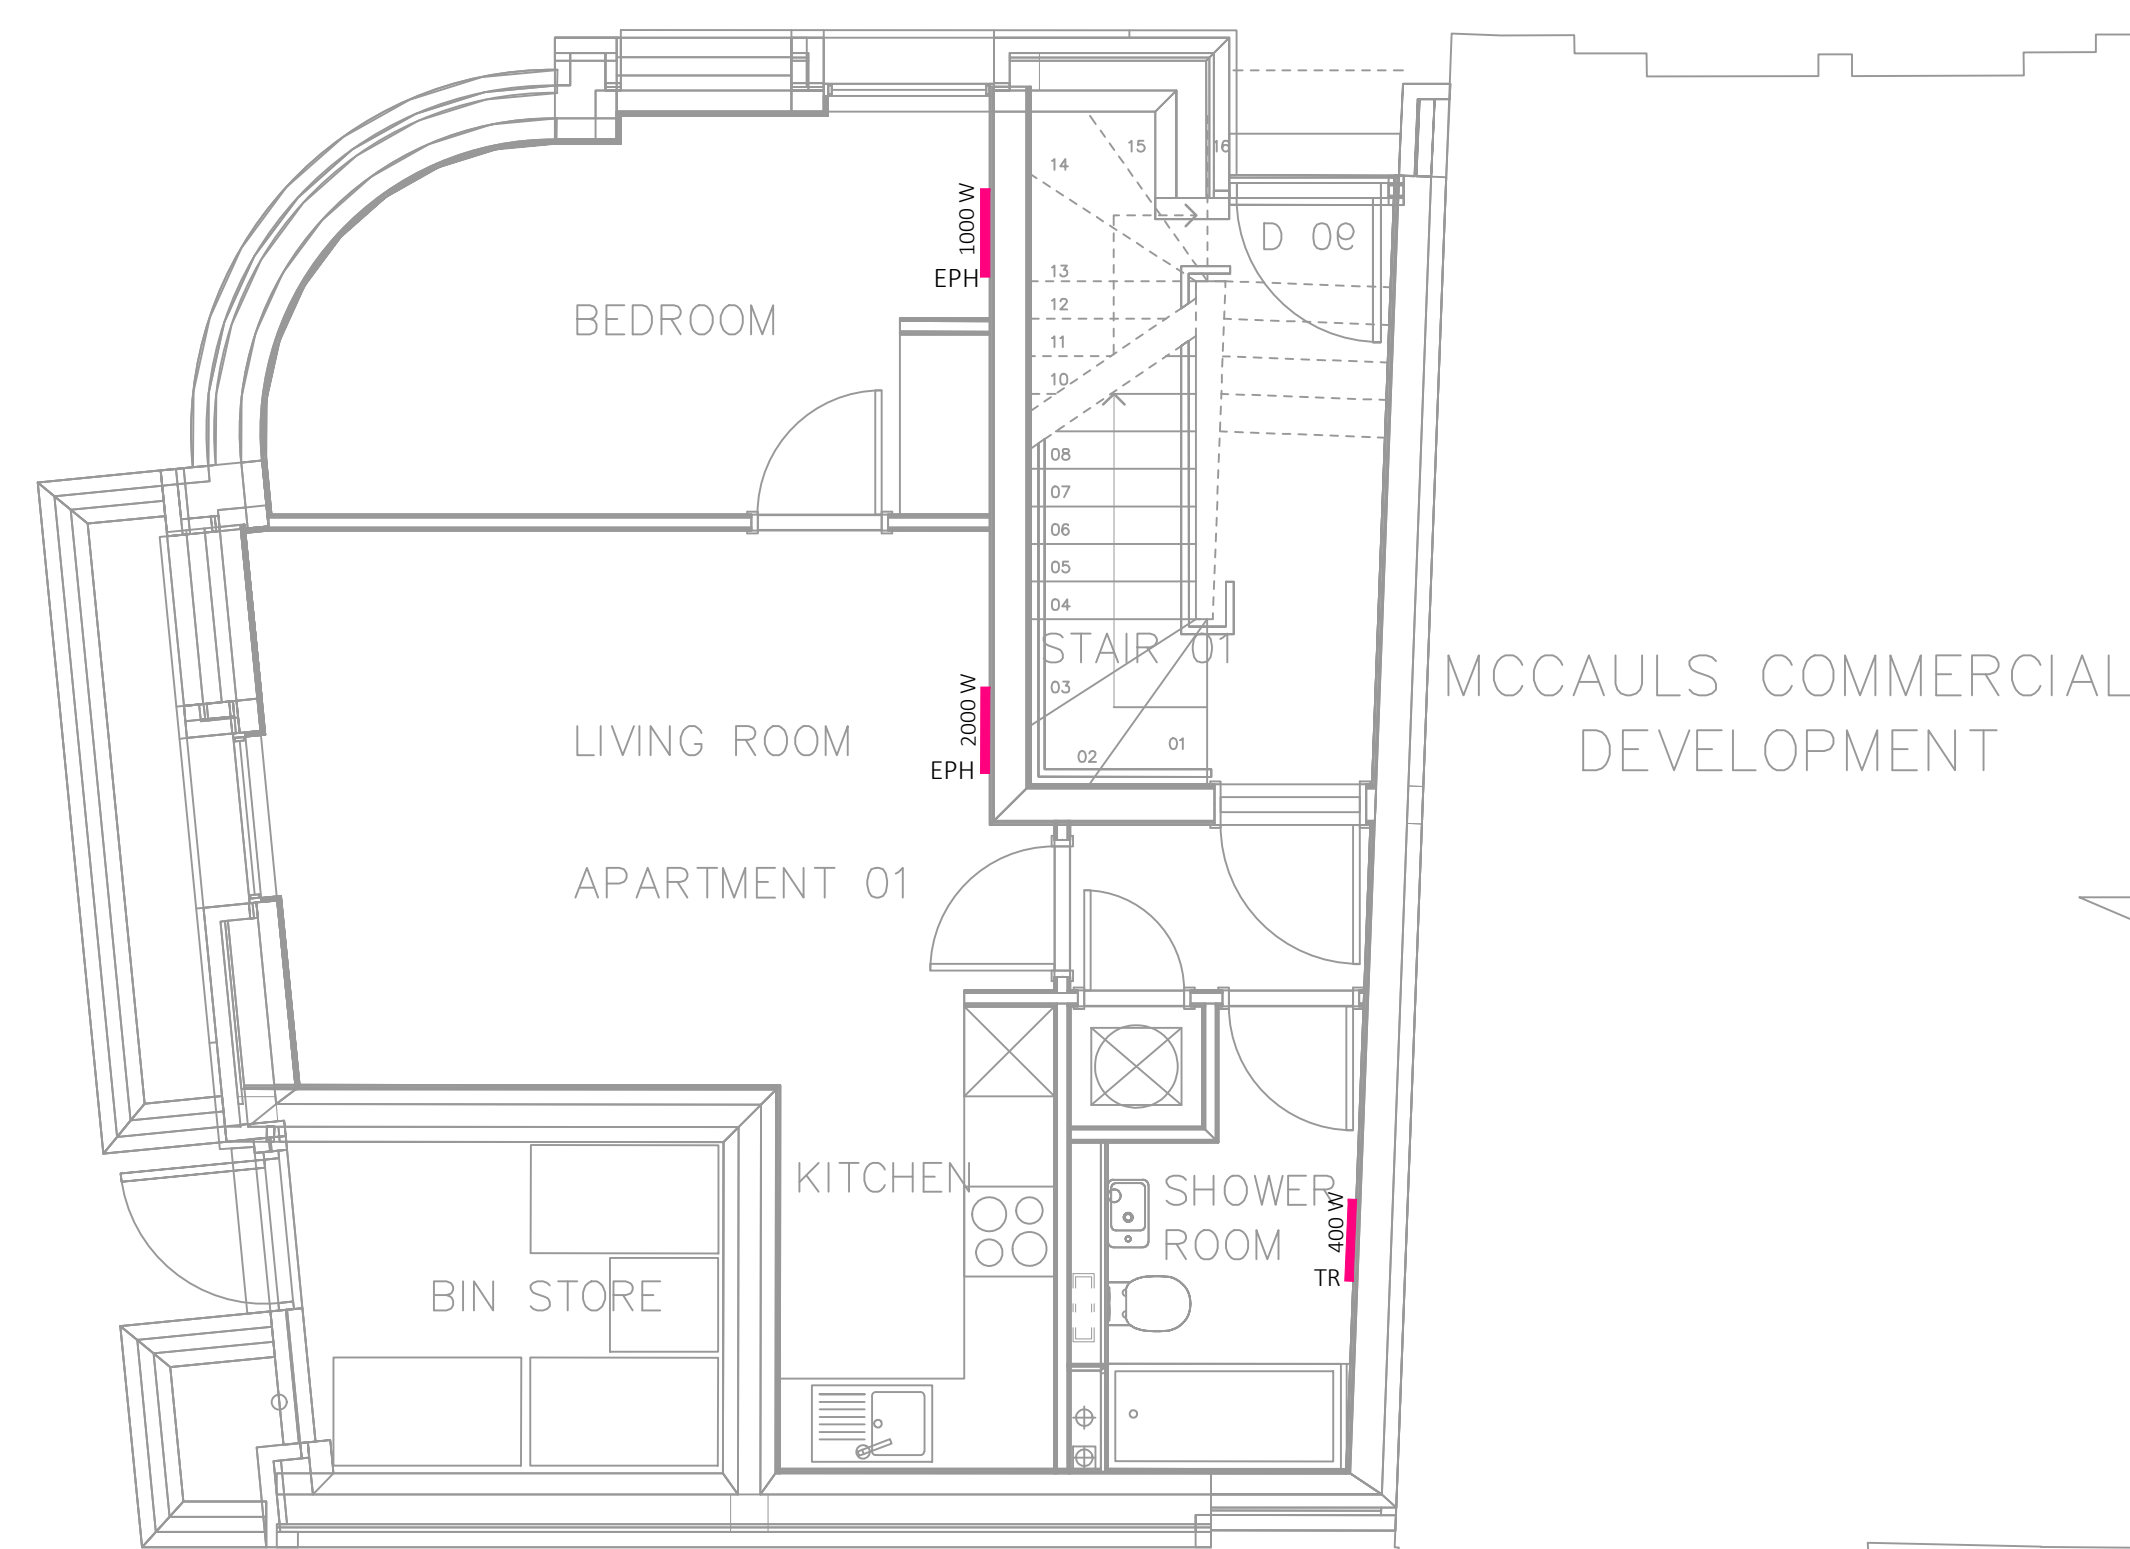

HEATING LAYOUT

WE&CE DRAWINGS ARE FOR DESIGN INTENT ONLY. THE MEP CONTRACTOR IS RESPONSIBLE FOR THE FINAL INSTALLATION DRAWINGS INCLUDING ALL SETTING OUT, DIMENSIONS, ALIGNMENT AND COORDINATION WITH THE ARCHITECTS REQUIREMENTS.

- Notes:
- This drawing is subject to copyright and is not to be reproduced in part or whole without approval.
 - Do not scale this drawing - check all dimensions on site.
 - This drawing shall be read in conjunction with the project specification(s) and all other contract documentation.
 - All dimensions are in millimetres unless otherwise stated.
 - Location of all equipment shown shall be confirmed/approved with the Client/Architect/Engineer prior to any installation.
 - This drawing must be read in conjunction with Mechanical and Electrical performance specifications and all other drawings as issued by the Architect, Structural Engineer and Watt Energy and Consulting Engineers.
 - The location of equipment is typical only. The Contractor shall perform all calculations to determine the exact quantity and agree the final locations with the Architect.
 - This drawing shows the intended location of building services plant and service routes in such detail as to indicate the design. The drawing does not show all components that may be necessary to provide a full working installation.
 - The positions of connection points, accessories and building services items are approximate and shown for guidance to assist during the tender process.
 - Fully co-ordinated drawings, Construction drawings and Builderswork drawings shall be produced by the contractor. Under no circumstances shall the tender drawings be used as installation drawings.

P1	11/06/24	PRELIMINARY ISSUE	AS
Rev:	Date:	Status/Amendments:	By:

40 KING STREET, MANCHESTER, M2 6BA
TEL: 0161 434 3103 EMAIL: office@wece.co.uk

Client:
MCCAULS

Project:
LAYSTALL STREET

Drawing Title:
MECHANICAL SERVICES
APARTMENT TYPE 01
LEVEL 00

Drawn By: AS	Checked By: DW	Cad By: AS
Scale: 1:50	Paper Size: A1	Date Created: 14/05/2024
Drawing Number: WECE / 404 / M / AP / 100	Drawing Revision: P1	