


SITE LOCATION

 


Reproduced by permission of Ordnance Survey on behalf of the Controller of Her Majesty's Stationary Office
All rights reserved. © Crown Copyright licence no. 100062043

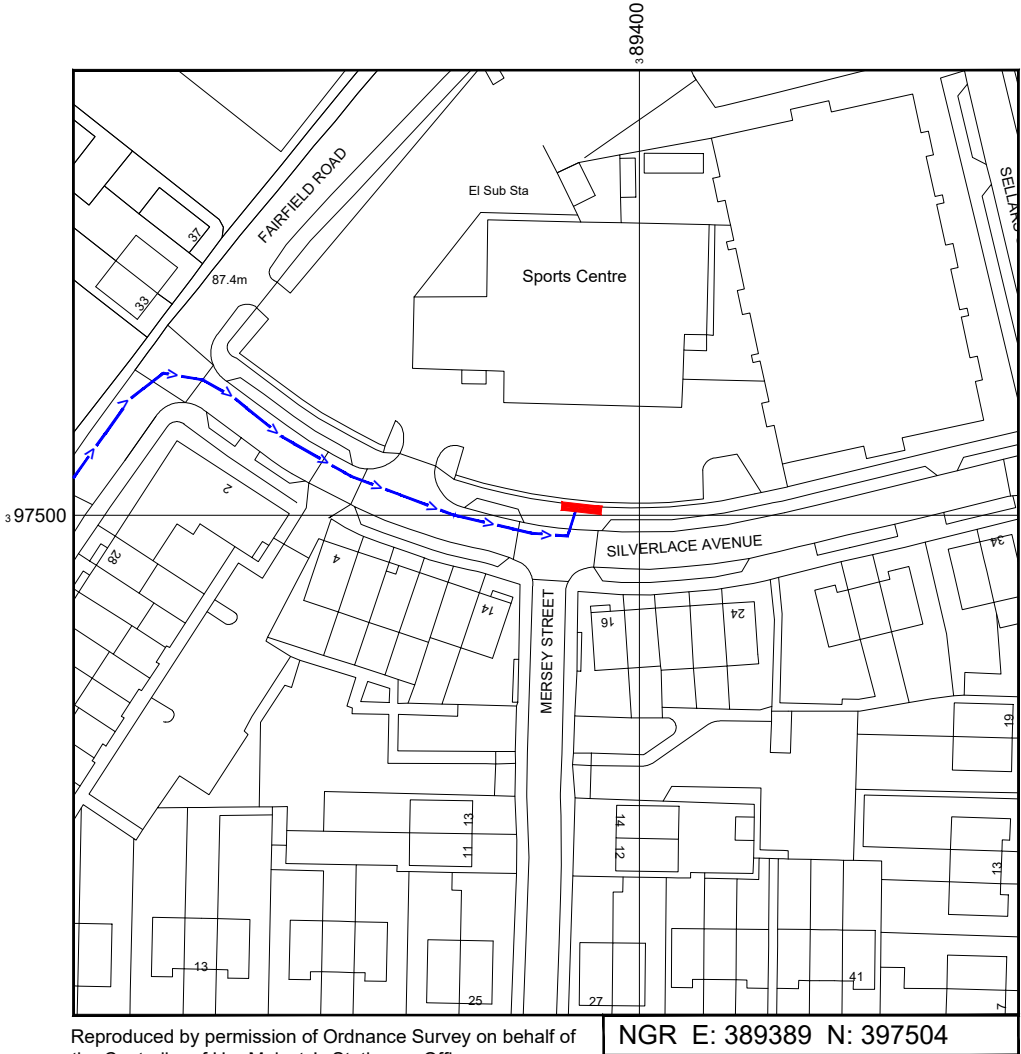


Reproduced by permission of Ordnance Survey on behalf of the Controller of Her Majesty's Stationary Office
All rights reserved. © Crown Copyright licence no. 100062043

SITE AREA PLAN



SITE PHOTOGRAPH

 SITE LOCATION PLAN



GOOGLE MAPS QR CODE

GOOGLE MAPS - <https://goo.gl/maps/D7Lct4LENckHZYrX8>

GOOGLE STREETVIEW - <https://goo.gl/maps/r783SFTg2QBh5G2v6>

NOTES:

1. ALL DIMENSIONS IN MM UNLESS OTHERWISE NOTED.
- DIRECTIONS TO SITE:
Head north on M60. At junction 24, Use the left lane to take the A57/M67 exit to M/cr City Centre/Denton/Hyde/Sheffield. Keep left at the fork and merge onto Manchester Rd/A57. Turn right onto Chapman St. At the roundabout, continue straight onto Cornwall St. Turn right onto Ogden Ln. Continue onto Fairfield Rd. Turn right onto Silverlace Ave. Follow Silverlace Ave and site location is on the left hand side.



Master:	MBNL / EE:	Project:	Purpose of Issue:	Issue:
M003	MBNL	3UK DNSW	Planning	C
Date:	06/02/2023	Revision / Upgrade Description:		
Drawn:	CDN	Pole location amended		
Checked:	DH			
Approved:	SD			
Master:	MBNL / EE:	Project:	Purpose of Issue:	Issue:
M002	MBNL	3UK DNSW	Planning	B
Date:	01/02/2021	Revision / Upgrade Description:		
Drawn:	CDN	Amended		
Checked:	DH			
Approved:	SD			
Master:	MBNL / EE:	Project:	Purpose of Issue:	Issue:
M001	MBNL	3UK DNSW	Planning	A
Date:	01/02/2020	Revision / Upgrade Description:		
Drawn:	CDN	First Issue - Site nomination dated: TBC		
Checked:	DH			
Approved:	SD			

CK Hutchison Networks (UK) Limited

Great Brighams Mead,
Vastern Road, Reading,
Berkshire, England,
RG1 8DJ

Design Consultant & Principal Contractor:



WHP Telecoms
Unit 1 Maple Park,
Low Fields Avenue, Leeds
LS12 6HH

Tel: 01133023550
e-mail: info@whptelecoms.com

Site Name:
SILVERLACE AVENUE STREETWORKS

Site ID:
MAN12080

Address:
SILVERLACE AVENUE,
ABBAY HEY,
CLAYTON,
MANCHESTER,
M11 1JE

Title:
002 SITE LOCATION PLAN

Project:
3UK DNSW


Purpose of Issue:
PLANNING

EE Cell ID: 65762	MBNL Cell ID: MAN473	Cell ID: M0203
----------------------	-------------------------	-------------------

Master Drawing No: MAN12080_M003	Issue: C
-------------------------------------	-------------



 EXISTING SITE PLAN



- NOTES:
- ALL DIMENSIONS IN MM UNLESS OTHERWISE NOTED.

Master:	MBNL / EE:	Project:	Purpose of Issue:	Issue:
M003	MBNL	3UK DNSW	Planning	C
Date:	06/02/2023	Revision / Upgrade Description:		
Drawn:	CDN	Pole location amended		
Checked:	DH			
Approved:	SD			
Master:	MBNL / EE:	Project:	Purpose of Issue:	Issue:
M002	MBNL	3UK DNSW	Planning	B
Date:	01/02/2021	Revision / Upgrade Description:		
Drawn:	CDN	Amended		
Checked:	DH			
Approved:	SD			
Master:	MBNL / EE:	Project:	Purpose of Issue:	Issue:
M001	MBNL	3UK DNSW	Planning	A
Date:	01/02/2020	Revision / Upgrade Description:		
Drawn:	CDN	First Issue - Site nomination dated: TBC		
Checked:	DH			
Approved:	SD			

CK Hutchison
Networks (UK)
Limited
Great Brighams Mead,
Vastern Road, Reading,
Berkshire, England,
RG1 8DJ



WHP Telecoms
Unit 1 Maple Park,
Low Fields Avenue, Leeds
LS12 6HH
Tel: 01133023550
e-mail: info@whptelecoms.com

Site Name:
SILVERLACE AVENUE STREETWORKS

Site ID:
MAN12080

Address:
SILVERLACE AVENUE,
ABBHEY HEY,
CLAYTON,
MANCHESTER,
M11 1JE

Title:
100 EXISTING SITE PLAN

Project:
3UK DNSW


Purpose of Issue:
PLANNING

EE Cell ID: 65762	MBNL Cell ID: MAN473	Cell ID: M0203
Master Drawing No: MAN12080_M003		Issue: C


100mm

150mm

10mm

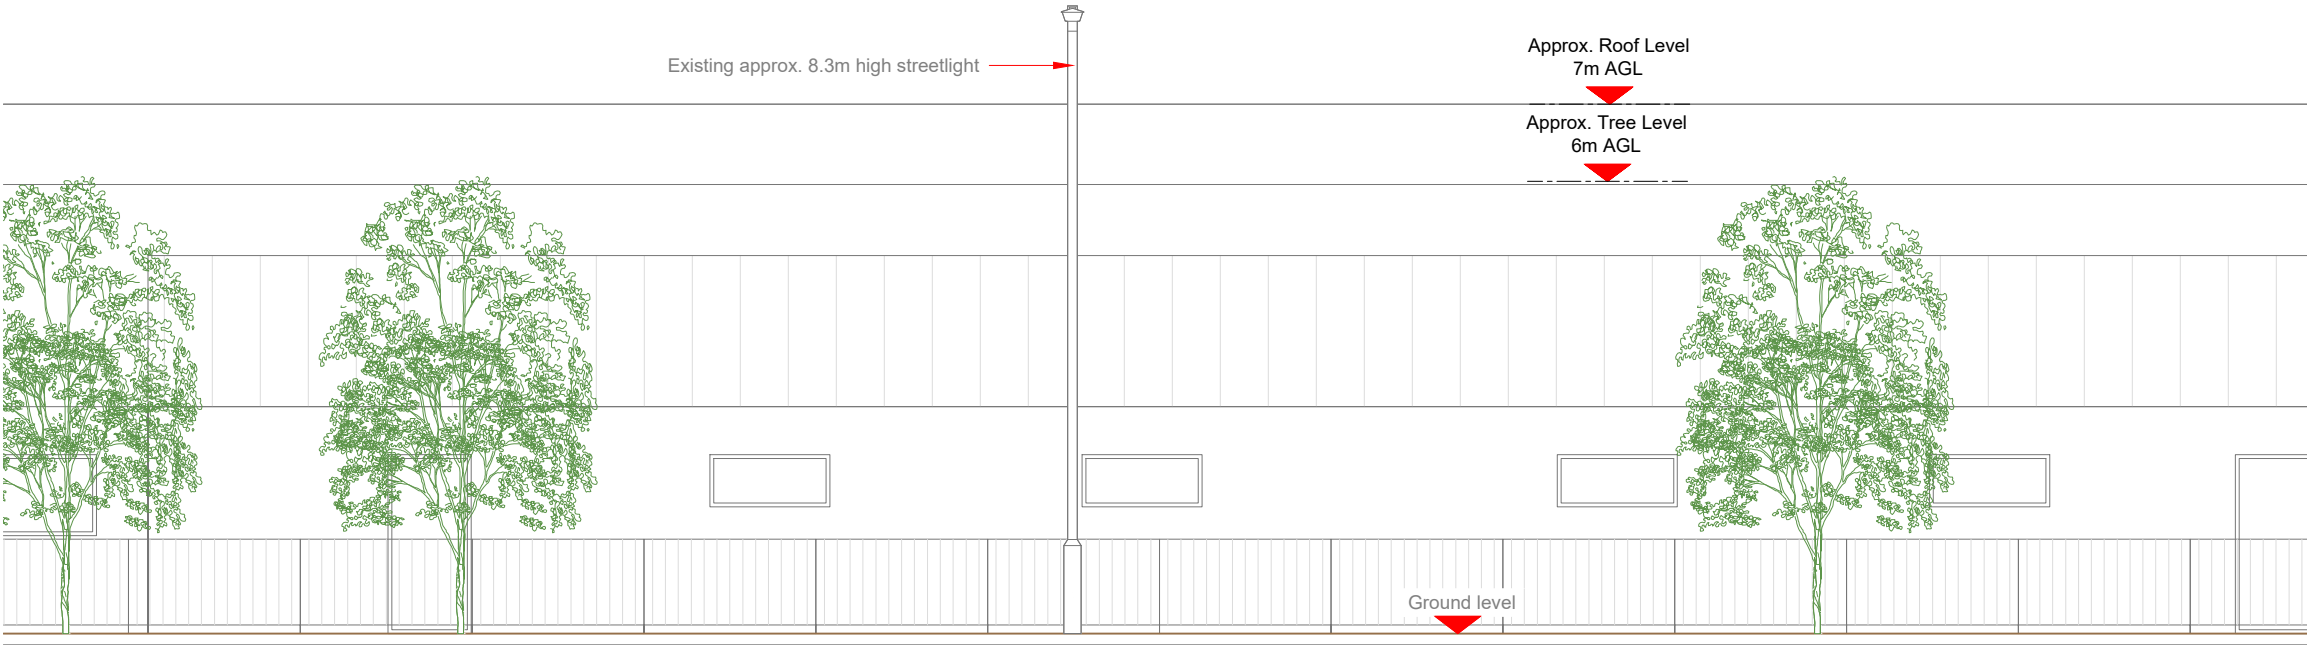

EXISTING ELEVATION A

 

- NOTES:
- ALL DIMENSIONS IN MM UNLESS OTHERWISE NOTED.

Master:	MBNL / EE:	Project:	Purpose of Issue:	Issue:
M003	MBNL	3UK DNSW	Planning	C
Date:	06/02/2023	Revision / Upgrade Description:		
Drawn:	CDN	Pole location amended		
Checked:	DH			
Approved:	SD			
Master:	MBNL / EE:	Project:	Purpose of Issue:	Issue:
M002	MBNL	3UK DNSW	Planning	B
Date:	01/02/2021	Revision / Upgrade Description:		
Drawn:	CDN	Amended		
Checked:	DH			
Approved:	SD			
Master:	MBNL / EE:	Project:	Purpose of Issue:	Issue:
M001	MBNL	3UK DNSW	Planning	A
Date:	01/02/2020	Revision / Upgrade Description:		
Drawn:	CDN	First Issue - Site nomination dated: TBC		
Checked:	DH			
Approved:	SD			

CK Hutchison
Networks (UK)
Limited
Great Brighams Mead,
Vastern Road, Reading,
Berkshire, England,
RG1 8DJ



WHP Telecoms
Unit 1 Maple Park,
Low Fields Avenue, Leeds
LS12 6HH
Tel: 01133023550
e-mail: info@whptelecoms.com

Site Name:
SILVERLACE AVENUE STREETWORKS

Site ID:
MAN12080

Address:
SILVERLACE AVENUE,
ABBHEY HEY,
CLAYTON,
MANCHESTER,
M11 1JE

Title:
150 EXISTING ELEVATION A

Project:
3UK DNSW

Purpose of Issue:
PLANNING

EE Cell ID:	MBNL Cell ID:	Cell ID:
65762	MAN473	M0203
Master Drawing No:		Issue:
MAN12080_M003		C



Antenna Aperture ID	Proposed 4G/5G Bearing
A1	340°
A2	340°
B1	100°
B2	100°
C1	220°
C2	220°

NOTES:
1. ALL DIMENSIONS IN MM UNLESS OTHERWISE NOTED.

Master:	MBNL / EE:	Project:	Purpose of Issue:	Issue:
M003	MBNL	3UK DNSW	Planning	C
Date:	06/02/2023	Revision / Upgrade Description:		
Drawn:	CDN	Pole location amended		
Checked:	DH			
Approved:	SD			

Master:	MBNL / EE:	Project:	Purpose of Issue:	Issue:
M002	MBNL	3UK DNSW	Planning	B
Date:	01/02/2021	Revision / Upgrade Description:		
Drawn:	CDN	Amended		
Checked:	DH			
Approved:	SD			

Master:	MBNL / EE:	Project:	Purpose of Issue:	Issue:
M001	MBNL	3UK DNSW	Planning	A
Date:	01/02/2020	Revision / Upgrade Description:		
Drawn:	CDN	First Issue - Site nomination dated: TBC		
Checked:	DH			
Approved:	SD			

CK Hutchison Networks (UK) Limited

Great Brighams Mead,
Vastern Road, Reading,
Berkshire, England,
RG1 8DJ

Design Consultant & Principal Contractor:

WHP

WHP Telecoms
Unit 1 Maple Park,
Low Fields Avenue, Leeds
LS12 6HH

Tel: 01133023550
e-mail: info@whptelecoms.com

Site Name:
SILVERLACE AVENUE STREETWORKS

Site ID:
MAN12080

Address:
SILVERLACE AVENUE,
ABBAY HEY,
CLAYTON,
MANCHESTER,
M11 1JE


Title:
210 PROPOSED SITE PLAN

Project:
3UK DNSW


Purpose of Issue:
PLANNING

EE Cell ID: 65762	MBNL Cell ID: MAN473	Cell ID: M0203
----------------------	-------------------------	-------------------

Master Drawing No: MAN12080_M003	Issue: C
-------------------------------------	-------------

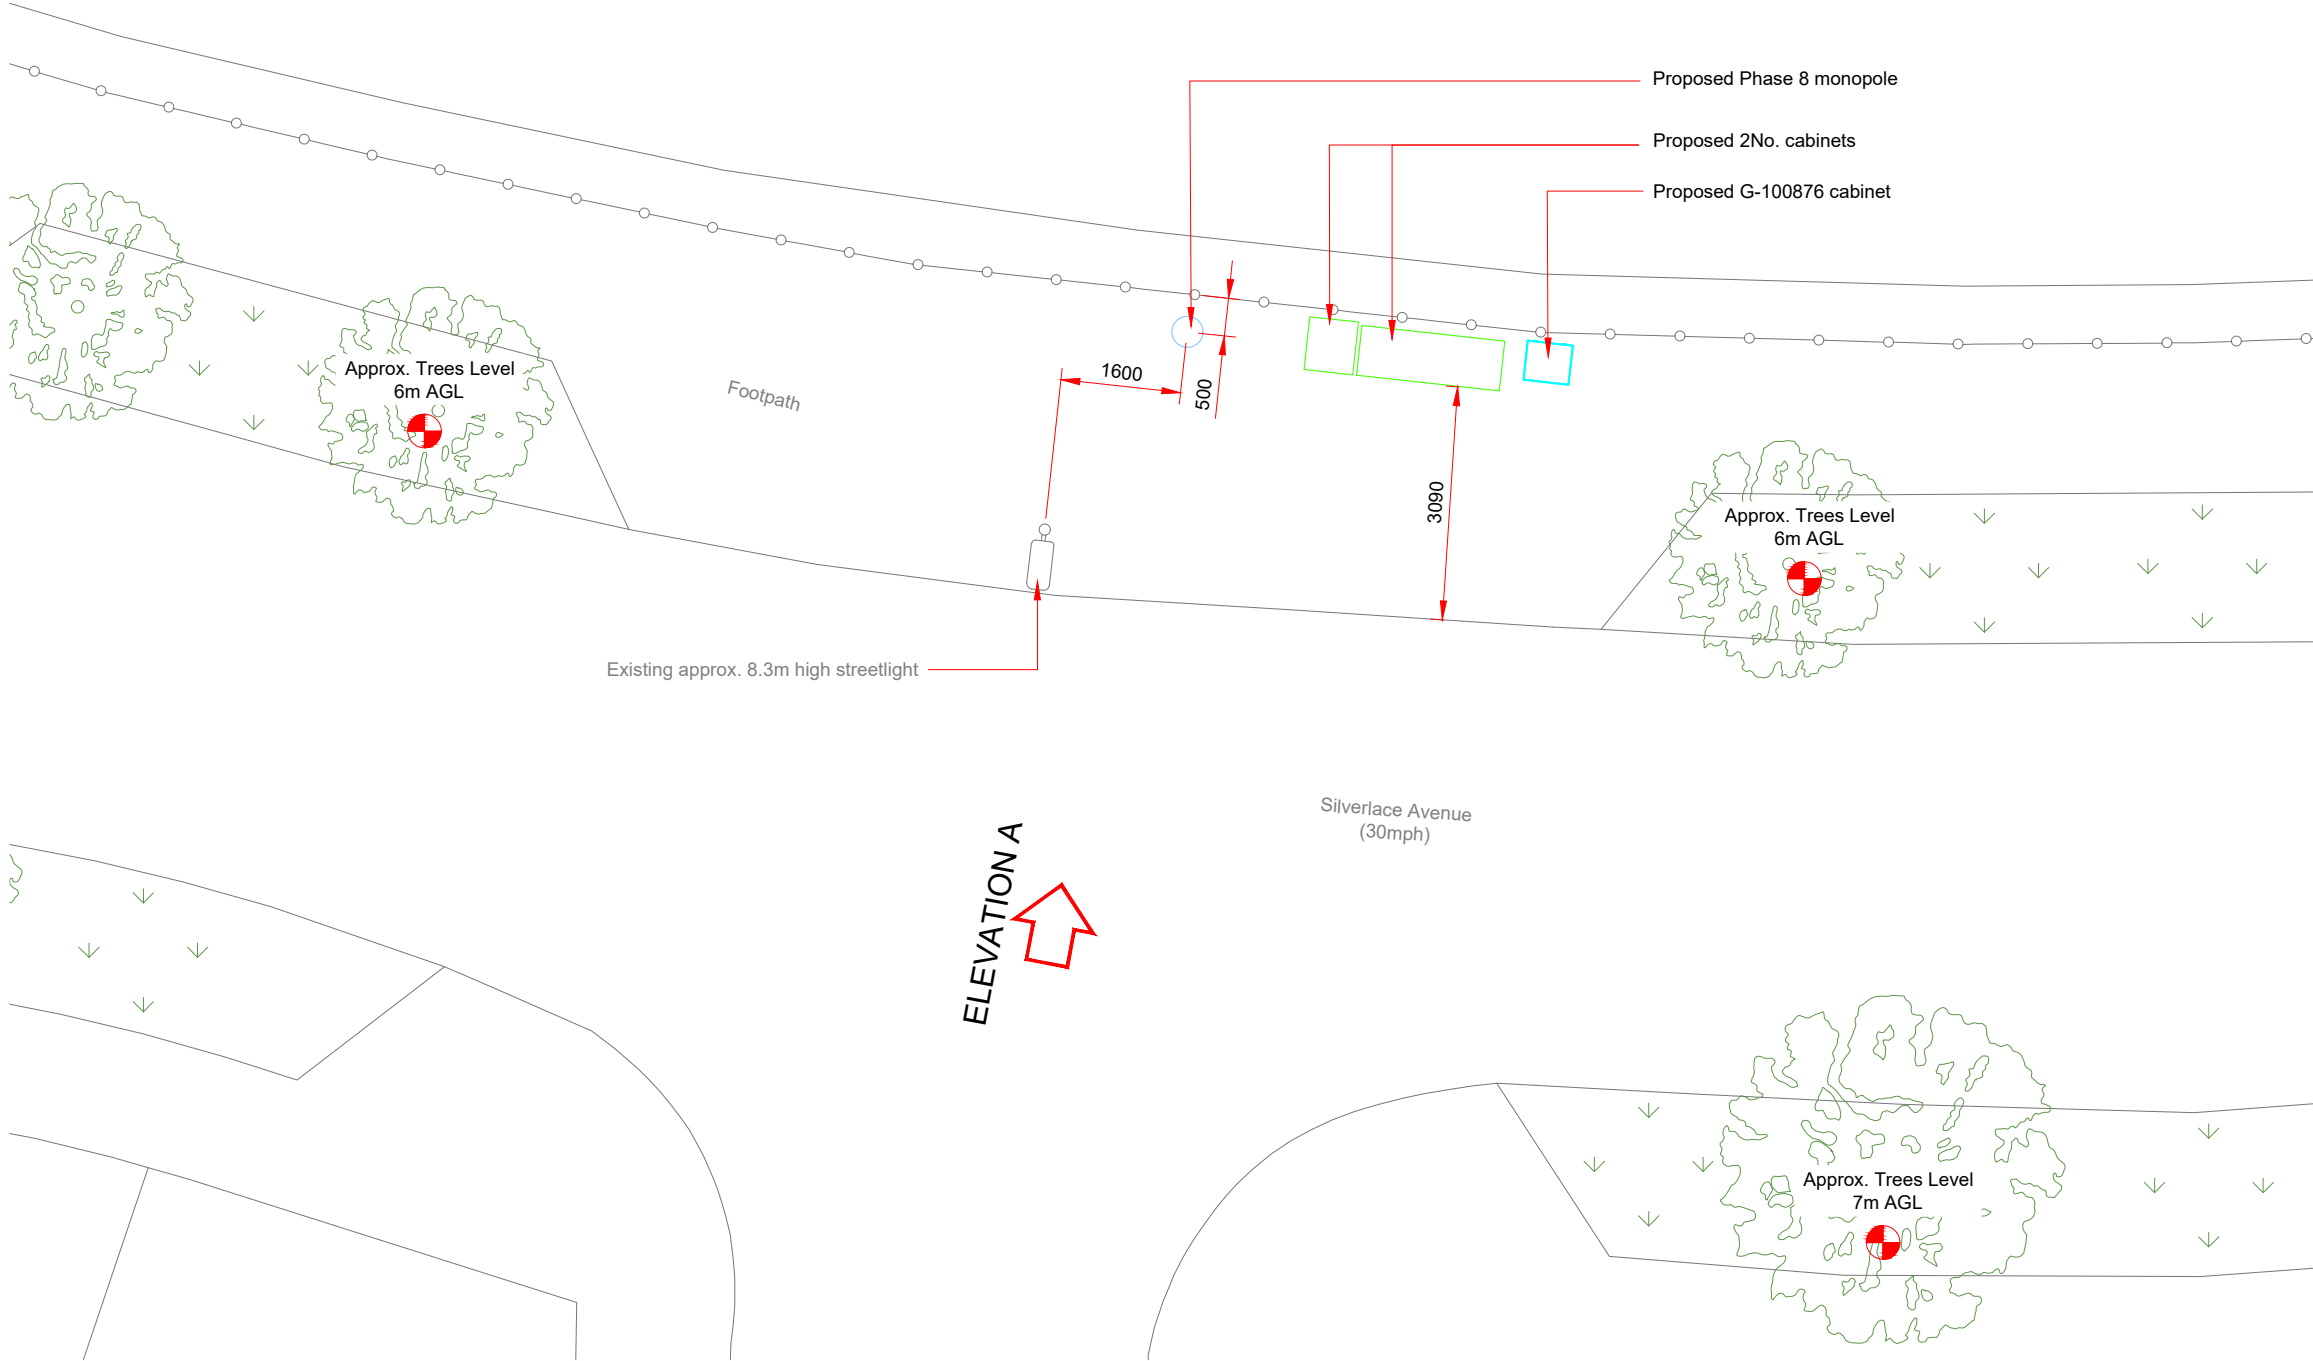

PROPOSED SITE PLAN

 

100mm


150mm

10mm

Antenna Aperture ID	Proposed 4G/5G Bearing
A1	340°
A2	340°
B1	100°
B2	100°
C1	220°
C2	220°

NOTES:

1. ALL DIMENSIONS IN MM UNLESS OTHERWISE NOTED.

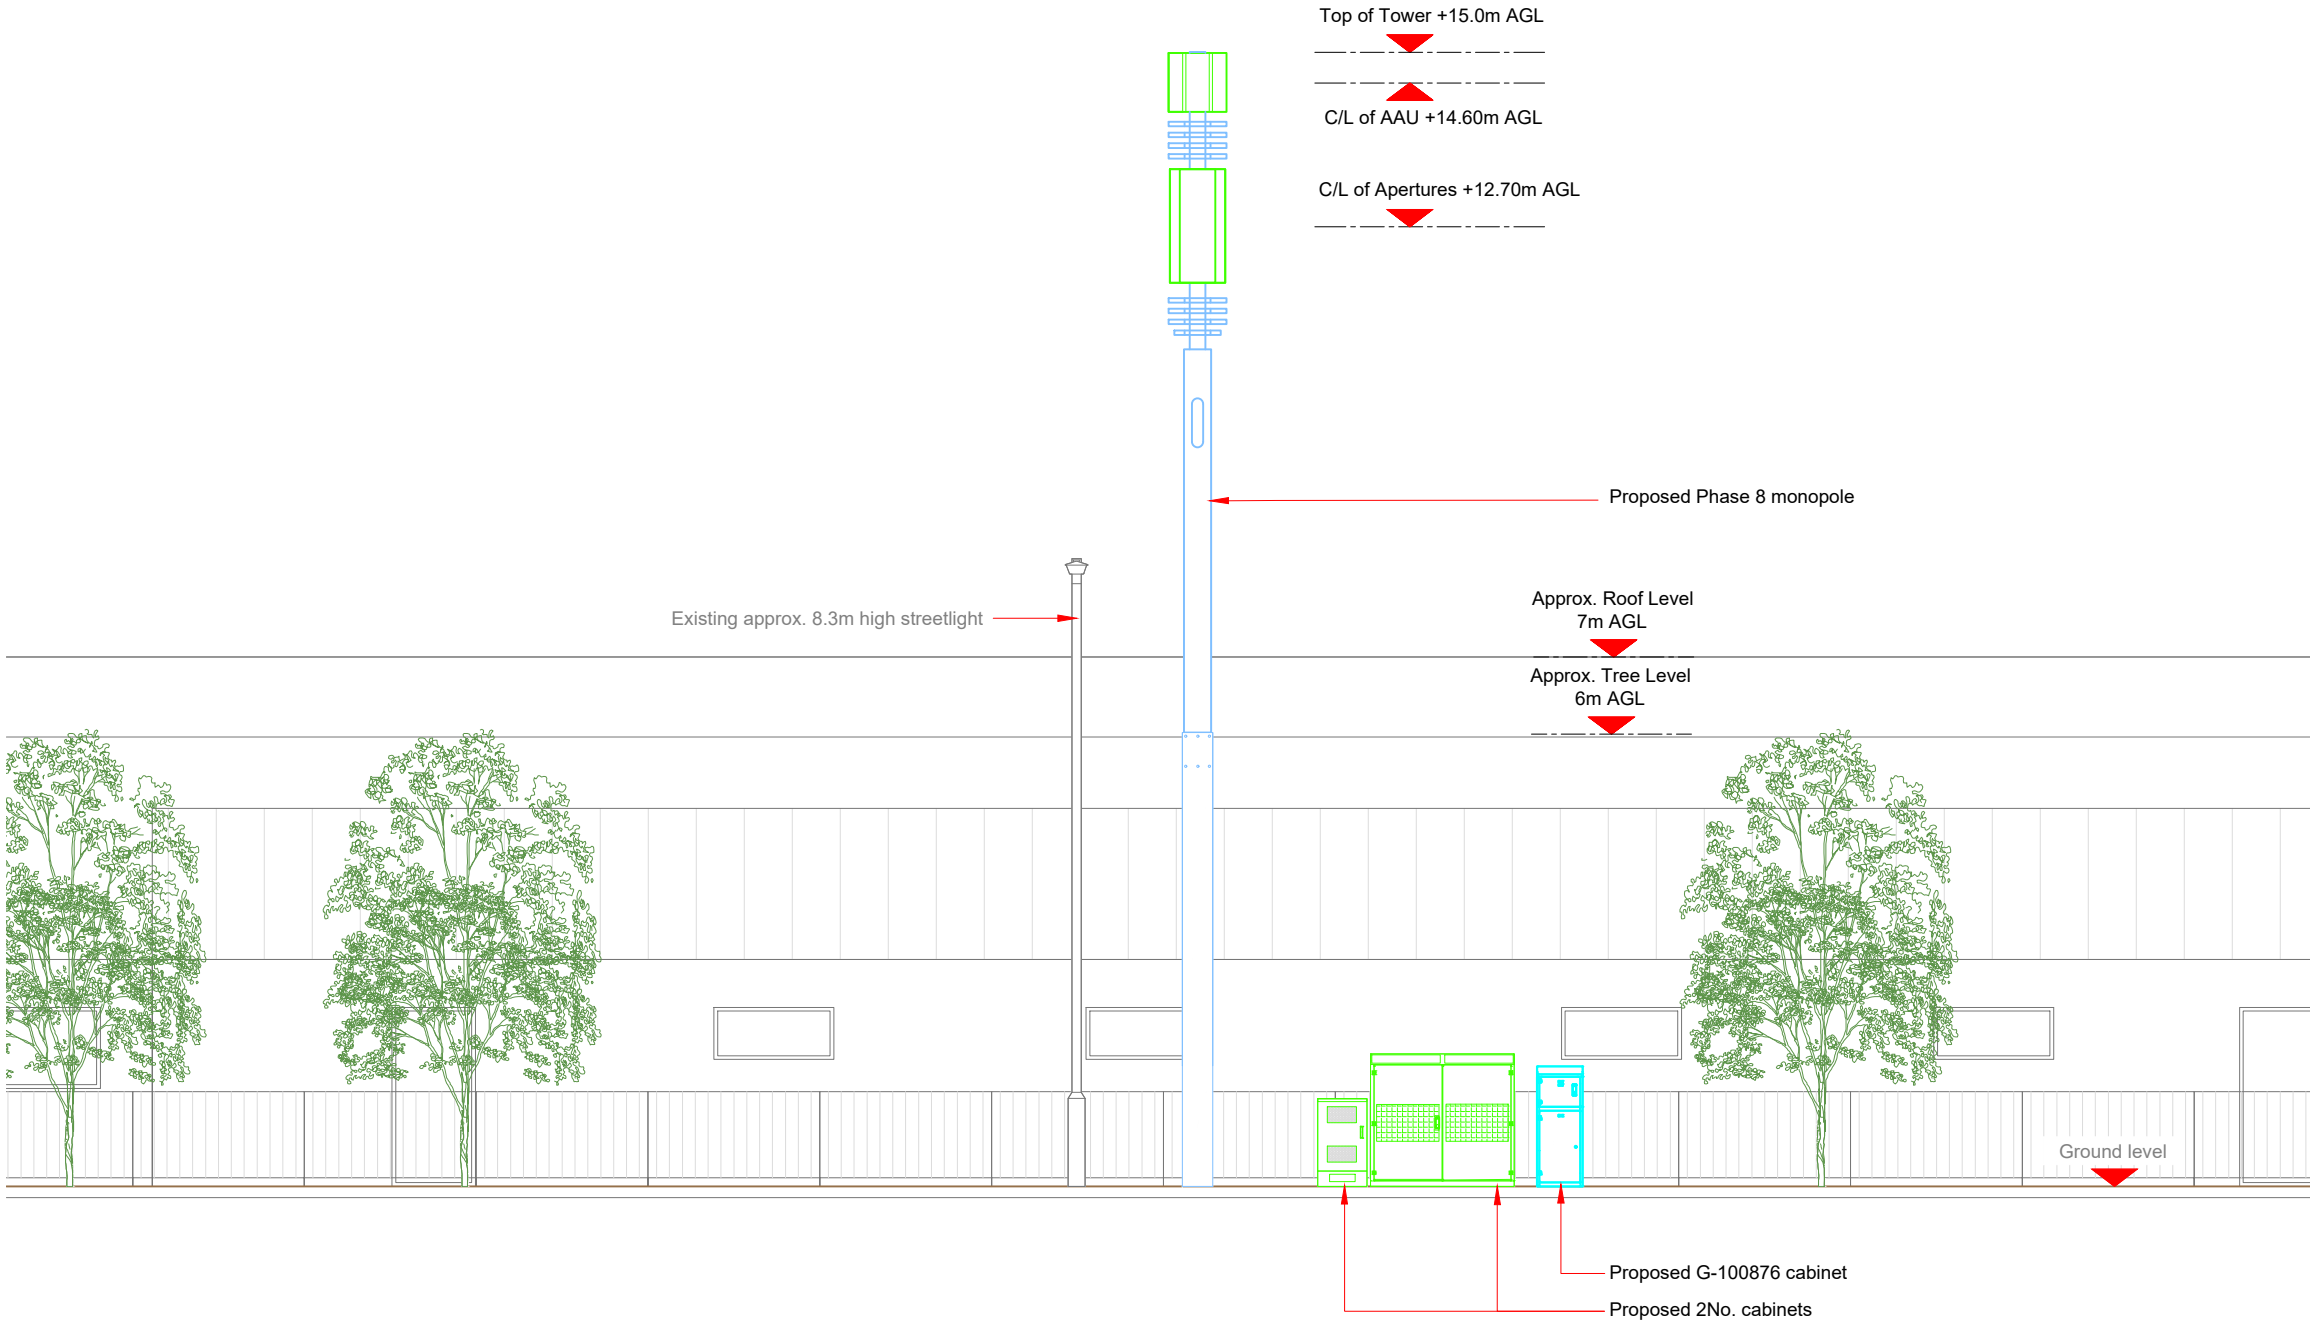

Master:	MBNL / EE:	Project:	Purpose of Issue:	Issue:
M003	MBNL	3UK DNSW	Planning	C
Date:	06/02/2023	Revision / Upgrade Description:		
Drawn:	CDN	Pole location amended		
Checked:	DH			
Approved:	SD			
Master:	MBNL / EE:	Project:	Purpose of Issue:	Issue:
M002	MBNL	3UK DNSW	Planning	B
Date:	01/02/2021	Revision / Upgrade Description:		
Drawn:	CDN	Amended		
Checked:	DH			
Approved:	SD			
Master:	MBNL / EE:	Project:	Purpose of Issue:	Issue:
M001	MBNL	3UK DNSW	Planning	A
Date:	01/02/2020	Revision / Upgrade Description:		
Drawn:	CDN	First Issue - Site nomination dated: TBC		
Checked:	DH			
Approved:	SD			

**CK Hutchison
Networks (UK)
Limited**

Great Brighams Mead,
Vastern Road, Reading,
Berkshire, England,
RG1 8DJ

Design Consultant & Principal Contractor:



WHP Telecoms

Unit 1 Maple Park,
Low Fields Avenue, Leeds
LS12 6HH

Tel: 01133023550
e-mail: info@whptelecoms.com

Site Name:
SILVERLACE AVENUE STREETWORKS

Site ID:
MAN12080

Address:
**SILVERLACE AVENUE,
ABBAY HEY,
CLAYTON,
MANCHESTER,
M11 1JE**

Title:
260 PROPOSED ELEVATION

Project:
3UK DNSW

Purpose of Issue:
PLANNING

EE Cell ID:	MBNL Cell ID:	Cell ID:
65762	MAN473	M0203

Master Drawing No:	Issue:
MAN12080_M003	C