



LEGEND	
	NEW PIPEWORK
	EXISTING PIPEWORK
	CONDENSATE PIPEWORK
	FAN COIL UNIT

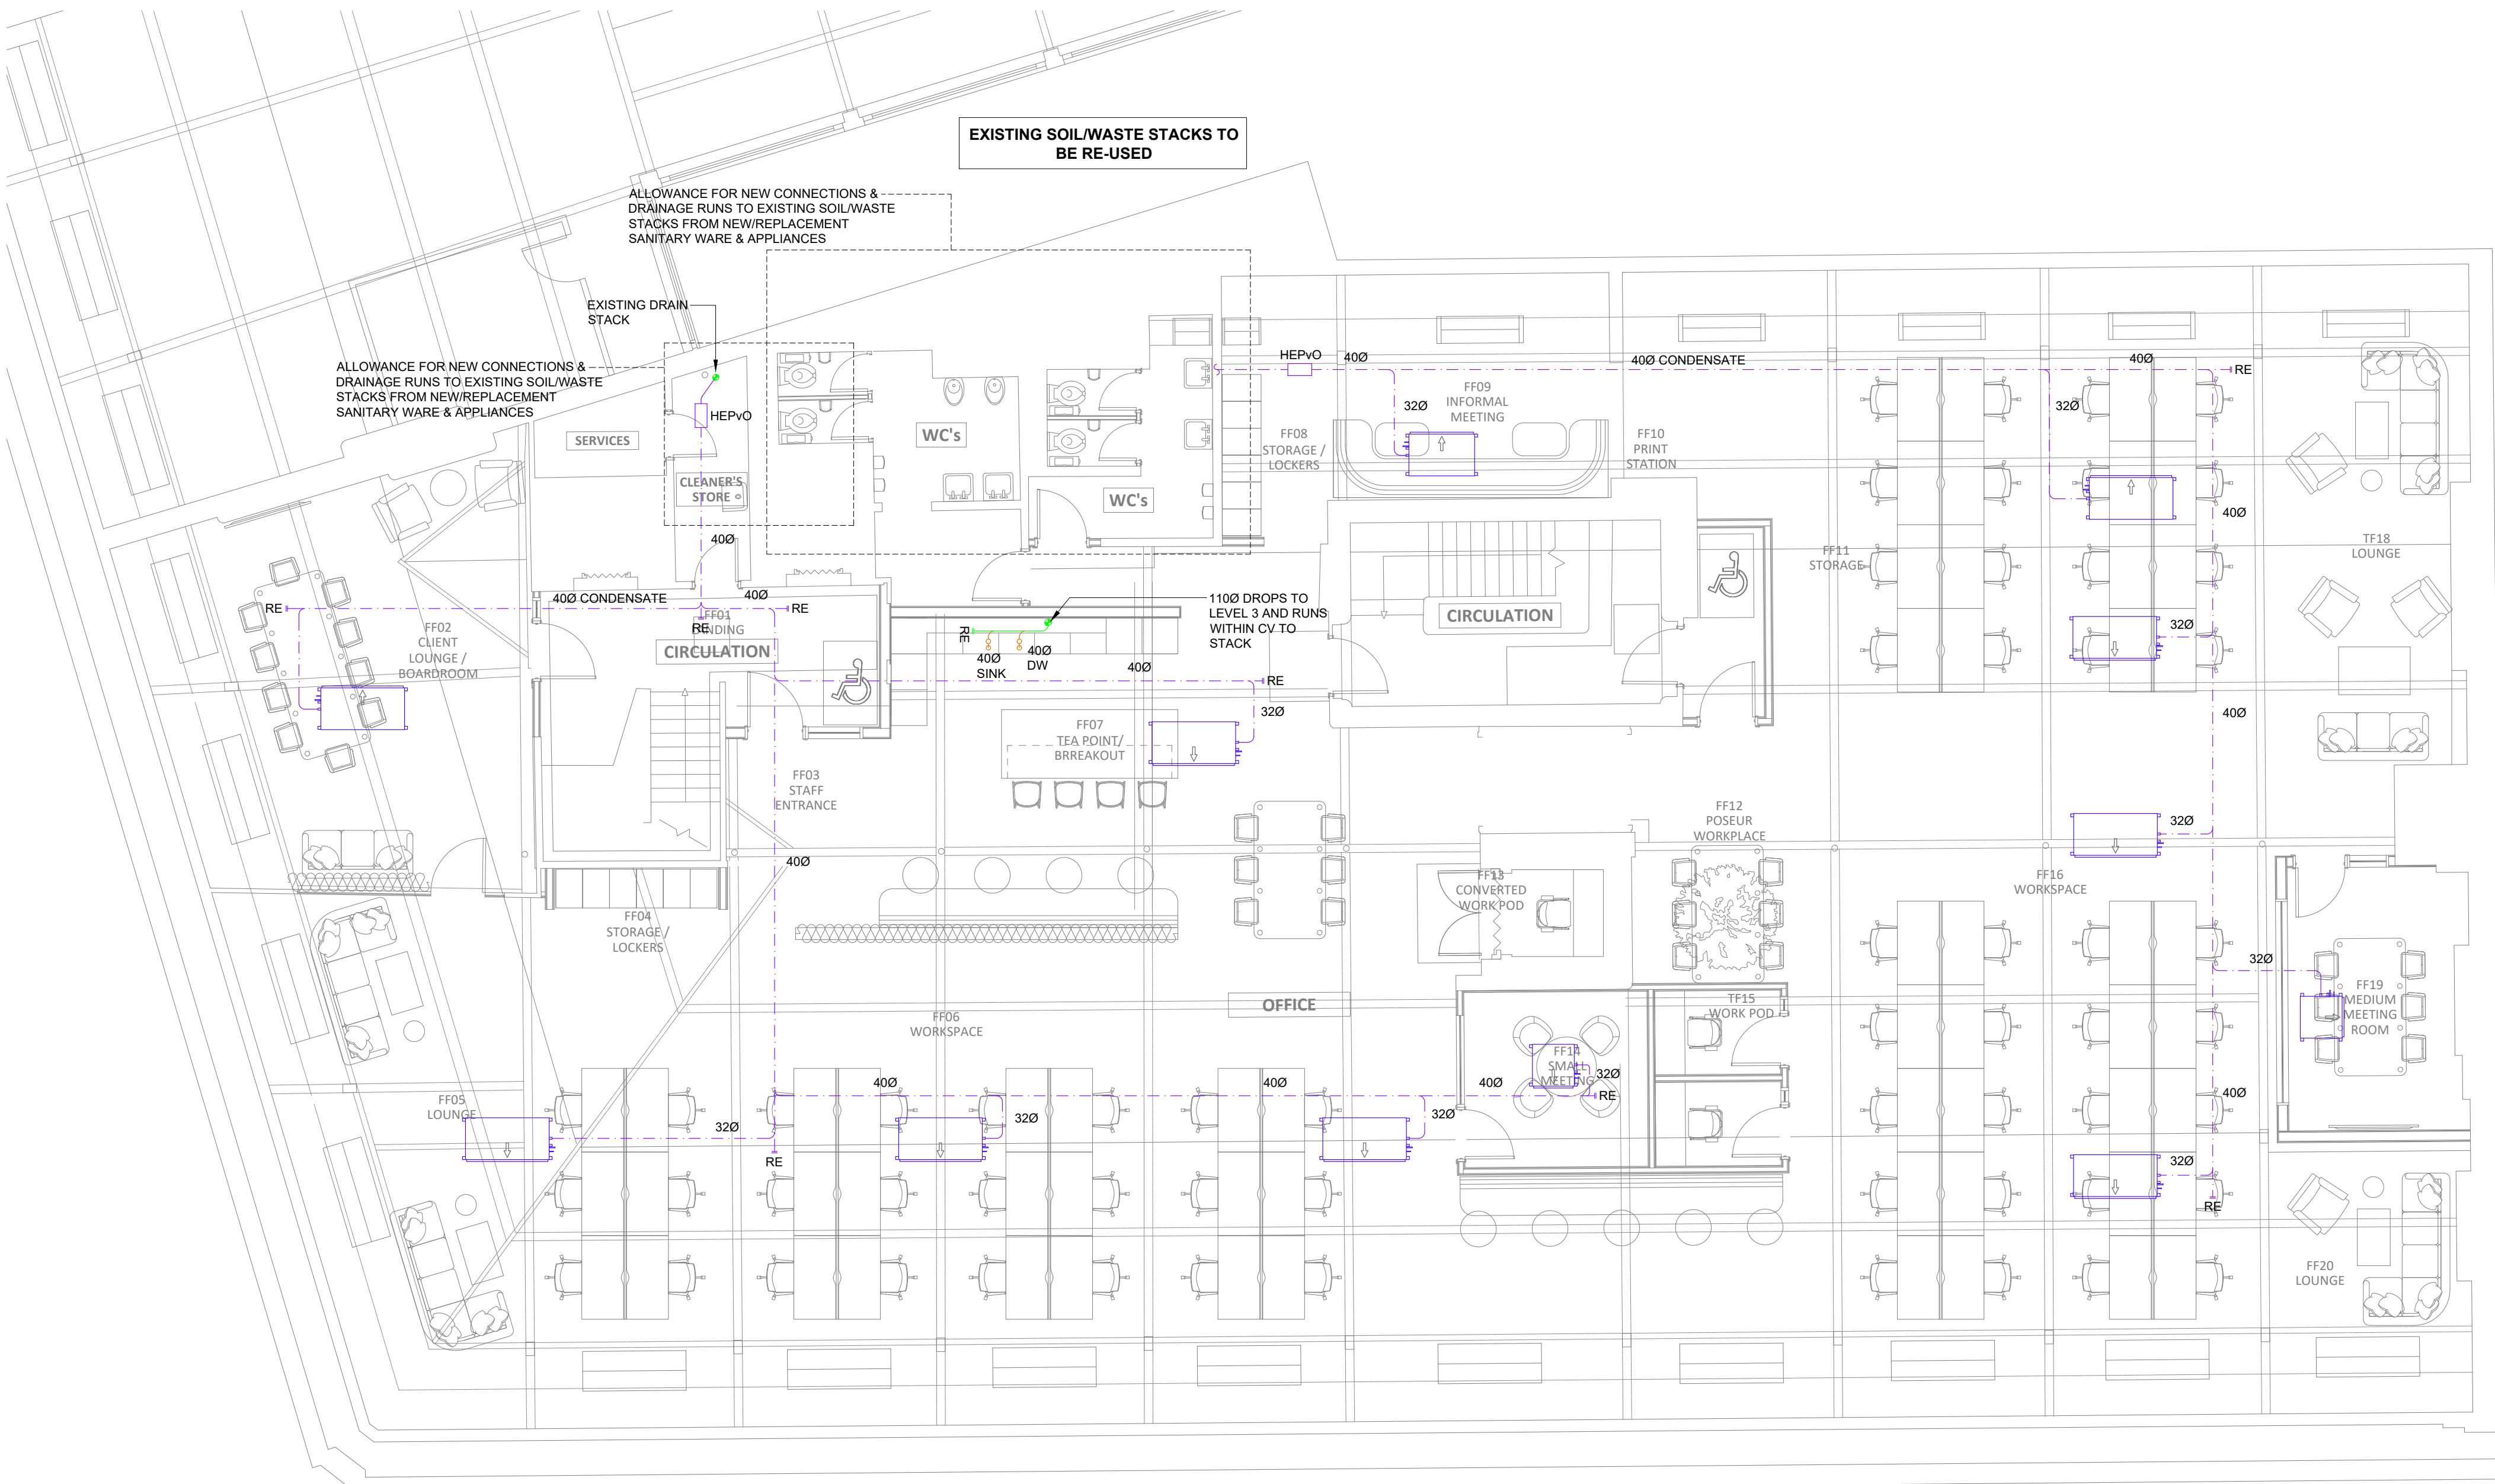

PROPOSED FOURTH FLOOR

P1	ISSUE FOR PLANNING	SR	17.05.24
REV	DESCRIPTION	BY	DATE

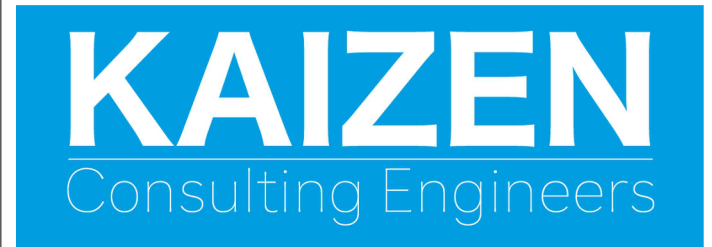

www.kaizen-ce.com [e: info@kaizen-ce.com](mailto:info@kaizen-ce.com)

CLIENT
bruntwood
SciTech

ARCHITECT
A X I

PROJECT
117-119 PORTLAND STREET
MANCHESTER

DRAWING TITLE
MECHANICAL SERVICES
FOURTH FLOOR
ABOVE GROUND DRAINAGE LAYOUT

CHECKED	DATE	DRAWN	SCALE
SR	FEB 24	MN	1:75@A1

STAGE 4

DRAWING NUMBER	STATUS	REV.
1168-KCE-ZZ-04-DR-M-5205	S4	P1