

NOTICE

THIS DRAWING INCLUDING THE PRINCIPLES OF DESIGN, REMAINS THE PROPERTY OF HAYVERN ELECTRICAL LTD. AND IS ISSUED ON THE UNDERSTANDING THAT IT IS NOT REPRODUCED OR LOANED IN PART OR WHOLE EXCEPT WITH THE OWNERS WRITTEN CONSENT. IT IS NOT TO BE USED IN ANY MANNER THAT MAY BE DETRIMENTAL TO HAYVERN ELECTRICAL LTD. ACCEPTANCE OF THIS DRAWING WILL BE CONSTRUED AS AN AGREEMENT OF THE ABOVE.

GENERAL NOTES


1.0 THE DRAWING SHALL BE READ IN CONJUNCTION WITH THE SPECIFICATION & ALL OTHER RELEVANT DOCUMENTS

CONTAINMENT LEGEND


- 100mm (UNLESS INDICATED) LIGHTING & POWER TRAY.
- 225mm (UNLESS INDICATED) SUB MAINS TRAY.
- 150mm (UNLESS INDICATED) BT/DATA/COMMS/FIRE ALARM/SECURITY BASKET WITH DIVIDERS.
- TP&N DISTRIBUTION BOARD.
- SP&N DISTRIBUTION BOARD.
- H.D.H.C. COPPER EARTH BAR.
- CONTAINMENT RISE/DROP.
- SWITCH PANEL.
- LOCKABLE ROTARY ISOLATOR SIZED AS SHOWN.
- REGIONAL ELECTRICITY COMPANY (R.E.C.) CABLE/SERVICE HEAD.
- REGIONAL ELECTRICITY COMPANY (R.E.C.) METER.
- INCOMING TELECOMS TERMINATION POINT.
- DATA/COMMUNICATIONS CABINET.
- DENOTES WEATHERPROOF TYPE.

GENERAL LEGEND

- L/L ITEM MOUNTED AT LOW LEVEL.
- H/L ITEM MOUNTED AT HIGH LEVEL.
- C/V ITEM MOUNTED IN CEILING VOID.
- R/V ITEM MOUNTED IN ROOF VOID.
- F/V ITEM MOUNTED IN FLOOR VOID.
- W/T ITEM MOUNTED AT WORKTOP LEVEL.
- WP DENOTES WEATHERPROOF IP65 TYPE SUITABLE FOR EXTERNAL USE.
- EX DENOTES EXISTING TO BE RETAINED.
- R DENOTES EXISTING TO BE RELOCATED.
- R.T.A. RISE TO ABOVE.
- R.F.B. RISE FROM BELOW.
- D.F.A. DROP FROM ABOVE.
- D.T.B. DROP TO BELOW.

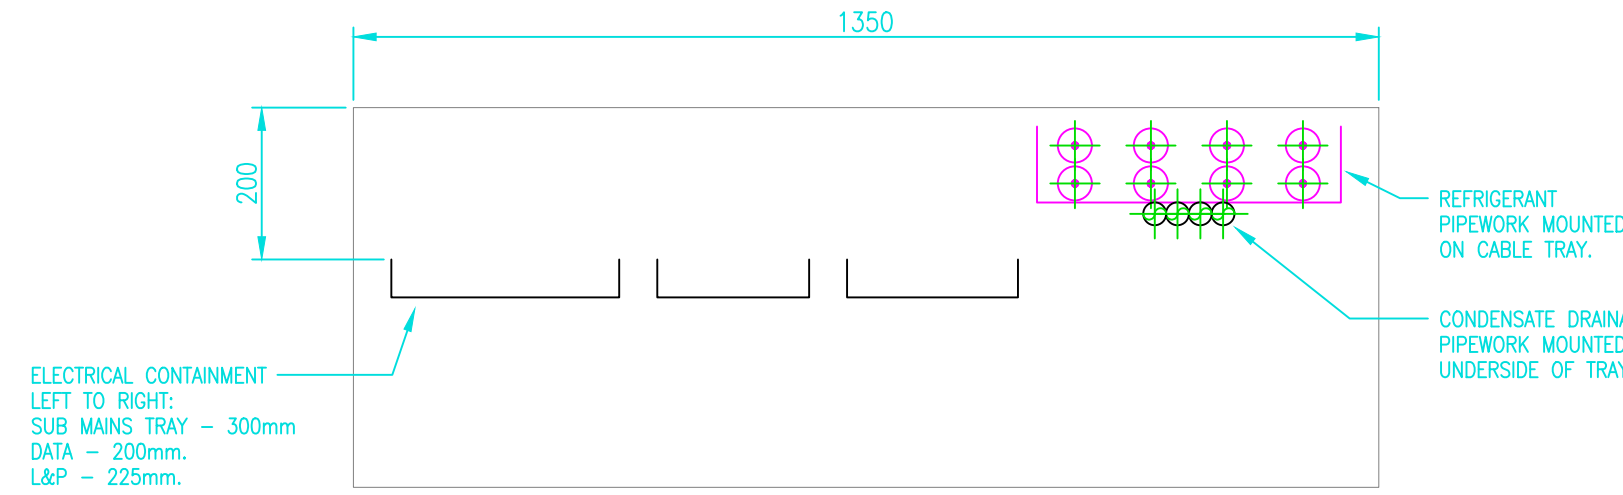

INDICATIVE SECTION A-A
SCALE 1 : 10

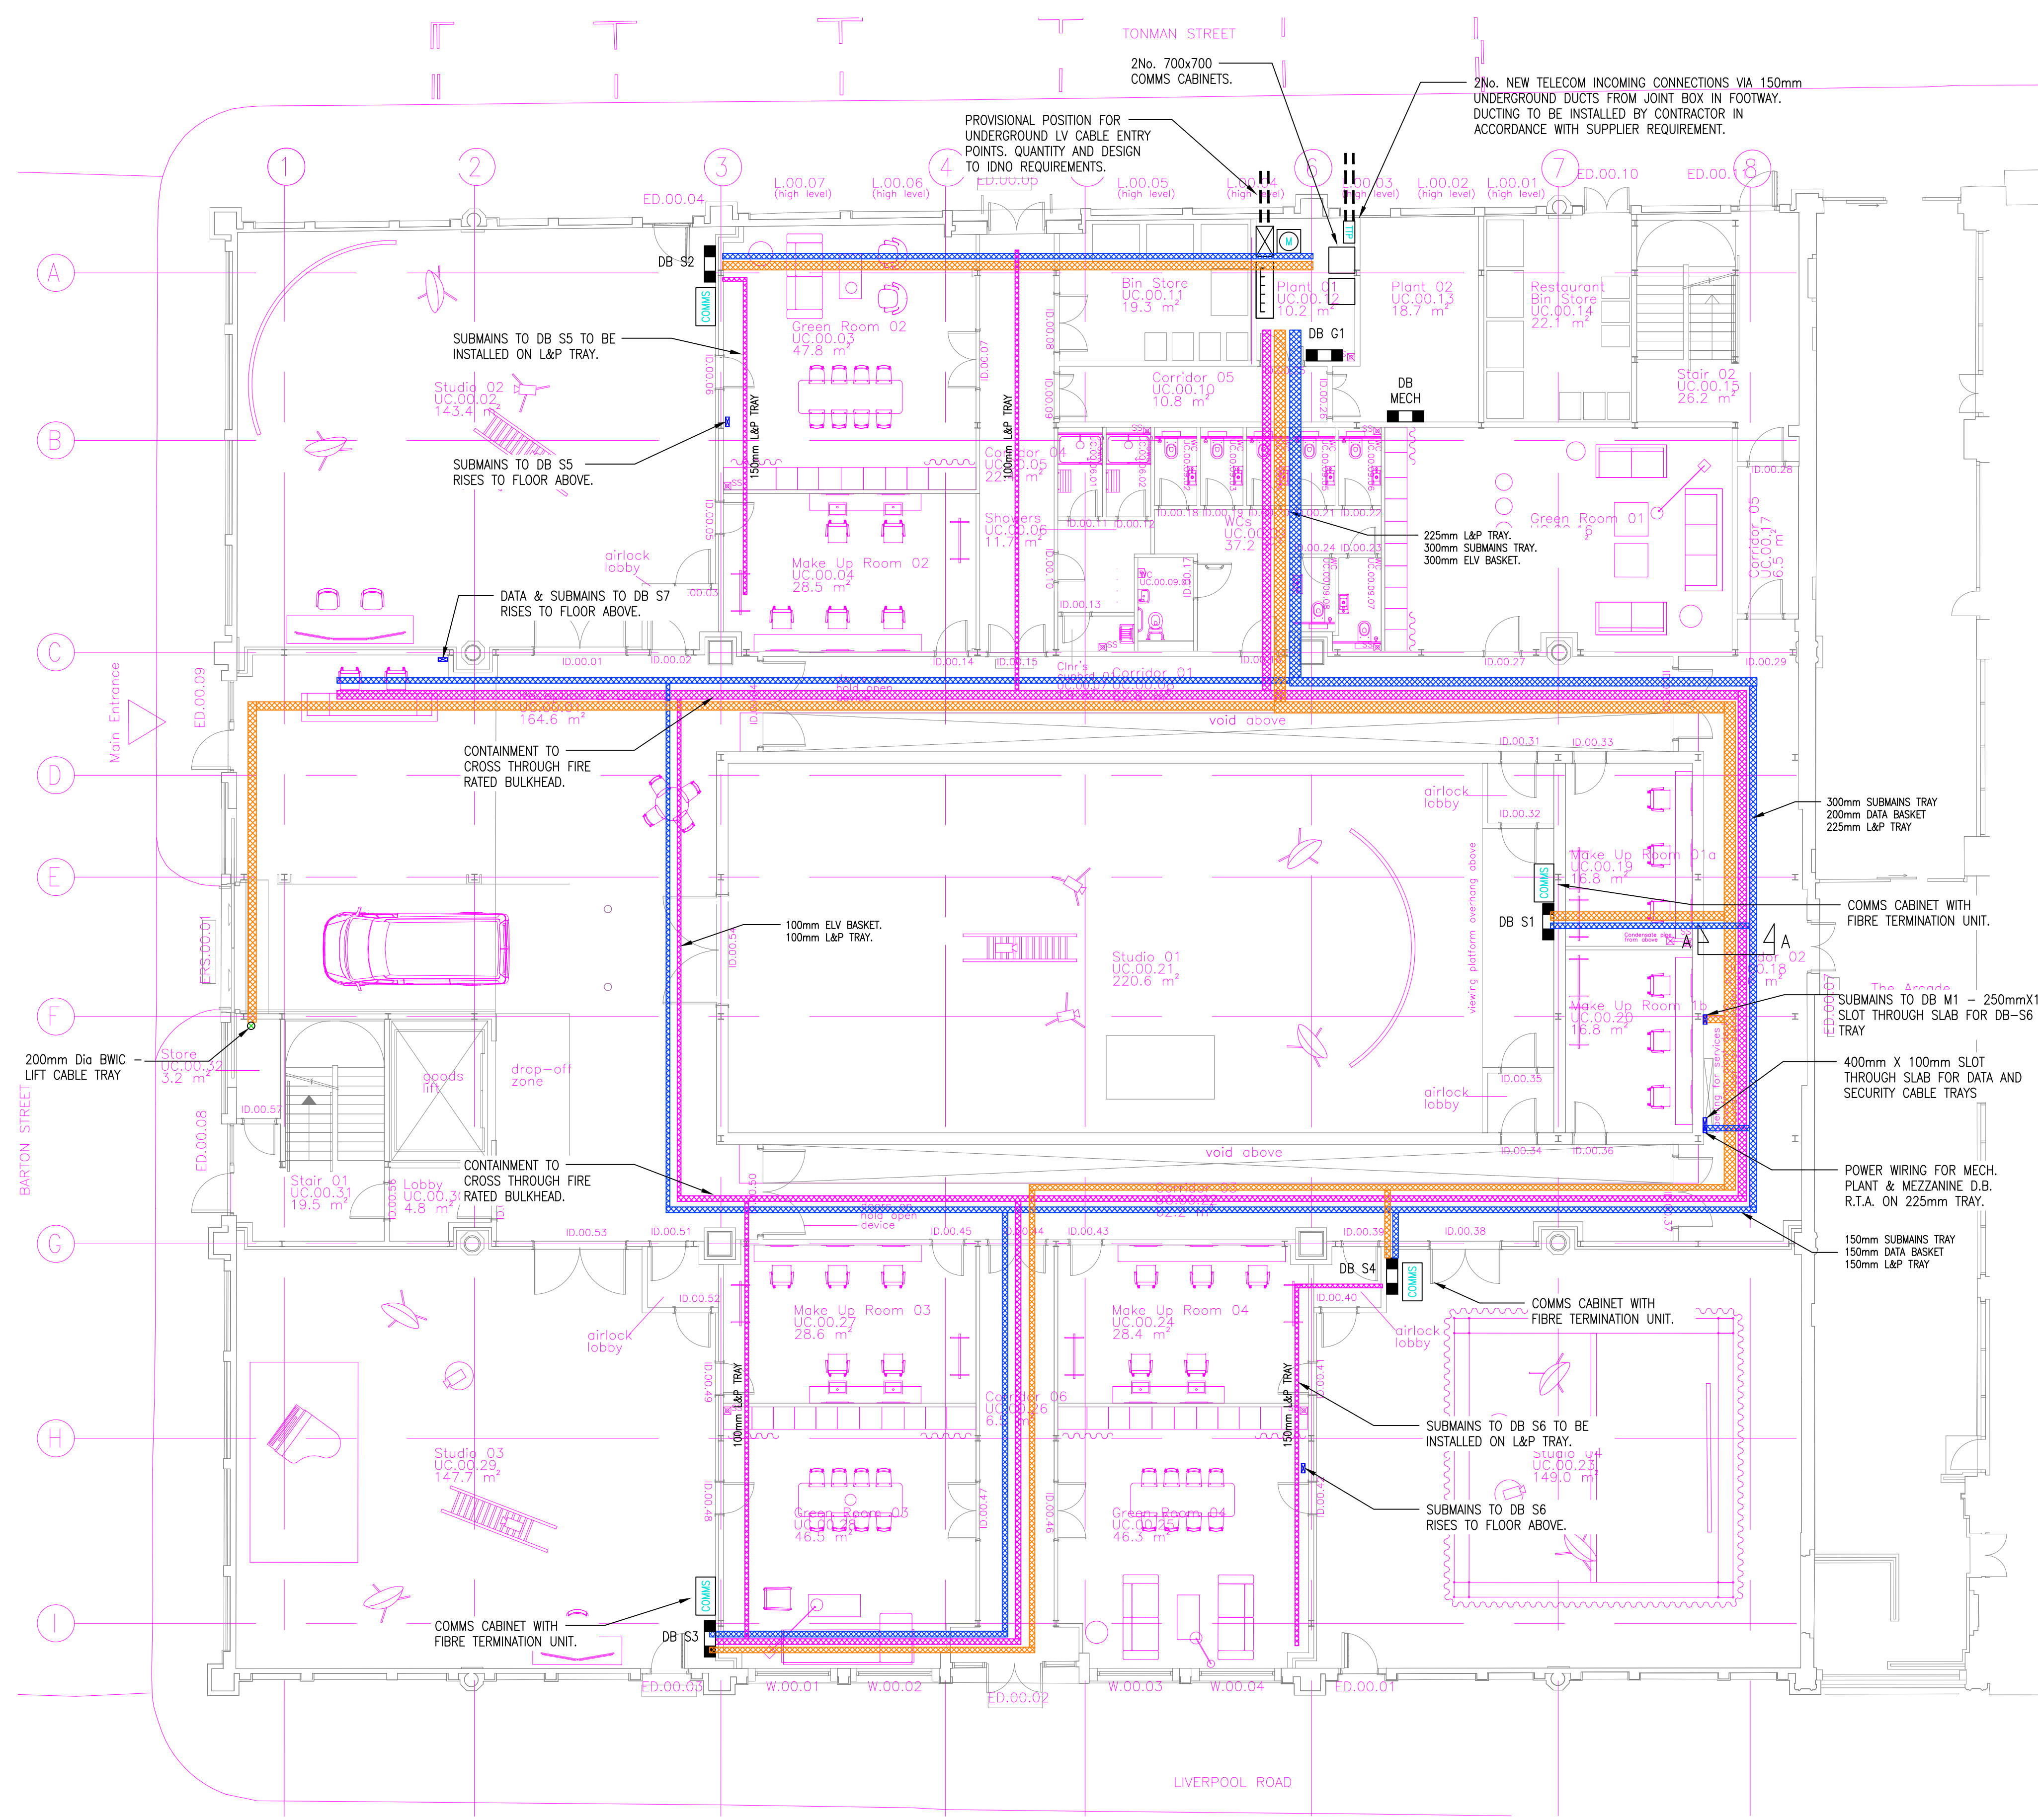

UPPER CAMPFIELD GROUND FLOOR PLAN

Revisions	Description	Ref	Eng	Date
 56 QUEEN STREET, FARNWORTH, BOLTON, 01204 579975				
Client	TJM			
Project Title	UPPER CAMPFIELD			
Drawing Title	CONTAINMENT GROUND FLOOR			
In Association with	—			
Drawn by	SB	Scales	1:100	
Checked by	DC		(work to figured dimensions)	
Date	25.04.24			
DRG No.	C4488/E004			Rev. P2