

GENERAL BULB SPECS:

- LP05 // E27 lampholder cap, gold, 1800K, 170lm, 2.5W. Available from SLD lighting
- LP06 // E27 lampholder cap, gold, 2100K, 320lm, 4W. Available from SLD lighting
- LP07 // E27 lampholder cap, warm white, 2700K, 806lm, 7W, LED. Available from Phillips
- LP14 // Lurra, T38, E27 lampholder cap, 2200K, 240lm, 3W, LED. Available from Tala

SOCKET REFERENCES	
S5	13amp fused spur finish in brushed chrome - refer to drawing for installation heights
S6	Knightsbridge screwed 13Amp 2 Gang Switched Socket with USB & USB C Charger Brushed Chrome with Black Insert. installed 450mm above FFL unless stated otherwise
S9	13amp single switched socket outlet finished in white. Installed at 450mm AFFL unless stated otherwise

GENERAL POWER NOTES

DIMENSIONS:
ALL SETTING OUT DIMS TAKEN FROM WALL LININGS

STANDARD ELECTRICAL SETTING OUT NOTE

- For Back of House electrical setting out, refer to drawing 11.0
- For Counter electrical setting out, refer to ITAB standard details

GENERAL LIGHTING NOTES

NOTE:
ALL LIGHTING DIMENSIONS TAKEN FROM PLASTERED WALL/BULKHEAD/DEMISE LINE

GENERAL LIGHTING NOTES:

- MAIN CONTRACTOR TO ENSURE LIGHTING IS LINKED TO MAIN CIRCUIT & LMO SWITCH BOARD
- PM TO ADVISE ON FINAL CCTV POSITION & MC TO ALLOW FOR POWER ADJACENT

NOTE: ALL EMERGENCY LIGHTING TO BE SUPPLIED BY MAIN CONTRACTOR

MOODMEDIA & PM NOTE:
PM TO LIAISE WITH MOODMEDIA TO ENSURE THE CORRECT COLOUR SPEAKERS ARE ORDERED ON A SITE PER SITE BASIS
WHITE SPEAKERS ARE TO BE INSTALLED WITH A CF1 CEILING

CEILING FINISH REFERENCES

A	Allow to retain extg MF ceiling and make good. Allow to decorate in 1no mist & 2no coats Dulux Scuffshield Matt
---	---

CEILING FINISH COLOUR REFERENCES

CF3	DULUX SCUFFSHIELD MATT JASMINE WHITE 0302-Y41R (RAL 9010)	
-----	---	--

1080
INDICATES SETTING OUT & TRACK LIGHTING LENGTH DIMENSION

1080
INDICATES POWER SETTING OUT DIMENSION

TRACK LIGHT POSITION KEY


A	Artwork
F	Floor
C	Counter

LP41 // - MINI LED TRACK LIGHT

PRODUCT CODE: 101626
DETAIL: Saxby spec Coiled Track Head, 15w, 1700 lm, 113 lm/w, 3000K
COLOUR: White
See drawing for specific lengths



Core Line Batten (Back of House)

PRODUCT: Phillips BN126C LED74S/830 WIA L1500, 116 lm/w, 3000K
COLOUR: White
Size: 1450mm length x 65mm width x 65mm depth
See drawing for specific lengths
Height of lighting: 2850mm FFL to underside of batten

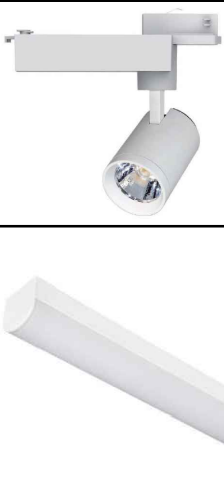

NOTE:
TO BE READ IN CONJUNCTION WITH LATEST DESIGN GUIDE

This drawing is the copyright of Street Eile Associates Limited. Do not scale from drawings. All dimensions and levels to be checked on site prior to commencement of work or manufacture of items. Notify SEA of any discrepancies. This drawing to be read in conjunction with specifications, specialist drawings and any bill of quantities. The Contractor is to comply with all relevant statutory legislation whether or not specifically stated on these drawings.

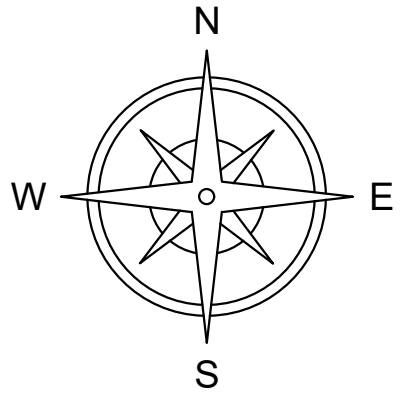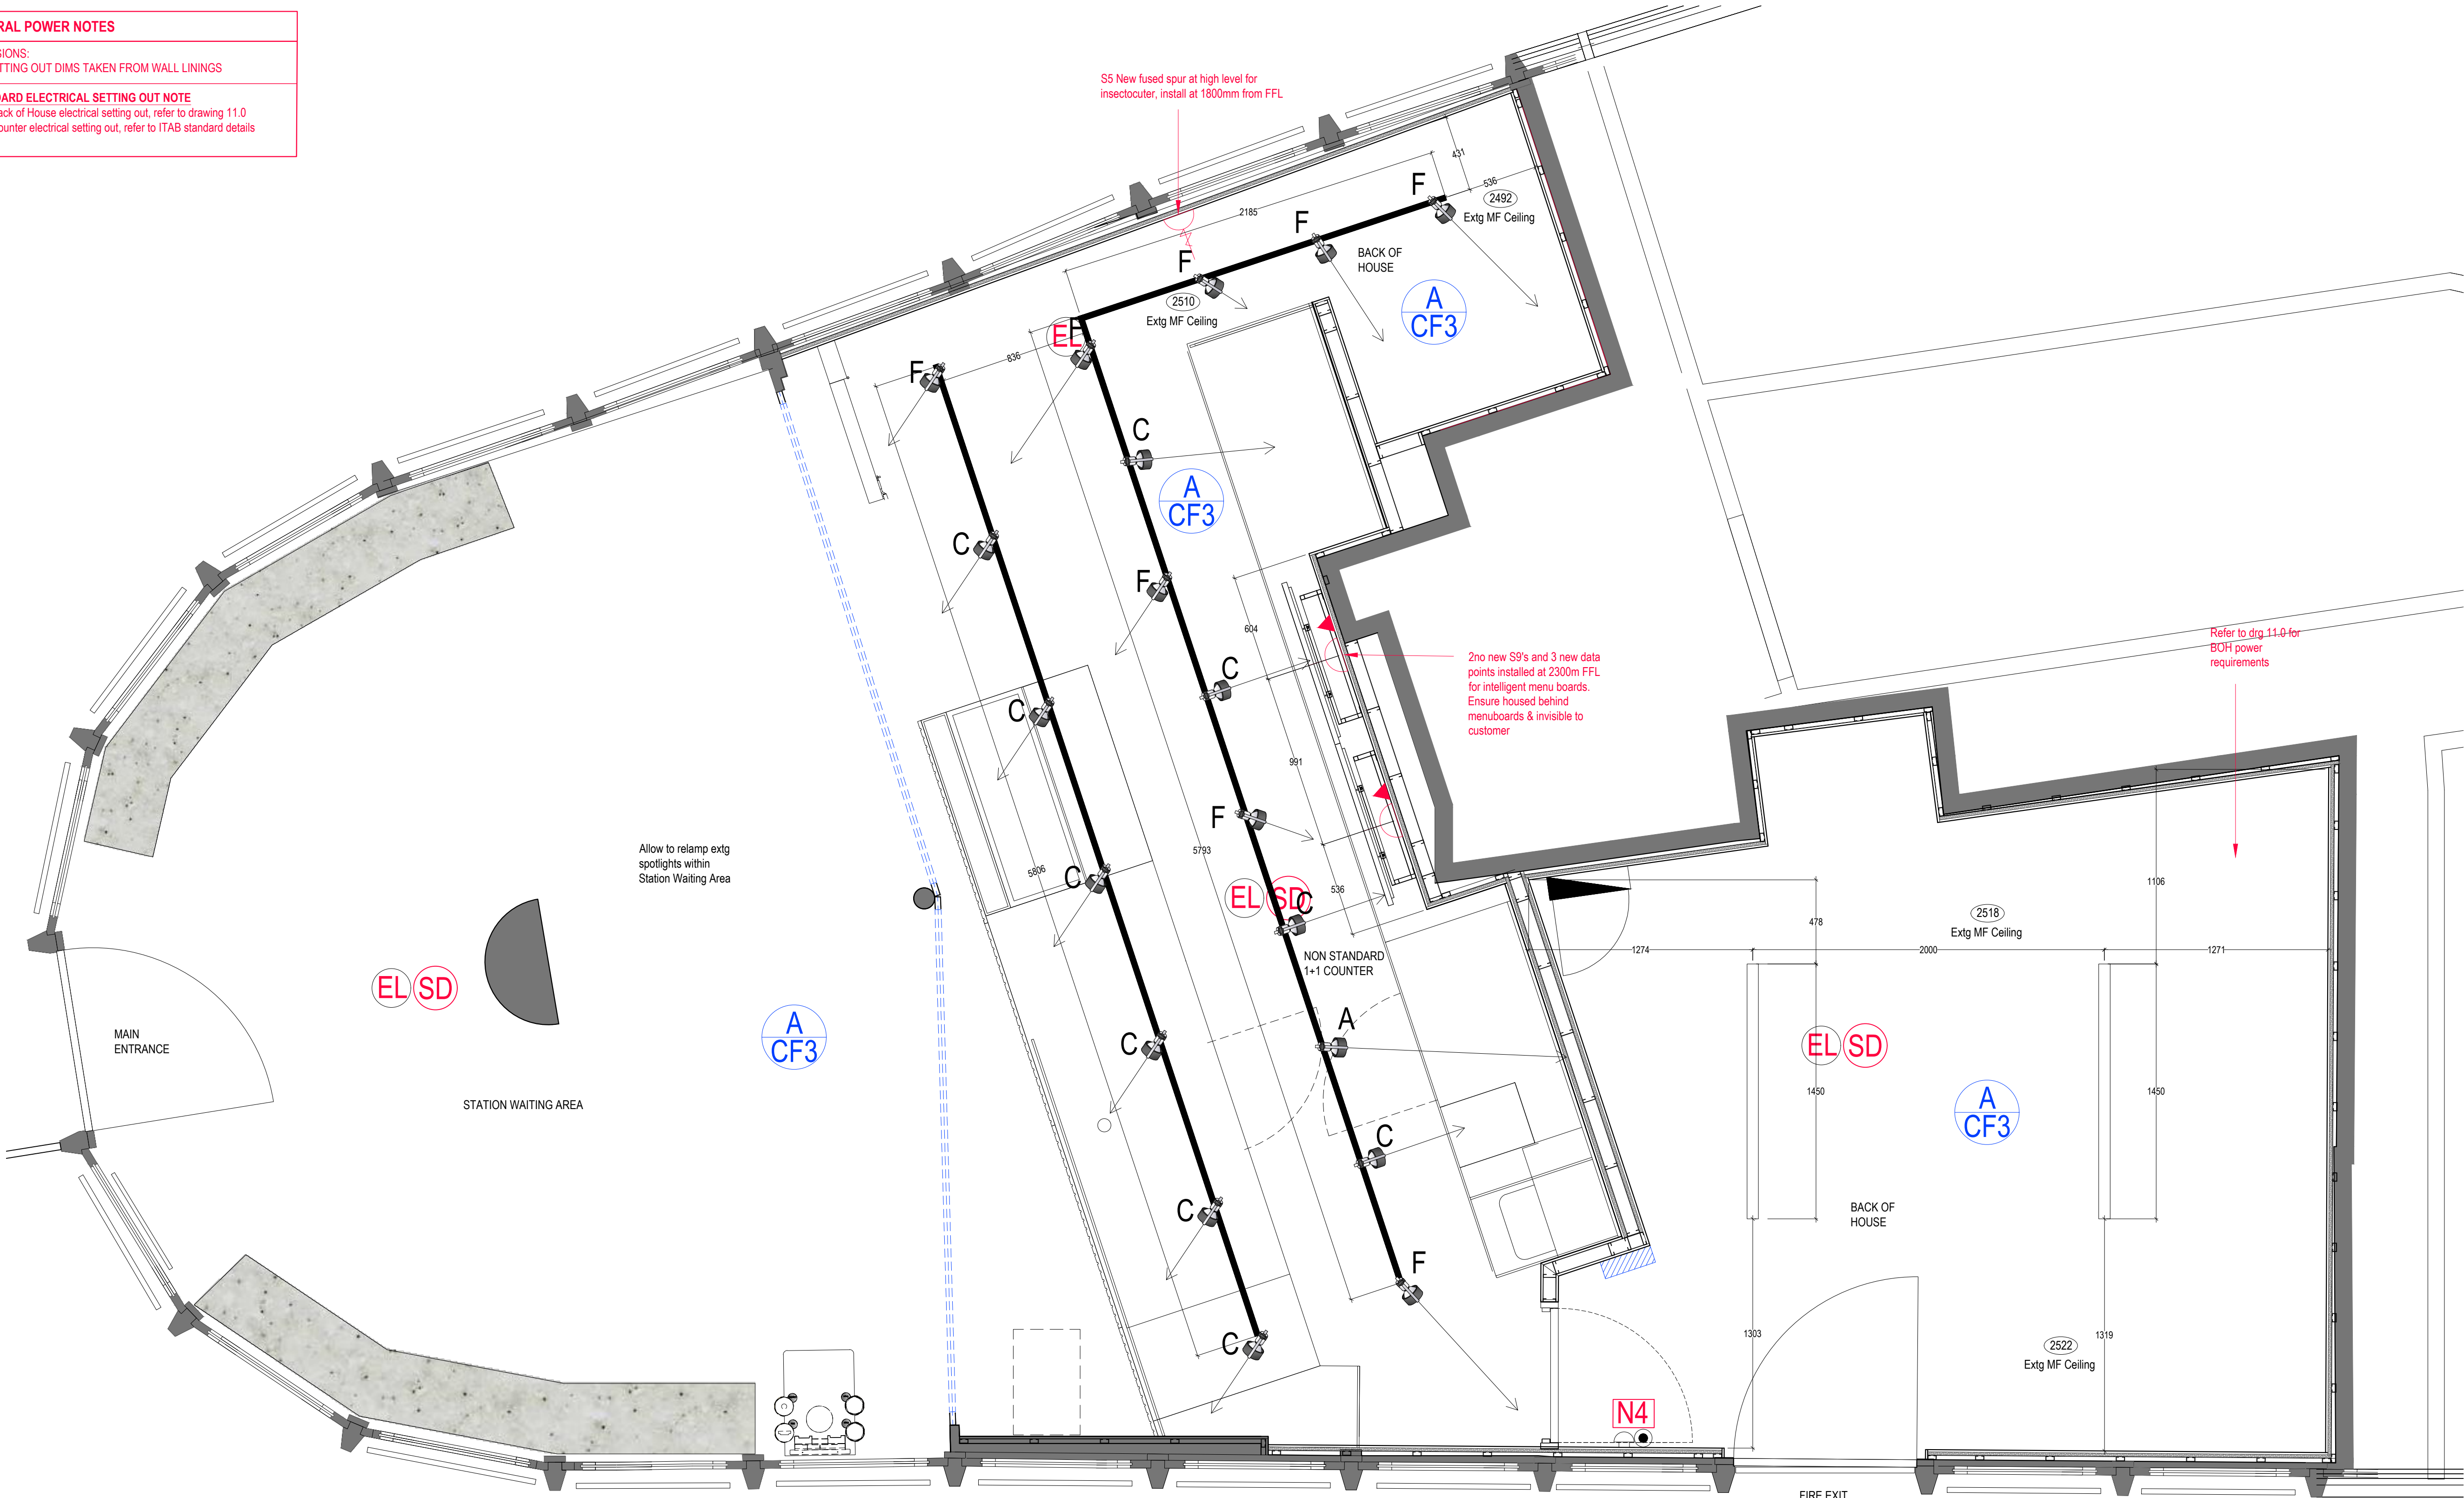



Client: COSTA COFFEE

Project: Manchester Oxford Road Station

Drg title: Proposed Reflected Ceiling & Small Power Plan

Scheme: Uplift v3.0

Scale: 1:20/@A1 Date: 13.08.24

Drg No: 223265/7.0 Rev:

Drg by: SH Check: CW

Rev by:

SEA Design Group, Unit 13D Princes Drive, Kenilworth, Warwickshire CV8 2FD UK
Email: office@seadesigngroup.com
Telephone: +44 (0)1926 864440

