


NOTE:DO NOT SCALE FROM THIS DRAWING.ALL DIMENSIONS TO BE CHECKED ON SITE.TO BE READ IN CONJUNCTION WITH ALL RELEVANT CONSULTANTS DOCUMENTATION

LEVER STREET

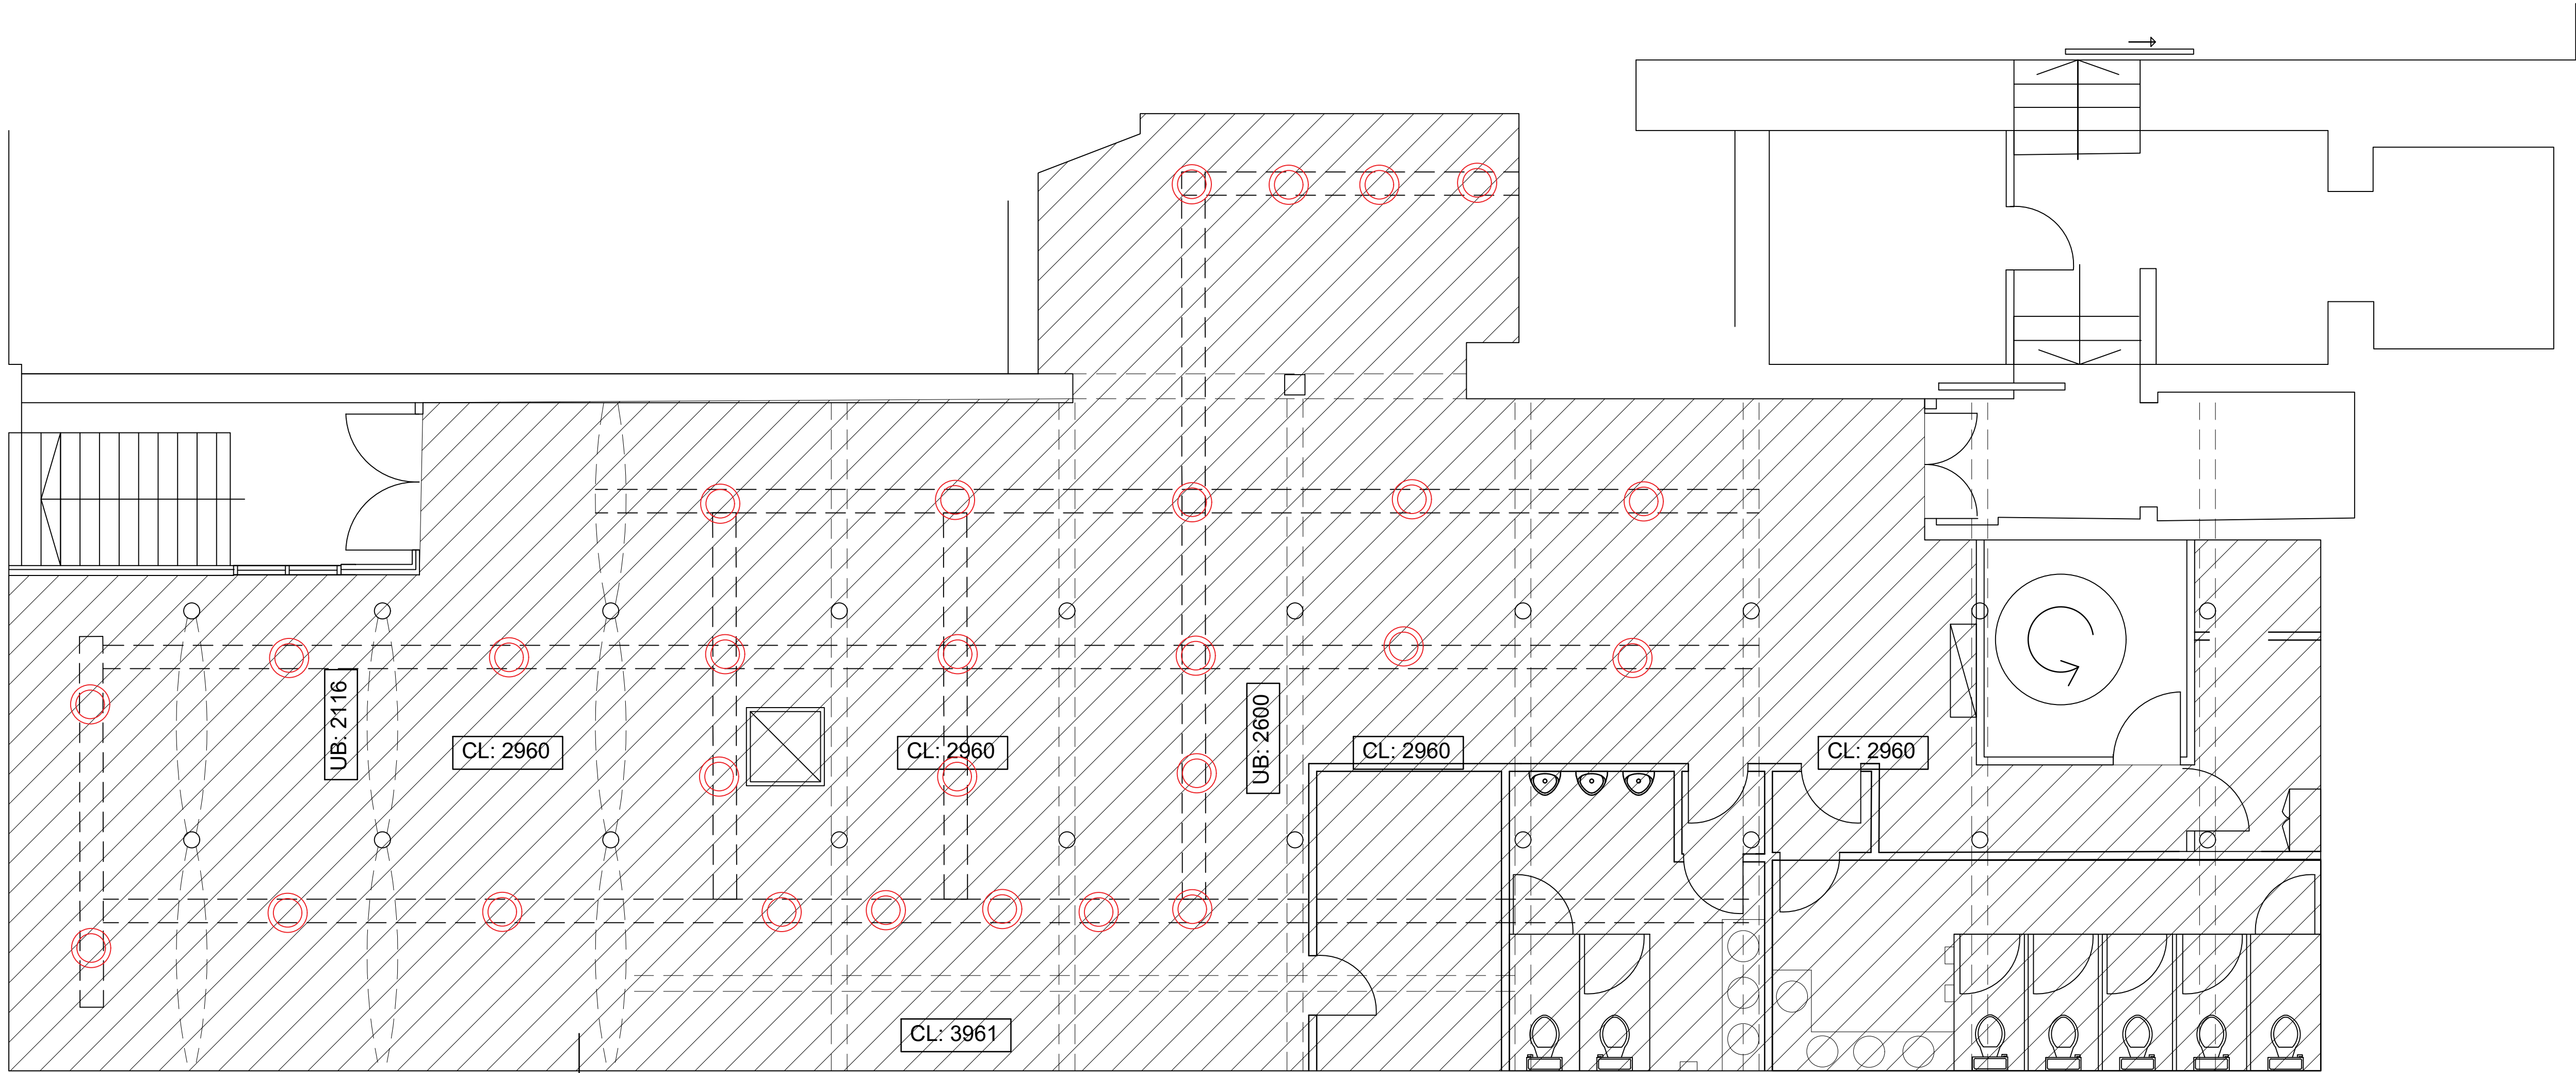

Fireline board fitted between steel beams for fire separation.

BUNSEN STREET

REVISIONS:
REV A: UPDATED TO NOTE CEILING FIXING. 14.05.24
REV B: CEILING DETAIL ADDED AND INDICATIVE MECHANICAL AND ELECTRICAL LAYOUT SHOWN. 19.07.24

iCatch Design
INTERIOR DESIGN

10 KILWORTH AVENUE
SALE, CHESHIRE
M33 4SE
TEL: 07983 539728
WWW.ICATCHDESIGN.CO.UK


Project
ST JOSEPHS GROUP
BASEMENT LEVEL, 24 LEVER STREET
MANCHESTER

Drawing
PROPOSED CEILING LAYOUT


Date APRIL 2024 Drawn By SS Scale 1:50@A1

Drawing Status PLANNING Drawing No. 0209-05 Rev No. B

Key:

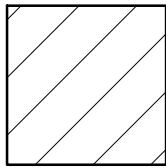

Fireline plasterboard

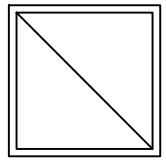


CEILING HUNG AC UNIT TO BE SUPPORTED FROM NEW CABLE TRAY




CEILING LIGHTS HUNG FROM CABLE TRAY

 
Note: Lighting and Fire detection equipment to be fixed to new plasterboard ceiling. Cable tray to be secured under to new ceiling.



WALL MOUNTED AC UNIT

 

CABLE TRAY RUNS TO BE POSITIONED BELOW THE EXISTING BEAMS, FIXED TO U/S OF NEW CEILING. TRAY TO CARRY LIGHTING AND CABLES AS NECESSARY.

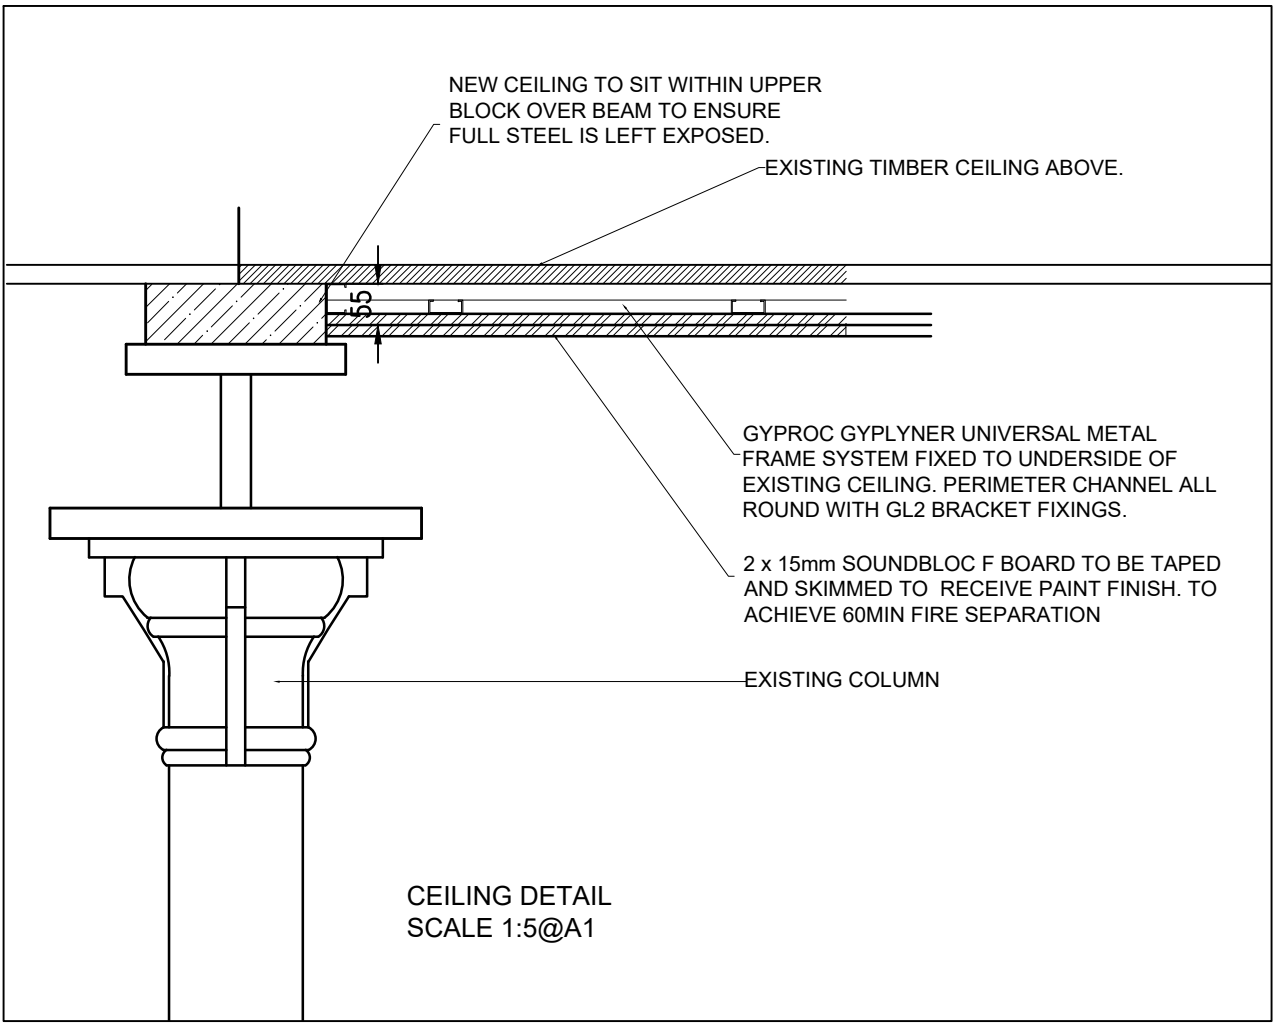

Proposed Ceiling Plan

Scale 1:50 @ A1