 



LEGEND	
	NEW PIPEWORK
	EXISTING PIPEWORK
	CONDENSATE PIPEWORK
	FAN COIL UNIT



P1	ISSUE FOR PLANNING	SR	17.05.24
REV	DESCRIPTION	BY	DATE

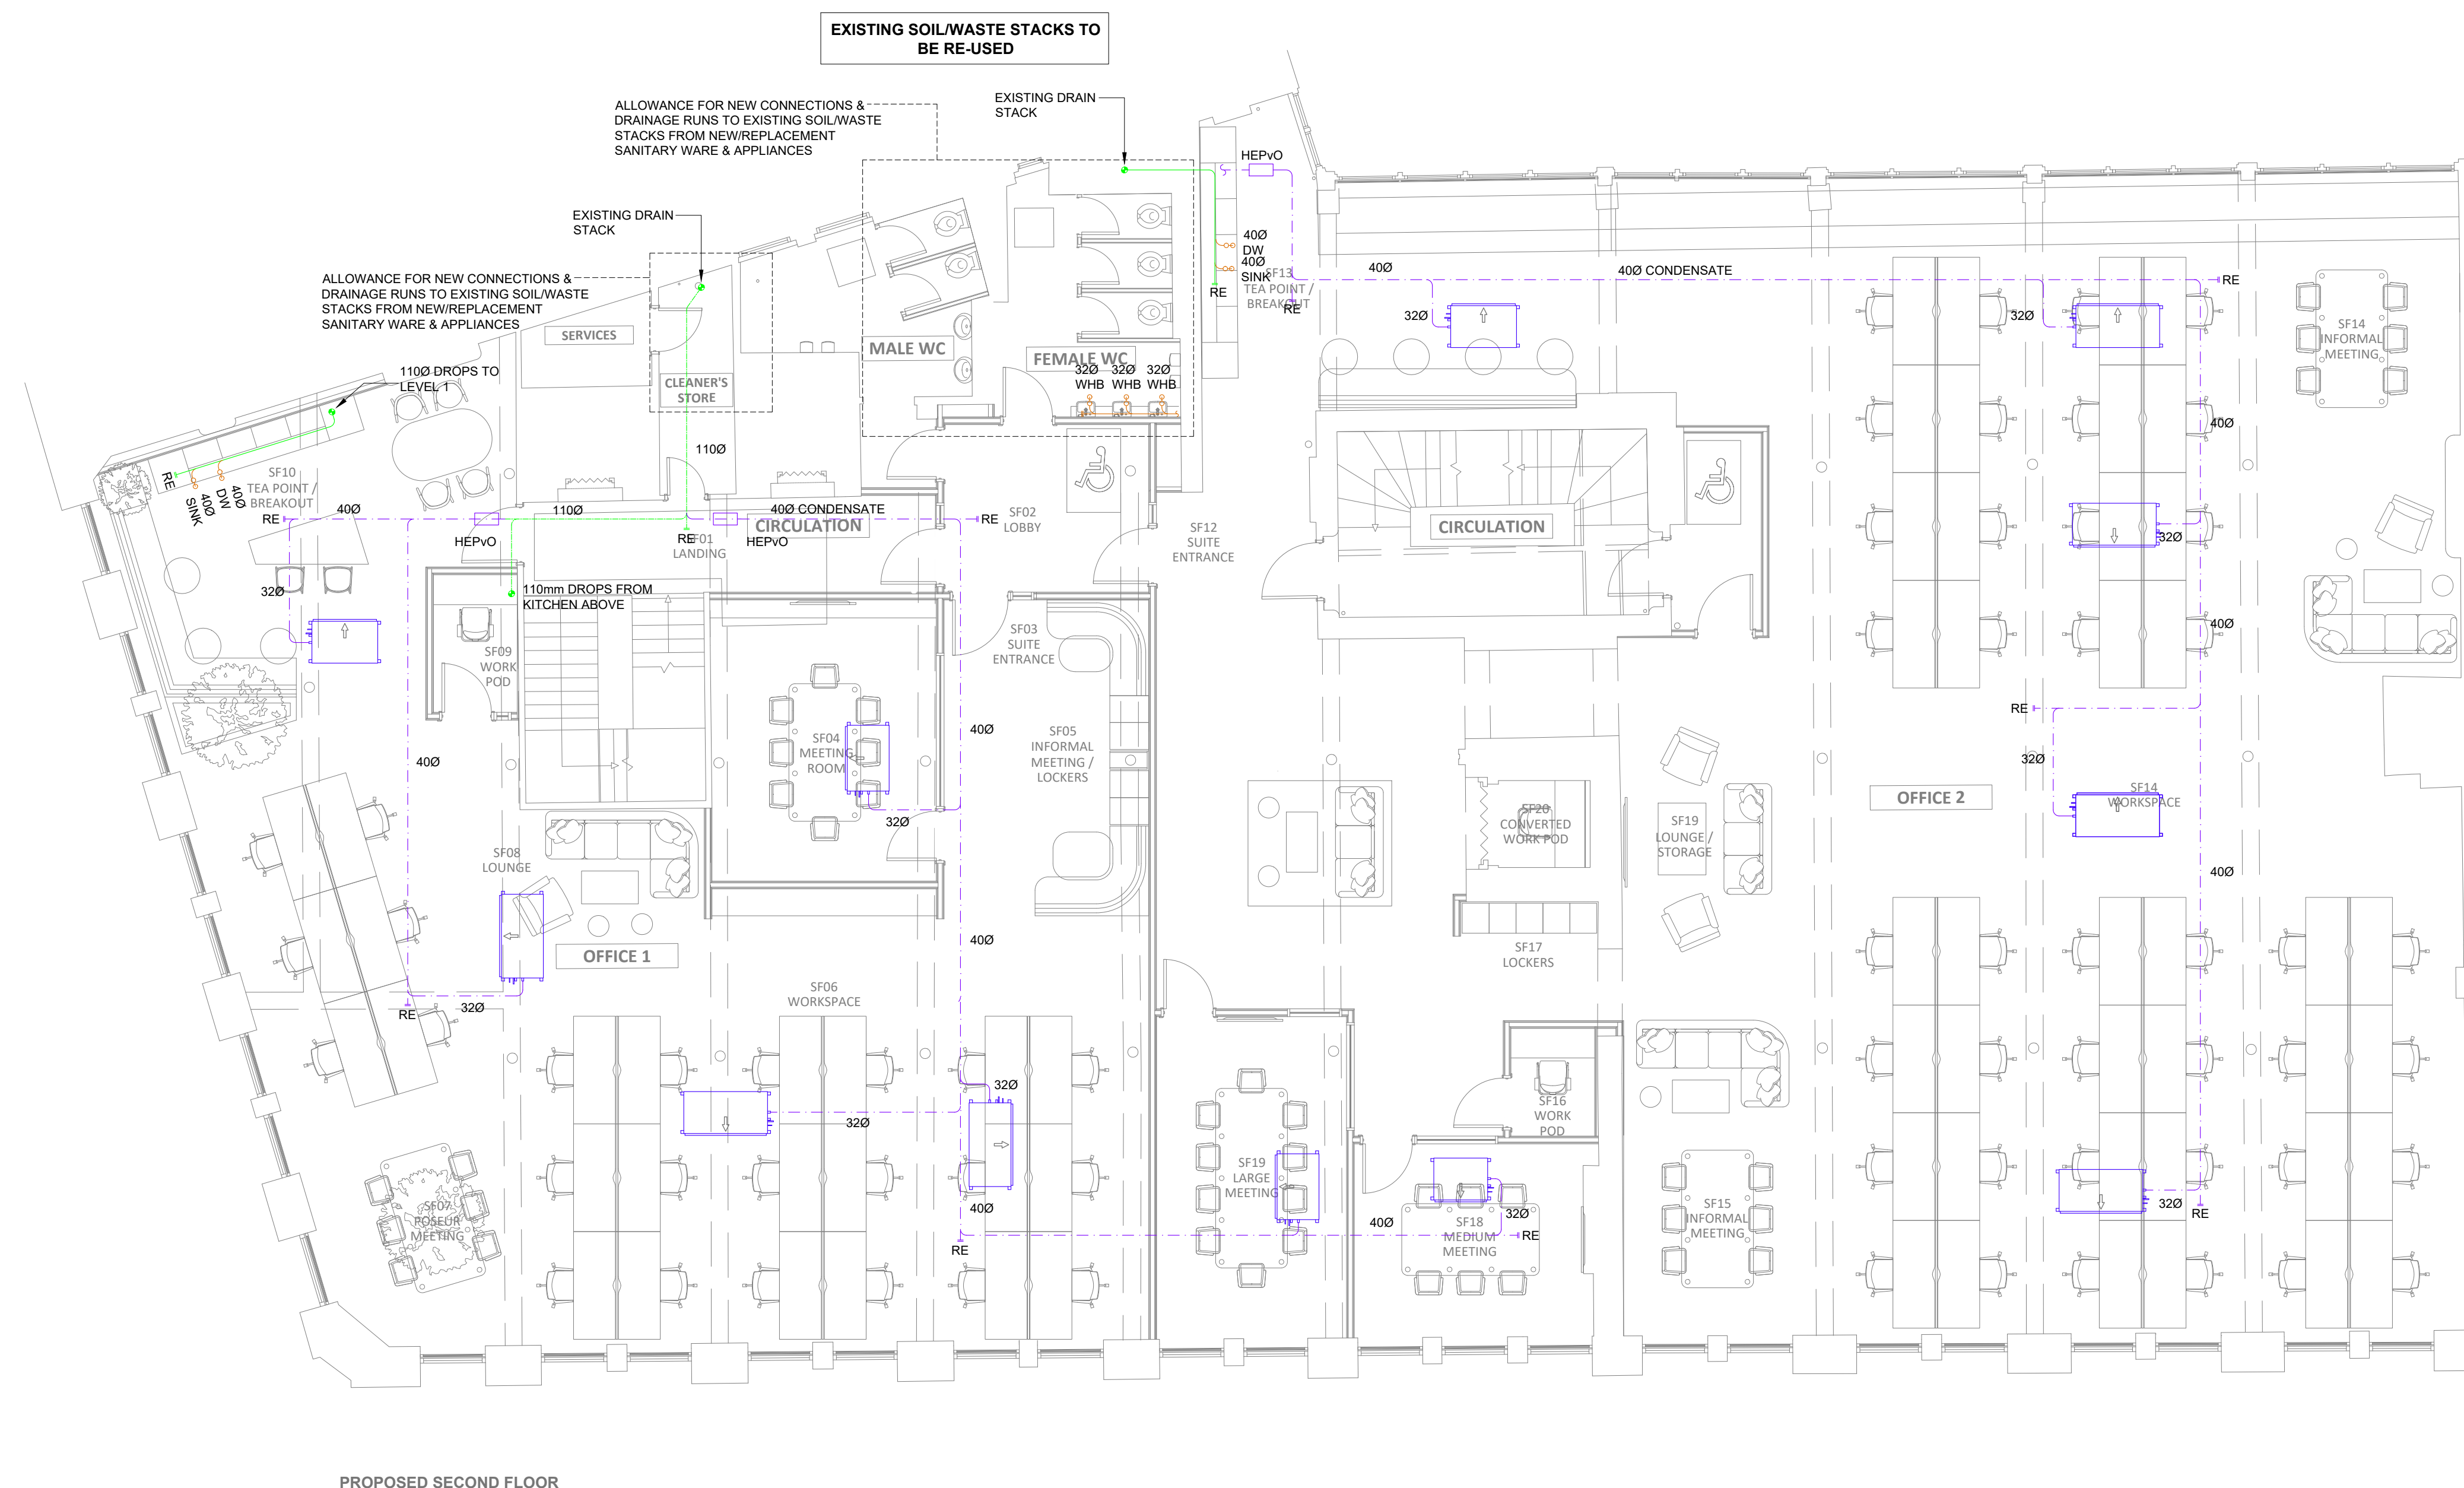

CLIENT

bruntwood
SciTech

ARCHITECT

PROJECT
117-119 PORTLAND STREET
MANCHESTER

DRAWING TITLE

MECHANICAL SERVICES
SECOND FLOOR
ABOVE GROUND DRAINAGE LAYOUT

CHECKED	DATE	DRAWN	SCALE
SR	FEB 24	MN	1:75@A1

STAGE 4

DRAWING NUMBER	STATUS	REV.
1168-KCE-ZZ-02-DR-M-5203	S4	P1

1168-KCE-ZZ-02-DR-M-5203

S4	P1
-----------	-----------