


All dimensions are in millimetres unless stated otherwise. No dimensions to be scaled from drawings. All dimensions to be checked on site prior to manufacture.

Any discrepancies between drawings and site conditions are to be reported to the contract manager.

This drawing is to be read in conjunction with all relevant Structural Engineers and Mechanical & Electrical Engineers drawings and specification.

© COPYRIGHT
The copyright in this drawing is vested in OBI Property Ltd and no licence or assignment of any kind has been, or is, granted to any third party whether by provision of copies or originals of the drawings or otherwise unless otherwise agreed in writing.

CF05 Dulux Paint Colour 1st 7024 Graphite Grey	TBC m2
LF06b Intelligent LED lighting - Sound Reactive	QTY 4
Feature Pendants	
LF04 Black linear light	

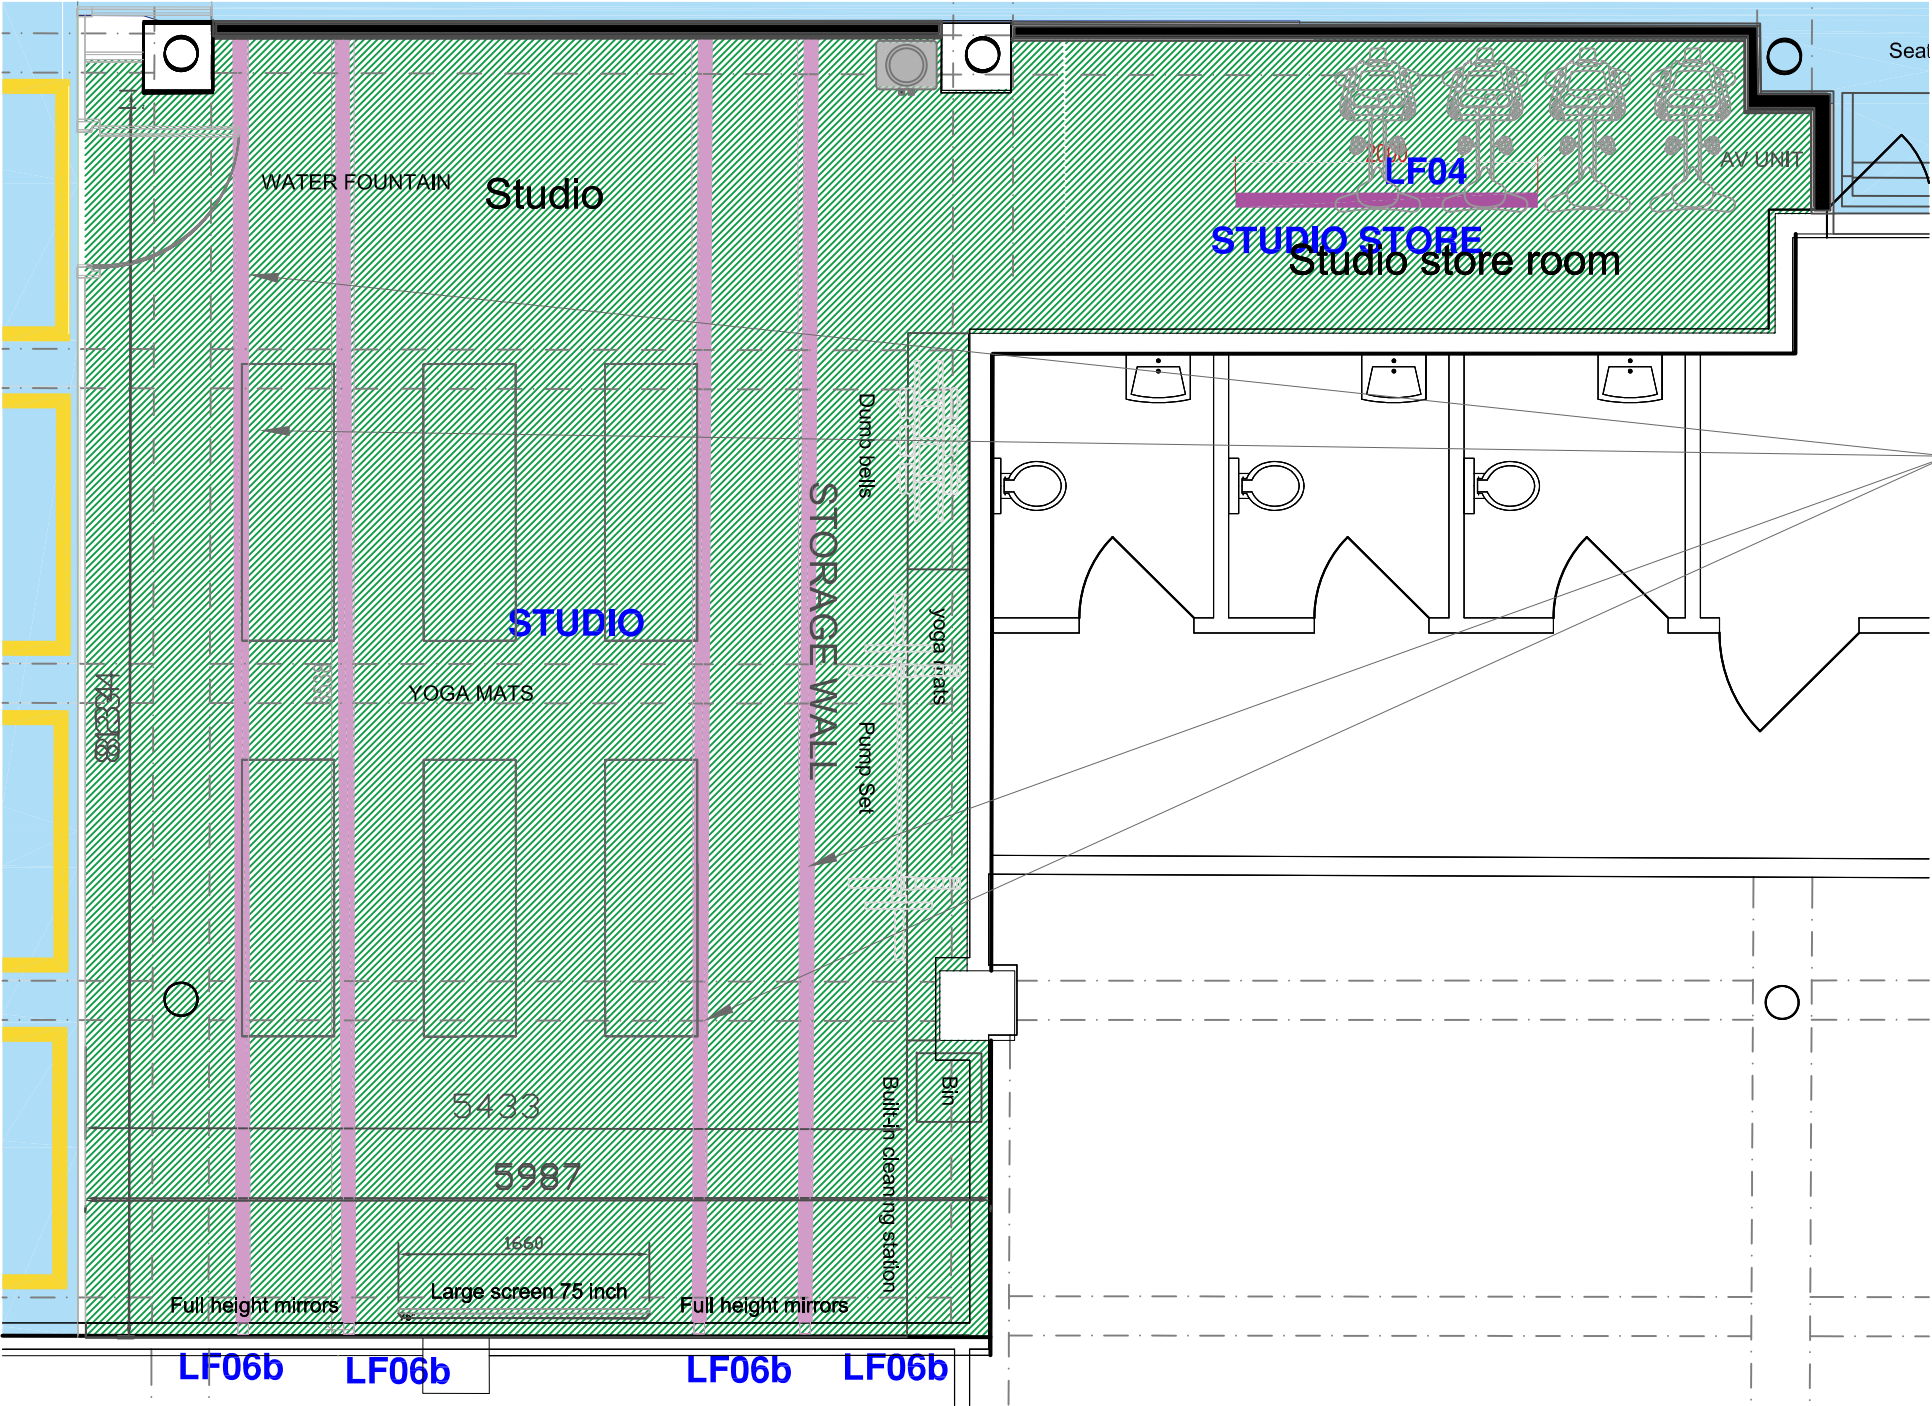

LF06B. Intelligent LED Lighting - Sound Reactive

4no ArtNet Integrated Driver - 2 output (will illuminate 1000 LED's)
8no 5m reel 12v RGB Addressable Pixel Strip -60 LED P/M (WS2815)
1no Madrix Key Basic software for (single pixel control)
20no 2m length deep extrusion (frosted extrusion)
1no INTEL 7 processor Laptop computer
Installation & Commissioning - 2 engineers - 4 days
Programming - 2 days

Wexer Virtual Fitness

1no 21" Wexer Virtual player, wall mounted
1no Cable set for the above Wexer
Installation & Commissioning - 2 engineers - 1 day

Large Screen Display

1no LG Commercial grade 75" display screen, c/w RS232 for automatic on/off when used with the Wexer Virtual Fitness.
1no Heavy duty mounting bracket for the above display
Installation & Commissioning - 1 engineer - 4 hours

**Spin Room Audio Systems - Automatic Mute
Connection to the existing Fire Alarm System**

4no JBL Control pendant speakers
1no 12U Wall mounted lockable equipment rack c/w 1U; 2U & 3U Rack shelves, 6 way power bar & rack screws
1no QSC Amplifier with relay connection to the existing fire alarm
1no Cable set
Installation & commissioning - 2 engineers - 3

Please note, we will have to liaise with the mirror manufacturer to ensure the depth and spacing between each mirror is correct, so that we can flush mount the Intelligent lighting correctly.



**Intelligent LED Lighting - Sound Reactive
WRAP FROM THE BOTTOM OF THE WALL AND CONTINUE ACROSS THE CEILING**

B	Area Updated	03/11/23	RG
A	REMOVED THE STUDIO DOOR DUE TO FIRE REGS	15/10/23	RG
-	First Issue	21/09/23	RG

REV	DESCRIPTION	DATE	BY	CHK
-----	-------------	------	----	-----

CLIENT NAME

Philip J Davies Holdings plc

PROJECT NAME

Sevendale House

DWG TITLE:
Lower Ground Floor - Studio Details

DWG NO:	14_-005	REVISION:	-
SCALE	1 : 50 @A3	DRAWN:	RG

DWG STATUS:

TENDER

Studio - ceiling and walls
scale 1/50