


LEGEND	
	NEW PIPEWORK
	EXISTING PIPEWORK
	CONDENSATE PIPEWORK
	FAN COIL UNIT

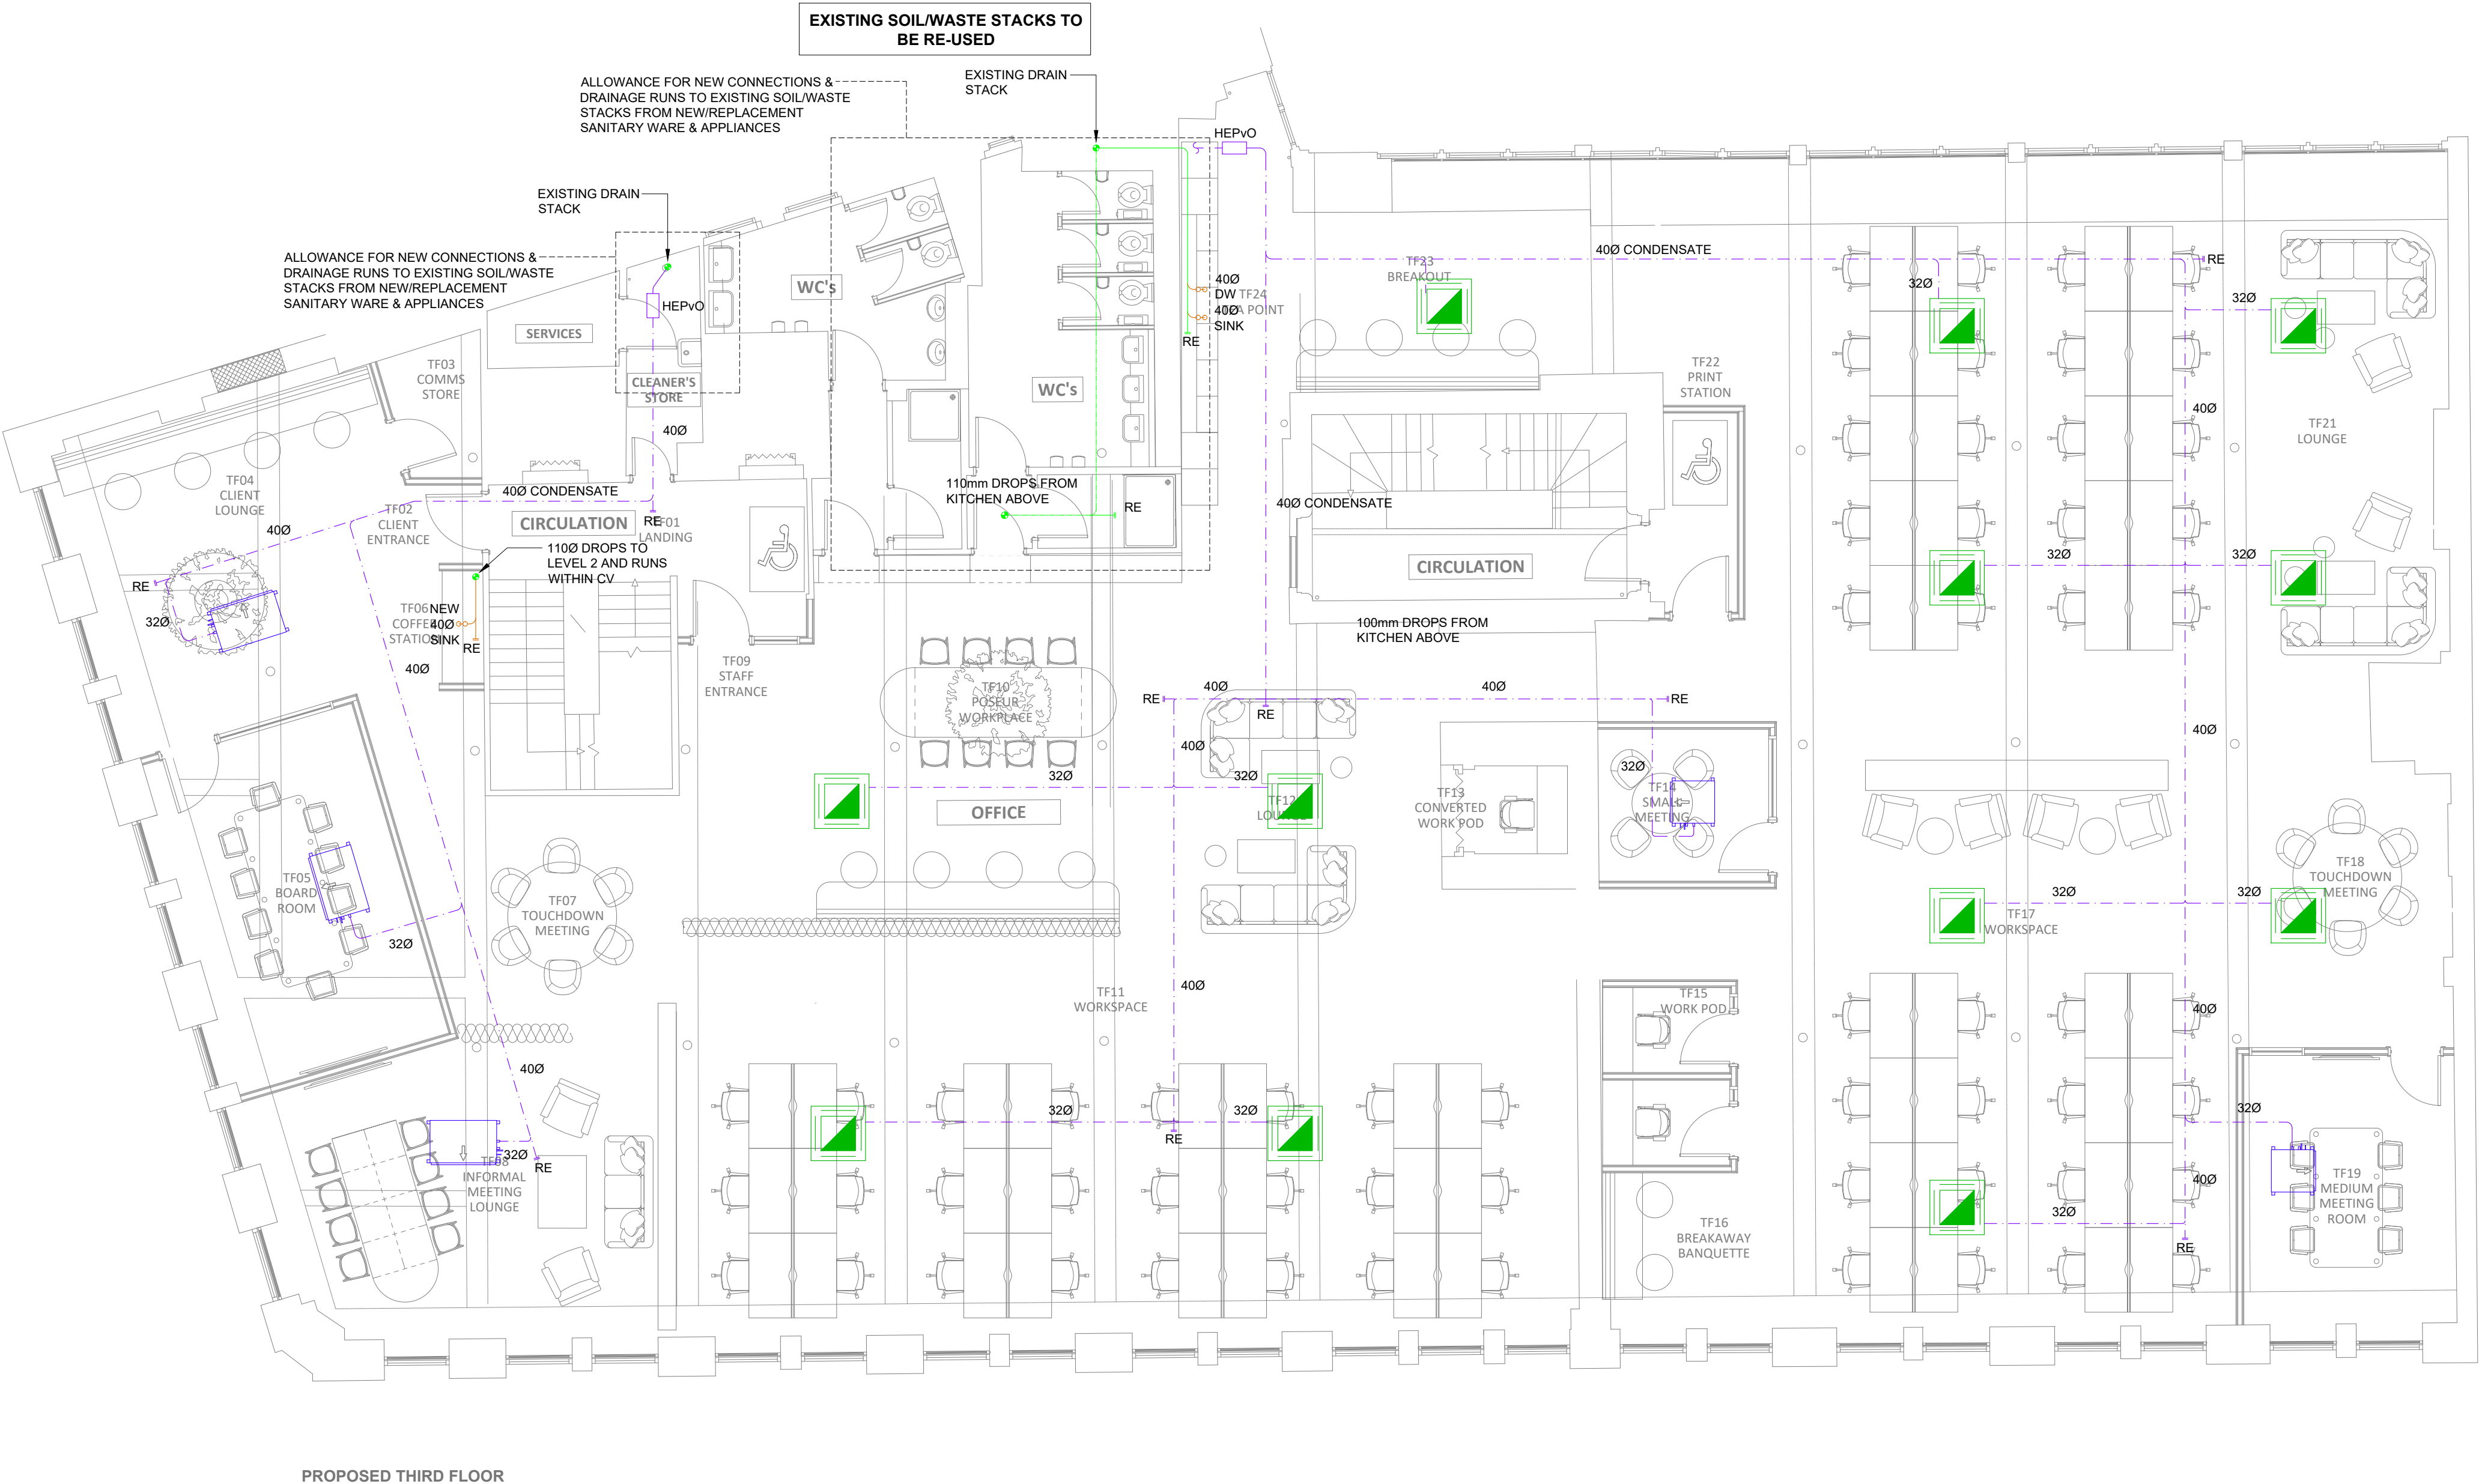

PROPOSED THIRD FLOOR

P1 ISSUE FOR PLANNING		SR 17.05.24	
REV	DESCRIPTION	BY	DATE
KAIZEN Consulting Engineers www.kaizen-ce.com e: info@kaizen-ce.com			
CLIENT			
bruntwood SciTech			
ARCHITECT			
A X I			
PROJECT			
117-119 PORTLAND STREET MANCHESTER			
DRAWING TITLE			
MECHANICAL SERVICES THIRD FLOOR ABOVE GROUND DRAINAGE LAYOUT			
CHECKED	DATE	DRAWN	SCALE
SR	FEB 24	MN	1:75@A1
STAGE 4			
DRAWING NUMBER		STATUS	REV.
1168-KCE-ZZ-03-DR-M-5204		S4	P1