


LEGEND

- SUPPLY AIR DUCT
- EXTRACT AIR DUCT
- FRESH AIR DUCT
- EXHAUST AIR DUCT
- SUPPLY GRILLE
- EXTRACT GRILLE / VALVE
- ATTENUATOR
- FLEXIBLE CONNECTION
- VOLUME CONTROL DAMPER

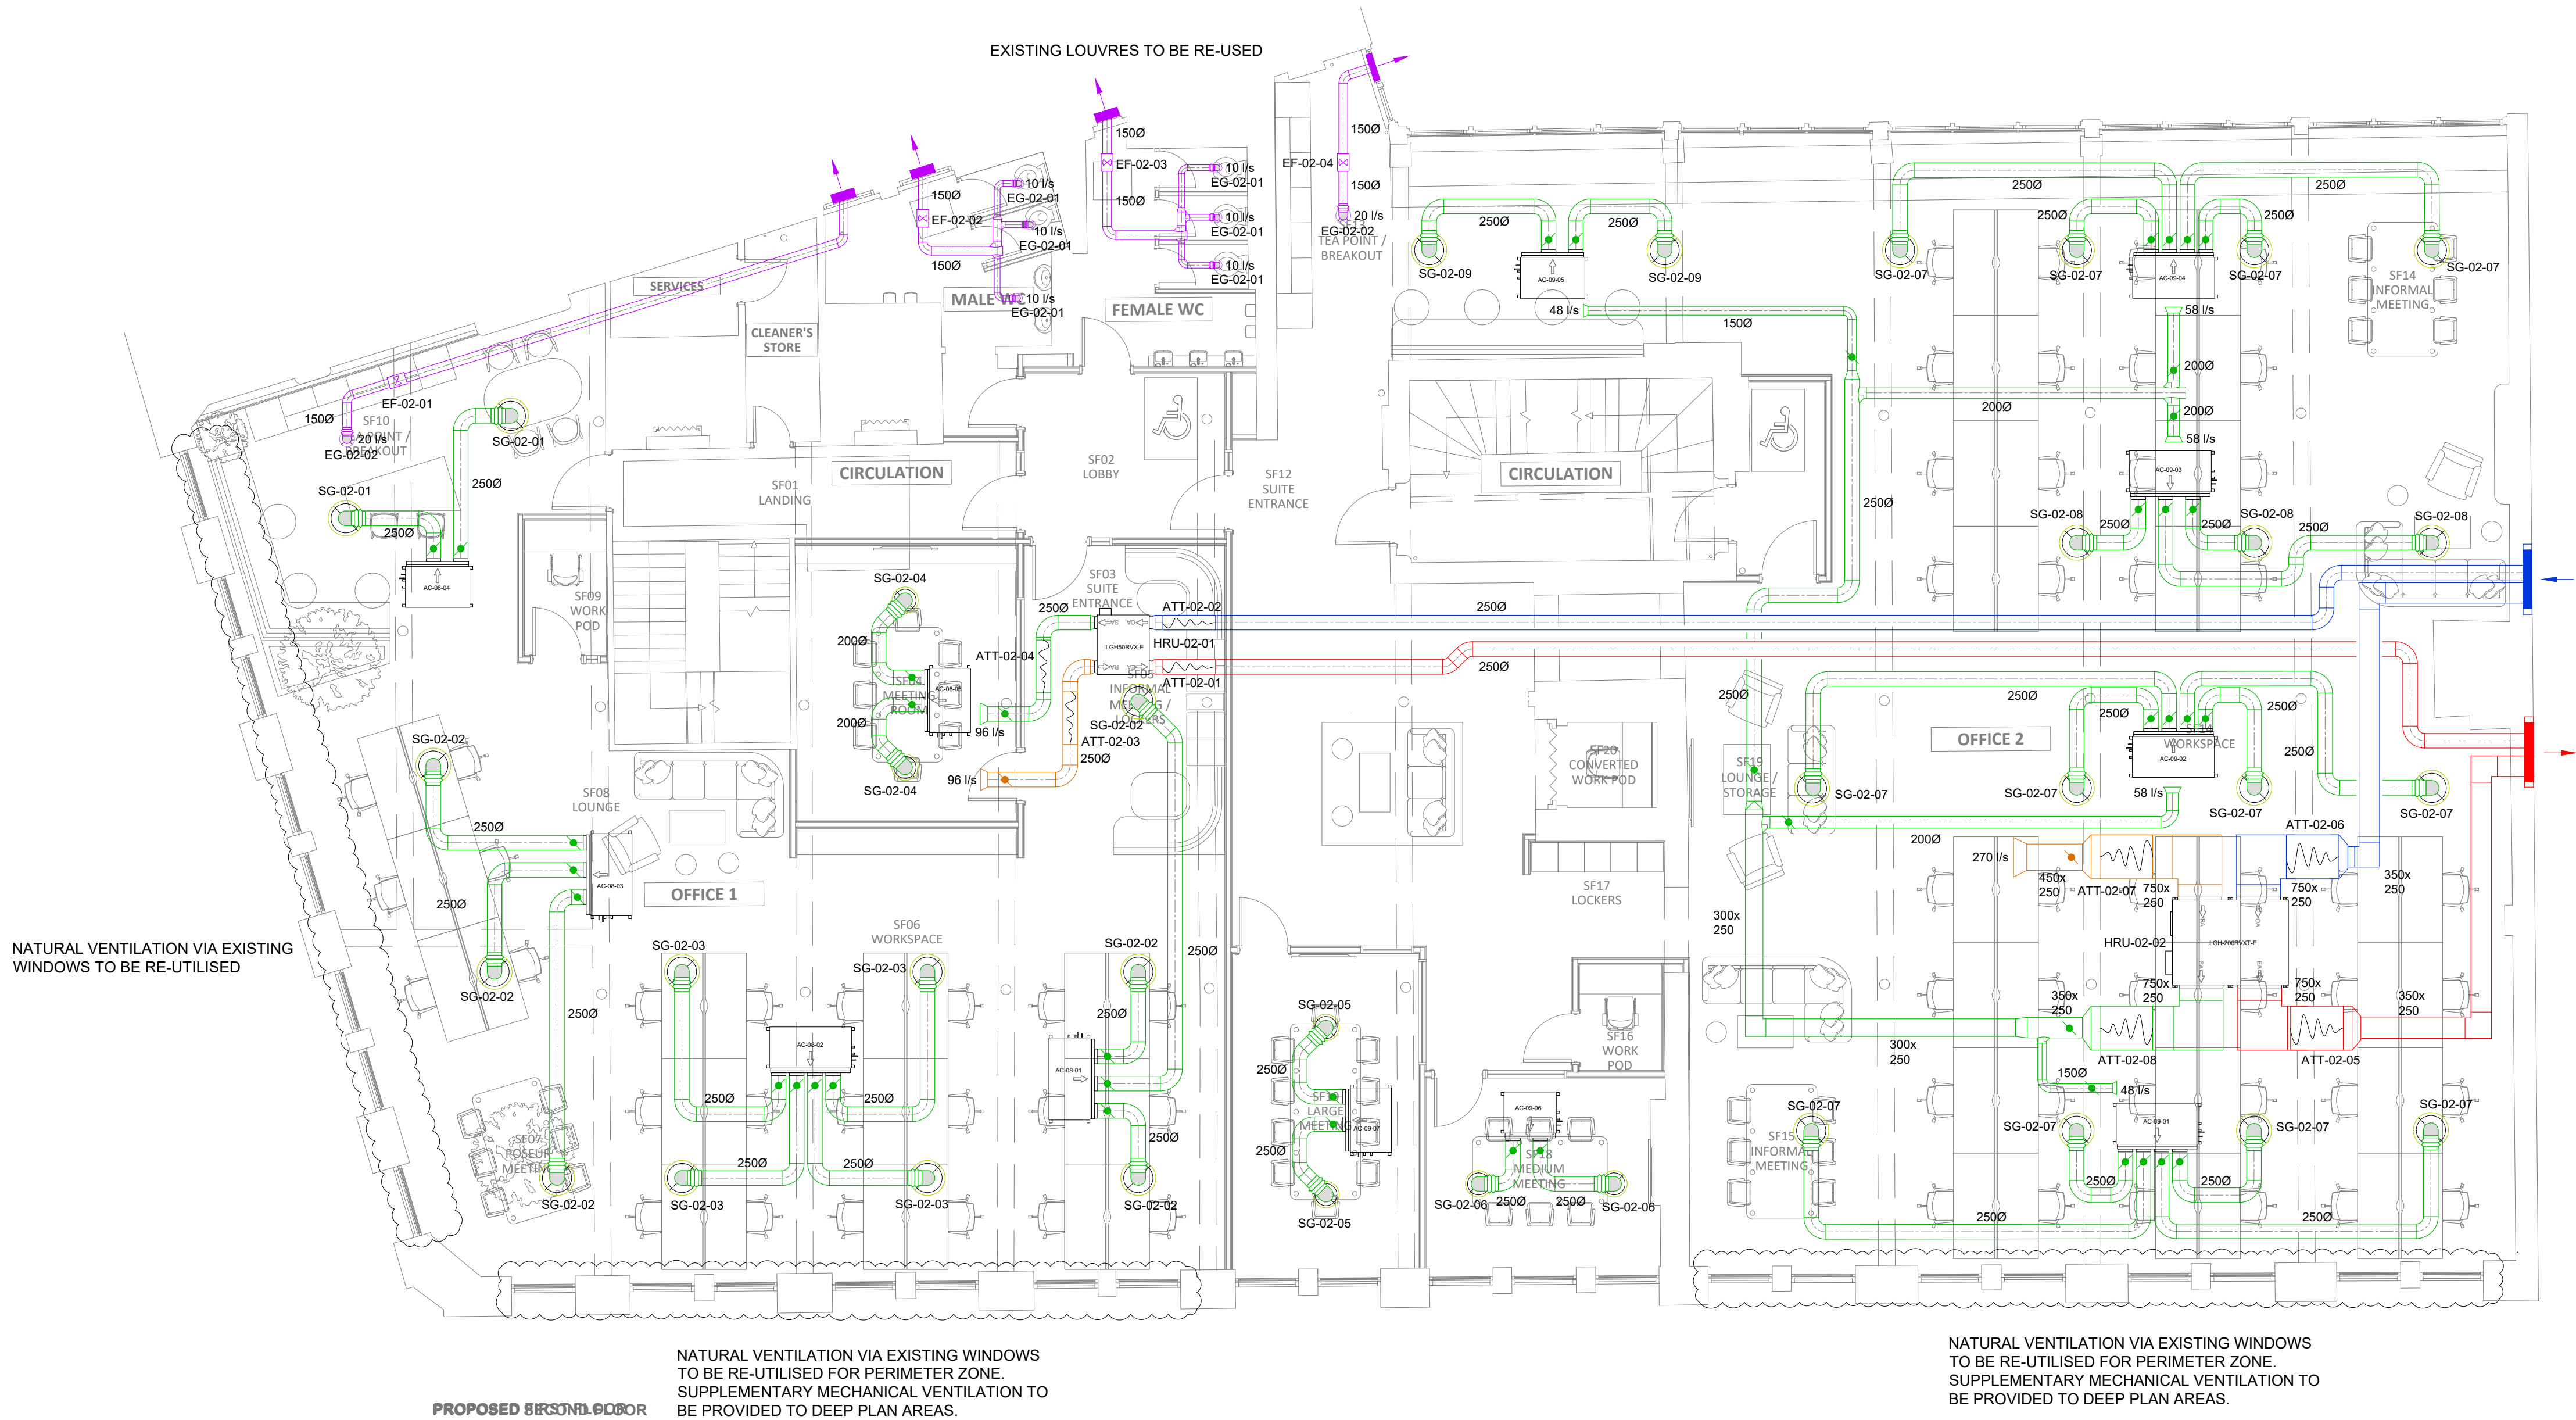

P1	ISSUE FOR PLANNING	SR	17.05.24
REV	DESCRIPTION	BY	DATE

KAIZEN
Consulting Engineers

www.kaizen-ce.com[e: info@kaizen-ce.com](mailto:info@kaizen-ce.com)

CLIENT

bruntwood
SciTech

ARCHITECT

A X I

PROJECT

117-119 PORTLAND STREET
MANCHESTER

DRAWING TITLE

MECHANICAL SERVICES
SECOND FLOOR
VENTILATION LAYOUT

CHECKED	DATE	DRAWN	SCALE
SR	FEB 24	MN	1:75@A1

STAGE 4

DRAWING NUMBER

1168-KCE-ZZ-02-DR-M-5703

STATUS/REV.

S4 P1