

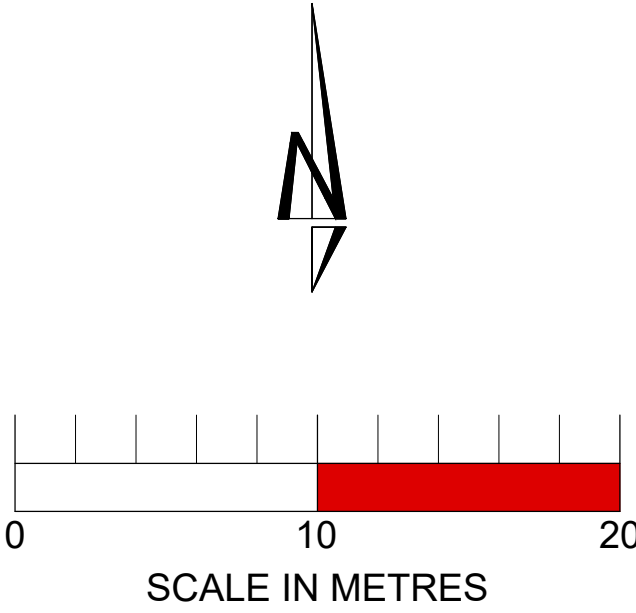


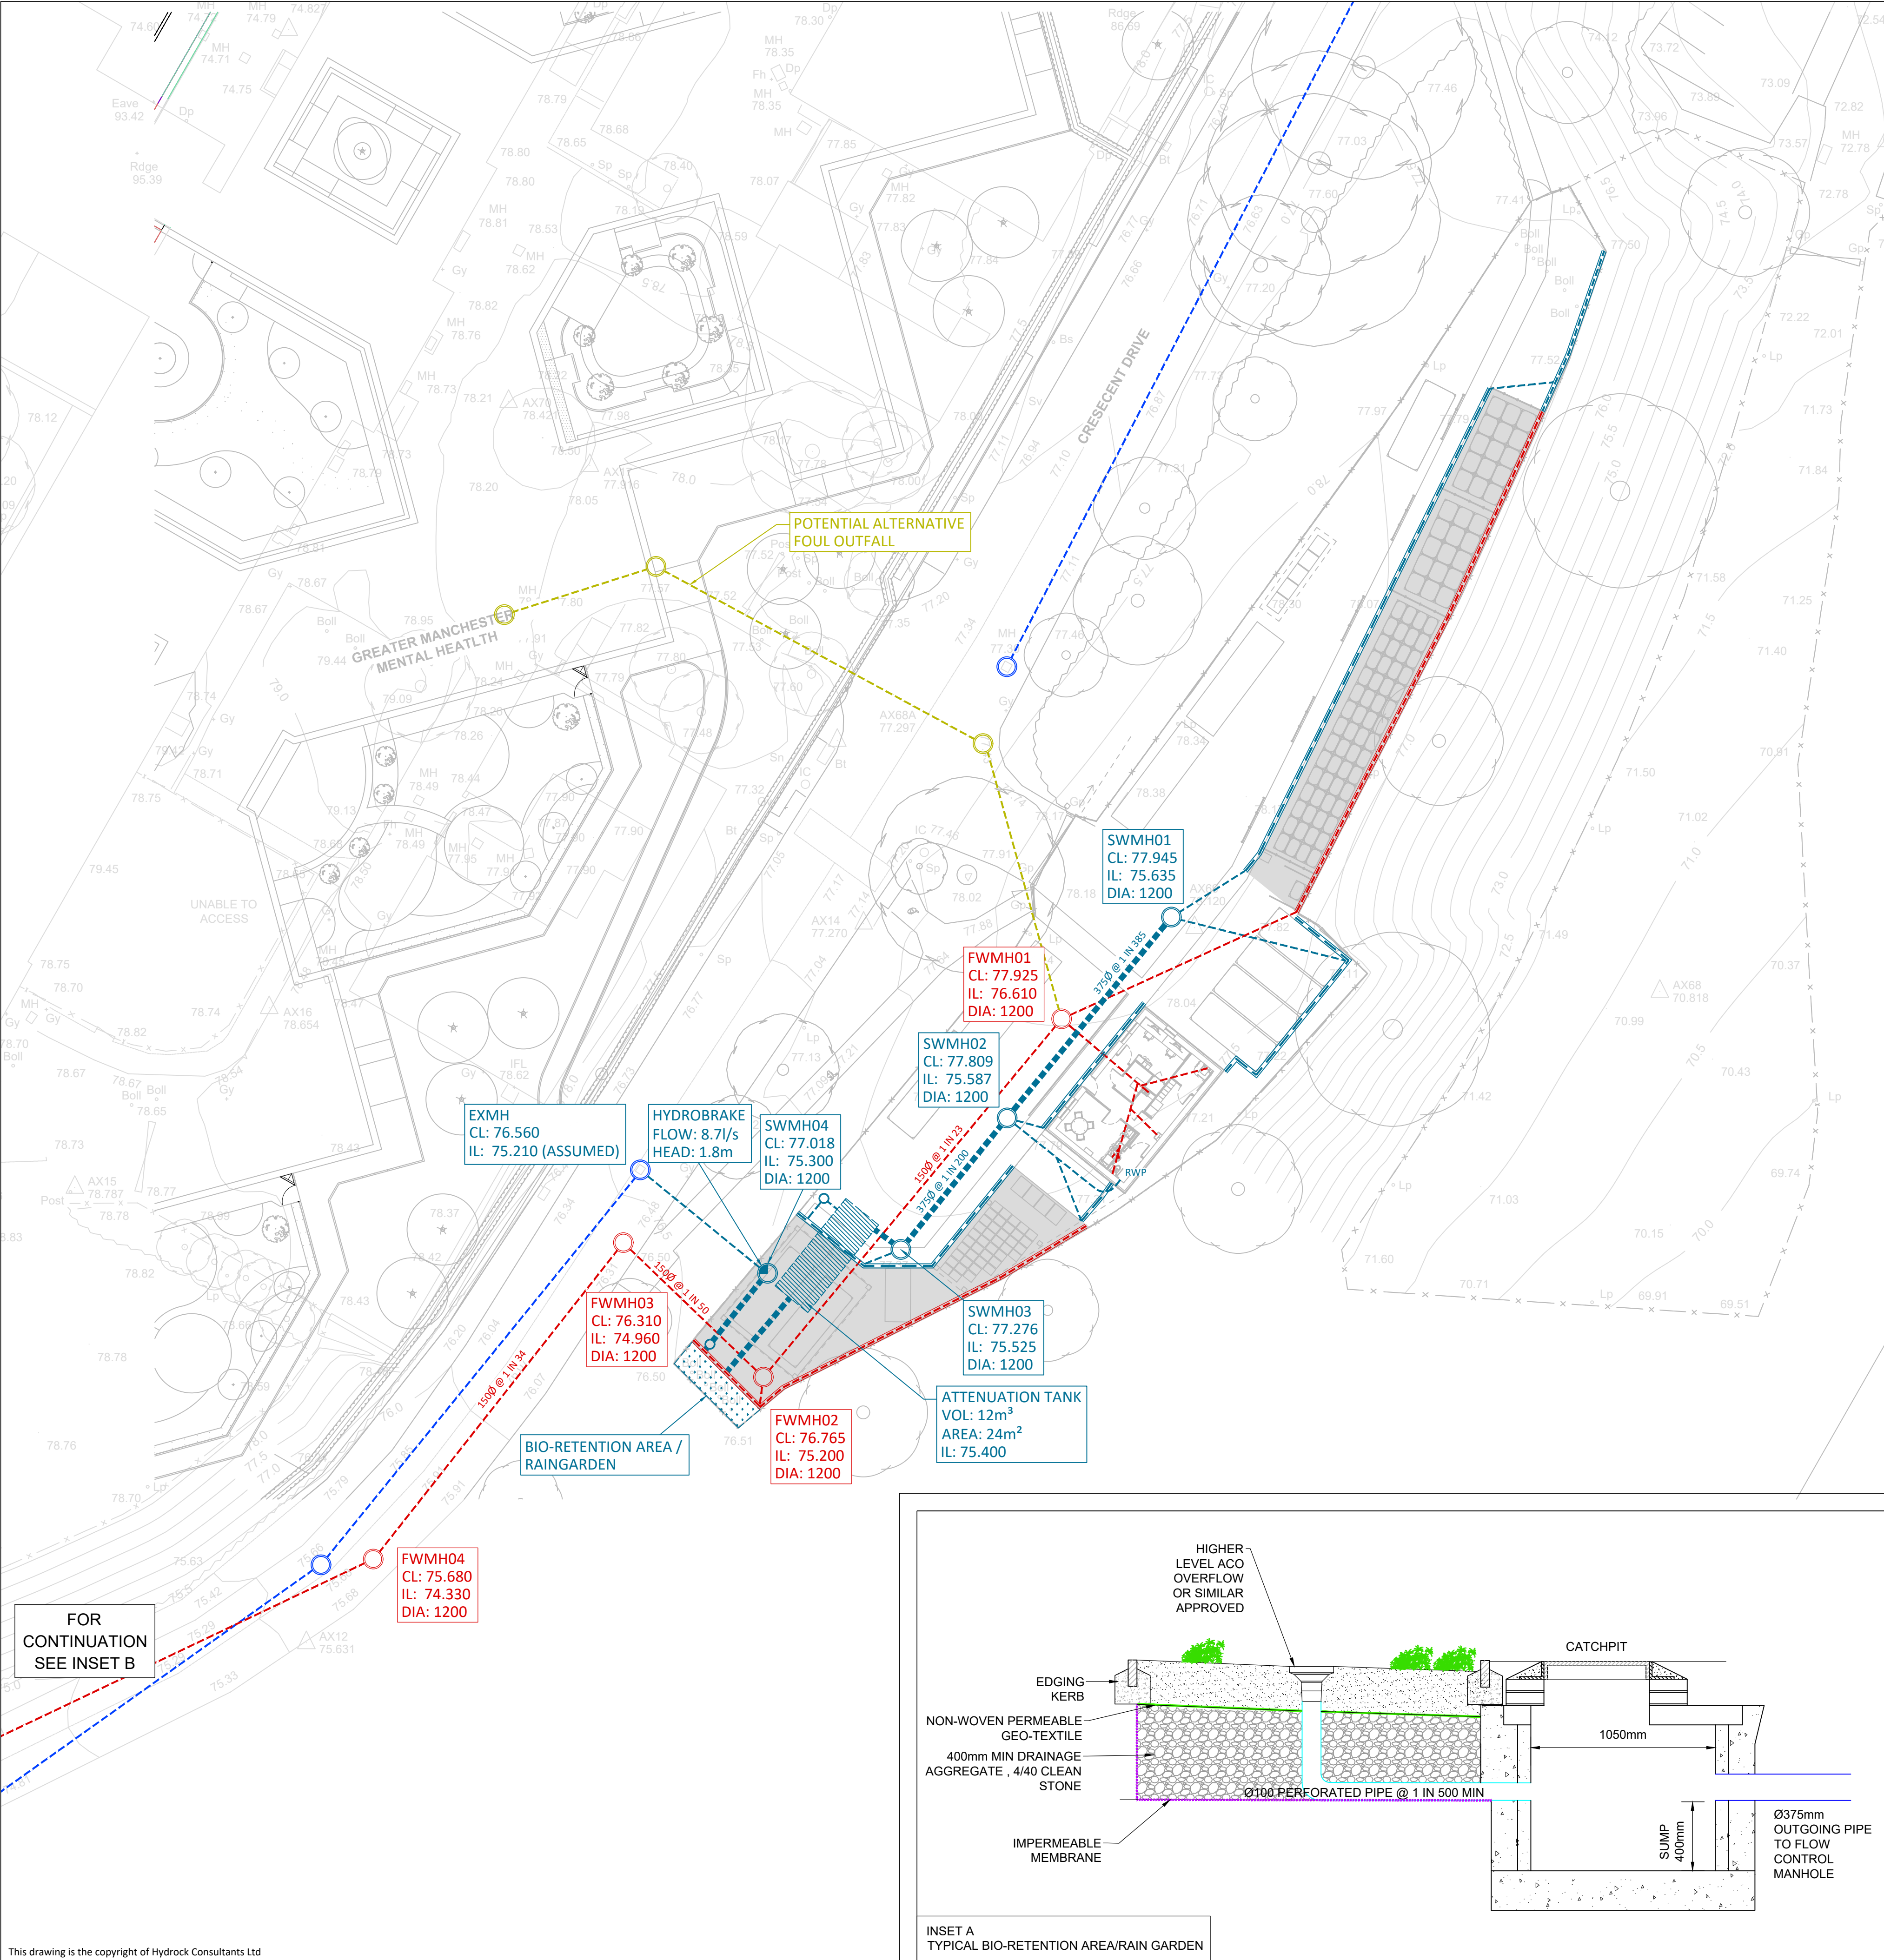

INSET B
PROPOSED CONNECTION INTO UU MANHOLE

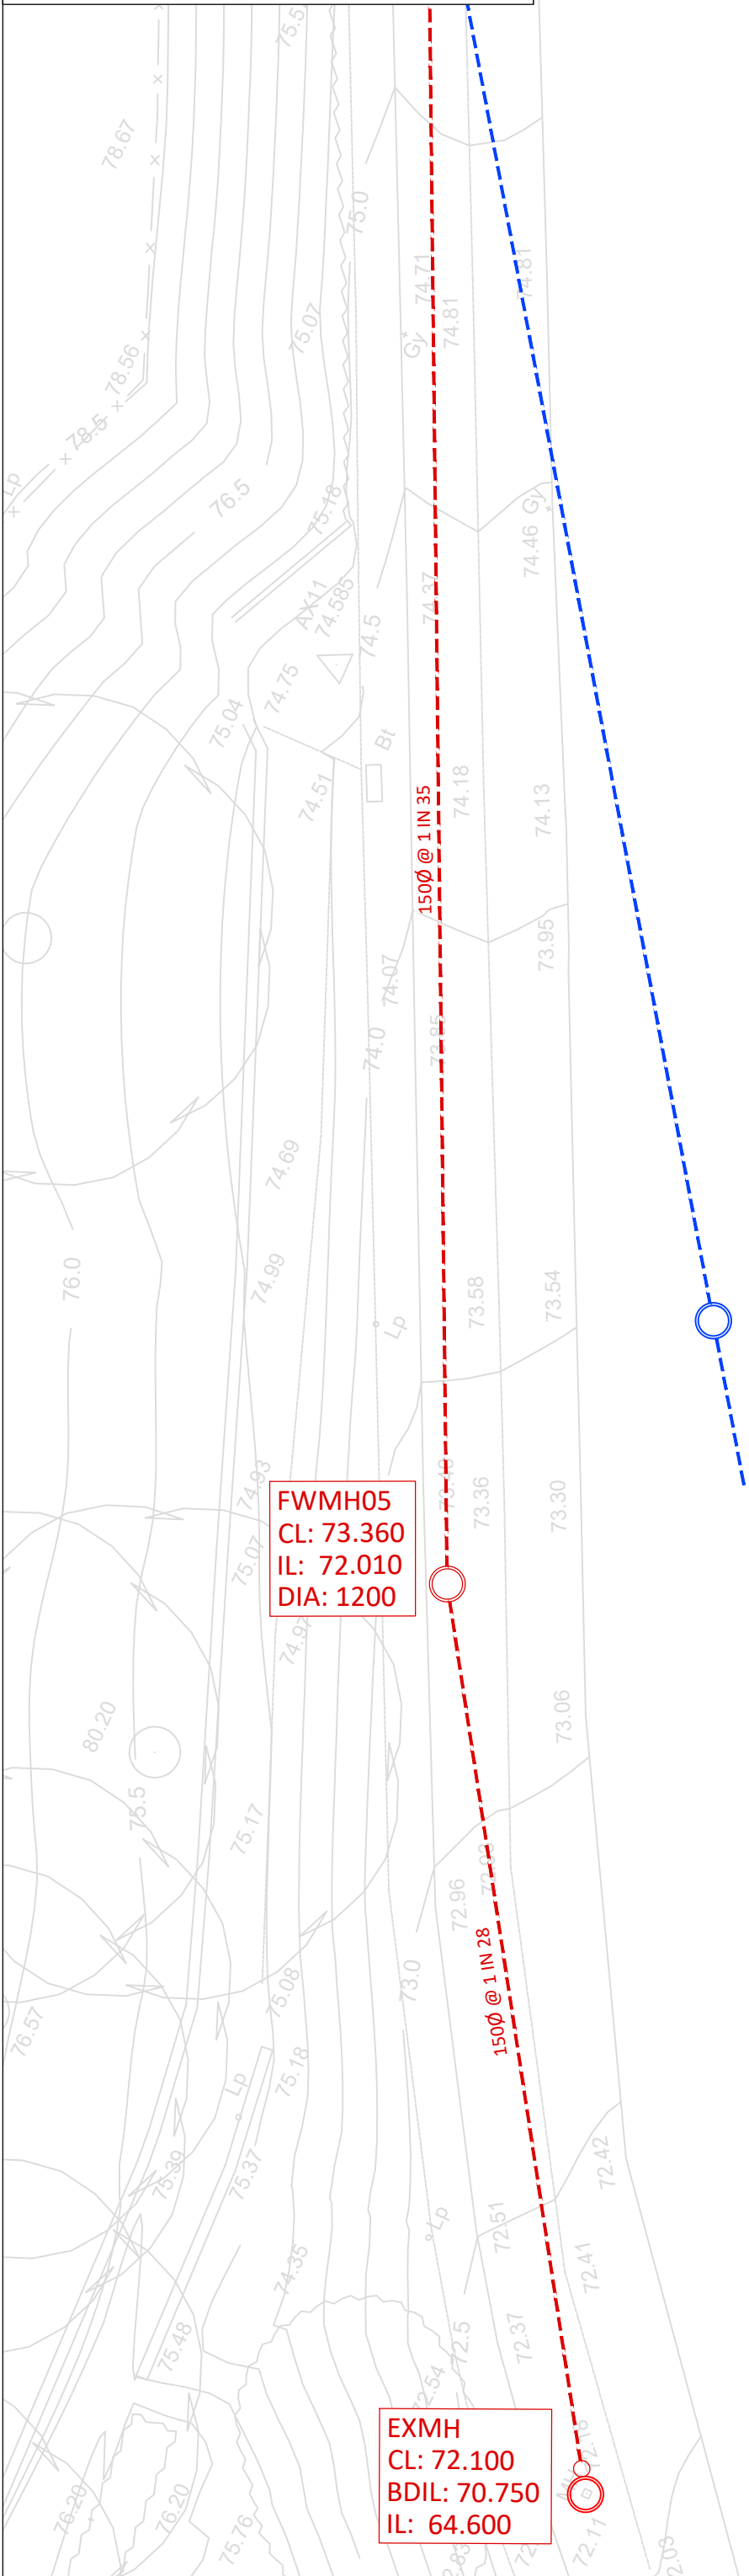


- Notes:**
- All dimensions are to be checked on site before the commencement of works. Any discrepancies are to be reported to the Architect & Engineer for verification. Figured dimensions only are to be taken from this drawing.
 - This drawing is to be read in conjunction with all relevant Engineers' and Service Engineers' drawings and specifications.
 - All RWP and pop-up locations are assumed, pending detailed design.
 - Outfall invert levels to be confirmed by survey prior to construction. Final outfall location may be changed for construction.
 - Drainage layout may be subject to change once the detailed design is carried

SAFETY, HEALTH AND ENVIRONMENTAL INFORMATION
IN ADDITION TO THE HAZARDS/RISKS NORMALLY ASSOCIATED WITH THE TYPES OF WORK DETAILED ON THIS DRAWING, NOTE THE FOLLOWING
CONSTRUCTION
MAINTENANCE / CLEANING
DECOMMISSIONING / DEMOLITION
IT IS ASSUMED THAT ALL WORKS WILL BE CARRIED OUT BY A COMPETENT CONTRACTOR WORKING, WHERE APPROPRIATE, TO AN APPROVED METHOD STATEMENT

- Key:**
- SURFACE WATER DRAINAGE
 - FOUL WATER DRAINAGE
 - FOUL WATER MANHOLE
 - SURFACE WATER MANHOLE
 - SURFACE WATER CHANNEL DRAIN
 - FOUL WATER CHANNEL DRAIN
 - BIN STORE CATCHMENT DRAINING TO FOUL NETWORK
 - ATTENUATION TANK
 - BIO-RETENTION AREA / RAINGARDEN
 - EXISTING SURFACE WATER DRAINAGE
 - EXISTING FOUL WATER DRAINAGE

P2	13.03.24	REVISED TO LATEST LAYOUT	TF	CF
P1	19.01.24	FIRST ISSUE	BP	CF
Rev	Date	Description	By	Ckd

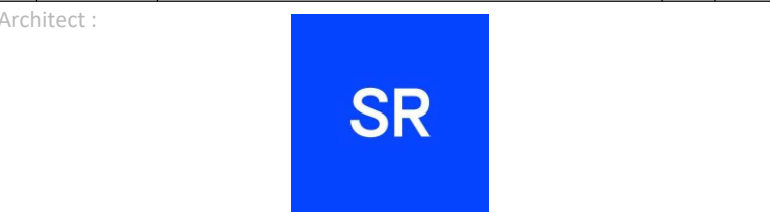

Project Title:

NORTH MANCHESTER GENERAL HOSPITAL

Drawing Title:

DRAINAGE LAYOUT

Drawing Status:

PLANNING

Hydrock Job No:

C32425

Drawn	Checked	Scale @ A1	Date	Issue Date
BP	CF	1:250	19.01.2024	19.01.2024

Drawing Number:

32425-HYD-XX-XX-DR-D-0500

Revision:

P2