



SITE LOCATION

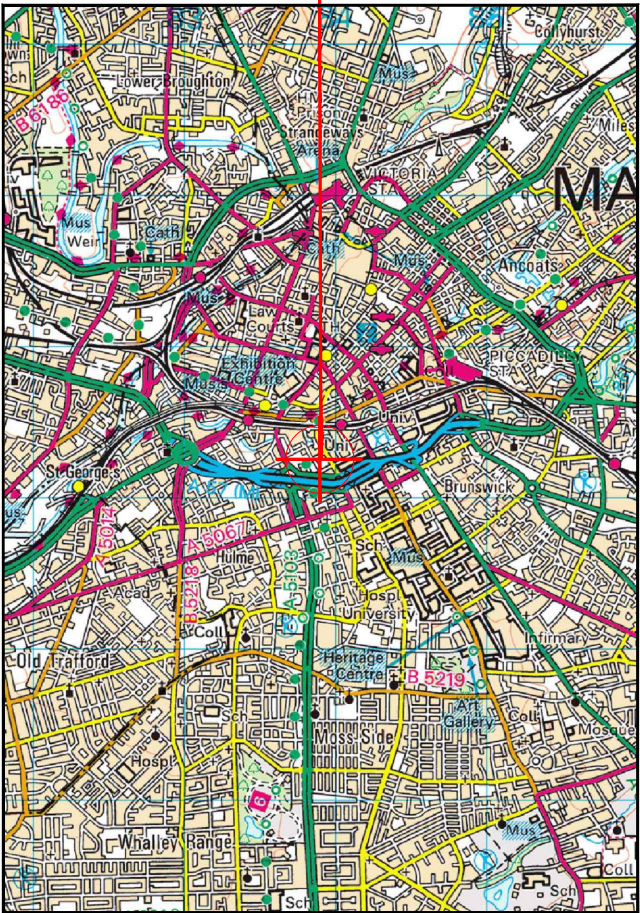

Reproduced by permission of Ordnance Survey on behalf of the Controller of Her Majesty's Stationery Office
All rights reserved. © Crown Copyright licence no. 100022432

SITE AREA PLAN

 
Scale 1:1000



SITE PHOTOGRAPH



SITE LOCATION

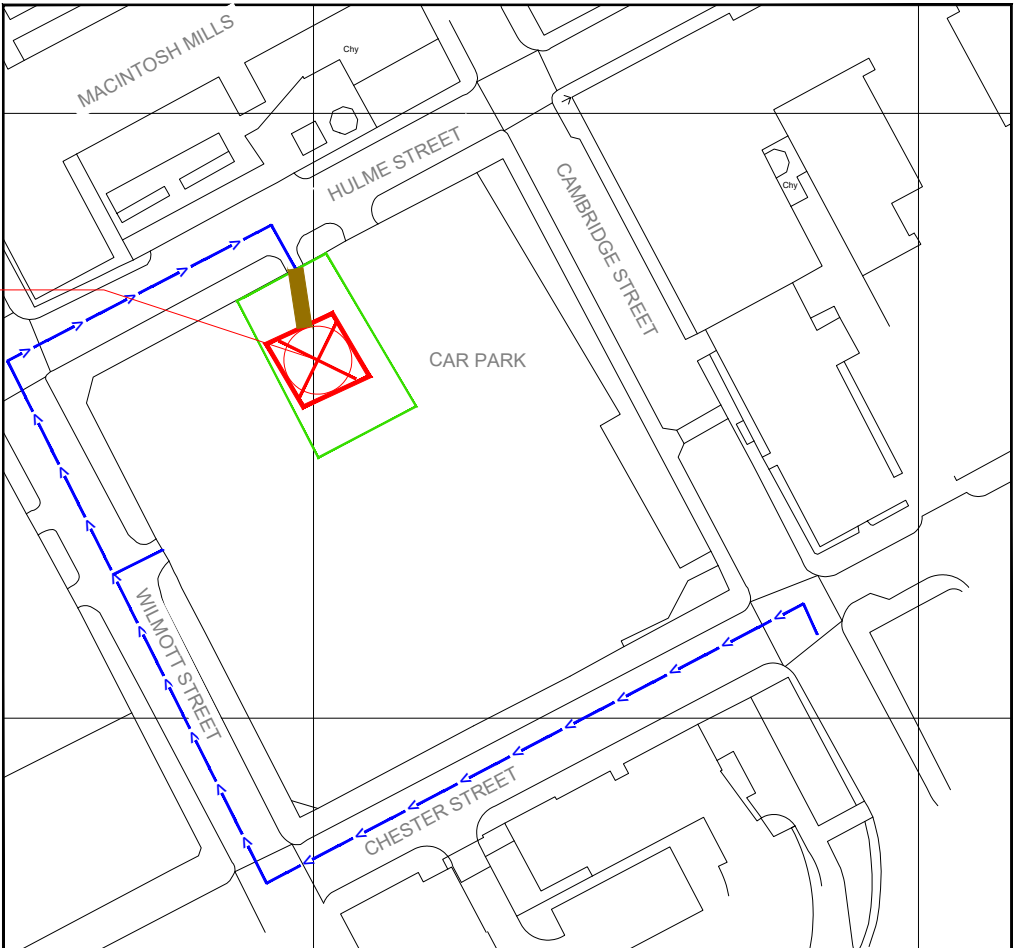


Reproduced by permission of Ordnance Survey on
behalf of the Controller of Her Majesty's Stationery Office
All rights reserved. © Crown Copyright licence no.
100022432

NGR E: 383901N: 397267

SITE LOCATION PLAN

 Scale 1:1250



GOOGLE MAPS QR CODE

<https://goo.gl/maps/n8BifHXX5rgbMv959>

<https://goo.gl/maps/LuqN3QyWiZnt6Eyz8>

NOTES:

1. ALL DIMENSIONS IN MM UNLESS OTHERWISE NOTED.

From M62 heading Eastbound, come to the end of the road and continue straight on to Regent Road.
Continue on straight and join the A57(M).
Take the third exit for the a5067 Cambridge Street. Take the first left onto Chester Street.
Take the first right on to Wilmott Street access to site is via gate on right hand side of the road.
For alternative site entrance continue down Wilmott Street and take the first right onto Hulme Street. Site entrance is on the right, half way down Hulme Street before you come to the car park.

Site Demise:



Access Route To Site:



Access Route:



Master:	MBNL / EE / H3G:	Project:	Purpose of Issue:	Issue:
M004	MBNL	T&A	Planning	D
Date:	09/07/20	Revision / Upgrade Description:		
Drawn:	R. PERKINS	Dish height amended		
Checked:	A. FANNING			
Approved:	P. CONVERY			
Master:	MBNL / EE / H3G:	Project:	Purpose of Issue:	Issue:
M003	MBNL	T&A	Planning	C
Date:	08/06/20	Revision / Upgrade Description:		
Drawn:	A. FANNING	Design solution amended		
Checked:	P. CONVERY			
Approved:	P. CONVERY			
Master:	MBNL / EE / H3G:	Project:	Purpose of Issue:	Issue:
M002	MBNL	T&A	Planning	B
Date:	19/05/20	Revision / Upgrade Description:		
Drawn:	R. PERKINS	Antennas and cabinets updated		
Checked:	A. FANNING			
Approved:	P. CONVERY			
Master:	MBNL / EE / H3G:	Project:	Purpose of Issue:	Issue:
M001	MBNL	T&A	Planning	A
Date:	13/03/20	Revision / Upgrade Description:		
Drawn:	D. PARTON	First Issue - Site nomination dated: 17/02/2020		
Checked:	S. TAYLOR			
Approved:	S. TAYLOR			



Hutchison 3G UK Limited
Star House, 20 Grenfell Road
Maidenhead, SL6 1EH
Tel: 01628 765 000
Fax: 01628 765 001



Hatfield Business Park
Hatfield
Hertfordshire
AL10 9BW
Tel: 01707 315000
Fax: 01707 319001



Mobile Broadband Network Limited
Sixth Floor, Thames Tower, Station Road, Reading, RG1 1LX

Design Consultant & Principal Contractor:



WHP Telecoms

Unit 1 Maple Park,
Low Fields Avenue, Leeds
LS12 6HH

Tel: 01133023550
e-mail: info@whptelecoms.com

Site Name:
1 WILMOTT STREET TEMP

Site ID:
1567499

Address:
1 WILMOTT STREET
MANCHESTER
GREATER MANCHESTER
M15 6BD


Title:
002 SITE LOCATION PLAN

Project:
NTQ

Purpose of Issue:
GENERAL ARRANGEMENT

EE Cell ID:	MBNL Cell ID:	3UK Cell ID:
37904	MAN429	-

Master Drawing No:	Issue:
1567499_MAN429_37904_M004_GA	D

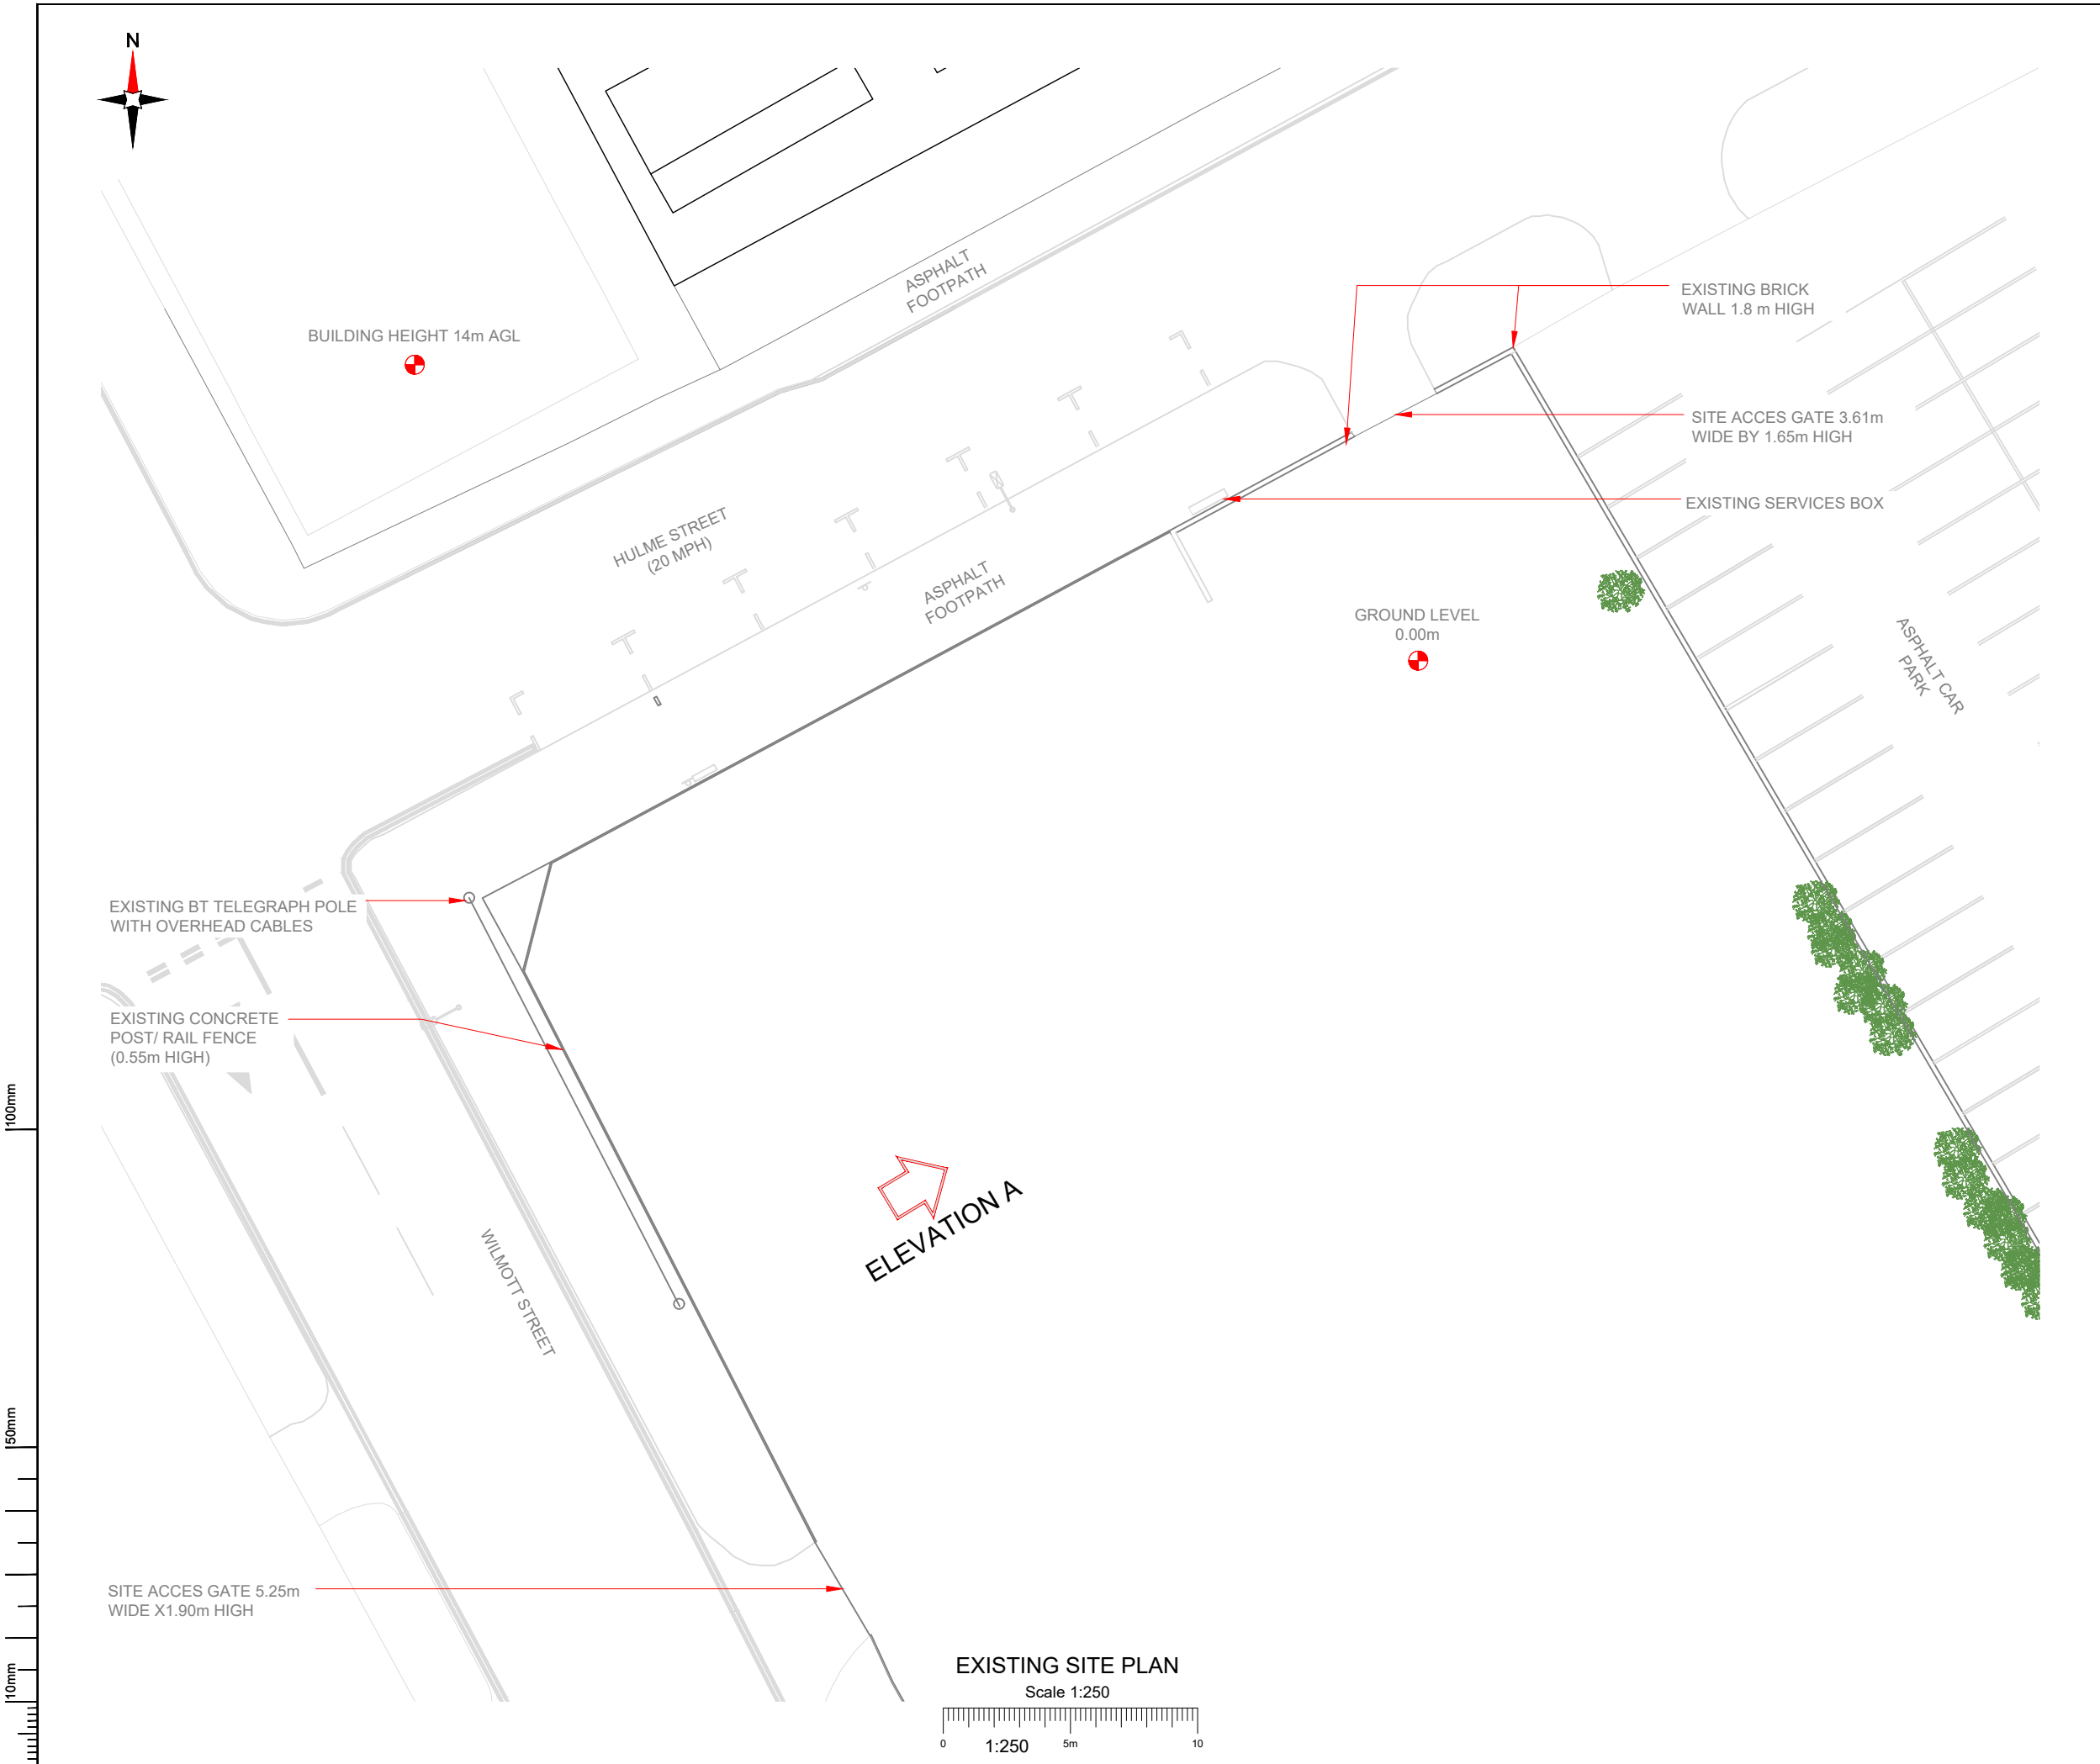

- NOTES:
- ALL DIMENSIONS IN MM UNLESS OTHERWISE NOTED.

Master:	MBNL / EE / H3G:	Project:	Purpose of Issue:	Issue:
M004	MBNL	T&A	Planning	D
Date:	09/07/20	Revision / Upgrade Description:		
Drawn:	R. PERKINS	Dish height amended		
Checked:	A. FANNING			
Approved:	P. CONVERY			
Master:	MBNL / EE / H3G:	Project:	Purpose of Issue:	Issue:
M003	MBNL	T&A	Planning	C
Date:	08/06/20	Revision / Upgrade Description:		
Drawn:	A. FANNING	Design solution amended		
Checked:	P. CONVERY			
Approved:	P. CONVERY			
Master:	MBNL / EE / H3G:	Project:	Purpose of Issue:	Issue:
M002	MBNL	T&A	Planning	B
Date:	19/05/20	Revision / Upgrade Description:		
Drawn:	R. PERKINS	Antennas and cabinets updated		
Checked:	A. FANNING			
Approved:	P. CONVERY			
Master:	MBNL / EE / H3G:	Project:	Purpose of Issue:	Issue:
M001	MBNL	T&A	Planning	A
Date:	13/03/20	Revision / Upgrade Description:		
Drawn:	D. PARTON	First Issue - Site nomination dated: 17/02/2020		
Checked:	S. TAYLOR			
Approved:	S. TAYLOR			



Hutchison 3G UK Limited
Star House, 20 Grenfell Road
Maidenhead, SL6 1EH
Tel: 01628 765 000
Fax: 01628 765 001



Hatfield Business Park
Hatfield
Hertfordshire
AL10 9BW
Tel: 01707 315000
Fax: 01707 319001

MBNL Mobile Broadband Network Limited
Sixth Floor, Thames Tower, Station Road, Reading, RG1 1LX

Design Consultant & Principal Contractor:



WHP Telecoms
Unit 1 Maple Park,
Low Fields Avenue, Leeds
LS12 6HH
Tel: 01133023550
e-mail: info@whptelecoms.com

Site Name:
1 WILMOTT STREET TEMP

Site ID:
1567499

Address:
**1 WILMOTT STREET
MANCHESTER
GREATER MANCHESTER
M15 6BD**

Title:
100 EXISTING SITE PLAN

Project:
NTQ

Purpose of Issue:
GENERAL ARRANGEMENT

EE Cell ID:	MBNL Cell ID:	3UK Cell ID:
37904	MAN429	-


Master Drawing No:
1567499_MAN429_37904_M004_GA

Issue:
D

100mm

150mm

10mm

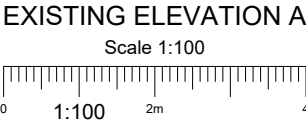

- NOTES:
1. ALL DIMENSIONS IN MM UNLESS OTHERWISE NOTED.

Master:	MBNL / EE / H3G:	Project:	Purpose of Issue:	Issue:
M004	MBNL	T&A	Planning	D
Date:	09/07/20	Revision / Upgrade Description:		
Drawn:	R. PERKINS	Dish height amended		
Checked:	A. FANNING			
Approved:	P. CONVERY			
Master:	MBNL / EE / H3G:	Project:	Purpose of Issue:	Issue:
M003	MBNL	T&A	Planning	C
Date:	08/06/20	Revision / Upgrade Description:		
Drawn:	A. FANNING	Design solution amended		
Checked:	P. CONVERY			
Approved:	P. CONVERY			
Master:	MBNL / EE / H3G:	Project:	Purpose of Issue:	Issue:
M002	MBNL	T&A	Planning	B
Date:	19/05/20	Revision / Upgrade Description:		
Drawn:	R. PERKINS	Antennas and cabinets updated		
Checked:	A. FANNING			
Approved:	P. CONVERY			
Master:	MBNL / EE / H3G:	Project:	Purpose of Issue:	Issue:
M001	MBNL	T&A	Planning	A
Date:	13/03/20	Revision / Upgrade Description:		
Drawn:	D. PARTON	First Issue - Site nomination dated: 17/02/2020		
Checked:	S. TAYLOR			
Approved:	S. TAYLOR			



Hutchison 3G UK Limited
Star House, 20 Grenfell Road
Maidenhead, SL6 1EH
Tel: 01628 765 500
Fax: 01628 765 501



Hatfield Business Park
Hatfield
Hertfordshire
AL10 9BW
Tel: 01707 315000
Fax: 01707 319001



Mobile Broadband Network Limited
Sixth Floor, Thames Tower, Station Road, Reading, RG1 1LX

Design Consultant & Principal Contractor:



WHP Telecoms
Unit 1 Maple Park,
Low Fields Avenue, Leeds
LS12 6HH

Tel: 01133023550
e-mail: info@whptelecoms.com

Site Name:
1 WILMOTT STREET TEMP

Site ID:
1567499

Address:
1 WILMOTT STREET
MANCHESTER
GREATER MANCHESTER
M15 6BD


Title:
150 EXISTING ELEVATION A

Project:
NTQ

Purpose of Issue:
GENERAL ARRANGEMENT

EE Cell ID:	MBNL Cell ID:	3UK Cell ID:
37904	MAN429	-

Master Drawing No:	Issue:
1567499_MAN429_37904_M004_GA	D

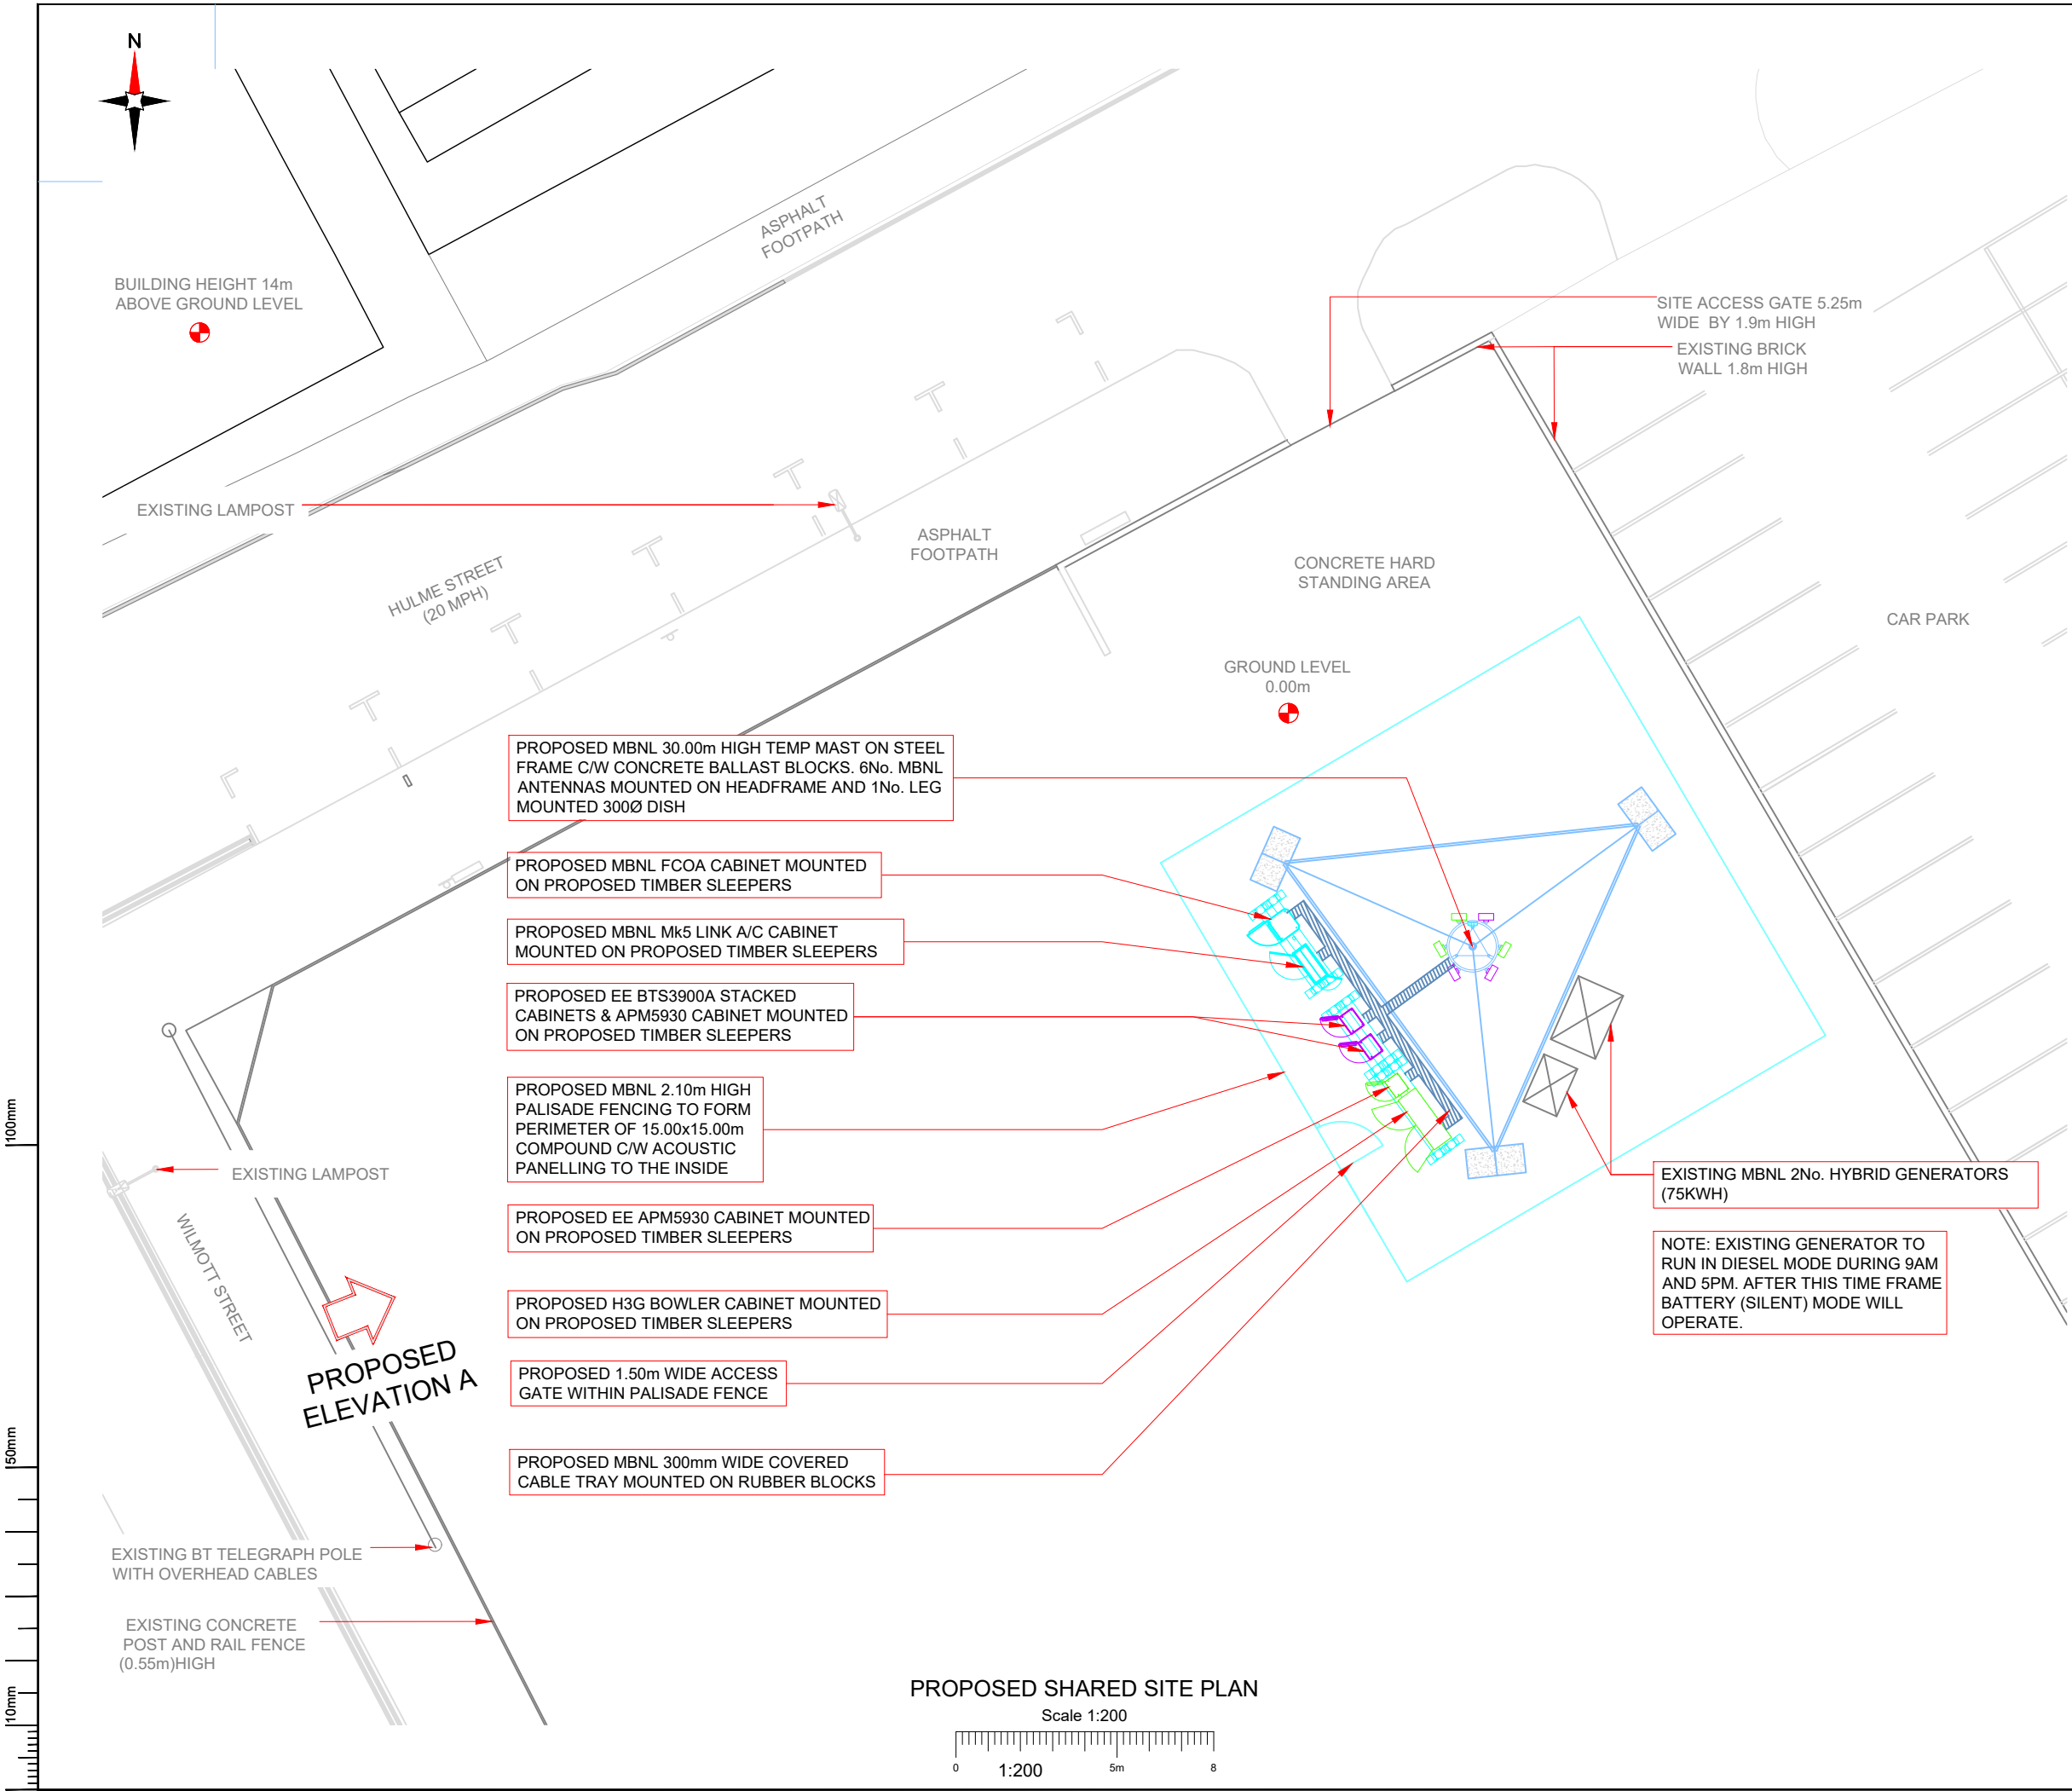

- NOTES:
- ALL DIMENSIONS IN MM UNLESS OTHERWISE NOTED.

SHARED CONFIGURATION SITE

CONFIG TYPE Temp B

Master:	MBNL / EE / H3G:	Project:	Purpose of Issue:	Issue:
M004	MBNL	T&A	Planning	D
Date:	09/07/20	Revision / Upgrade Description:		
Drawn:	R. PERKINS	Dish height amended		
Checked:	A. FANNING			
Approved:	P. CONVERY			
Master:	MBNL / EE / H3G:	Project:	Purpose of Issue:	Issue:
M003	MBNL	T&A	Planning	C
Date:	08/06/20	Revision / Upgrade Description:		
Drawn:	A. FANNING	Design solution amended		
Checked:	P. CONVERY			
Approved:	P. CONVERY			
Master:	MBNL / EE / H3G:	Project:	Purpose of Issue:	Issue:
M002	MBNL	T&A	Planning	B
Date:	19/05/20	Revision / Upgrade Description:		
Drawn:	R. PERKINS	Antennas and cabinets updated		
Checked:	A. FANNING			
Approved:	P. CONVERY			
Master:	MBNL / EE / H3G:	Project:	Purpose of Issue:	Issue:
M001	MBNL	T&A	Planning	A
Date:	13/03/20	Revision / Upgrade Description:		
Drawn:	D. PARTON	First Issue - Site nomination dated: 17/02/2020		
Checked:	S. TAYLOR			
Approved:	S. TAYLOR			



Hutchison 3G UK Limited
Star House, 20 Grenfell Road
Maidenhead, SL6 1EH
Tel: 01628 765 000
Fax: 01628 765 001



Hatfield Business Park
Hatfield
Hertfordshire
AL10 9BW
Tel: 01707 315000
Fax: 01707 319001



Mobile Broadband Network Limited
Sixth Floor, Thames Tower, Station Road, Reading, RG1 1LX

Design Consultant & Principal Contractor:



WHP Telecoms
Unit 1 Maple Park,
Low Fields Avenue, Leeds
LS12 6HH

Tel: 01133023550
e-mail: info@whptelecoms.com

Site Name:
1 WILMOTT STREET TEMP

Site ID:
1567499

Address:
1 WILMOTT STREET
MANCHESTER
GREATER MANCHESTER
M15 6BD

Title:
200 PROPOSED SHARED SITE PLAN

Project:
NTQ

Purpose of Issue:
GENERAL ARRANGEMENT


EE Cell ID: 37904	MBNL Cell ID: MAN429	3UK Cell ID: -
----------------------	-------------------------	-------------------

Master Drawing No: 1567499_MAN429_37904_M004_GA	Issue: D
--	-------------

100mm

150mm

10mm

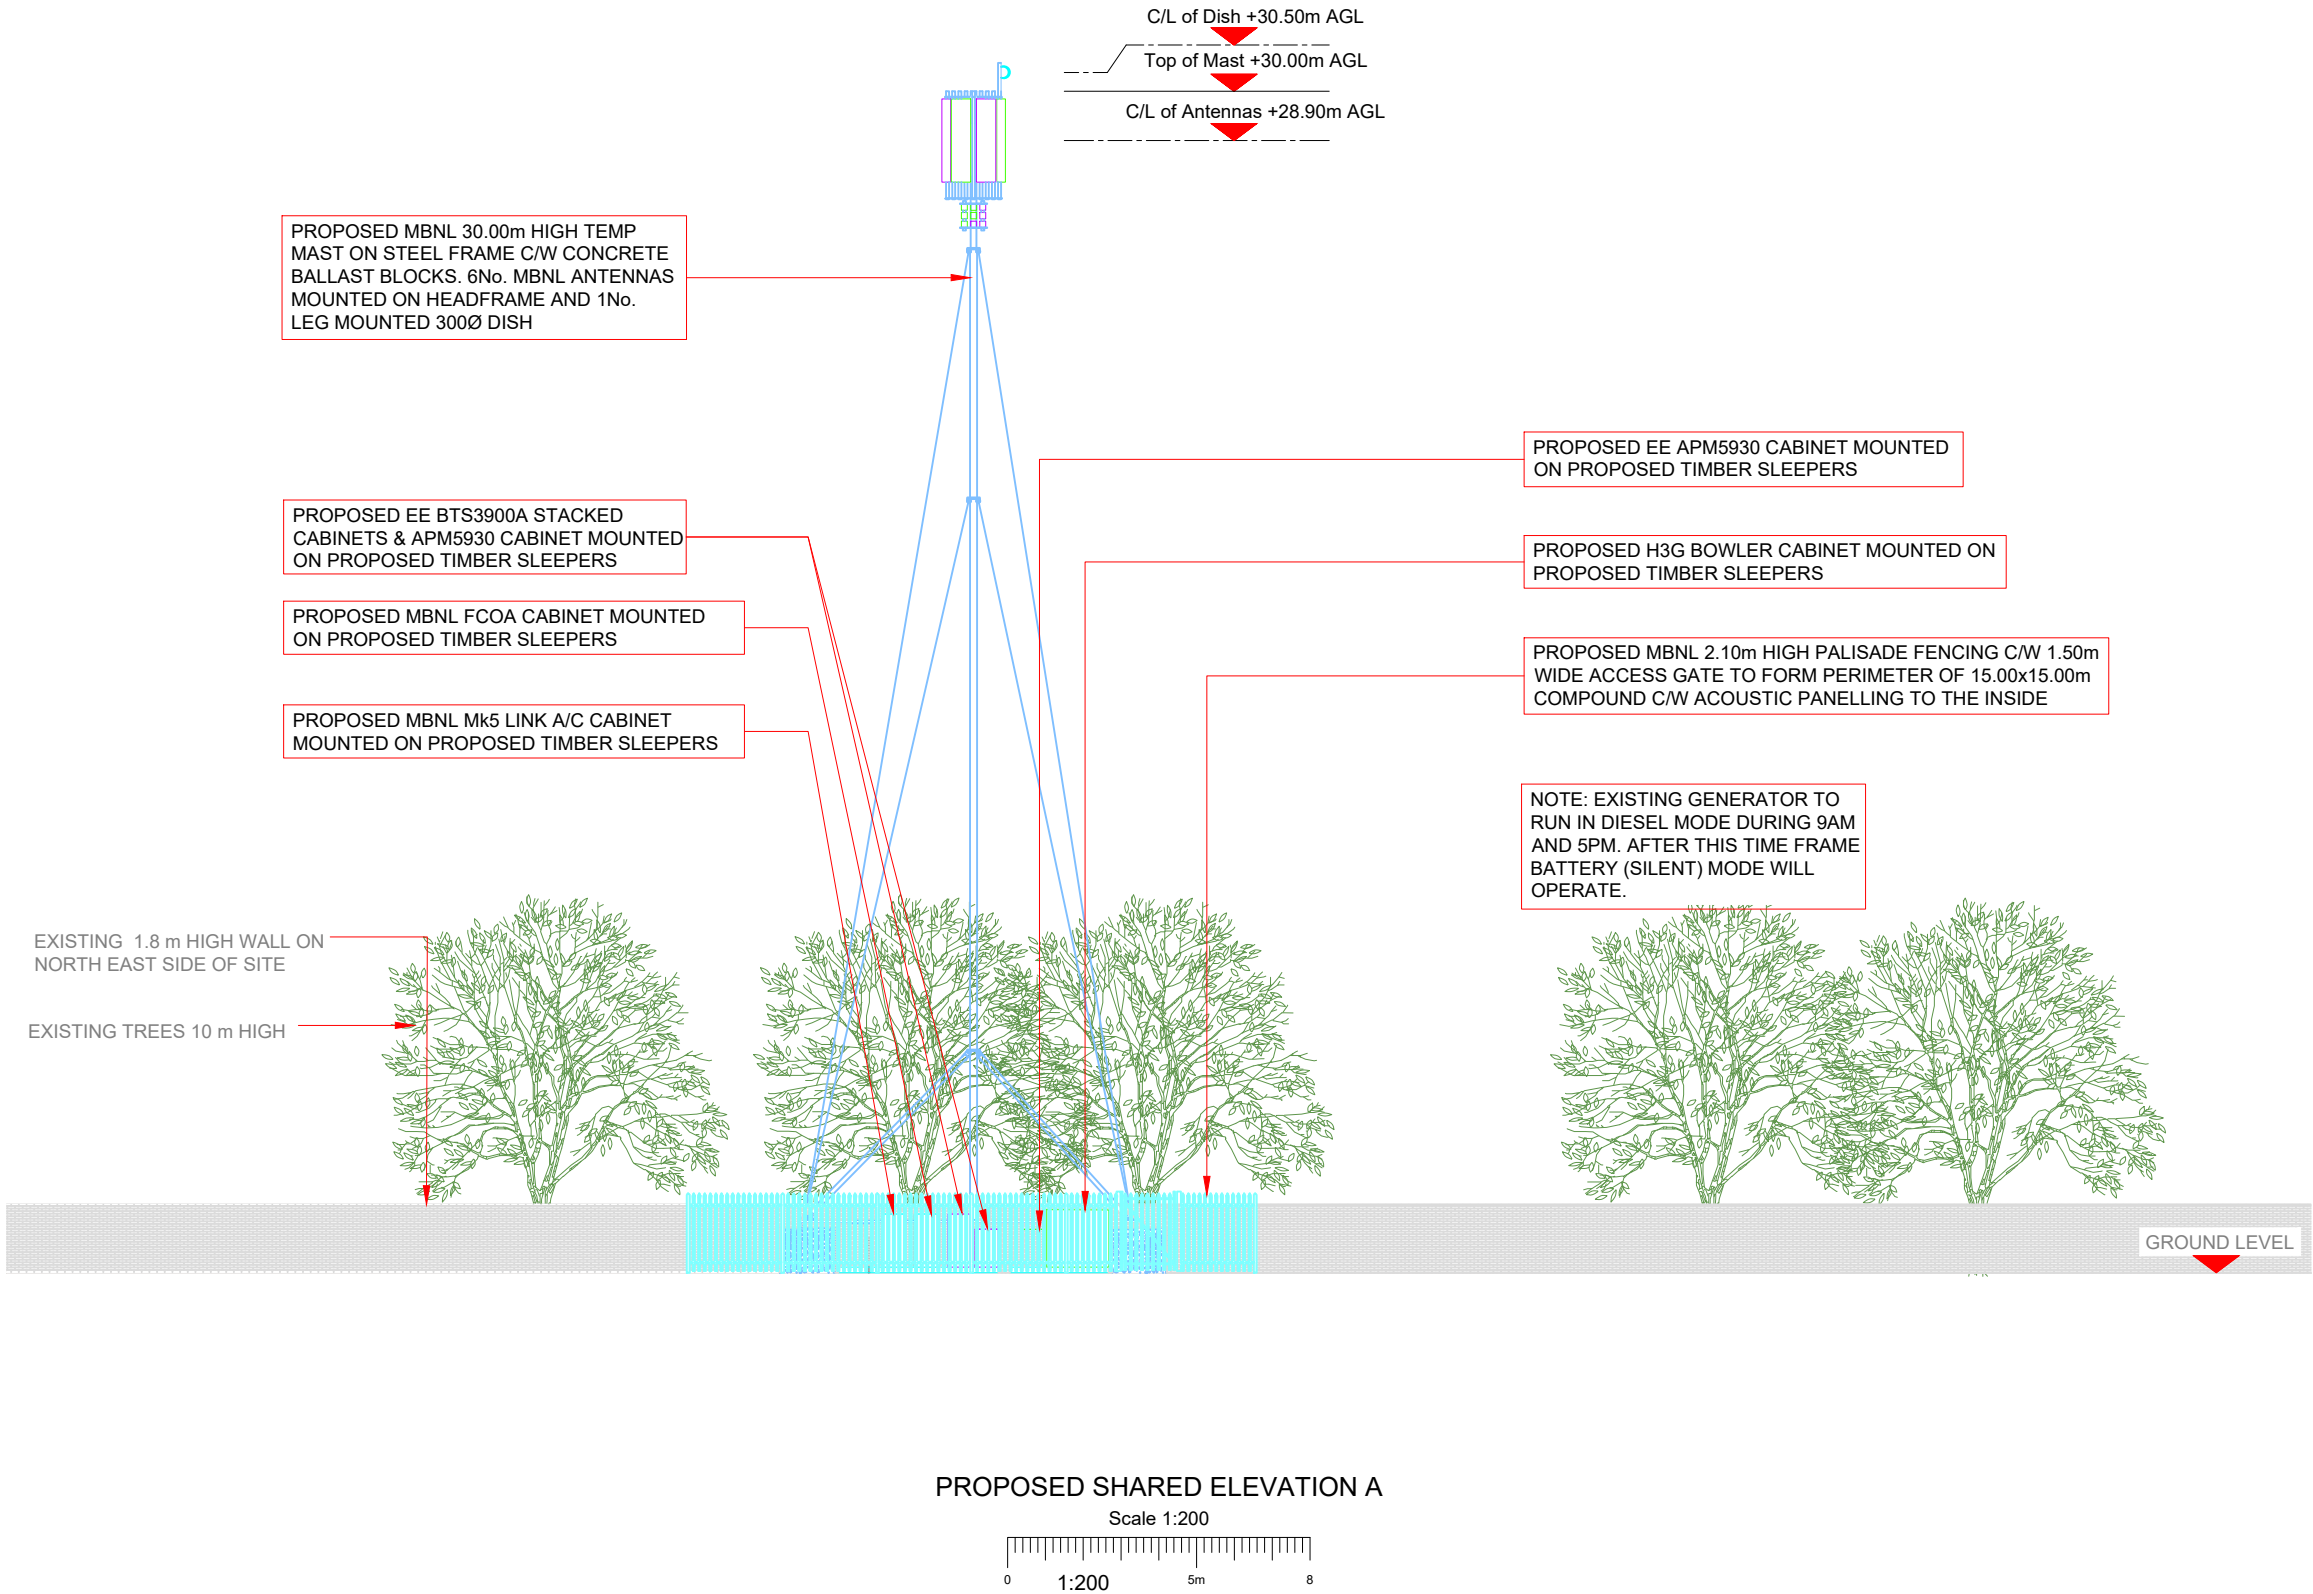

- NOTES:
- ALL DIMENSIONS IN MM UNLESS OTHERWISE NOTED.

SHARED CONFIGURATION SITE

CONFIG TYPE

Temp B

Master:	MBNL / EE / H3G:	Project:	Purpose of Issue:	Issue:
M004	MBNL	T&A	Planning	D
Date:	09/07/20	Revision / Upgrade Description:		
Drawn:	R. PERKINS	Dish height amended		
Checked:	A. FANNING			
Approved:	P. CONVERY			
Master:	MBNL / EE / H3G:	Project:	Purpose of Issue:	Issue:
M003	MBNL	T&A	Planning	C
Date:	08/06/20	Revision / Upgrade Description:		
Drawn:	A. FANNING	Design solution amended		
Checked:	P. CONVERY			
Approved:	P. CONVERY			
Master:	MBNL / EE / H3G:	Project:	Purpose of Issue:	Issue:
M002	MBNL	T&A	Planning	B
Date:	19/05/20	Revision / Upgrade Description:		
Drawn:	R. PERKINS	Antennas and cabinets updated		
Checked:	A. FANNING			
Approved:	P. CONVERY			
Master:	MBNL / EE / H3G:	Project:	Purpose of Issue:	Issue:
M001	MBNL	T&A	Planning	A
Date:	13/03/20	Revision / Upgrade Description:		
Drawn:	D. PARTON	First Issue - Site nomination dated: 17/02/2020		
Checked:	S. TAYLOR			
Approved:	S. TAYLOR			



Hutchison 3G UK Limited
Star House, 20 Grenfell Road
Maidenhead, SL6 1EH
Tel: 01628 765 000
Fax: 01628 765 001



Hatfield Business Park
Hatfield
Hertfordshire
AL10 9BW
Tel: 01707 315000
Fax: 01707 319001



Mobile Broadband Network Limited
Sixth Floor, Thames Tower, Station Road, Reading, RG1 1LX

Design Consultant & Principal Contractor:



WHP Telecoms
Unit 1 Maple Park,
Low Fields Avenue, Leeds
LS12 6HH

Tel: 01133023550
e-mail: info@whptelecoms.com

Site Name:
1 WILMOTT STREET TEMP

Site ID:
1567499

Address:
1 WILMOTT STREET
MANCHESTER
GREATER MANCHESTER
M15 6BD

Title:
250 PROPOSED SHARED ELEVATION A

Project:
NTQ

Purpose of Issue:
GENERAL ARRANGEMENT

EE Cell ID: 37904	MBNL Cell ID: MAN429	3UK Cell ID: -
----------------------	-------------------------	-------------------

Master Drawing No: 1567499_MAN429_37904_M004_GA	Issue: D
--	-------------

Max Configuration Antenna Aperture Schedule & RF Equipment Capacity																	
Antenna Aperture ID	Antenna Aperture Size (Length x Width x Depth)	Aperture Height C/L	Aperture Max Weight (kg)	Proposed 4G/5G Bearing	Tech: 4G/5G	Operator: Shared/ EE/H3G	Antenna Aperture Coordinates		RRU No. Max Size & Weight L=300mm W=400mm D=150mm Weight=25kg	MHA No. Max Size & Weight L=300mm W=300mm D=150mm Weight=10kg	Main Feeder			BOB Max Size & Weight (300x300x250mm & 5kg)		Active Router No. Max Size & Weight (370x260x150mm & 10kg)	Passive Router No. Max Size & Weight (350x220x150mm & 10kg)
							Eastings	Northings			Size	Length	No.	No. Top	No. Bottom		
A1	2200x550x350mm	28.90m	100kg	0°	2G/3G/4G	EE	-	-	-	4	LDF5-50	30m	6	-	-	-	-
A2	2200x550x350mm	28.90m	100kg	0°	2G/3G/4G	H3G	-	-	-	5	LDF5-50	30m	6	-	-	-	-
B1	2200x550x350mm	28.90m	100kg	120°	2G/3G/4G	EE	-	-	-	4	LDF5-50	30m	6	-	-	-	-
B2	2200x550x350mm	28.90m	100kg	120°	2G/3G/4G	H3G	-	-	-	5	LDF5-50	30m	6	-	-	-	-
C1	2200x550x350mm	28.90m	100kg	240°	2G/3G/4G	EE	-	-	-	4	LDF5-50	30m	6	-	-	-	-
C2	2200x550x350mm	28.90m	100kg	240°	2G/3G/4G	H3G	-	-	-	5	LDF5-50	30m	6	-	-	-	-

Passive Infrastructure Equipment Capacity		
A	B	C
Temp B	Temp B	Temp B

STATUS KEY:

Installed:

Retain:

Relocate:

Remove:

Proposed:

Existing

Existing and to remain

Existing and to be relocated

Existing to be removed from site

New on site

Master: M004

MBNL

MBNL / EE / H3G:

Date: 09/07/20

Drawn: R. PERKINS

Checked: A. FANNING

Approved: P. CONVERY

Project: T&A

Purpose of Issue: Planning

Issue: D

Revision / Upgrade Description:

Dish height amended

Master: M003

MBNL

MBNL / EE / H3G:

Date: 08/06/20

Drawn: A. FANNING

Checked: P. CONVERY

Approved: P. CONVERY

Project: T&A

Purpose of Issue: Planning

Issue: C

Revision / Upgrade Description:

Design solution amended

Master: M002

MBNL

MBNL / EE / H3G:

Date: 19/05/20

Drawn: R. PERKINS

Checked: A. FANNING

Approved: P. CONVERY

Project: T&A

Purpose of Issue: Planning

Issue: B

Revision / Upgrade Description:

Antennas and cabinets updated

Master: M001

MBNL

MBNL / EE / H3G:

Date: 13/03/20

Drawn: D.PARTON

Checked: S.TAYLOR

Approved: S.TAYLOR

Project: T&A

Purpose of Issue: Planning

Issue: A

Revision / Upgrade Description:

First Issue - Site nomination dated: 17/02/2020



Hutchison 3G UK Limited

Star House, 20 Grenfell Road

Maidenhead, SL6 1EH

Tel: 01628 765 000

Fax: 01628 765 001

H3G Base Station Information line:

0845 6043000

Available 8am-8pm Monday to Friday



Hatfield Business Park

Hatfield

Hertfordshire

AL10 9BW

Tel: 01707 315000

Fax: 01707 319001

MBNL

Mobile Broadband Network Limited

Sixth Floor, Thames Tower, Station Road, Reading, RG1 1LX

Design Consultant & Principal Contractor:



WHP Telecoms

Unit 1 Maple Park,

Low Fields Avenue, Leeds

LS12 6HH

Tel: 01133023550

e-mail: info@whptelecoms.com

Site Name:

1 WILMOTT STREET TEMP

Site ID:

1567499

Address:

1 WILMOTT STREET
MANCHESTER
GREATER MANCHESTER
M15 6BD

Title:

304 MAX CONFIGURATION ANTENNA
SCHEDULE & LINE CONFIGURATION

Project:

NTQ

Purpose of Issue:

GENERAL ARRANGEMENT

EE Cell ID:

37904

MBNL Cell ID:

MAN429

3UK Cell ID:

-

Master Drawing No:

1567499_MAN429_37904_M004_GA

Issue:

D

100mm

150mm

10mm

15