



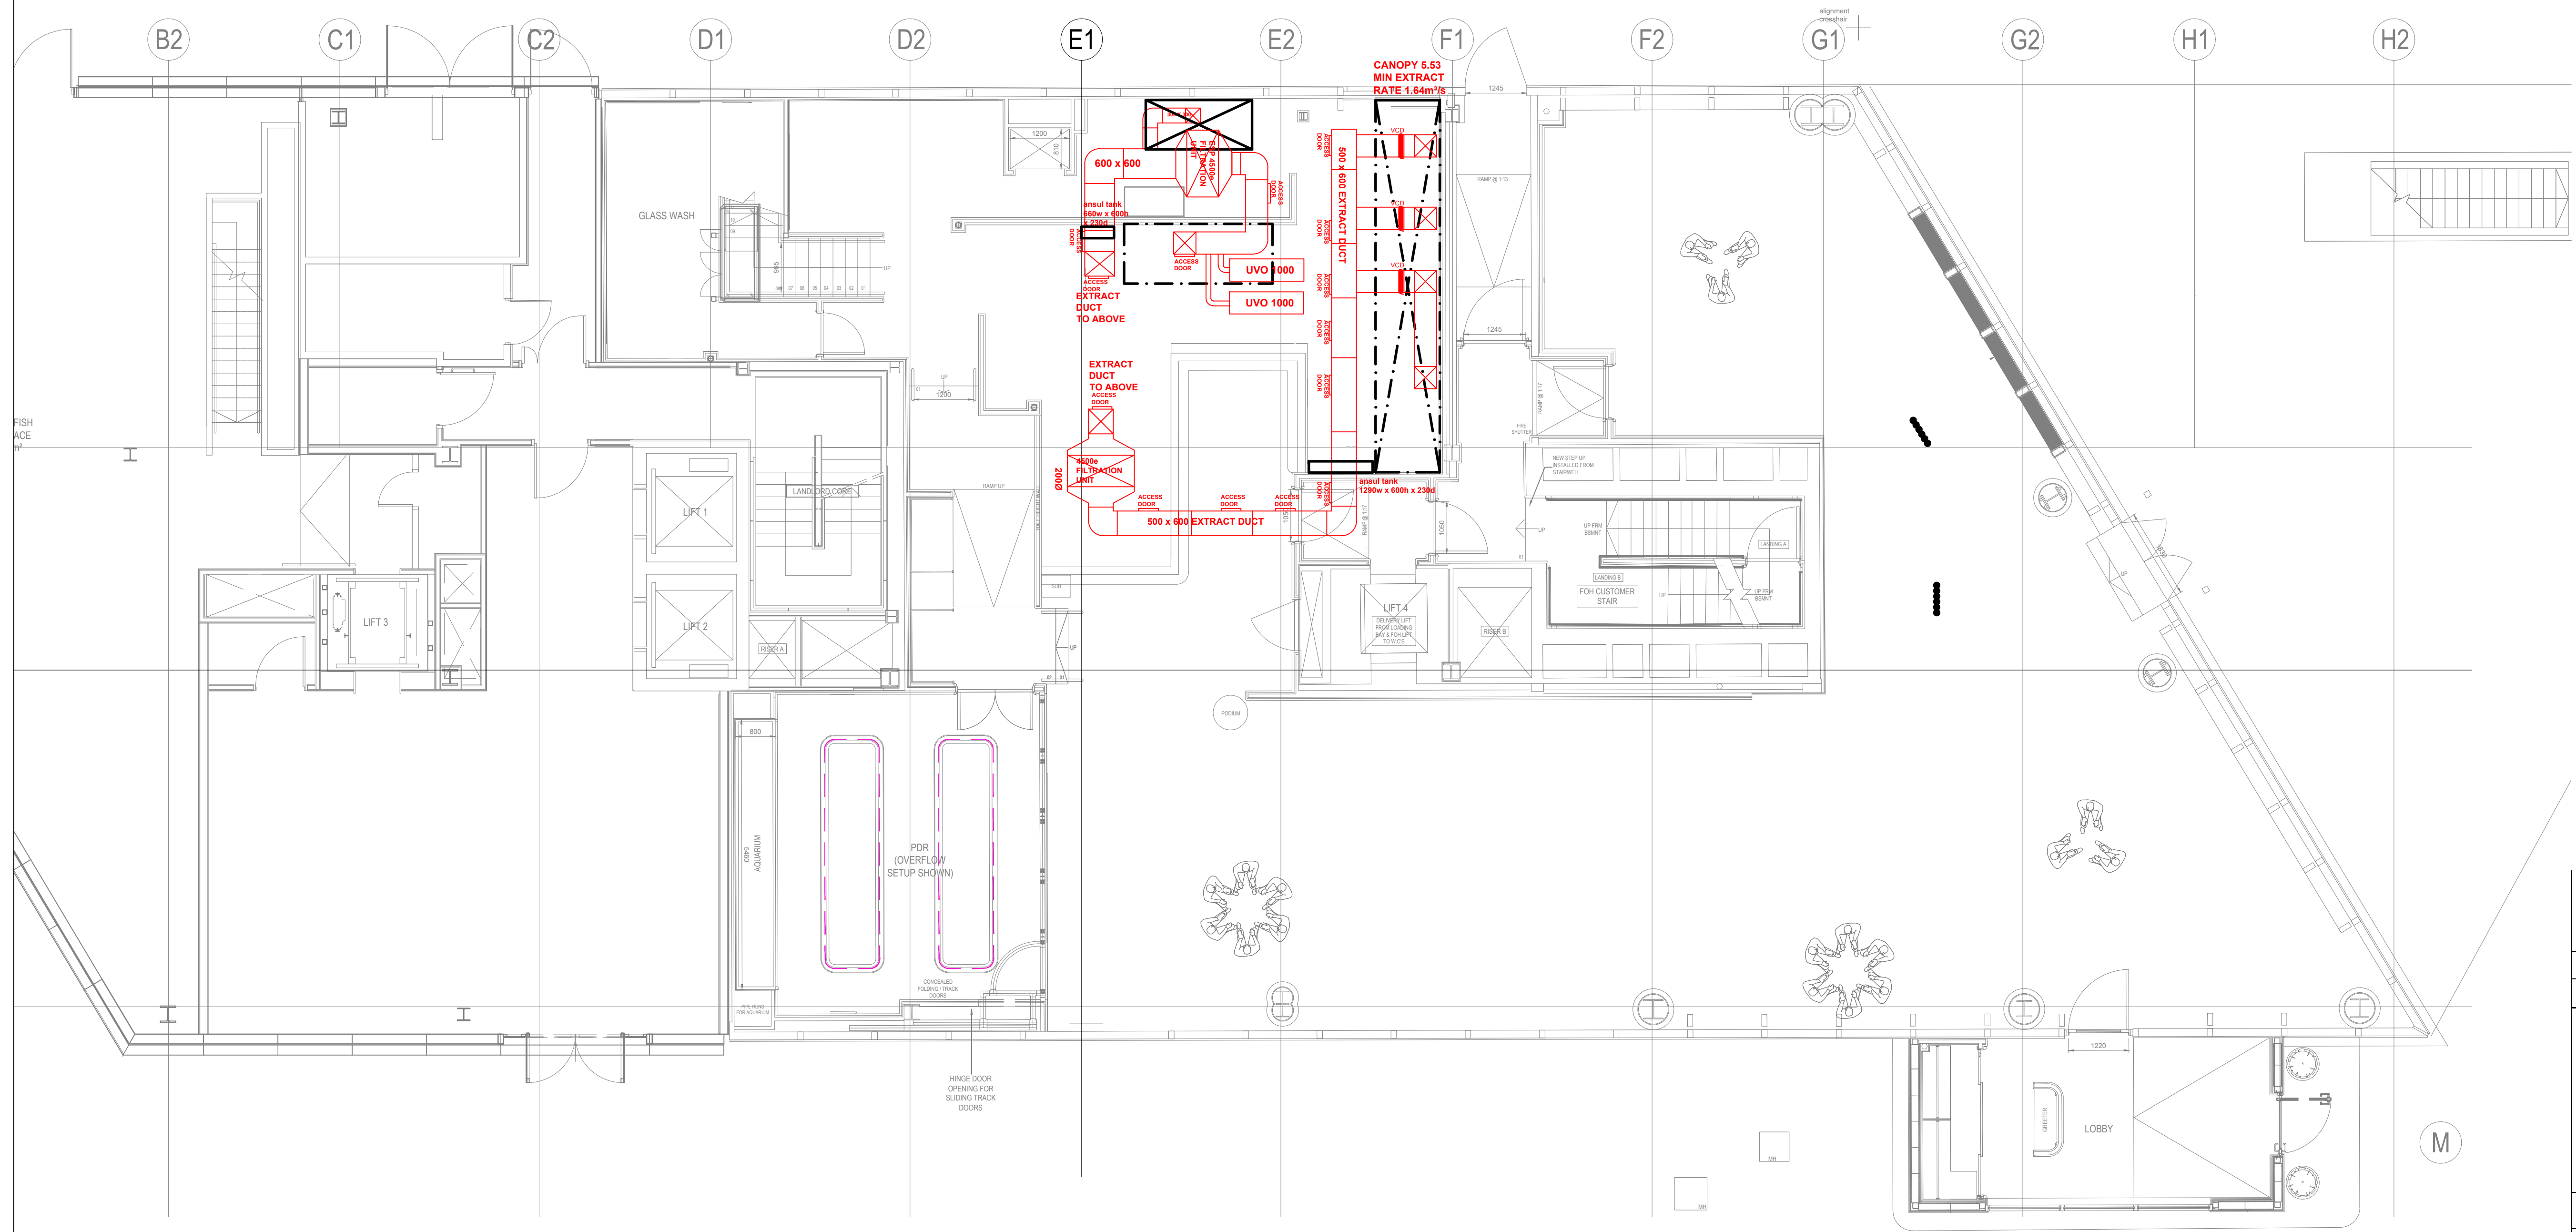


LEGEND	
	Supply Air Grill
	Extract Air Grill
	AC Cassette
	Indicative route of AC pipework
	Wall Mounted AC unit
	AC Condensor
	Extract Air Duct
	Supply Air Duct
	WC/Toilet Extract Vent
	WC/Toilet Extract Duct
	Volume Control Damper
	Fire Damper
	Non Return Damper
	Over Door Heater
	UVO Odour Control Unit
	Kitchen Extract Fan
	Kitchen Supply Fan
	General Supply Fan
	Back Of House Extract Fan
	Toilet/WC Extract Fan
	E-STOP

-	-	-
Rev	Date	Description
FWP UK LTD REFRIGERATION-AIR CONDITIONING-VENTILATION 17 Calverton Business Park Hoyle Road Calverton Nottingham NG14 6QL tel: 0115 965 5042 web: fwpuk.com		
Drawn:	Checked:	Date:
-	-	--/------
Issue: Provisional ☐ Approved ☐ As Built ☐ Current ☐		
Site Address: Sexy Fish Manchester		
Drawing Title: Ground Floor Ventilation		
Drawing Number: 21368/010	Rev: AB	Paper size: A1 Scale: 1:100

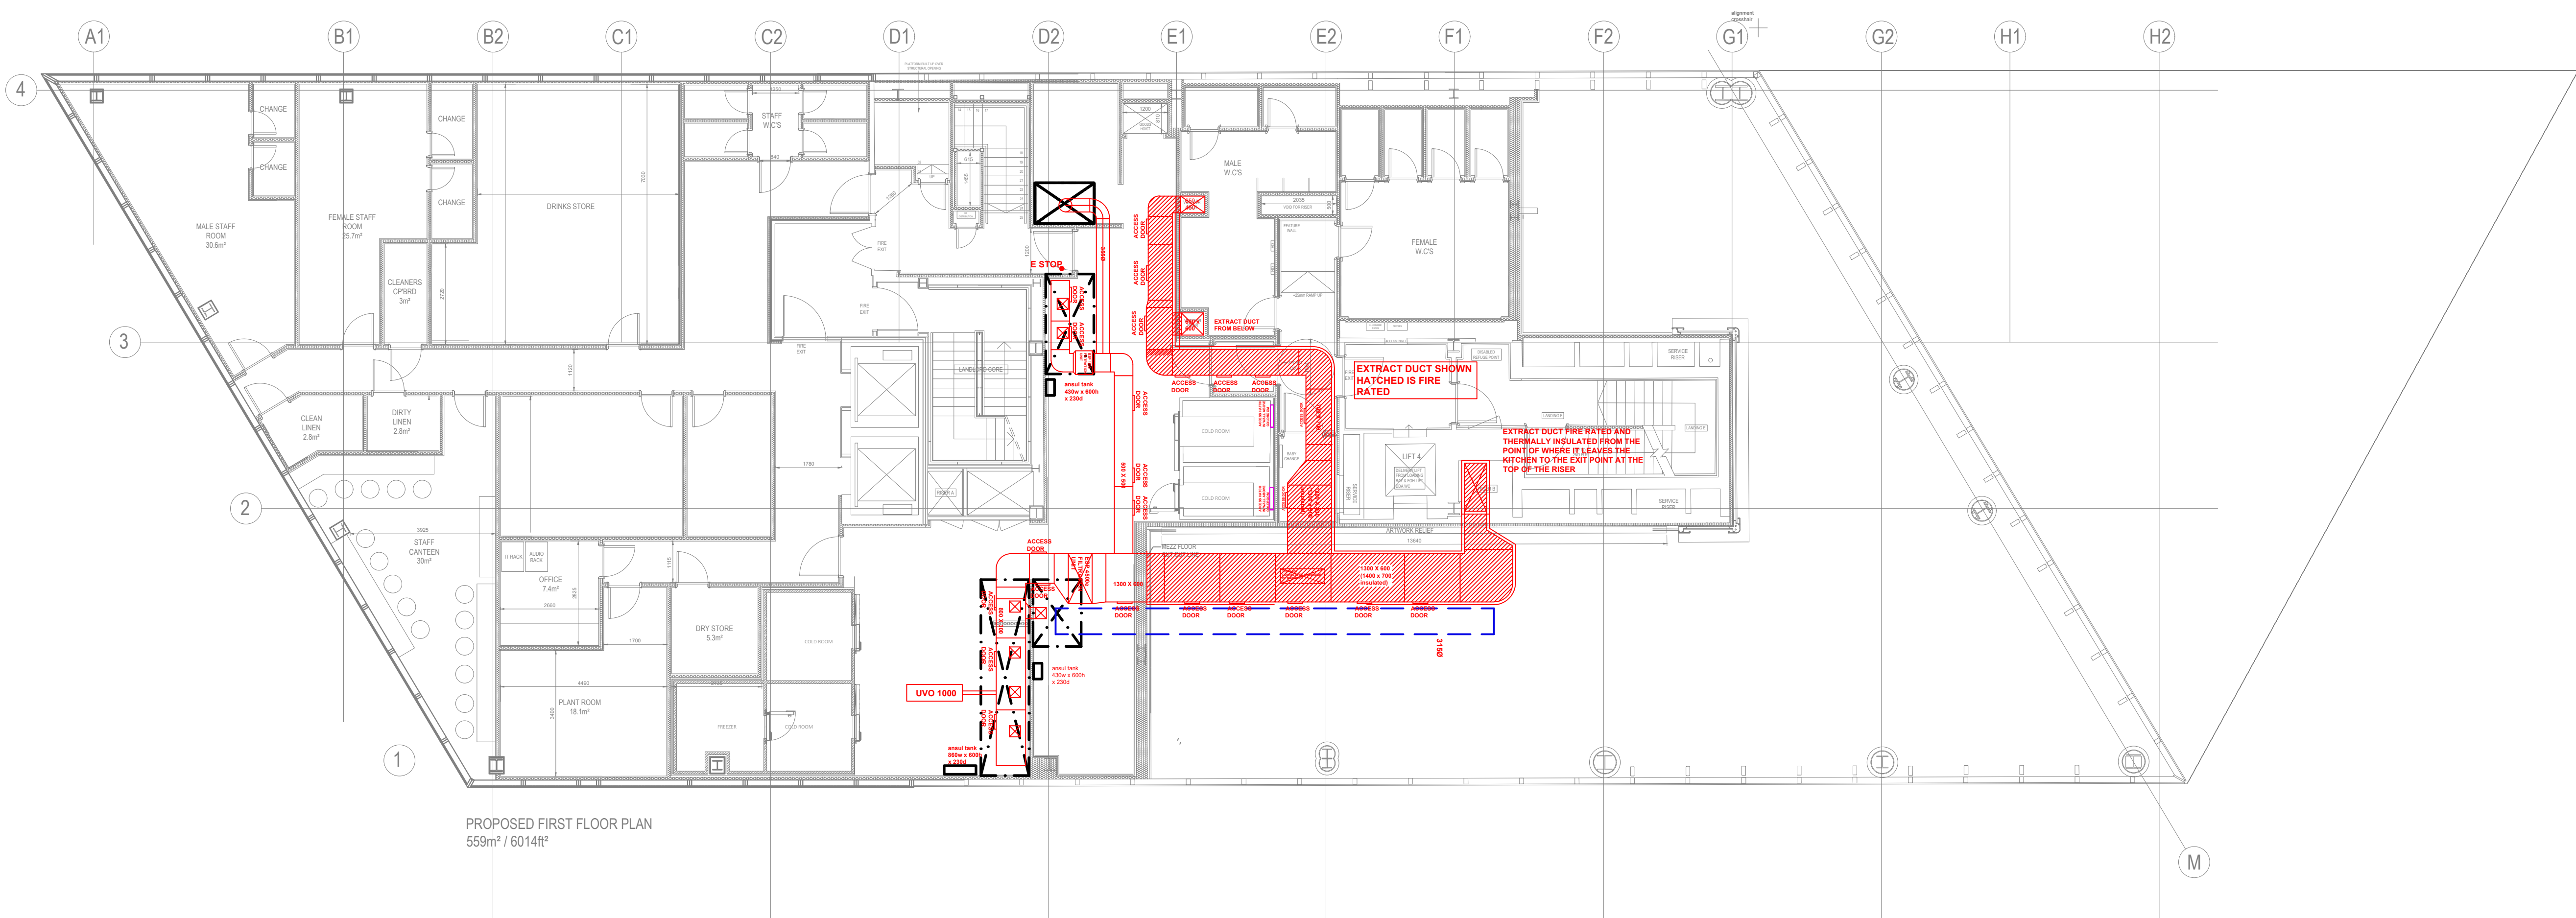


LEGEND	
	Supply Air Grill
	Extract Air Grill
	AC Cassette
	Indicative route of AC pipework
	Wall Mounted AC unit
	AC Condensor
	Extract Air Duct
	Supply Air Duct
	WC/Toilet Extract Vent
	WC/Toilet Extract Duct
	Volume Control Damper
	Fire Damper
	Non Return Damper
	Over Door Heater
	UVO Odour Control Unit
	Kitchen Extract Fan
	Kitchen Supply Fan
	General Supply Fan
	Back Of House Extract Fan
	Toilet/WC Extract Fan
	E-STOP

-	-	-
Rev	Date	Description
 REFRIGERATION-AIR CONDITIONING-VENTILATION 17 Calverton Business Park Hoyle Road Calverton Nottingham NG14 6QL tel: 0115 965 5042 web: fwpuk.com		
Drawn:	Checked:	Date:
-	-	--/--/----
Issue:		
Provisional ☐ Approved ☐ As Built ☒ Current ☐		
Site Address: Sexy Fish Manchester		
Drawing Title: First Floor Ventilation		
Drawing Number: 21368/011	Rev: AB	Paper size: A1 Scale: 1:100

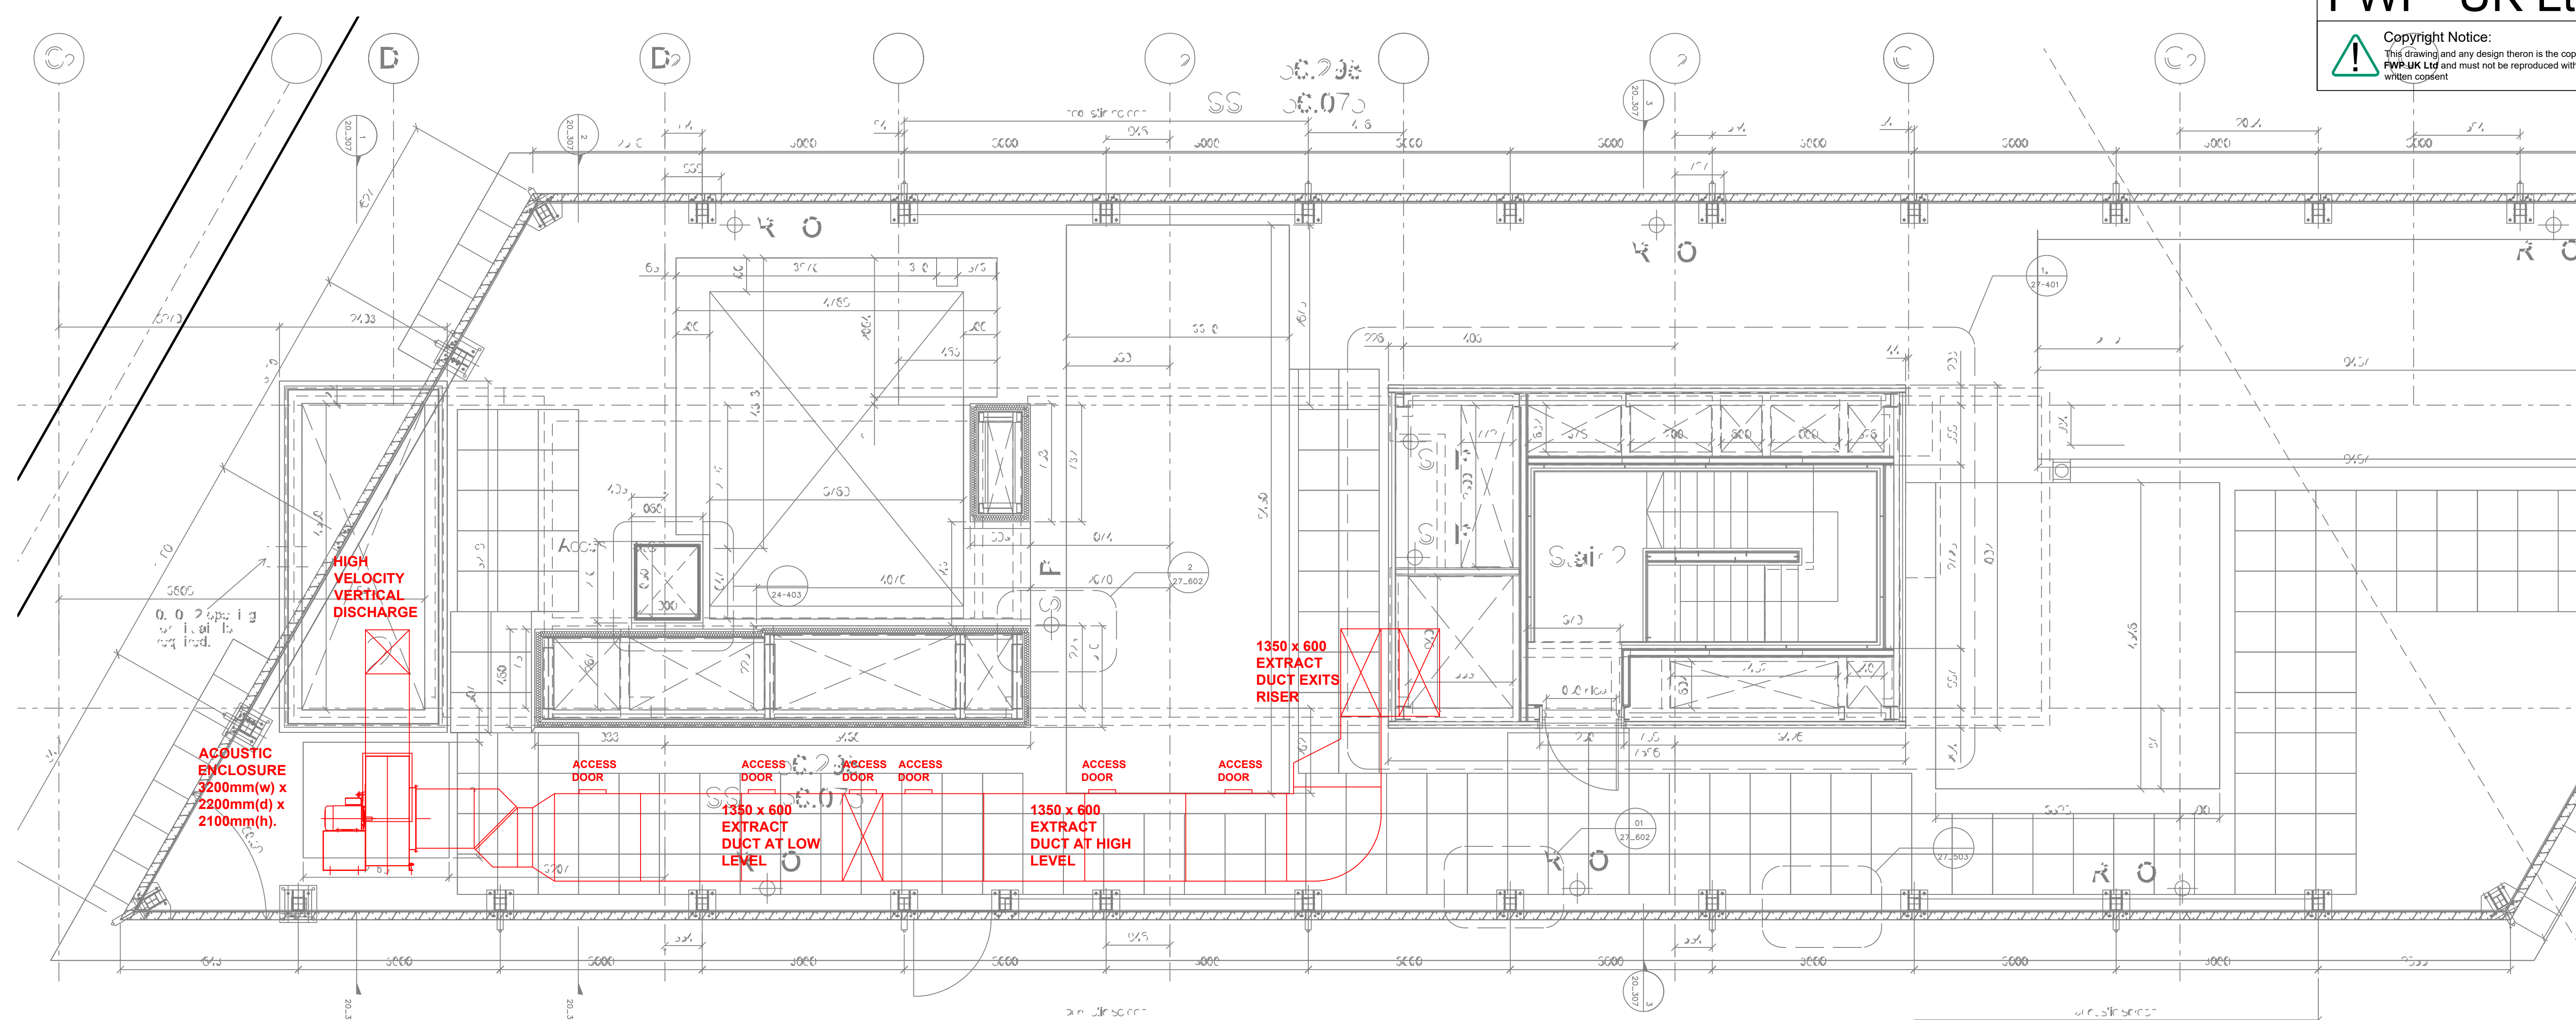

Attenuator	Overall dims (excl. flanges)	Insertion loss (dB) in 1/1 octave band centre frequencies (Hz)								Pressure drop (Pa)
		63	125	250	500	1k	2k	4k	8k	
Room-side	1300(w) x 1300(d) x 750(l)	4	7	12	18	25	20	16	11	50 (@ 8m³/s)
Atm-side	1300(w) x 1300(d) x 750(l)	4	7	12	18	25	20	16	11	50 (@ 8m³/s)

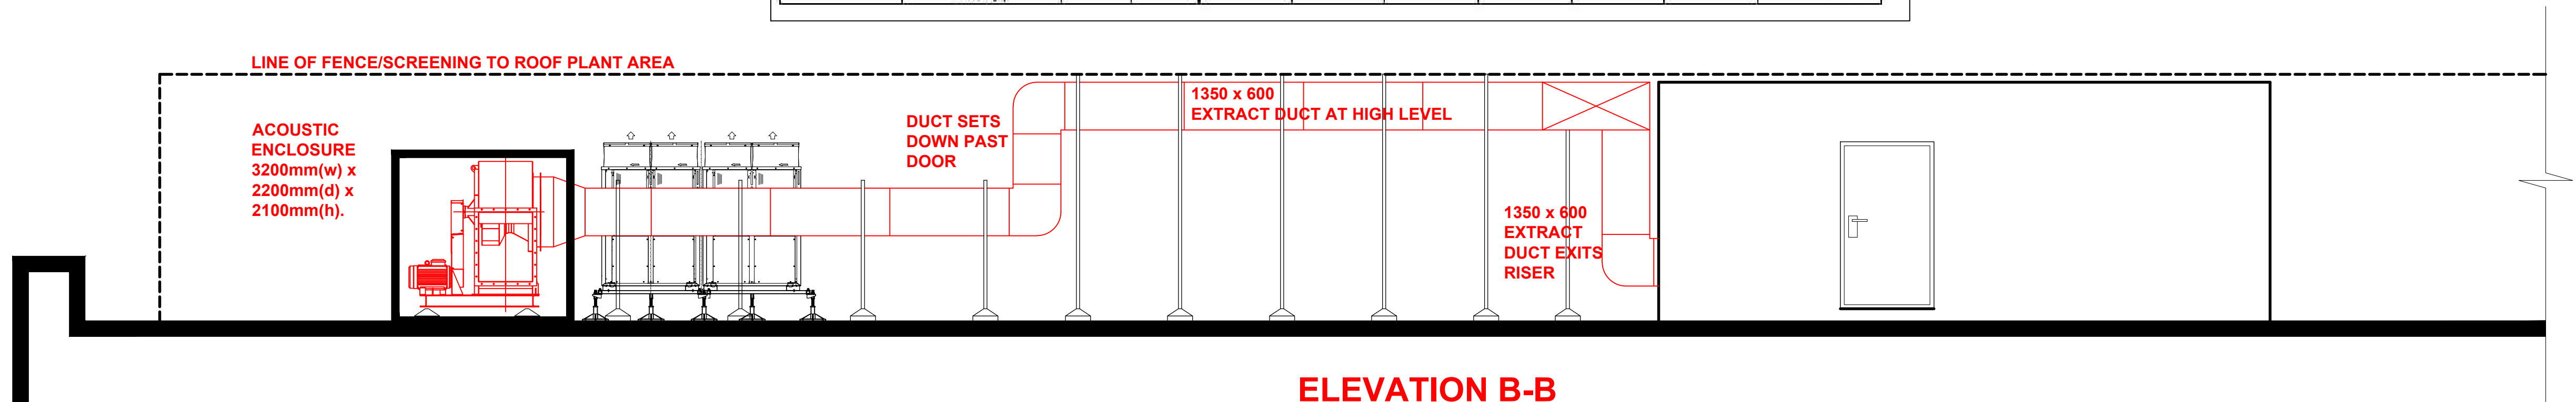

ELEVATION B-B

Rev	Date	Description

FWP
UK LTD

REFRIGERATION-AIR CONDITIONING-VENTILATION
17 Calverton Business Park
Hoyle Road
Calverton
Nottingham NG14 6QL
tel: 0115 965 5042
web: fwpuk.com

Drawn: -

Checked: -

Date: --/--/----

Issue:

Provisional ☐ Approved ☐ As Built ☐ Current ☐

Site Address:
Sexy Fish
Manchester

Drawing Title:
Roof Plan

Drawing Number:
21368/021

Rev:
AB

Paper size:
A1

Scale:
1:50