


SECURITY

- CCTV CAMERA PTZ
- CCTV CAMERA FIX
- CCTV CAMERA IN A DOME PTZ
- CCTV CAMERA IN A DOME FIX
- PRESENCE INFRARED DETECTOR CEILING MOUNTED. 360° COVERAGE
- PRESENCE INFRARED DETECTOR
- INTRUDER ALARM PANEL
- POWER SUPPLY UNIT
- ACCESS CONTROL SWIPE READER
- SECURE SIDE EMERGENCY RELEASE (GREEN BGU)
- MAGNETIC DOOR HOLDER
- PUSH BUTTON/ DOOR RELEASE BUTTON
- INTRUDER ALARM KEY PAD
- MONITORED DOOR CONTACT
- VIDEO ENTRY SYSTEM
- VIDEO ENTRY HANDSET
- VIDEO ENTRY SPEECH PANEL
- EXTERNAL BELL / BEACON UNIT
- EXTERNAL SOUNDER STROBE UNIT
- ACCESS CONTROL
- G2 GRADE 2 MONITORED
- G3 GRADE 3 MONITORED

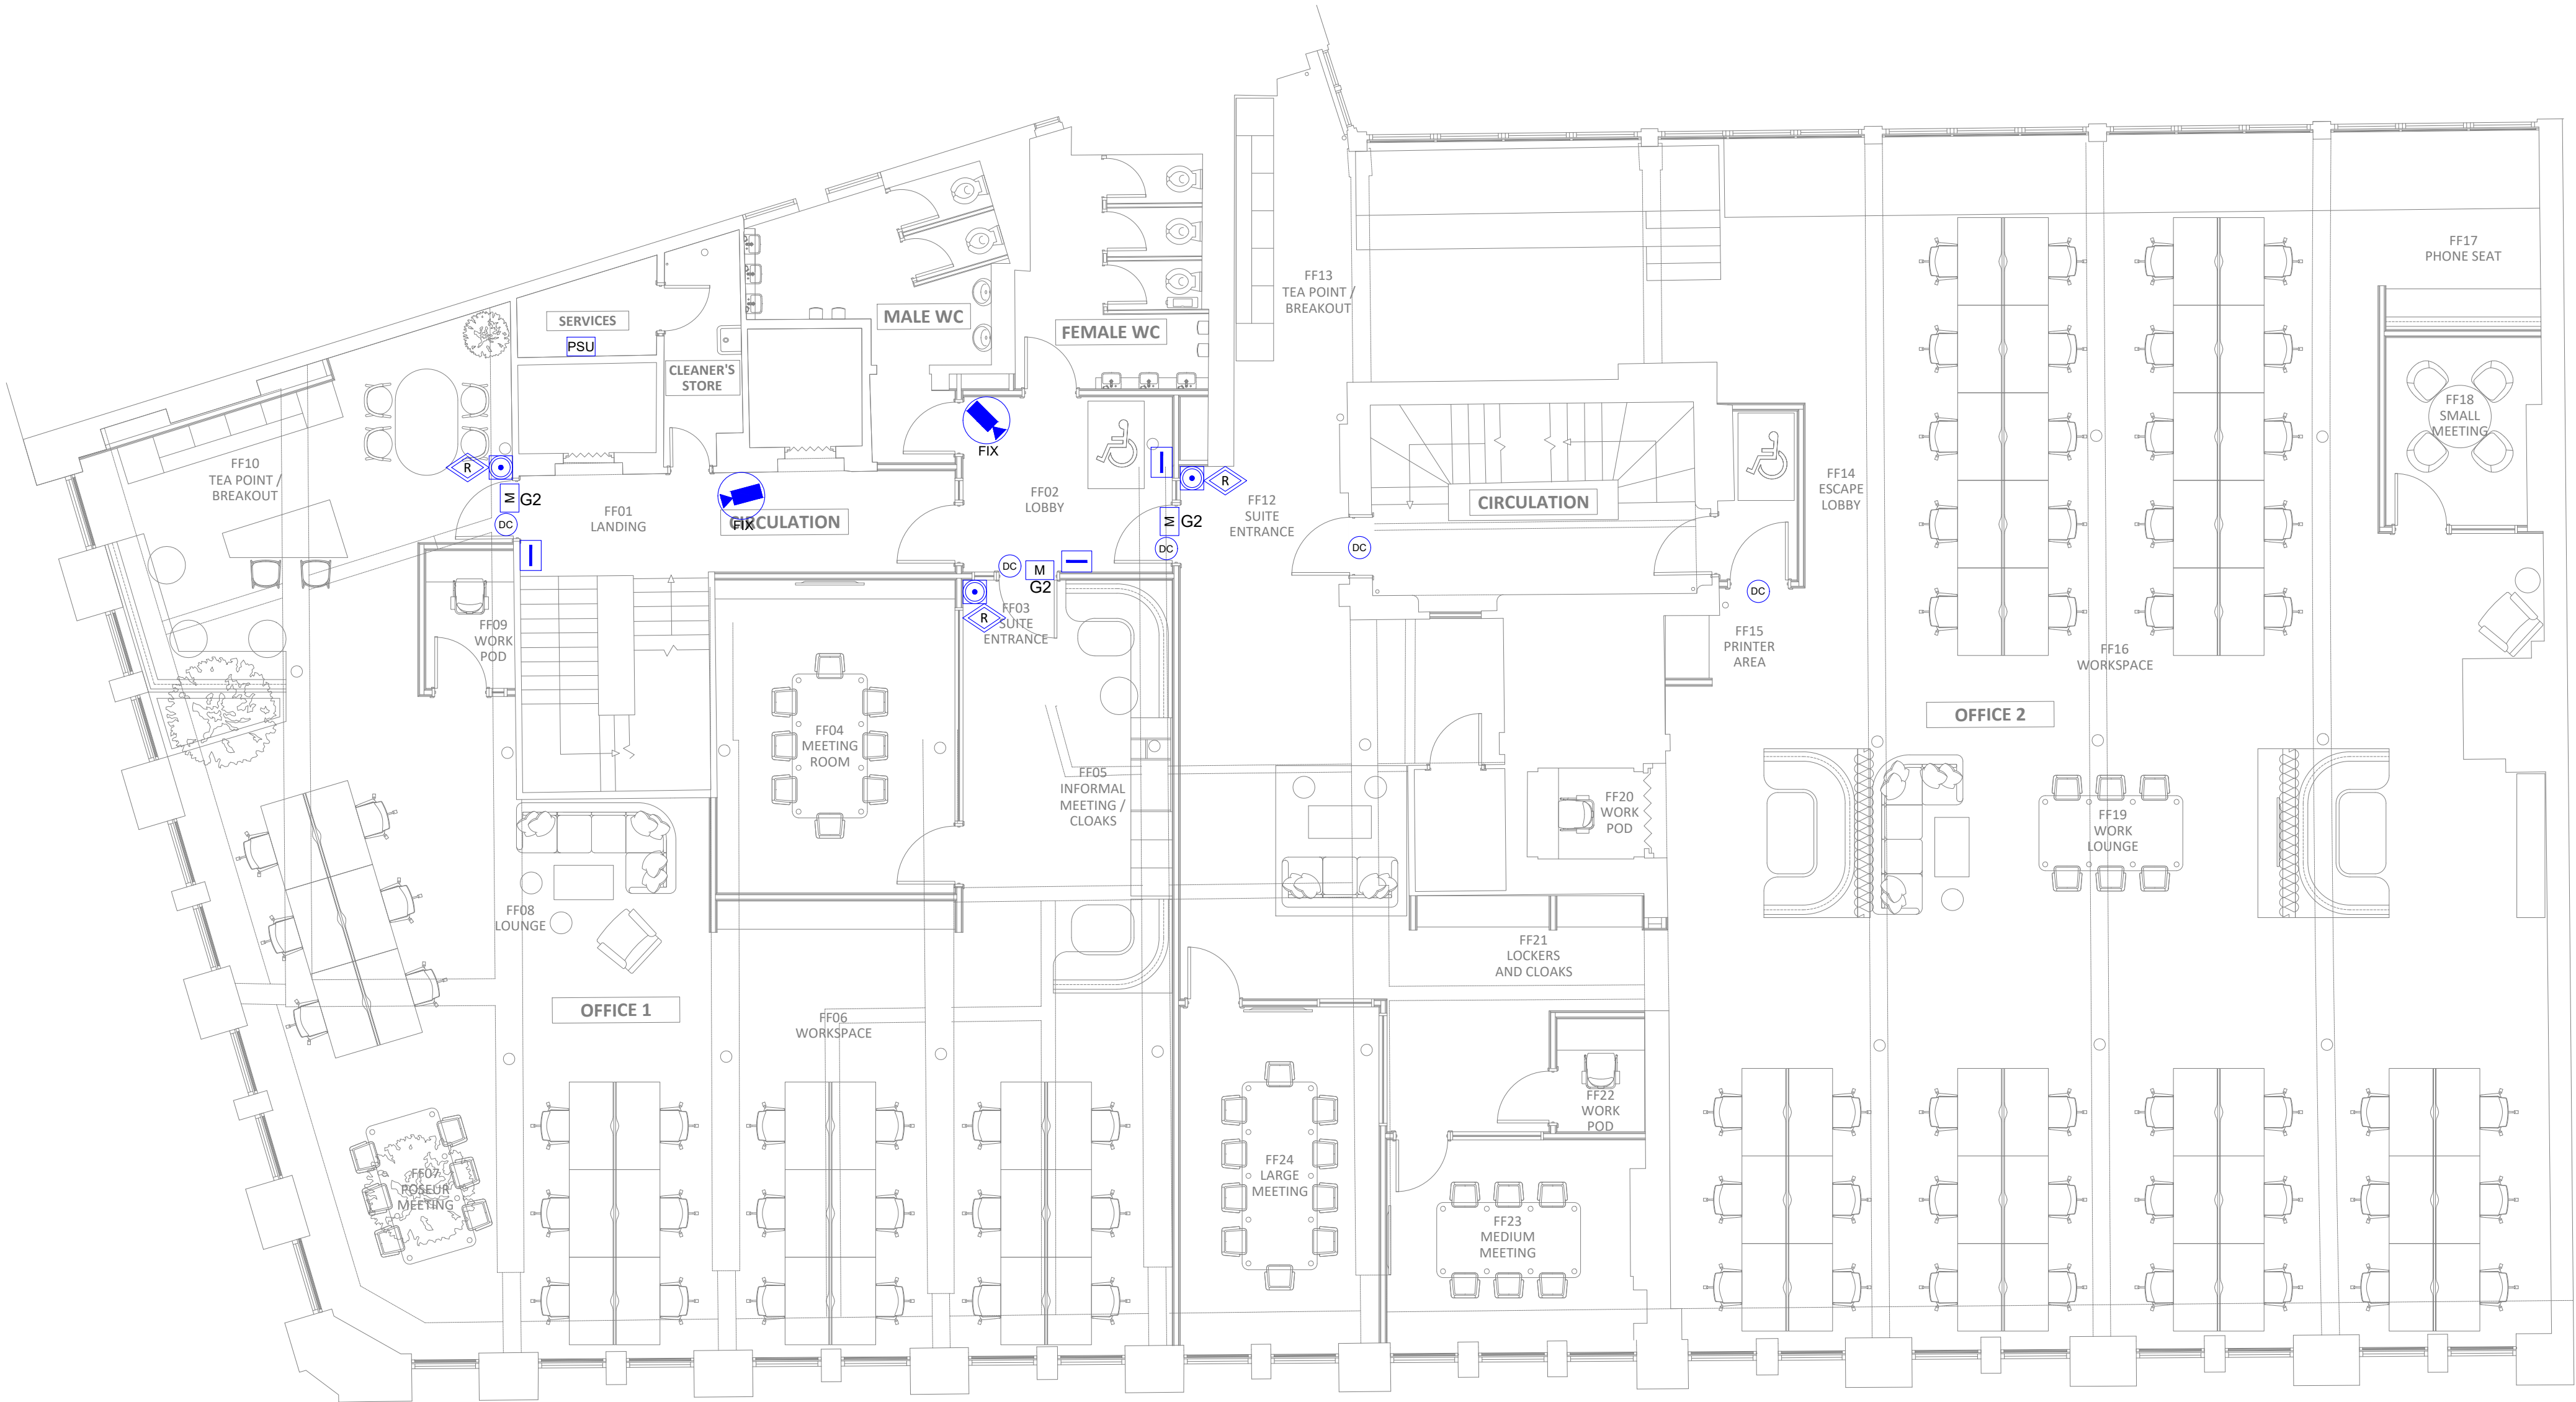

PROPOSED FIRST FLOOR

P1	ISSUE FOR PLANNING	LF	17.05.24
REV	DESCRIPTION	BY	DATE

KAIZEN

Consulting Engineers

www.kaizen-ce.com[e: info@kaizen-ce.com](mailto:info@kaizen-ce.com)

CLIENT

bruntwood

SciTech

ARCHITECT

A

X

I

PROJECT

117-119 PORTLAND STREET
MANCHESTER

DRAWING TITLE

ELECTRICAL SERVICES
FIRST FLOOR
SECURITY LAYOUT

CHECKED	DATE	DRAWN	SCALE
LF	FEB 24	MN	1:75@A1

STAGE 4

DRAWING NUMBER	STATUS	REV.
1168-KCE-ZZ-01-DR-E-6802	S4	P1