



Drawing Scale 1:1250 @ A3

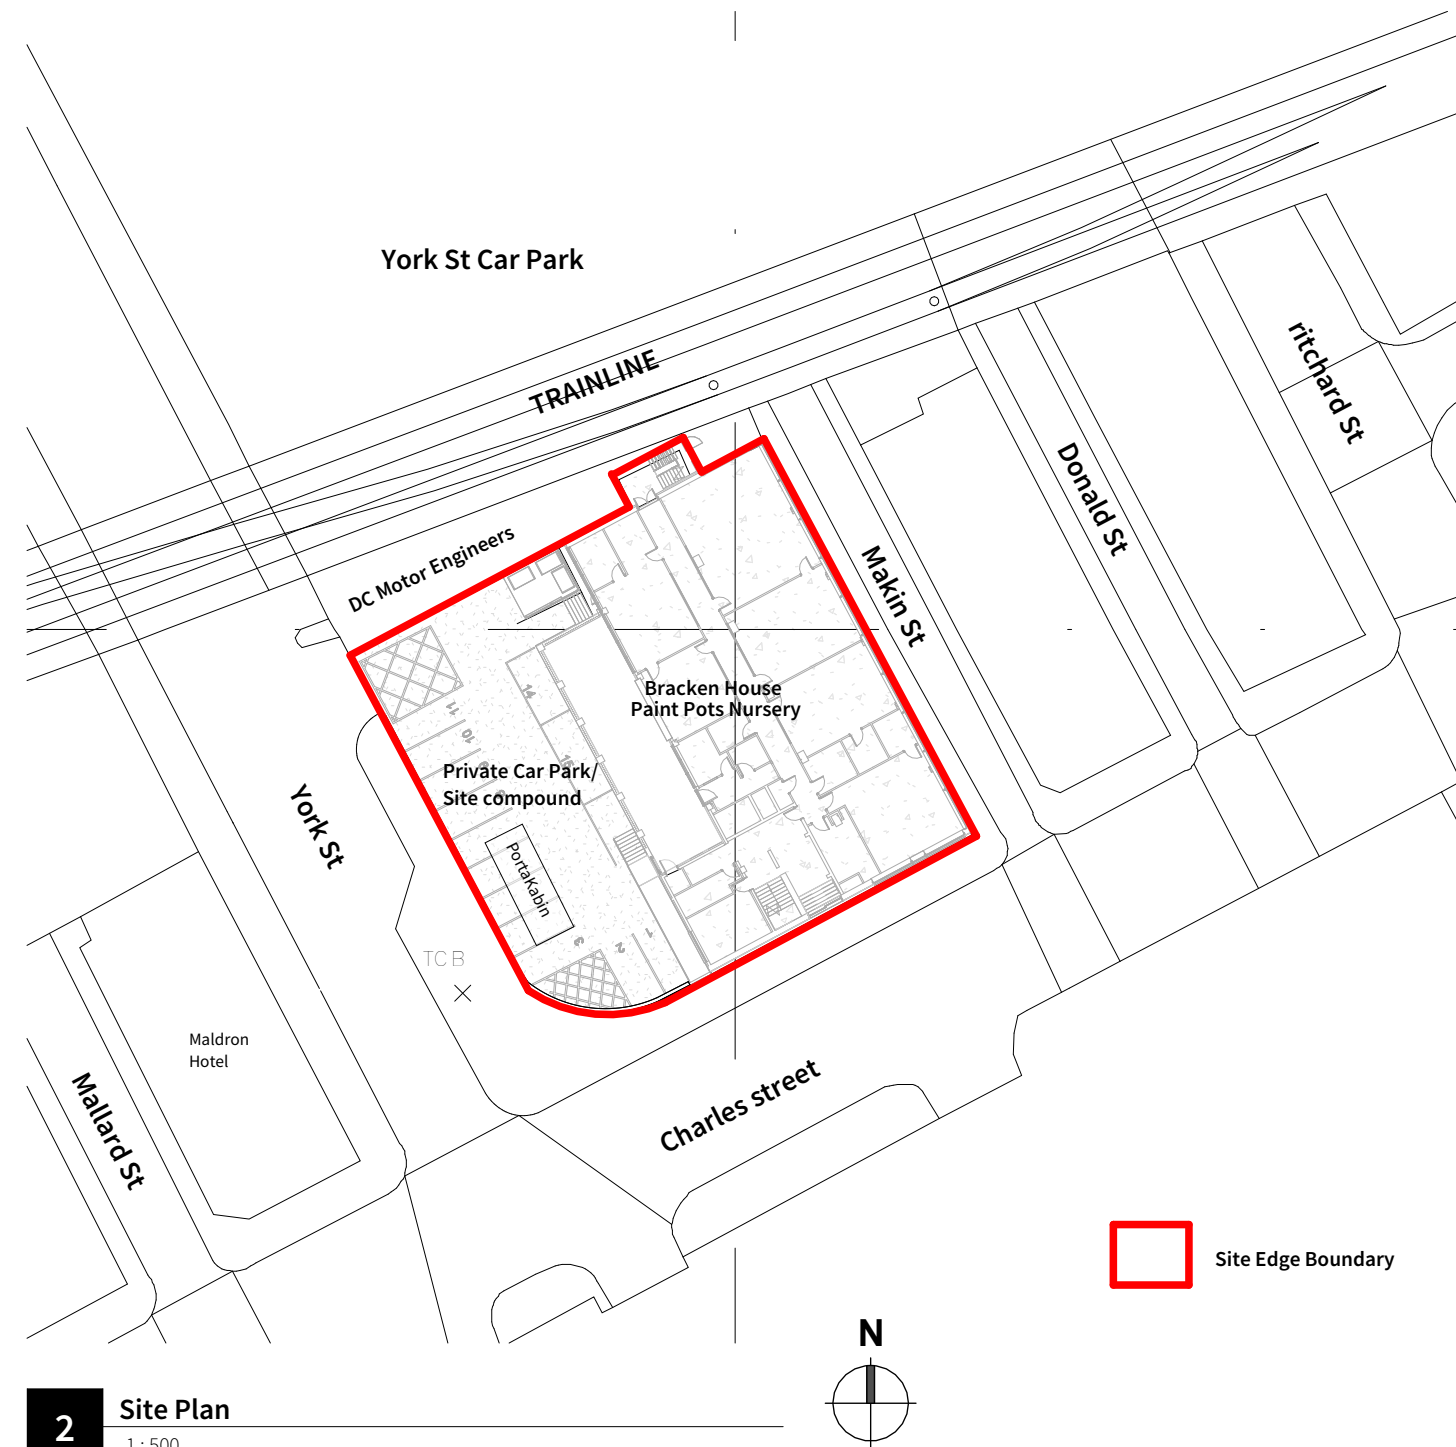

2 Site Plan
1 : 500

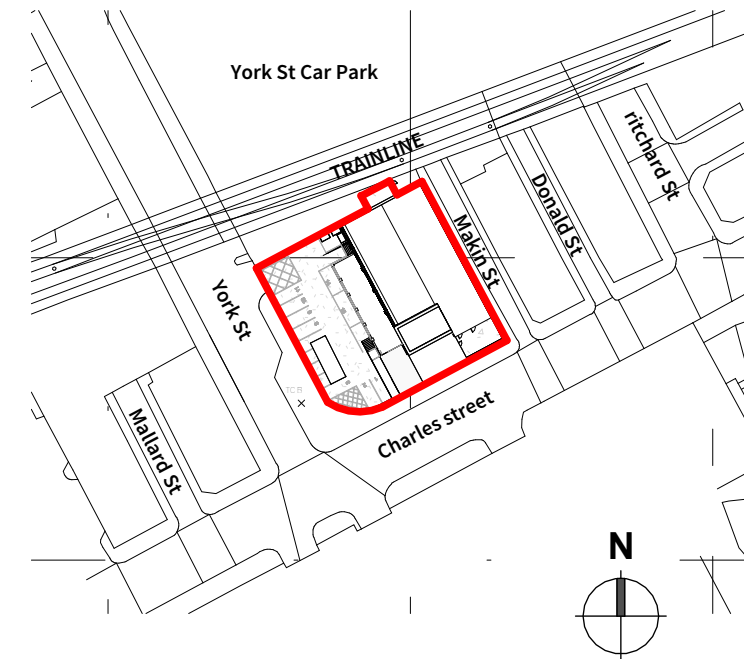

1 Location Plan..
1 : 1250

<div>Four Architects Limited (11613893)</div> <div>Note:</div> <div>This drawing is copyright.</div> <div>Do not scale dimensions from drawings.</div> <div>All dimensions must be checked on site by contractor or suitable qualified individual.</div> <div>Contractor to report any discrepancies, errors or omissions prior to commencing work.</div>	Project Title: BRACKEN HOUSE		Status: ISSUED FOR PLANNING	
	Location: MANCHESTER		Scale: As indicated	Date: 12/05/2025
	Drawing title: Location Plan _ Nursery		Job Number: 19-016	<div>Drawing Number: FA-DR-08-209</div> <div>Revision: P1</div>

F

Four

Architects

113 Portland Street, Manchester, M1 6DW

Tel. 01614707969 Email. info@fourarchitects.co.uk