


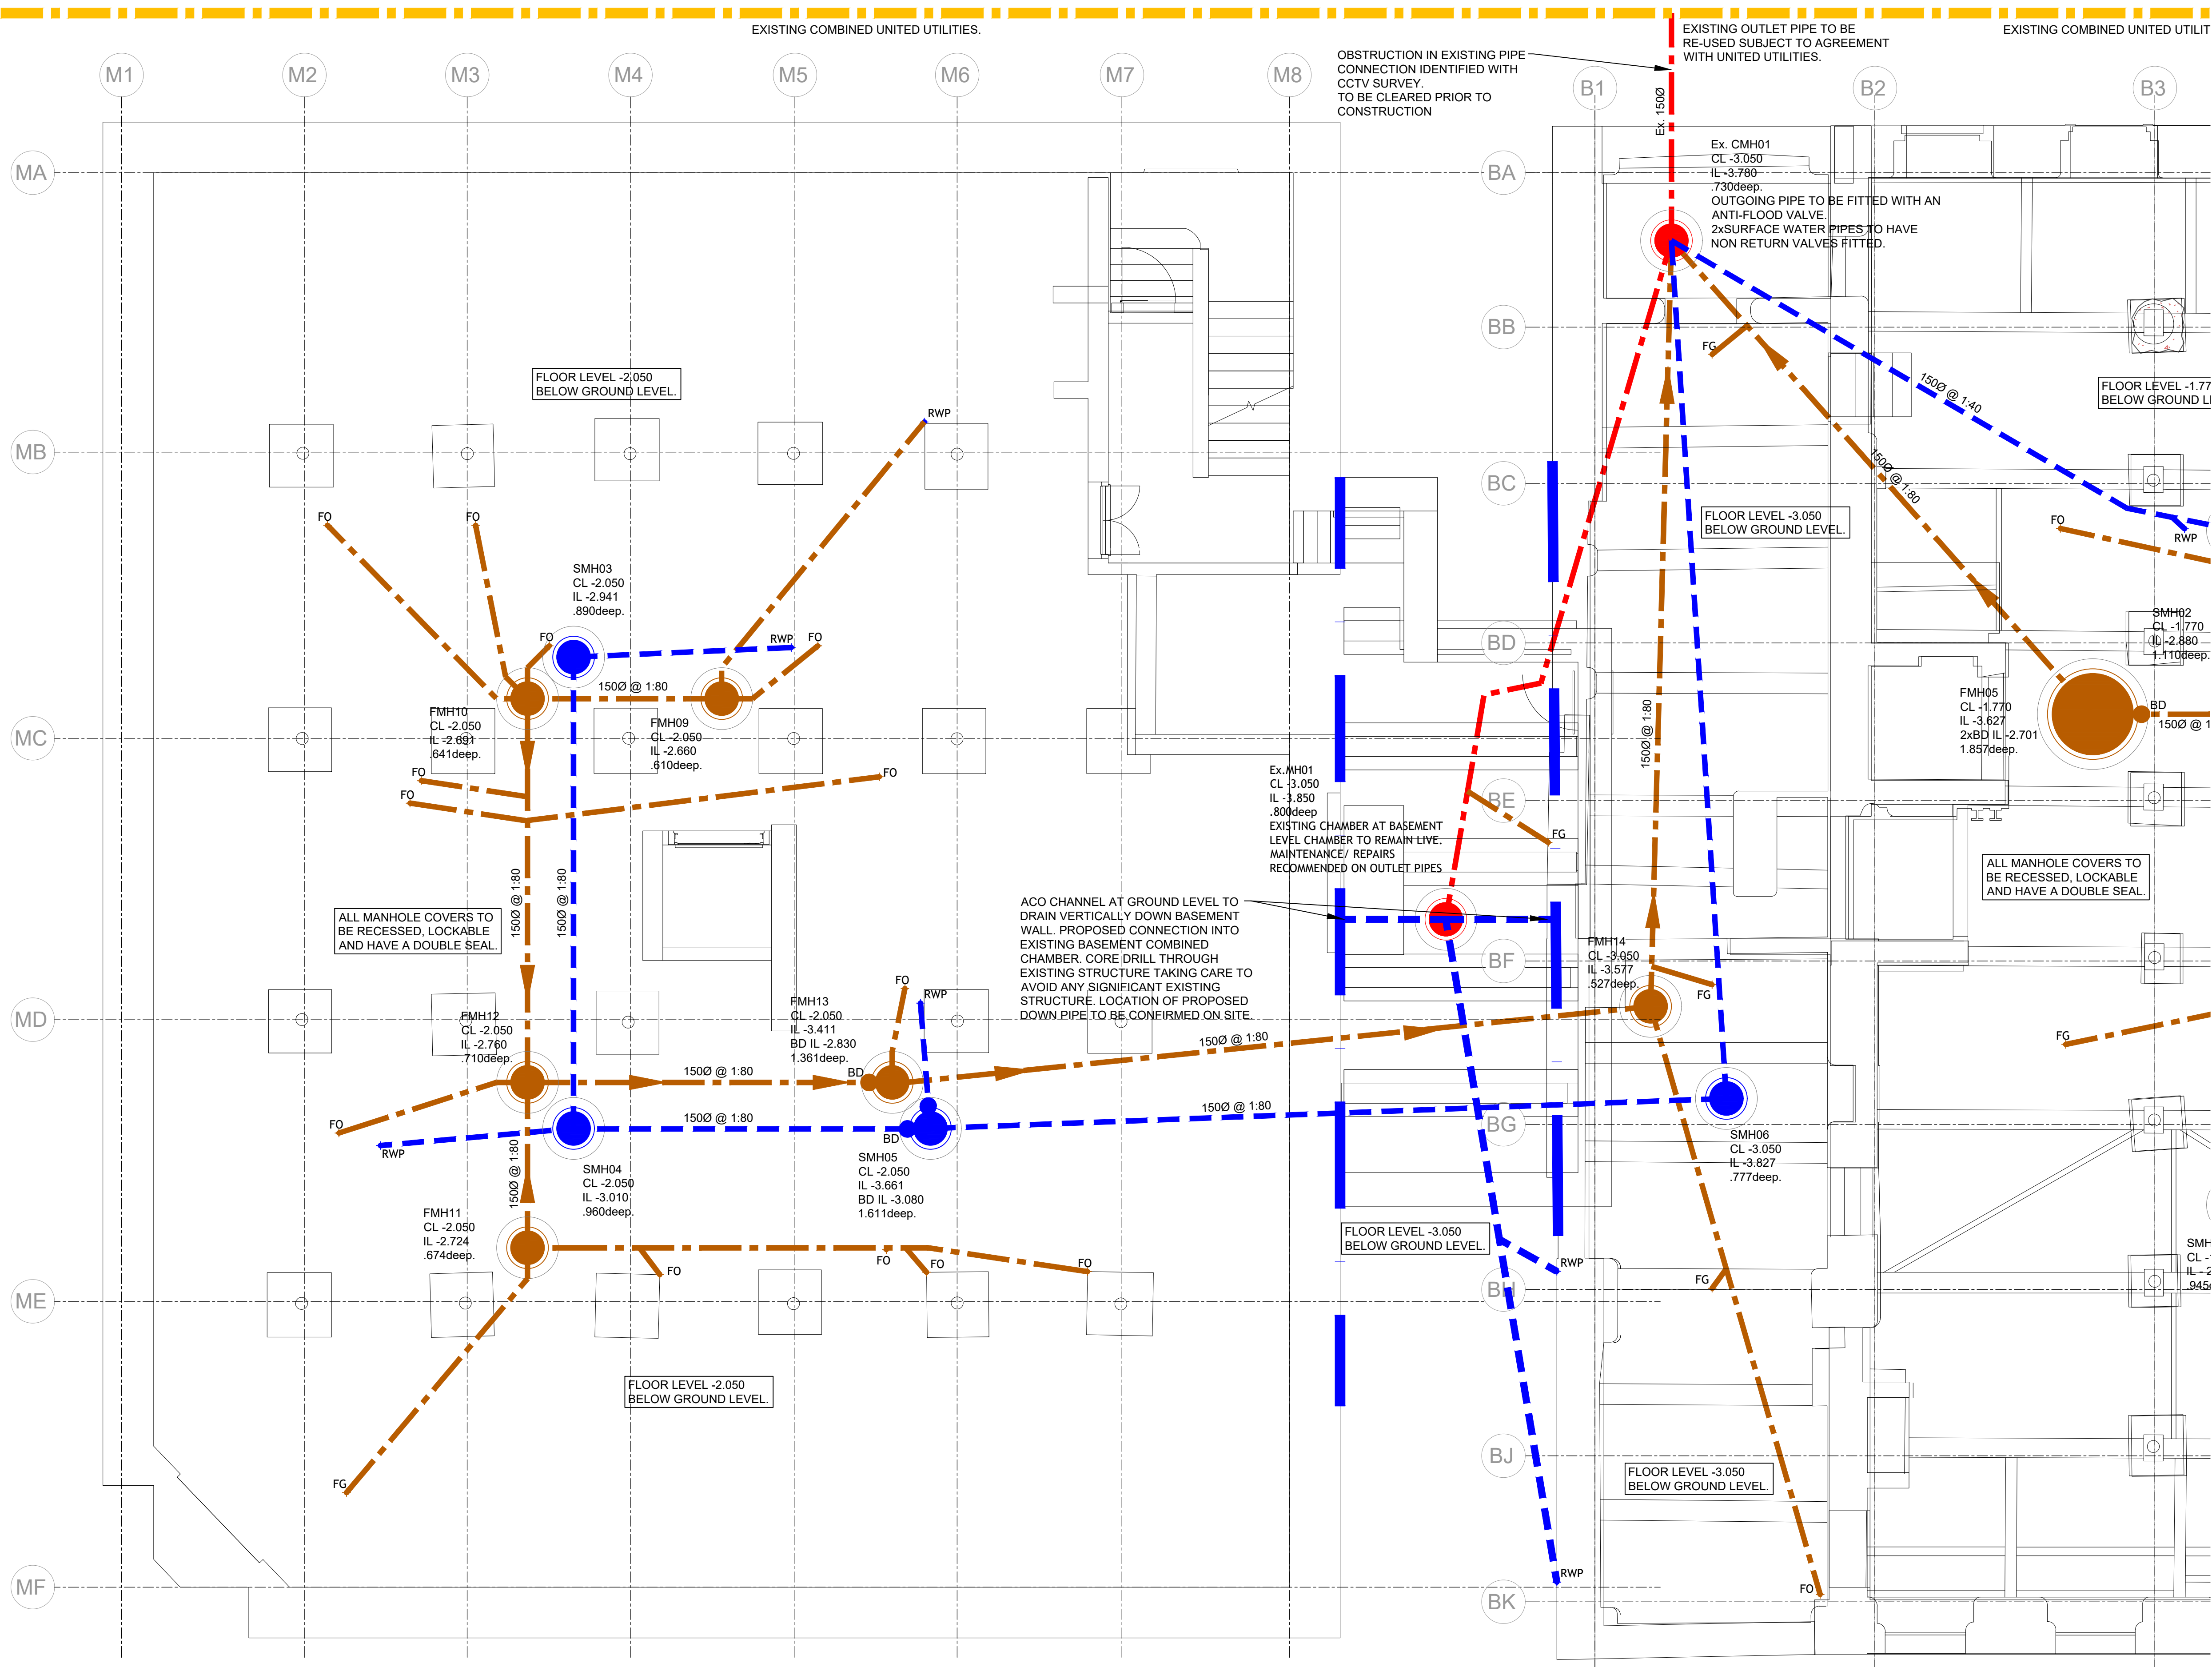

Notes:

1. THIS DRAWING IS THE COPYRIGHT OF TIER CONSULT LTD AND CANNOT BE REPRODUCED IN ANY FORM WITHOUT WRITTEN CONSENT FROM THE COMPANY.
2. THIS DRAWING IS TO BE READ IN CONJUNCTION WITH ALL OTHER RELEVANT ARCHITECTS, ENGINEERS AND SPECIALISTS DRAWINGS TOGETHER WITH THE APPROPRIATE SPECIFICATION.
3. ALL DIMENSIONS ARE IN MILLIMETRES UNO, FOR THE PURPOSES OF CONSTRUCTION THIS DRAWING MUST NOT BE SCALED AND ONLY WRITTEN DIMENSIONS USED. IT IS THE CONTRACTORS RESPONSIBILITY TO CHECK DIMENSIONS ON SITE PRIOR TO CONSTRUCTION AND ANY DISCREPANCIES TO BE BROUGHT TO THE IMMEDIATE ATTENTION TO THE ENGINEER IN WRITING.
4. ALL LEVELS ARE IN METRES UNO & TO OS DATUM.

1. THE WORKS SHALL BE IN ACCORDANCE WITH THE NATIONAL BUILDING SPECIFICATION.
2. THE LOCATION LINE & LEVEL OF ALL KNOWN EXISTING DRAINAGE PIPEWORK INDICATED ON THE DRAWINGS ARE APPROXIMATE AND FOR GUIDANCE PURPOSES ONLY.
3. CONNECTION TO THE EXISTING PUBLIC SEWERS WILL BE SUBJECT TO THE RELEVANT APPROVALS FROM THE STATUTORY UNDERTAKER.
4. UPON COMPLETION OF THE WORKS THE CONTRACTOR SHALL PROVIDE AS BUILT SETTING OUT CO-ORDINATE AND LEVEL INFORMATION ALONG WITH A FULL CCTV REPORT AND LOGS.
5. POLYPROPYLENE INSPECTION CHAMBERS OF 450mm x 1.2m DEEP TO BE FITTED WITH A REDUCED ACCESS FITTING.
6. SVP CONNECTIONS TO BE 100mm DIA UNO.
7. ALL FO AND RWP LOCATIONS TO BE TO BE COMPLETE WITH A LOW LEVEL ACCESS PLATE FOR RODDING.

	Ex. FOUL PUBLIC SEWER.
	Ex. FOUL MANHOLE.
	PROPOSED SURFACE WATER DRAIN. (TYPICALLY 1000' FROM RWP AND 1500' FROM RG/SU UNO)
	PROPOSED SURFACE WATER INSPECTION CHAMBER / MANHOLE.
	PROPOSED LINEAR DRAINAGE CHANNEL. RWP
	PROPOSED RAINWATER PIPE.
	PROPOSED FOUL DRAIN (1000 UNO).
	PROPOSED FOUL INSPECTION CHAMBER / MANHOLE.
	FO
	FG
	BD
	PROPOSED FOUL OUTLET.
	PROPOSED FOUL GULLY OUTLET.
	PROPOSED BACK DROP CONNECTION.

MAIN DRAINAGE RUNS BASED ON DRG No's:
C-18281-HYD-XX-XX-DR-C-0500_C06_Proposed
Drainage Layout - Sheet 1
C-18281-HYD-XX-XX-DR-C-0502_C06_Proposed
Drainage Layout - Sheet 2

NOTE:
EXISTING SHALLOW SERVICES PRESENT UNDER
BUILDING AND EXTERNAL WORKS AREAS. M&E
ENGINEER TO CONFIRM LIVE STATUS OF SERVICES.
CONTRACTOR LIAISON WITH STATUTORY PROVIDERS
TO BE UNDERTAKEN TO UNDERSTAND REQUIREMENTS
FOR CONSTRUCTION AND TO ARRANGE PROTECTIONS /
DIVERSIONS.

NOTE:
TANKING PROPOSALS AND CONNECTIONS INTO
PROPOSED DRAINAGE TO BE CONFIRMED BY TANKING
DESIGNER.

SVPS AT BASEMENT LEVEL TO BE FITTED WITH
RODDABLE ACCESS VIA AIR ADMITTANCE VALVES
(AAVS). SVPS FROM UPPER FLOORS TO BE FITTED WITH
RODDABLE ACCESS PLATES TO MEP CONSULTANTS
DETAILS

1. THIS DRAWING TO BE READ IN CONJUNCTION WITH ALL OTHER RELEVANT ARCHITECT'S, ENGINEER'S AND SPECIALIST'S DRAWINGS TOGETHER WITH THE APPROPRIATE SPECIFICATION.
2. IT IS THE CONTRACTOR'S RESPONSIBILITY TO CHECK ALL DIMENSIONS ON SITE. DIMENSIONS MUST NOT BE SCALED FROM THIS DRAWING. ANY DISCREPANCIES TO BE BROUGHT TO THE IMMEDIATE ATTENTION OF THE ARCHITECT IN WRITING.
3. ALL DIMENSIONS ARE IN MILLIMETRES, UNLESS NOTED OTHERWISE.
4. ALL LEVELS ARE IN METRES, UNLESS NOTED OTHERWISE.

Project Title	Piccadilly Warehouse Bloom Street
Drawing Title	Proposed Basement Drainage Layout. Sheet 2.
Issue Status:	Preliminary

ORIGINATOR	ZONE	LEVEL	TYPE	ROLE	NUMBER	REV
TCM	BS	B1	DR	C	0801	P1