


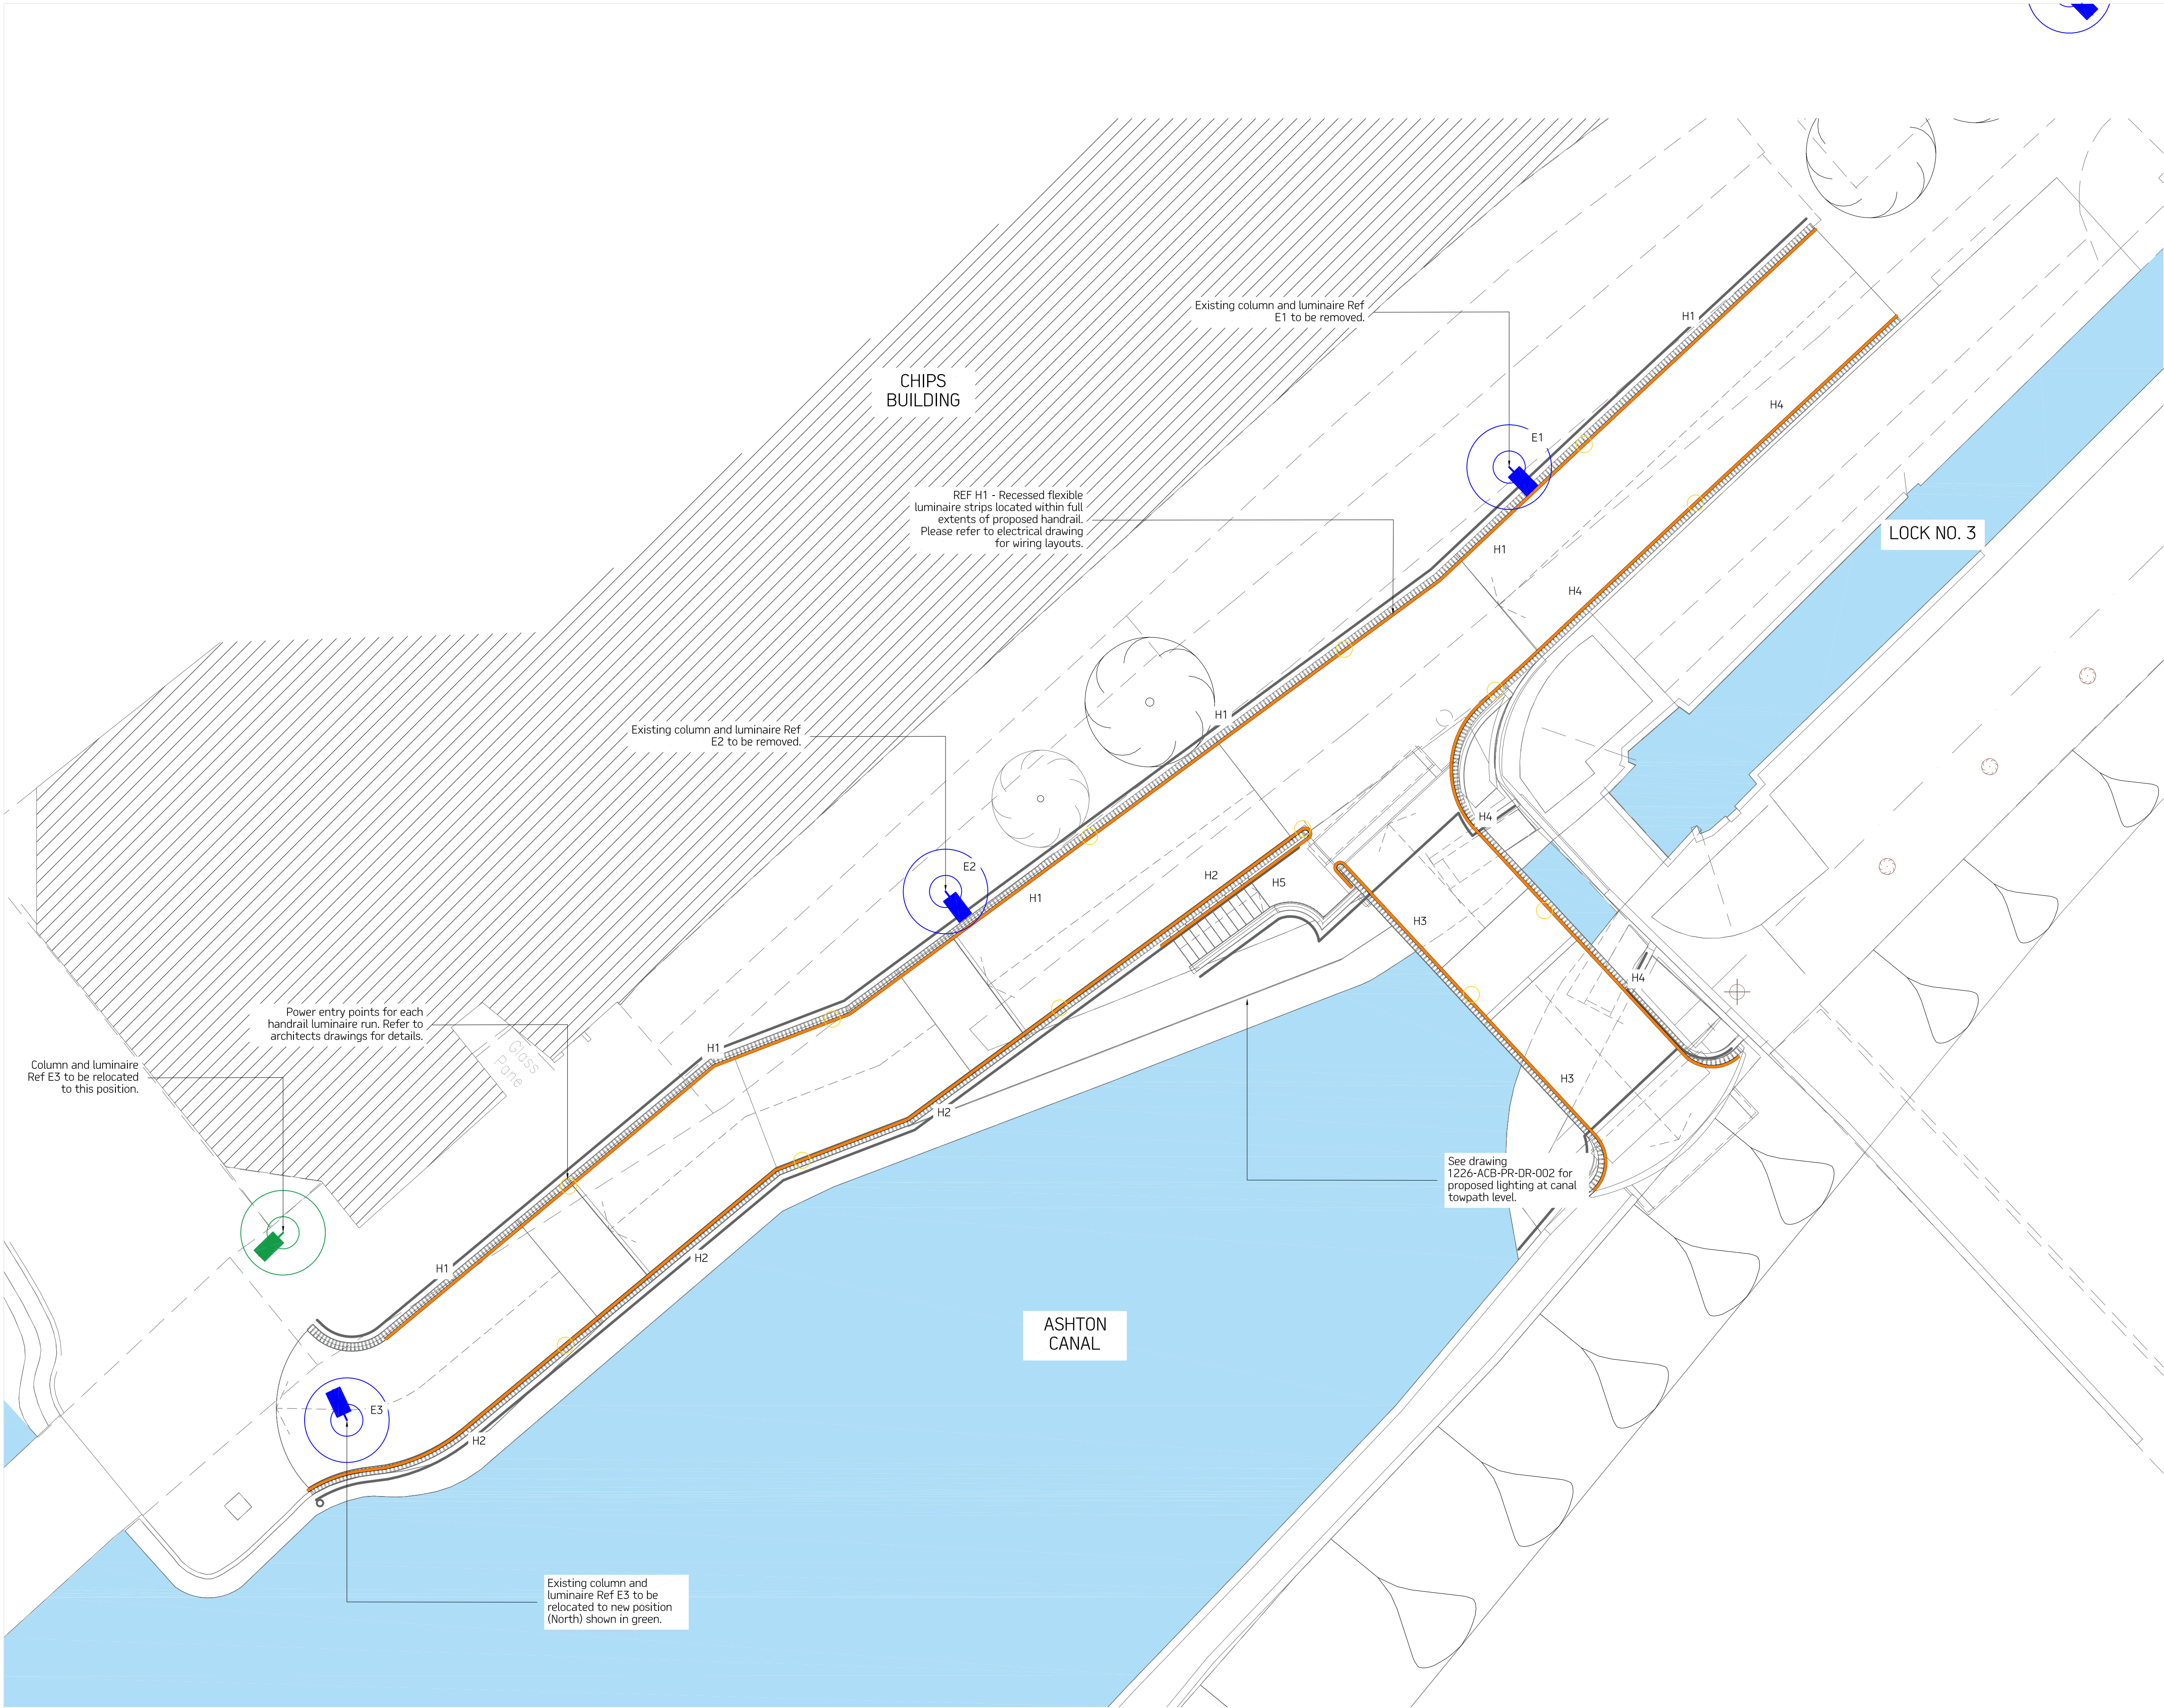

STUDIO DEKKA LIMITED SHALL HAVE NO RESPONSIBILITY FOR ANY USE MADE OF THIS DOCUMENT OTHER THAN FOR THAT WHICH IT WAS PREPARED AND ISSUED.

ALL DIMENSIONS SHOULD BE CHECKED ON SITE.
DO NOT SCALE FROM THIS DRAWING.

ANY DRAWING ERRORS OR DIVERGENCES SHOULD BE BROUGHT TO THE ATTENTION OF STUDIO DEKKA LIMITED AT THE ADDRESS BELOW.

NOTES

TO BE READ IN CONJUNCTION WITH:
1226-ACB-PR-SH-001 - Proposed Luminaire Schedule

Please refer to:

- the architects drawings for all design details.
- the electrical engineers drawings for all wiring routes, cable specifications and feeder pillar details.

Stage 4 Issue

JHCS21/10/22

REVISION / DESCRIPTION	DRAWN	CHECKED	DATE

STUDIO DEKKA

Independent Lighting Design Consultants

30 Aldreth Grove
York
YO23 1LB
01904 341361
studio@studiodekka.com
www.studiodekka.com

PROJECT TITLE

Islington Cycle Bridge, Lock No.3
Ashton Canal, Manchester

CLIENT

Hawkins Brown for
Manchester City Council

DRAWING TITLE

Proposed Lighting Layout
Bridge & Ramp Level

SCALE

1:100 @ A1

DATE

21/10/2022

DRAWING NO.

1226-ACB-PR-DR-001

REVISIONS

-