

 
LEGEND

— SUPPLY AIR DUCT


— EXTRACT AIR DUCT

— FRESH AIR DUCT

— EXHAUST AIR DUCT

 SUPPLY GRILLE

 
EXTRACT GRILLE / VALVE



ATTENUATOR

 FLEXIBLE CONNECTION

VOLUME CONTROL DAMPER

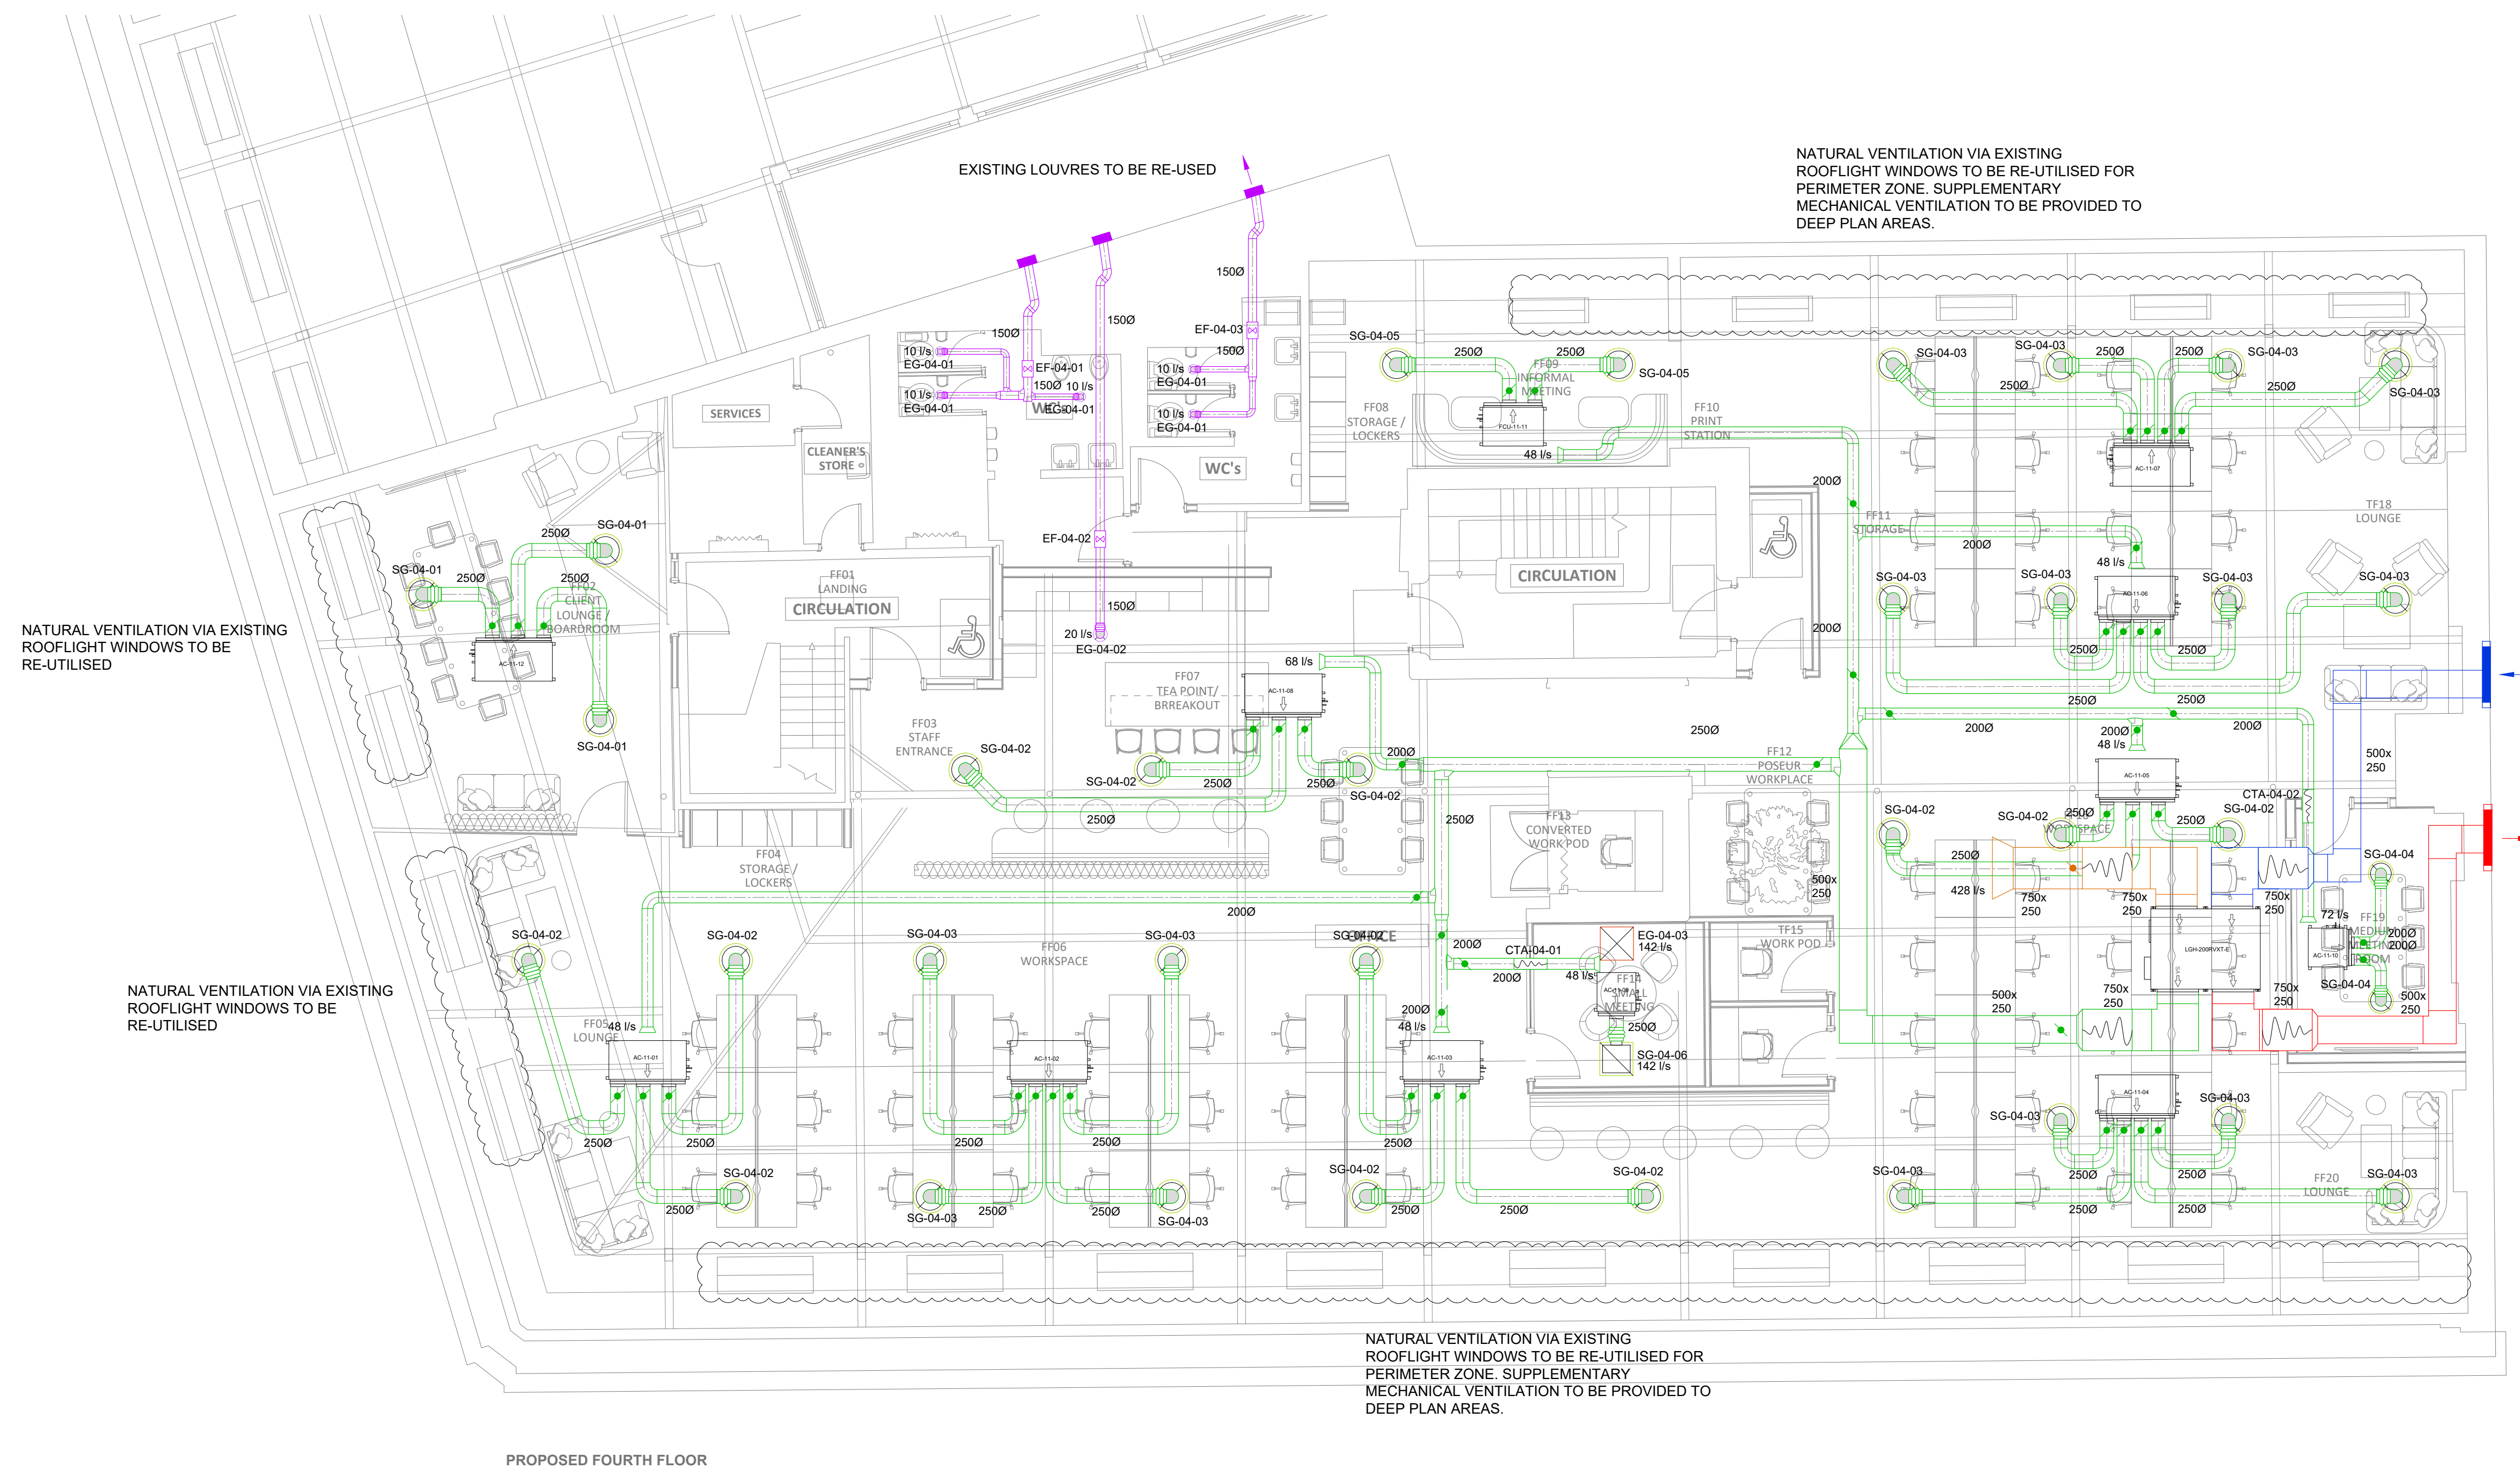

P1	ISSUE FOR PLANNING	SR	17.05.24
REV	DESCRIPTION	BY	DATE



www.kaizen-ce.com e: info@kaizen-ce.com

CLIENT

bruntwood
SciTech

ARCHITECT



PROJECT
117-119 PORTLAND STREET
MANCHESTER

DRAWING TITLE

MECHANICAL SERVICES

FOURTH FLOOR

VENTILATION LAYOUT

CHECKED SR	DATE FEB 24	DRAWN MN	SCALE 1:75@A1
---------------	----------------	-------------	------------------

STAGE 4

DRAWING NUMBER	STATUS	REV.
1168-KCE-ZZ-04-DR-M-5705	S4	P1