


LEGEND

- SUPPLY AIR DUCT
- EXTRACT AIR DUCT
- FRESH AIR DUCT
- EXHAUST AIR DUCT
- SUPPLY GRILLE
- EXTRACT GRILLE / VALVE
- ATTENUATOR
- FLEXIBLE CONNECTION
- VOLUME CONTROL DAMPER

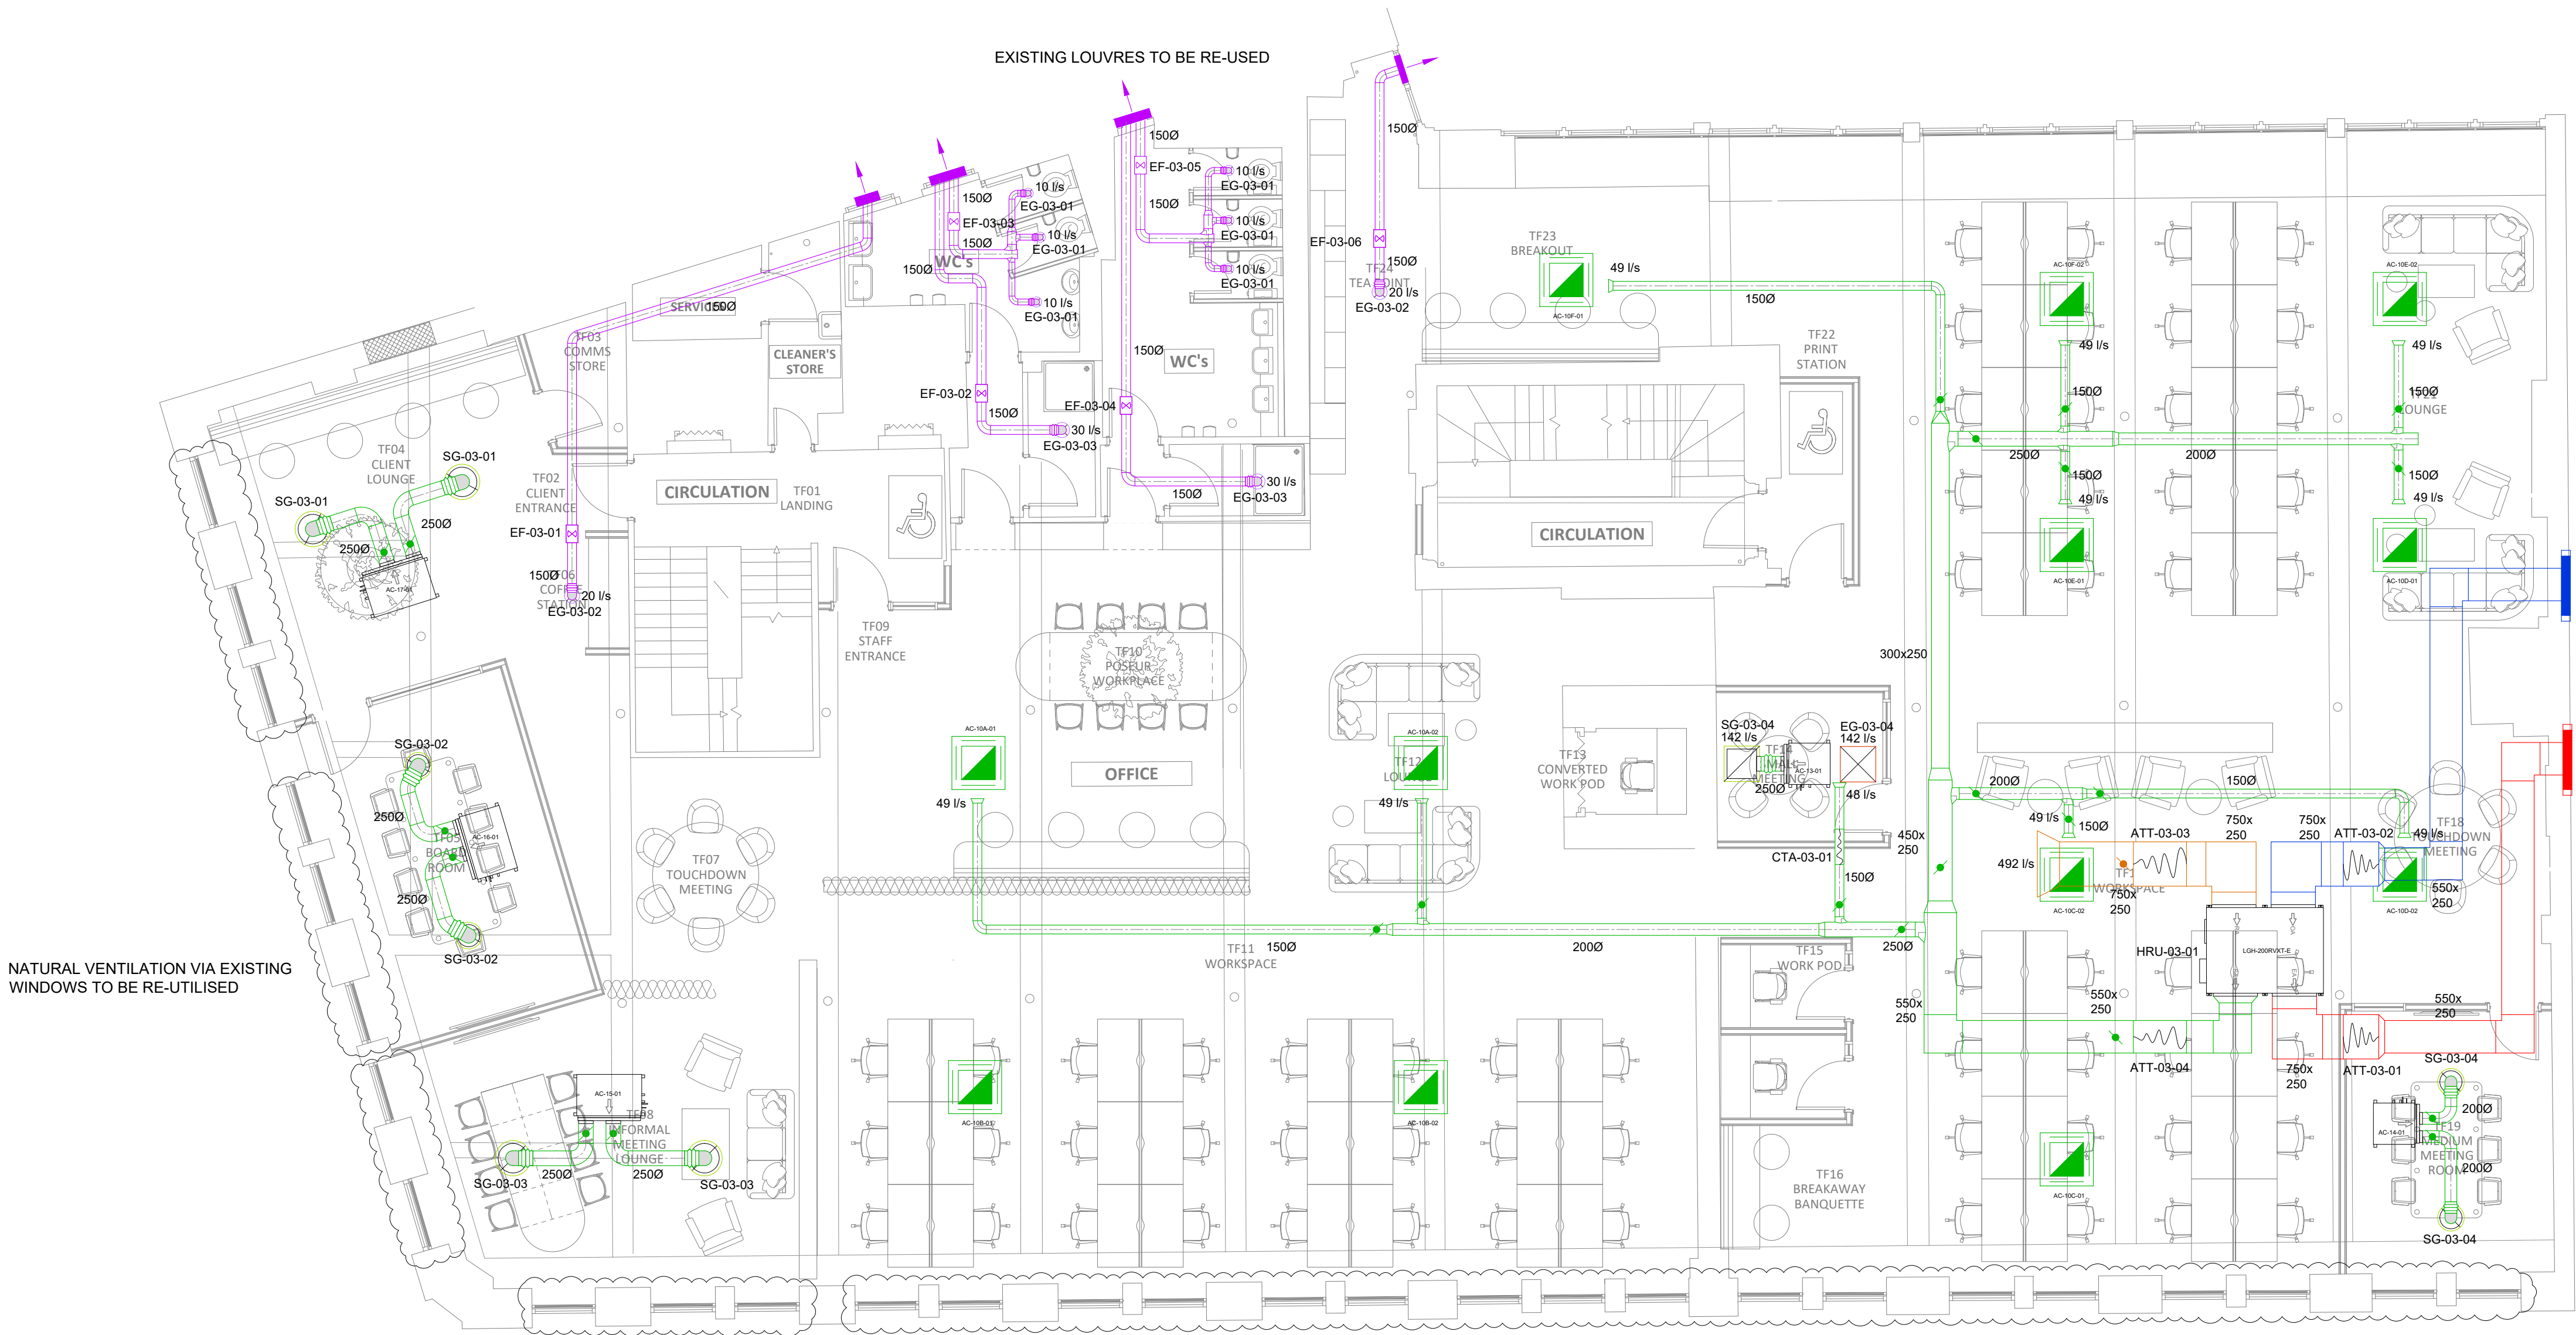


NATURAL VENTILATION VIA EXISTING WINDOWS TO BE RE-UTILISED

NATURAL VENTILATION VIA EXISTING WINDOWS TO BE RE-UTILISED FOR PERIMETER ZONE. SUPPLEMENTARY MECHANICAL VENTILATION TO BE PROVIDED TO DEEP PLAN AREAS.

NATURAL VENTILATION VIA EXISTING WINDOWS TO BE RE-UTILISED FOR PERIMETER ZONE. SUPPLEMENTARY MECHANICAL VENTILATION TO BE PROVIDED TO DEEP PLAN AREAS.

PROPOSED THIRD FLOOR

P1	ISSUE FOR PLANNING	SR	17.05.24
REV	DESCRIPTION	BY	DATE

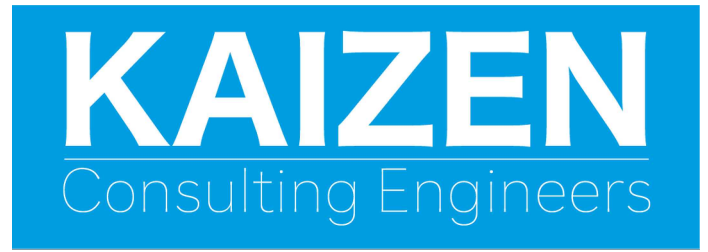

www.kaizen-ce.com e: info@kaizen-ce.com

CLIENT
bruntwood
SciTech

ARCHITECT
A X I

PROJECT
117-119 PORTLAND STREET
MANCHESTER

DRAWING TITLE
**MECHANICAL SERVICES
THIRD FLOOR
VENTILATION LAYOUT**

CHECKED	DATE	DRAWN	SCALE
SR	FEB 24	MN	1:75@A1

STAGE 4

DRAWING NUMBER	STATUS	REV.
1168-KCE-ZZ-03-DR-M-5704	S4	P1