


AS PROPOSED SITE PLAN

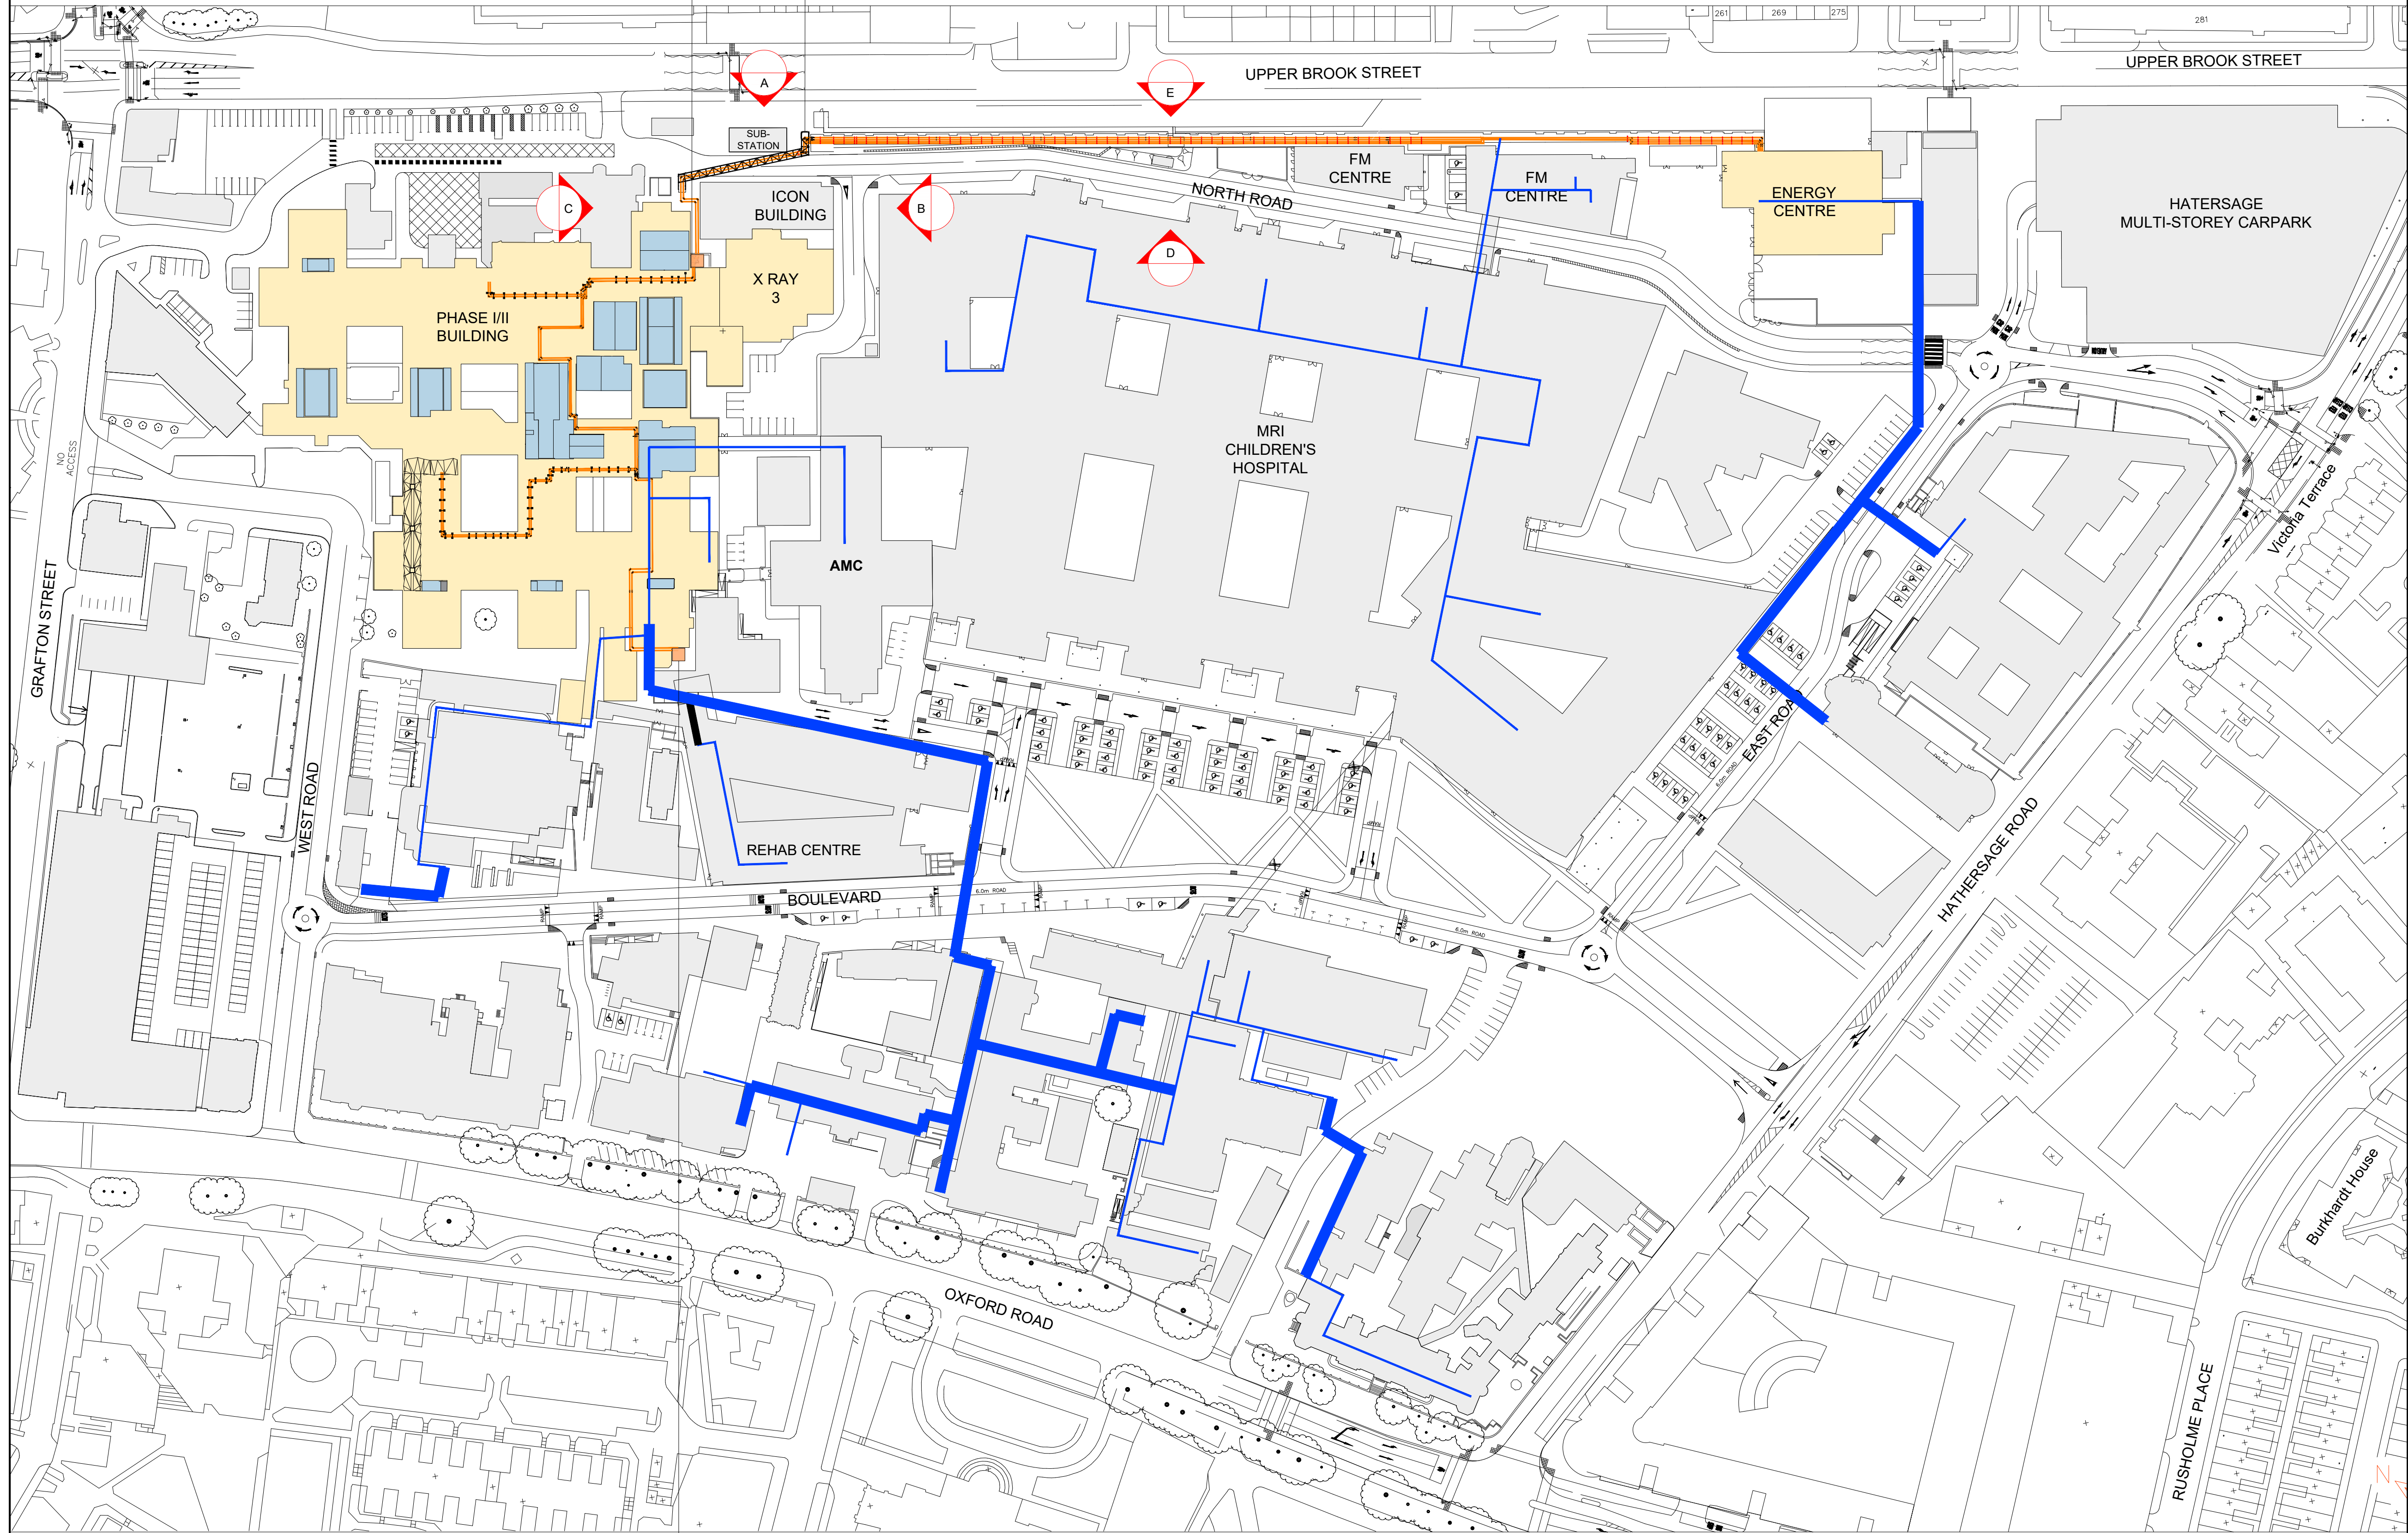

LOCATION OF PROPOSED PIPEWORK RISER
TO ROOF LEVEL REFER TO DRAWINGS:
2201-1-MaG-Z1-RF-D4-S-11-320 & 321 & 322

LOCATION OF PROPOSED NEW PIPEWORK
GANTRY BRIDGE OVER NORTH ROAD
AS PER ELEVATION DRAWINGS A - E

LOCATION OF PROPOSED PIPEWORK RISER
TO ROOF LEVEL REFER TO DRAWINGS:
2201-1-MaG-Z1-RF-D4-S-11-320 & 321 & 322

Note:
Contractor is to verify all dimensions and levels on site prior to site works commencement. Under no circumstances are any dimensions or levels to be scaled from this drawing number for the purpose of manufacturing components. Contractor to report any discrepancies to the Designer.

KEY:

- MANCHESTER UNIVERSITY NHS FOUNDATION TRUST BUILDINGS NOT ASSOCIATED WITH APPLICATION
- EXTENT OF BUILDINGS ASSOCIATED WITH PROPOSED SCHEME OF PIPEWORK REPLACEMENT WORKS
- EXTENT OF EXISTING ROOFTOP PLANTROOMS TO PHASE I/II BUILDING TO RECEIVE NEW STEAMLINE CONNECTIONS
- EXTENT OF EXISTING ABOVE GROUND SERVICE CORRIDOR HOUSING EXISTING STEAMLINE PIPEWORK RUNNING BETWEEN THE ENERGY CENTRE BUILDING AND THE FM CENTRE / PHASE I/II MRI BUILDING TO BE RETAINED & NEW PIPEWORK MOUNTED ABOVE
- EXTENT OF EXISTING ROOFTOP PLANTROOMS TO PHASE I/II BUILDING TO RECEIVE NEW STEAMLINE CONNECTIONS
- ROUTE OF EXISTING STEAMLINE PIPEWORK TO BE RETAINED
- ROUTE OF EXISTING BELOW GROUND SERVICE DUCT HOUSING STEAMLINE PIPEWORK TO BE RETAINED
- ROUTE OF NEW STEAM & CONDENSATE LINES TO SERVE VARIOUS ROOFTOP PLANTROOMS

REVISION		DESCRIPTION		DATE
--	PLANNING			JUNE 24
SCALE	1:1000		SIGNATURE	DATE
		DRAWN	MP	JUNE 24
		CHECKED	MB	JUNE 24
ORIGINAL SIZE	A1	APPROVED	MB	JUNE 24
This drawing is copyright and may not be reproduced or made use of unless expressly agreed by M Bradbury Consulting Ltd				
CLIENT				
CM Oxendale Ltd Unit 5 Dorlan Court Alan Ramsbottom Way Great Harwood Blackburn BB6 7UR				
PROJECT				
Manchester Royal Infirmary, Oxford Road, Manchester, M13 9WL Steamline Replacement Scheme				
<div> 59 Wilmslow Road, Handforth, Cheshire, SK9 3EN WEB: www.bradbury-consulting.co.uk TEL: 01625 522 209</div>				
TITLE				
AS PROPOSED SITE PLAN				
JOB NUMBER				
2022.096				
DRAWING NUMBER				
2022.096.PL03				