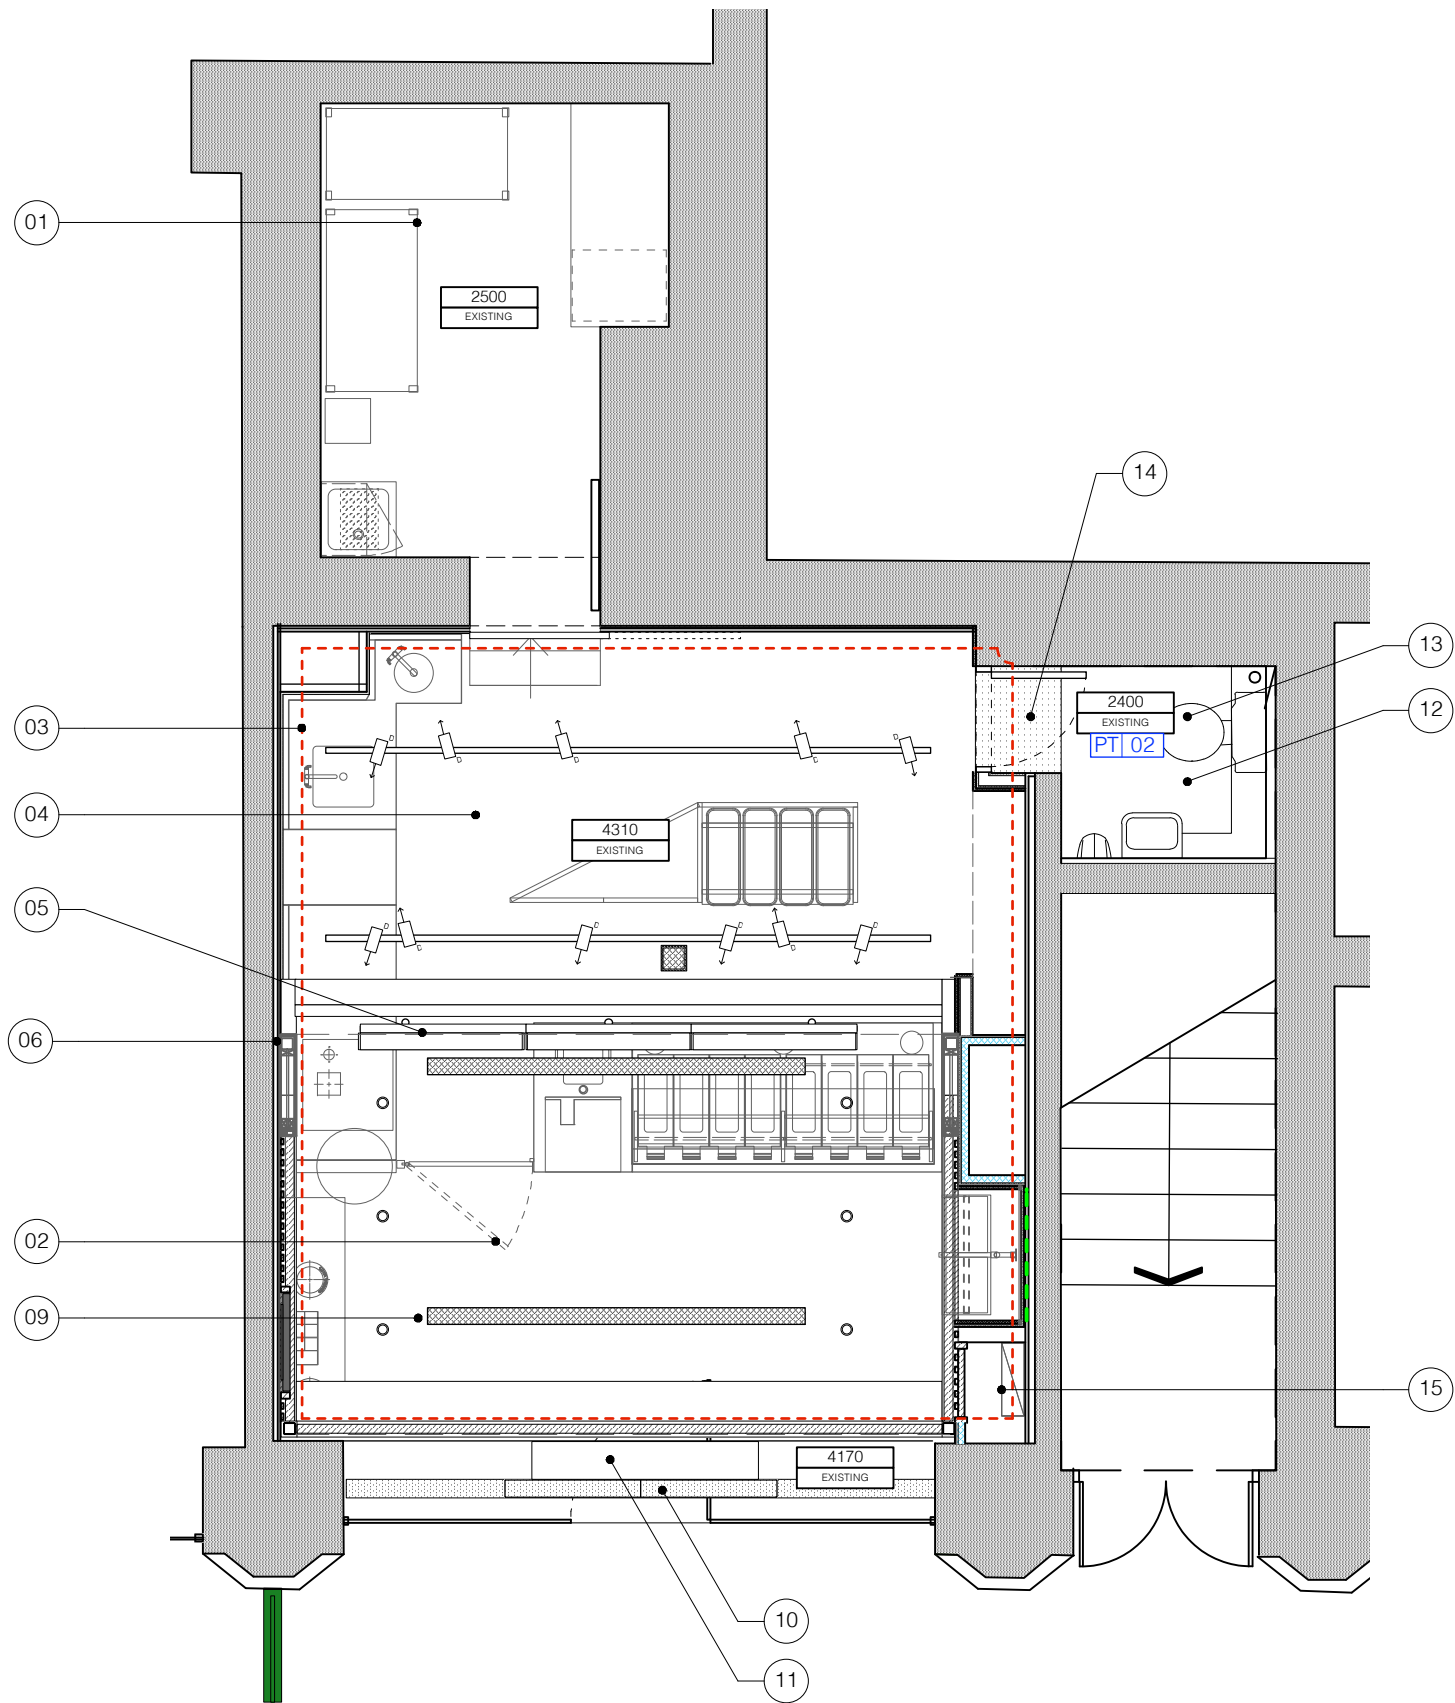


CEILING HEIGHT	
SYMBOL	DESCRIPTION
0000	Denotes ceiling heights with description below. Note - new plasterboard ceilings to be taped and joined ready for paint decoration.

SPEAKERS	
SYMBOL	DESCRIPTION
[Symbol]	BLACK BOSE FreeSpace Loudspeaker ceiling suspended. NOTE: Music system to be interfaced with fire alarm system and closed down on activation of fire alarm.

LIGHTING	
SYMBOL	DESCRIPTION
[Symbol]	White track with track mounted adjustable LED white spot light. Integral driver. 12W 12" 2700k 900lm with LSOH and non PVC cabling
[Symbol]	LED tape 2700K 900lm
[Symbol]	LED Non-maintained Emergency Lighting to comply with BS 5266:2016

- Notes
- Existing ceiling to BOH store room to be retained.
 - Plasterboard soffit to be supported from free standing external framework to each side
 - Dashed red line denotes extent of existing original ceiling cornice, all to be retained and no fixings permitted. Existing non original suspended plasterboard ceiling inside of cornice to be retained.
 - Existing plasterboard ceiling and walls above 3-3.6m to be decorated PT01. Any visible ducting, venting, cable trays etc at high level to be decorated to match. Fixings into ceiling only to existing non original plasterboard ceiling - allow for additional ply pattresses as necessary - fixings only into plasterboard structure
 - 3no. 50" horizontal digital menu screens fixed back to new rear feature bulkhead
 - Freestanding structure for feature display 'box' - lateral restrain to be taken back to existing plasterboard lining
 - N/A
 - N/A
 - Recessed linear AC grill ducted form FCU in rear area. Grille to be powder-coated RAL 9010 - exact size of grille TBC by Mechanical contractor.
 - 1.8m internally illuminated brand sign to be mounted to top of existing steel beam INSIDE of shopfront glazing. For signage detail refer to Drg. 044.02.4.
 - Overdoor heater to be fixed back to existing steel beam. Heater to be concealed from view externally behind bow tie sign.
 - Electrical contractor to review existing lighting to staff WC and relamp with LED as necessary
 - Existing ceiling to staff WC and to be retained.
 - New plasterboard ceiling to infill space between existing staff WC ceiling and new door position. Fix only to existing timber uprights along existing perimeter wall. New ceiling to be decorated PT02.
 - Existing electrical cupboard open to soffit to be maintained for electrical cabling route.
 - N/A

Revision

DESCRIPTION
Reflected Ceiling Plan

CLIENT
Krispy Kreme

PROJECT
Manchester Deansgate

ADDRESS
111 Deansgate, Manchester M3 2BQ

JOB No. DWG No. REV.

044.01.3 -

DATE: **APR 24** STATUS: **APPROVAL**

DRAWN BY
SW

SCALE
1:50 @ A3

PATH

Unit 5, 7 Wenlock Road, London N1 7SL
T +44 (0)20 7253 9005 F +44 (0)20 7253 9004
www.pathdesign.co.uk info@pathdesign.co.uk

THIS DRAWING IS FOR DESIGN INTENT PURPOSES ONLY. DO NOT SCALE THIS DRAWING

* This drawing is based on provision that it is not subject to development without the prior written consent of PATH DESIGN
* Contractors should provide their own setting out drawings for confirmation by PATH DESIGN
* This drawing is the property of PATH DESIGN and copyright is reserved by them.
* All structural works are to be retained, confirmed and approved by structural engineer.
* All dimensions to be verified on site prior to work commencing.

**ALL EXISTING WALL SUPPORTS
BEHIND EXISTING WALL FINISHES
TO BE RETAINED FOR NEW
FINISHES TO BE FIXED BACK TO.**

**NO FIXINGS PERMITTED TO
EXISTING GRADE II LISTED
CEILING CORNICE TO PERIMTER
OF MAIN SPACE. EXISTING
SUSPENDED PLASTERBOARD
CEILING INSIDE OF CORNICE TO
BE RETAINED.**