

SECURITY

-  PTZ

 FIX

 PTZ

 FIX

 PIR
- 

 IAP

 PSU




-  M

 R

 KP

 DC

 V
-  VH


 INT






 AC
-  G2

 G3

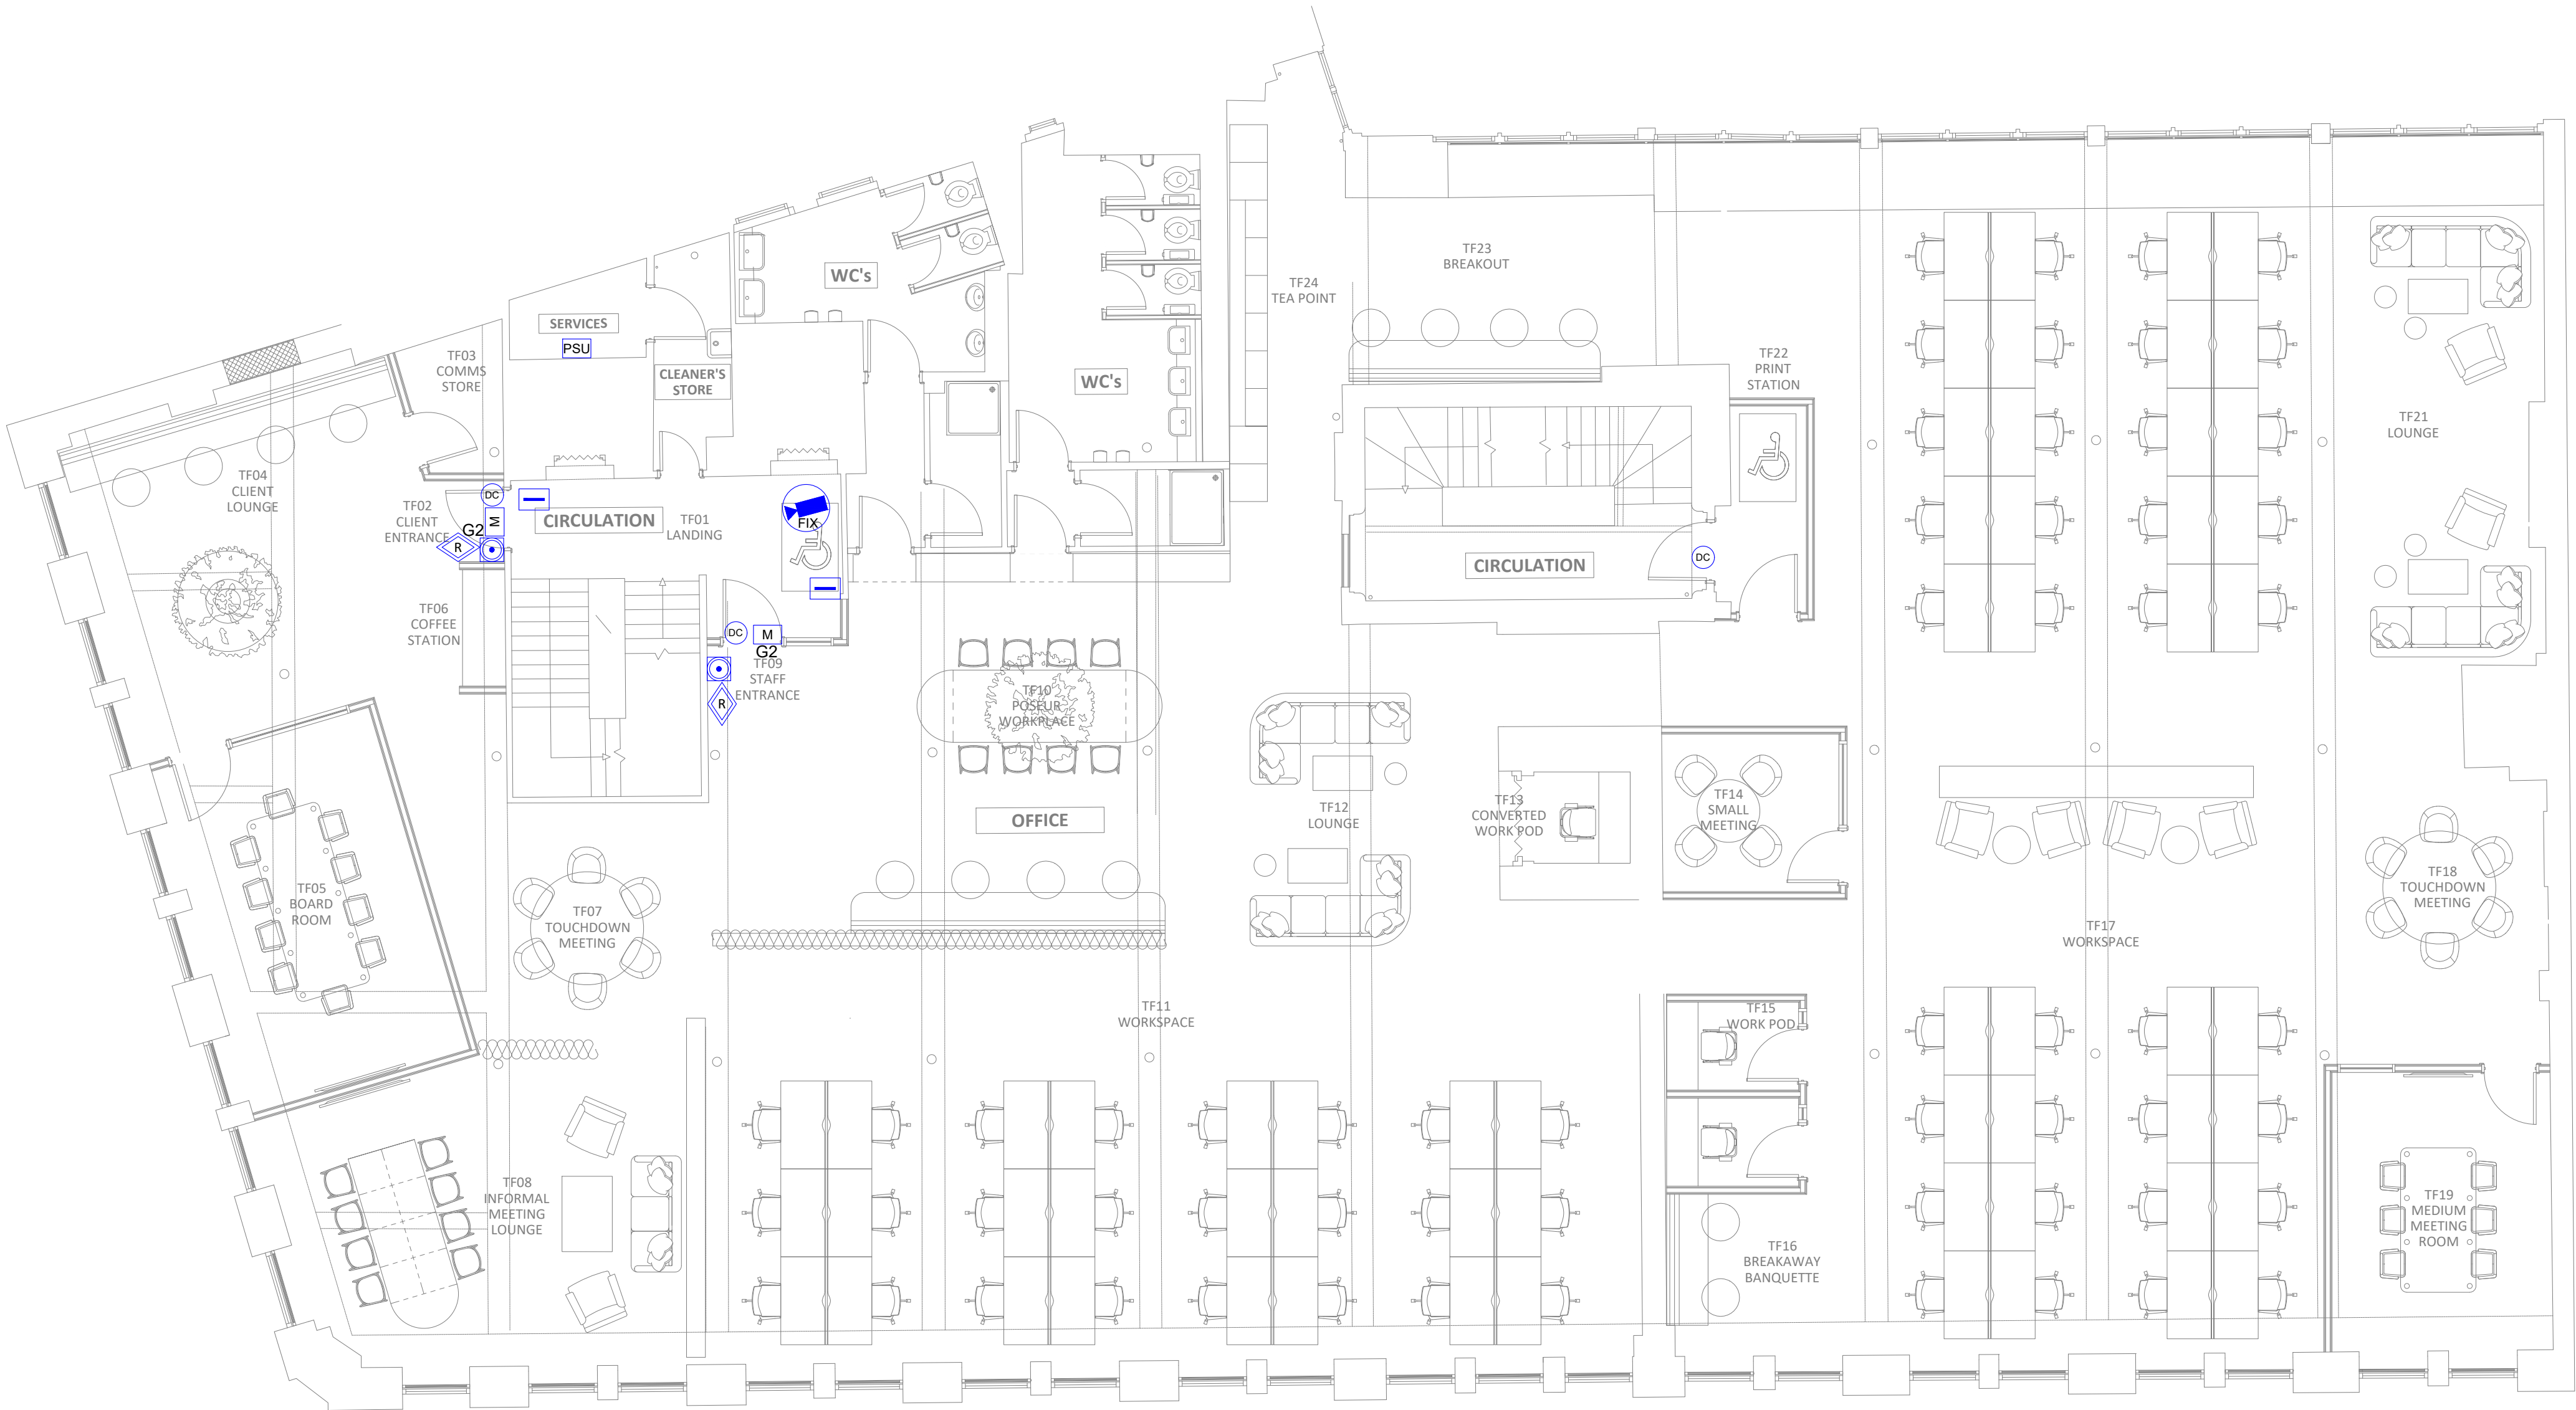

PROPOSED THIRD FLOOR

P1	ISSUE FOR PLANNING	LF	17.05.24
REV	DESCRIPTION	BY	DATE

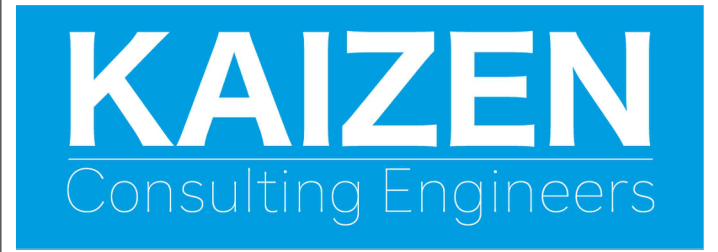

www.kaizen-ce.com e: info@kaizen-ce.com

CLIENT

bruntwood
SciTech

ARCHITECT
A X I

PROJECT
117-119 PORTLAND STREET
MANCHESTER

DRAWING TITLE
ELECTRICAL SERVICES
THIRD FLOOR
SECURITY LAYOUT

CHECKED	DATE	DRAWN	SCALE
LF	FEB 24	MN	1:75@A1

STAGE 4

DRAWING NUMBER	STATUS	REV.
1168-KCE-ZZ-03-DR-E-6804	S4	P1