


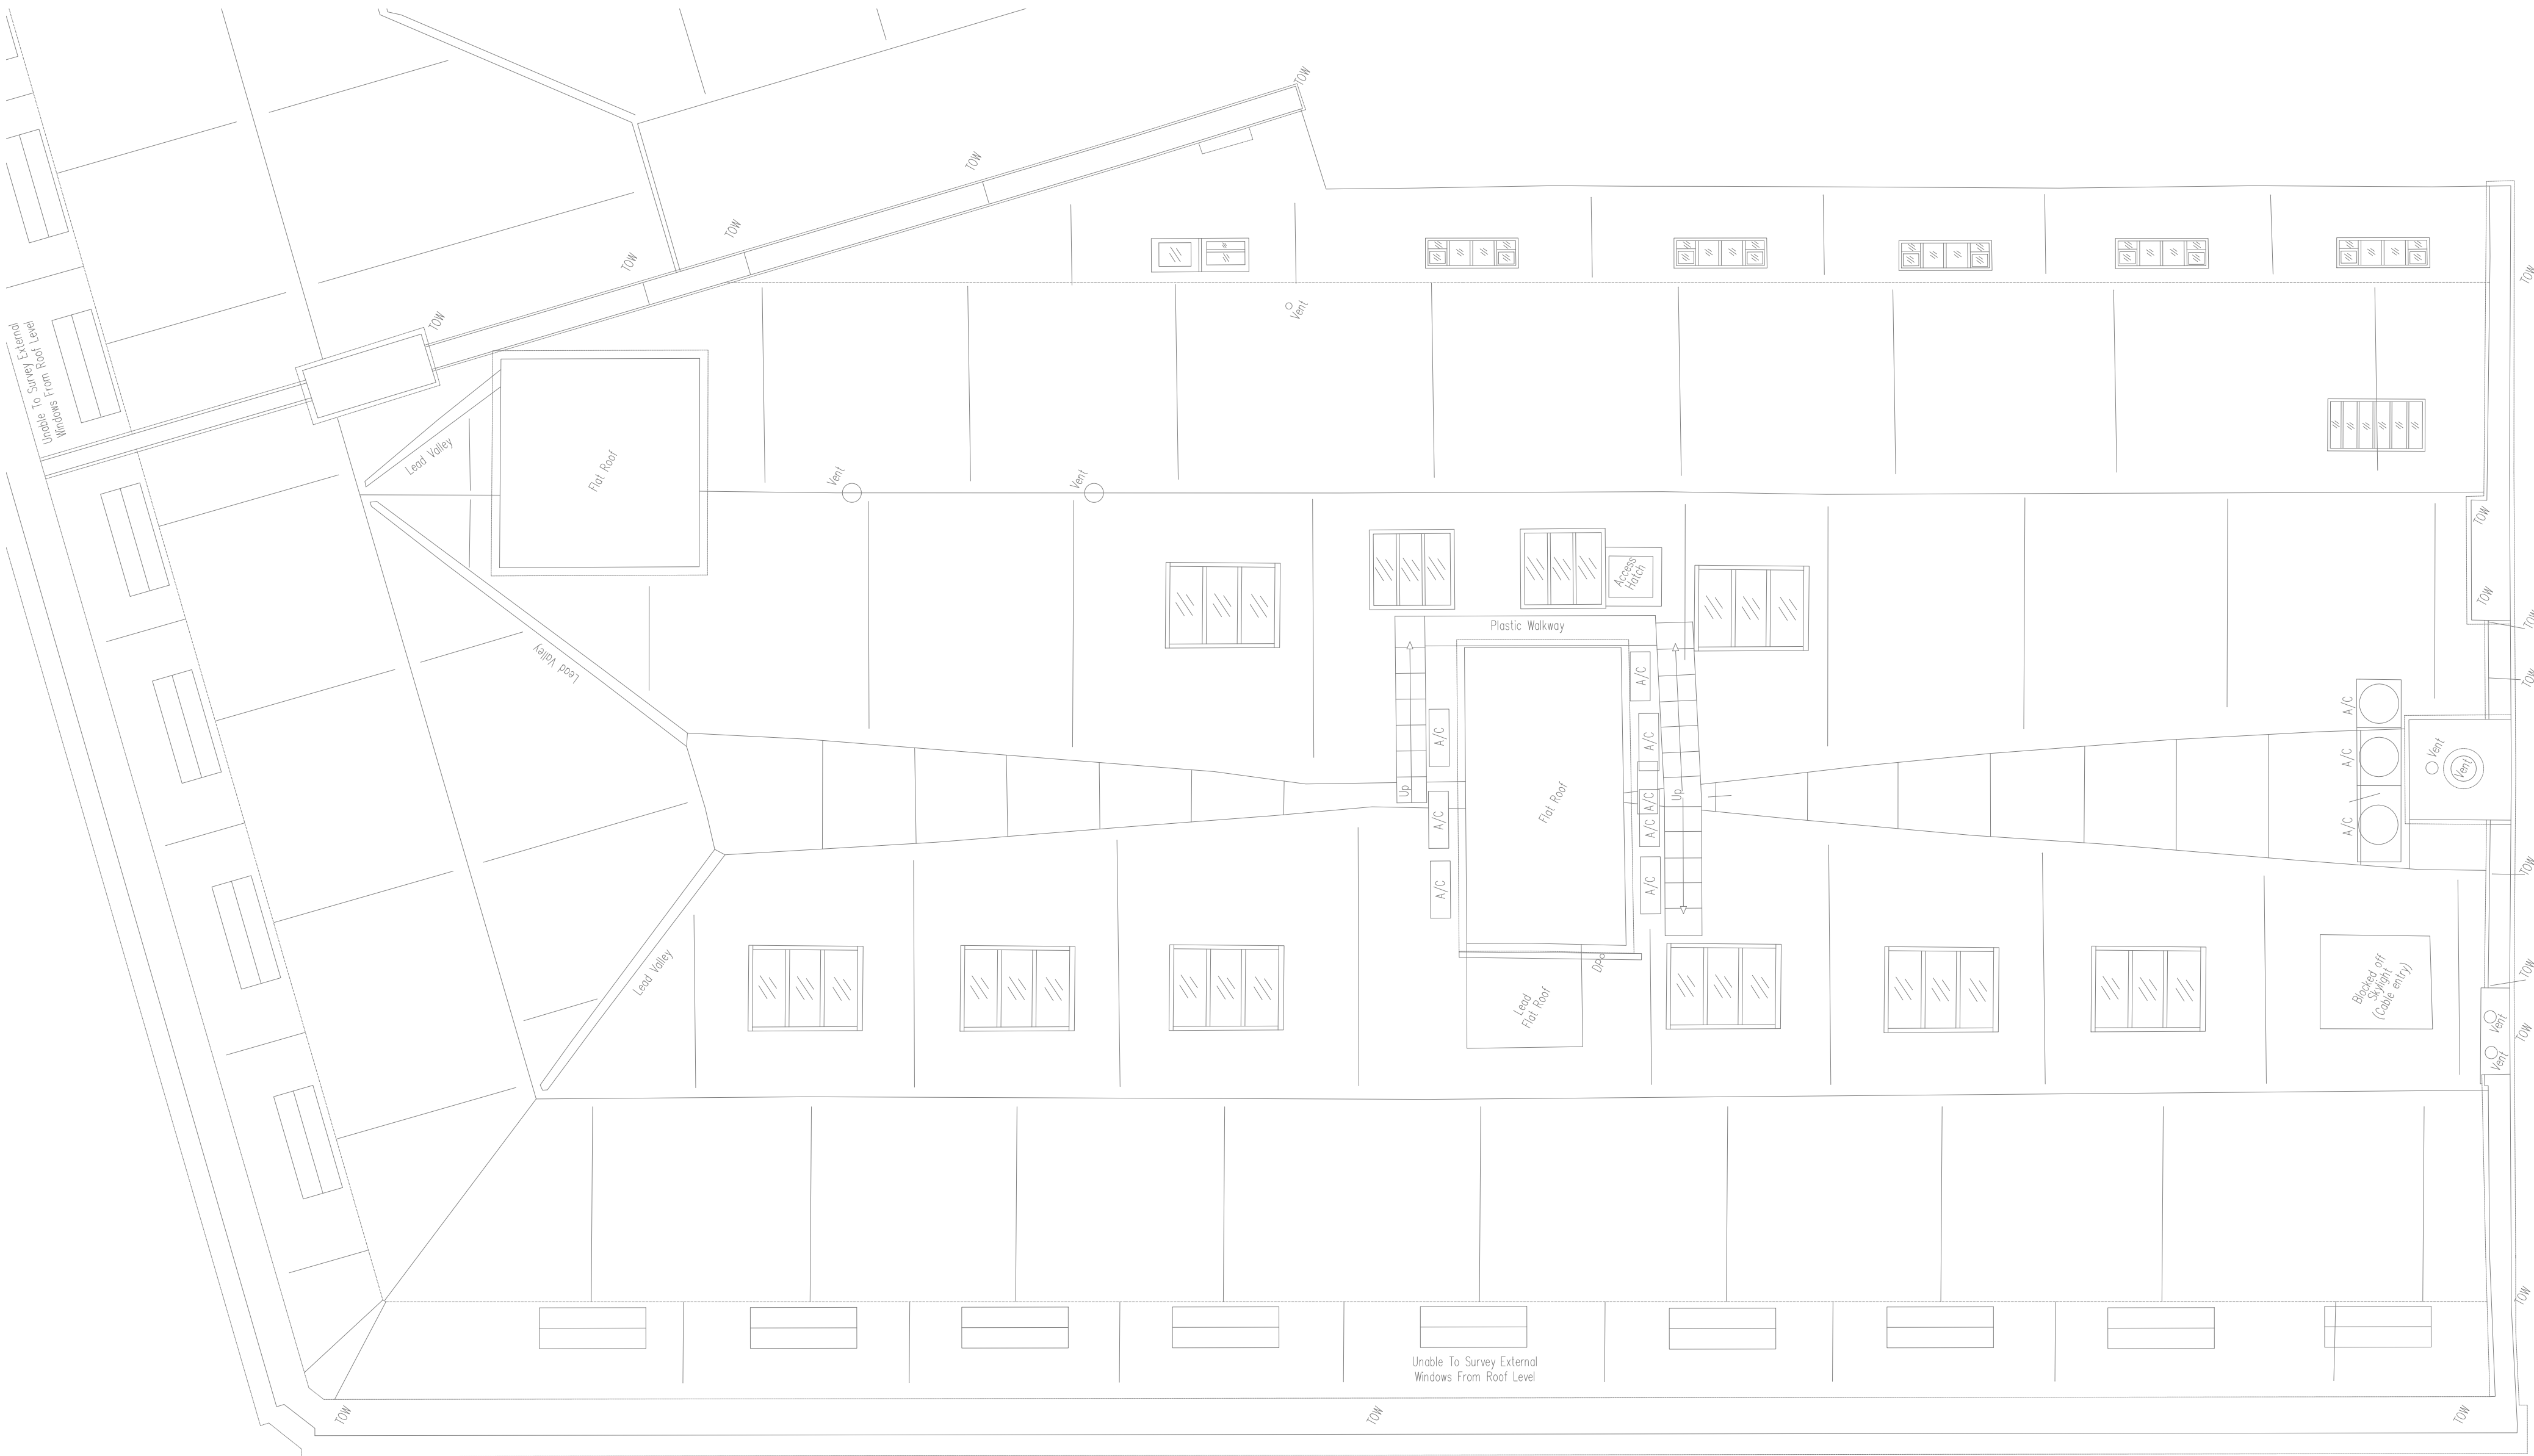


1 ROOF SECURITY LAYOUT  
1:75

SECURITY

- PTZ CCTV CAMERA PTZ
- FIX CCTV CAMERA FIX
- PTZ CCTV CAMERA IN A DOME PTZ
- FIX CCTV CAMERA IN A DOME FIX
- PIR PRESENCE INFRARED DETECTOR CEILING MOUNTED. 360° COVERAGE
- PIR PRESENCE INFRARED DETECTOR
- IAP INTRUDER ALARM PANEL
- PSU POWER SUPPLY UNIT
- ACCESS CONTROL SWIPE READER
- SECURE SIDE EMERGENCY RELEASE (GREEN BGU)
- M MAGNETIC DOOR HOLDER
- R PUSH BUTTON/ DOOR RELEASE BUTTON
- KP INTRUDER ALARM KEY PAD
- DC DOOR CONTACT
- V VIDEO ENTRY SYSTEM
- VH VIDEO ENTRY HANDSET
- INT VIDEO ENTRY SPEECH PANEL
- EXTERNAL BELL / BEACON UNIT
- EXTERNAL SOUNDER STROBE UNIT
- AC ACCESS CONTROL

|     |                    |    |          |
|-----|--------------------|----|----------|
| P1  | ISSUE FOR PLANNING | LF | 17.05.24 |
| REV | DESCRIPTION        | BY | DATE     |

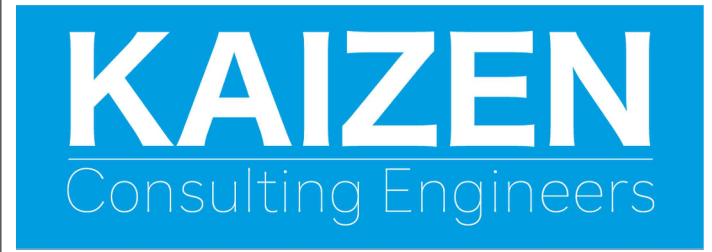

www.kaizen-ce.com e: info@kaizen-ce.com

CLIENT  
**bruntwood**  
SciTech

ARCHITECT  
**A X I**

PROJECT  
117-119 PORTLAND STREET  
MANCHESTER

DRAWING TITLE  
**ELECTRICAL SERVICES**  
ROOF SECURITY LAYOUT

|         |        |       |         |
|---------|--------|-------|---------|
| CHECKED | DATE   | DRAWN | SCALE   |
| LF      | FEB 24 | EW    | 1:75@A1 |

**STAGE 4**

|                          |        |      |
|--------------------------|--------|------|
| DRAWING NUMBER           | STATUS | REV. |
| 1168-KCE-ZZ-RF-DR-E-6806 | S4     | P1   |