



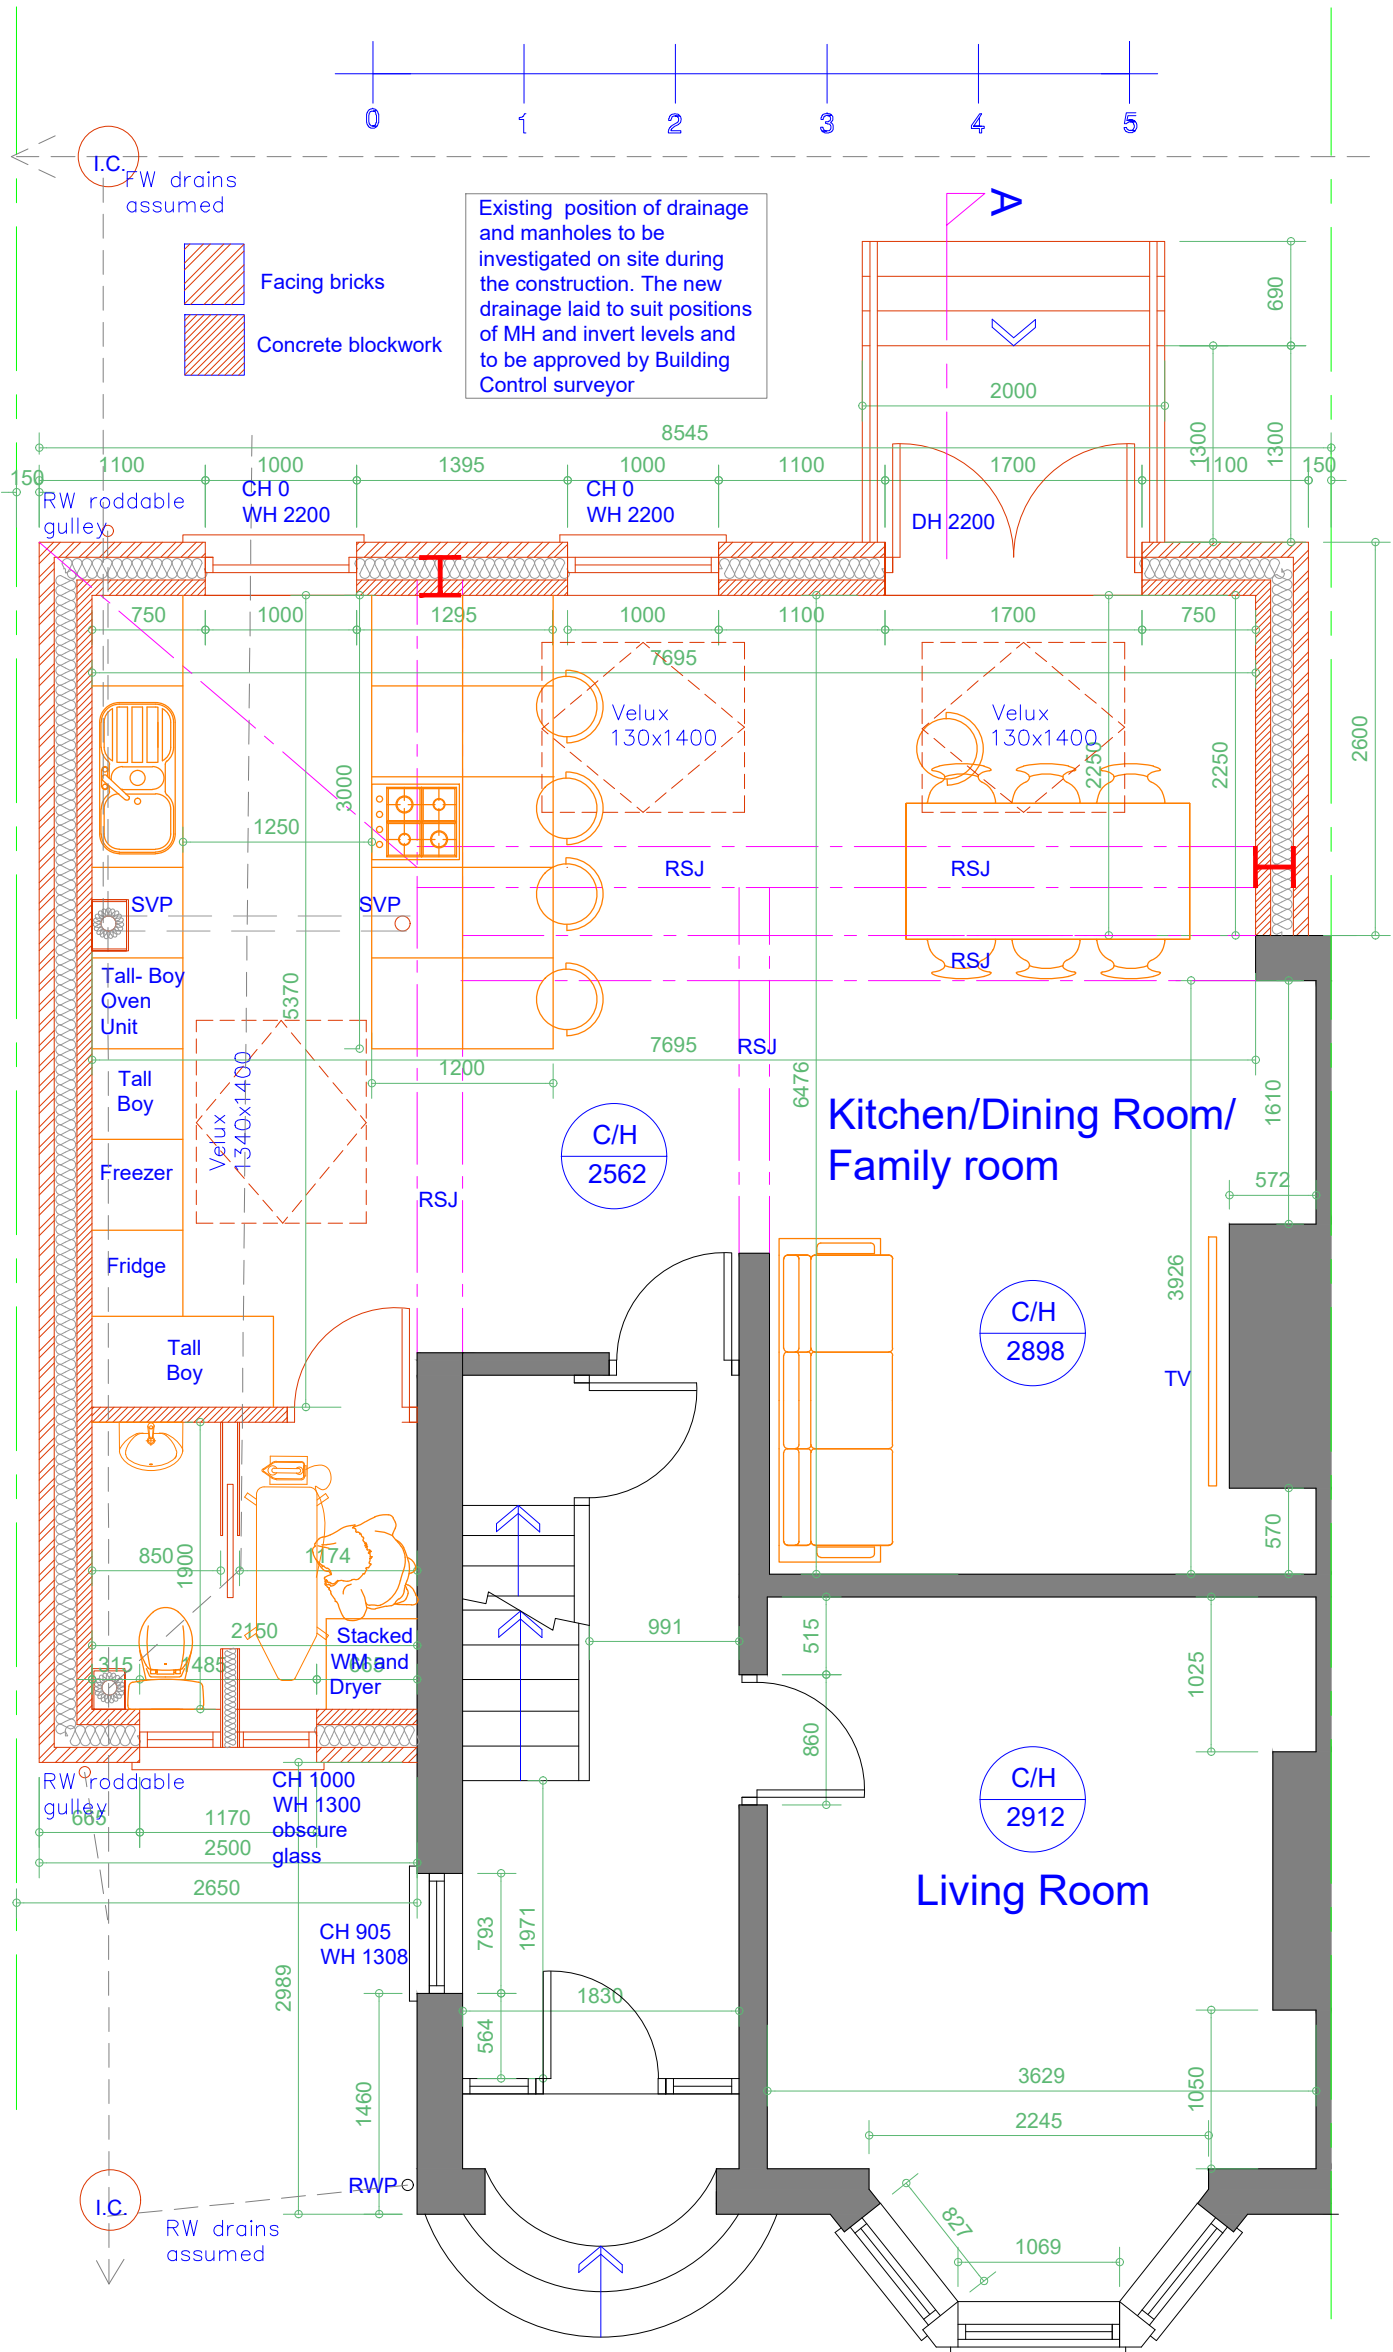

Proposed Ground Floor Plan
Scale 1:50

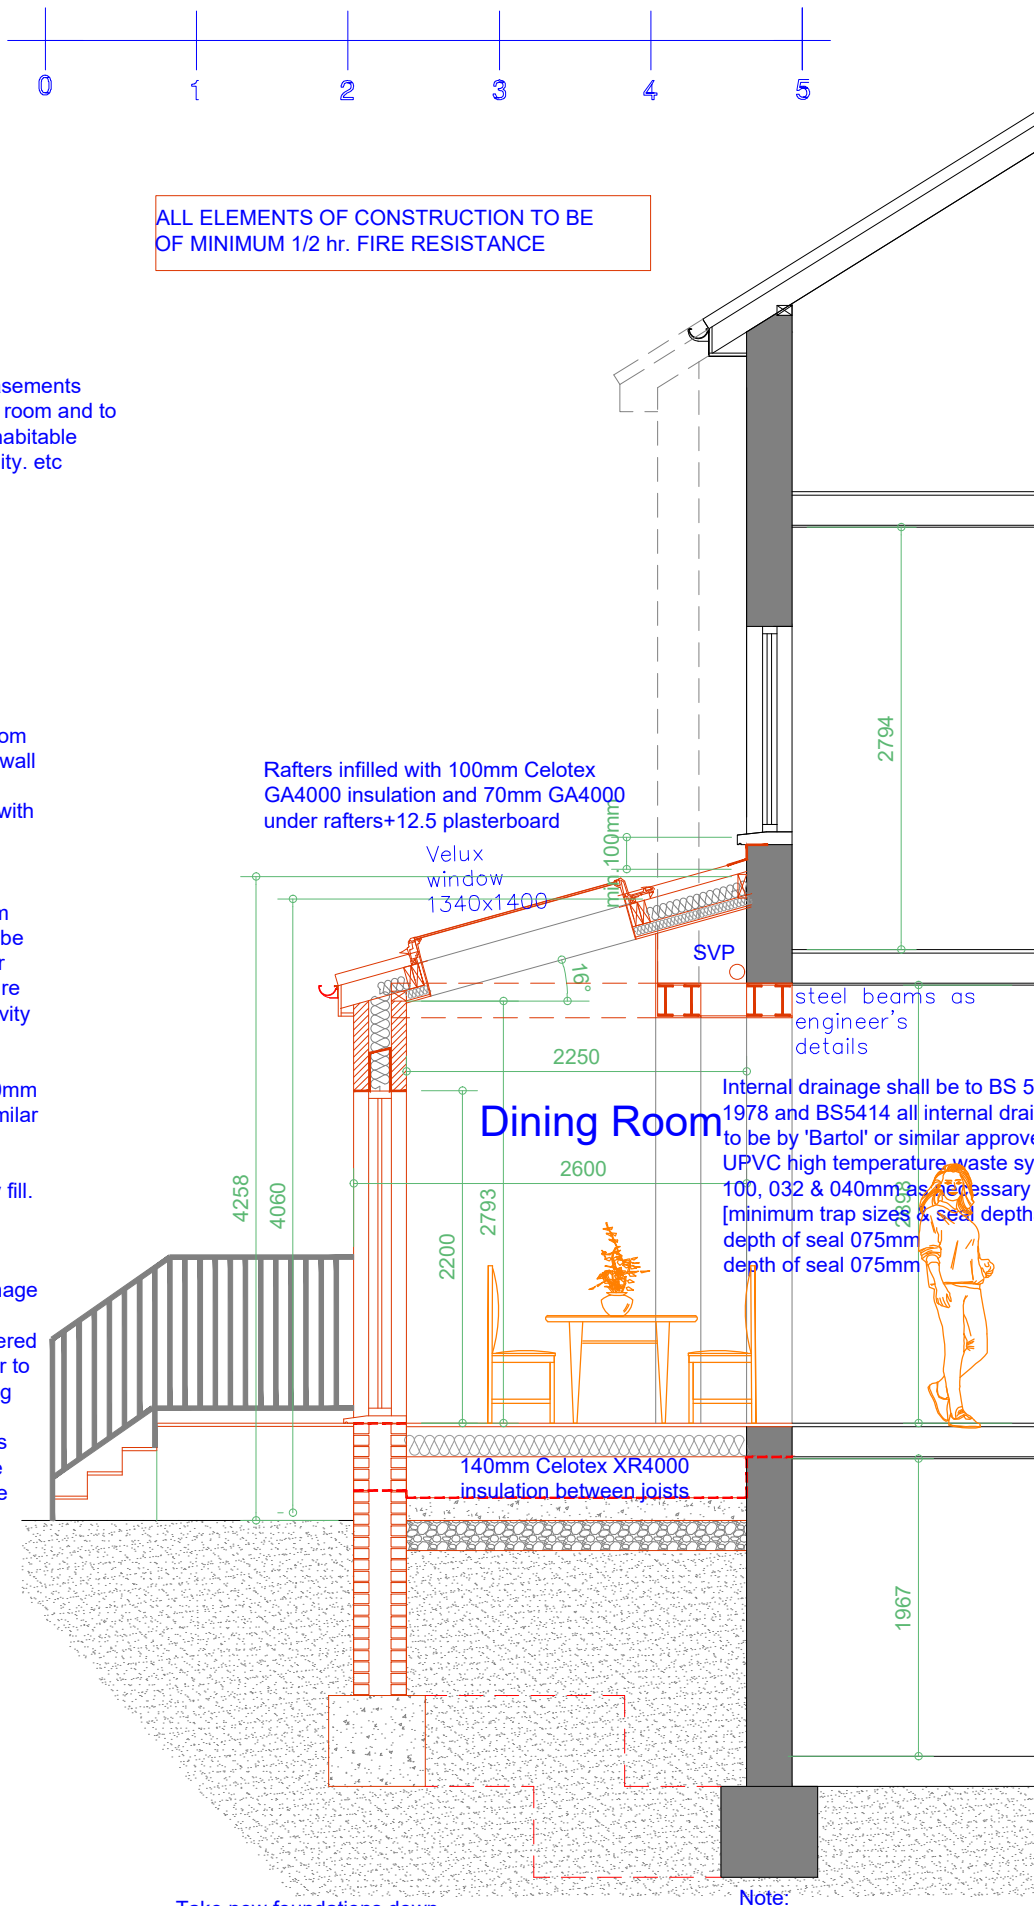

Proposed Section A-A
Scale 1:50

All windows to have openable casements equal to min. 1/20th floor area of room and to be fully weatherstripped all non-habitable rooms IE bathrooms, kitchen, utility. etc

Kingspan Thermabate Cavity Wall Closers (or equivalent) will be used.

Eaves ventilation to be type FV100 by 'Glidevale' to 10,000mm² / lin. metre free air space

Lateral restraint provided to bottom truss chords parallel to external wall to be of 030x005mm MS straps, carried over min. 3 no. chords [with 050x100mm noggins under] at 2000mm centres.

wall construction to be of 350mm cavity construction outer skin to be of facing brick as exist. or similar approved, built at gauge to ensure horizontal alignment, 150mm cavity with 150mm Rockwool full fill insulation installed as work proceeds, inner leaf to be of 100mm thermalite turbo blockwork or similar approved, NOTE. cavity wall insulation to extend past DPC to top of cavity fill.

NOTE, Positions of proposed drainage runs and types of drainage indicated on drawings are provisional only, and may be altered to suit site conditions. Contractor to check invert & position of existing drainage systems to ensure adequate fall & to ensure BCO is satisfied with proposed drainage layout, fall and site inverts before excavation of drainage runs

ALL ELEMENTS OF CONSTRUCTION TO BE OF MINIMUM 1/2 hr. FIRE RESISTANCE

Cross flow ventilation provided to roof rafter space via propriety eaves strip (continuous and dry ridge (5mm) ventilation systems levels at least to a min 25mm continuous wide strip

ELECTRICITY service into existing buildings., care must be taken when any excavation is taking place near these positions. Confirm position of electricity cables with UK Power Networks (plans@ukpowernetworks.co.uk) before commencing on site, position of service cable to be marked on site, and also on copy of plans.

WATER supply to be located & isolated prior to removal of any pipework, water supply pipe to be adequately protected froaccidental wilful damage at all times, contact United Utilities 0845 746 2200

GAS service into existing buildings., care must be taken when any excavation is taking place near these positions. Confirm position of gas supply pipe with Transco 01204 - 546900, before commencing on site, position of service pipe to be marked on site, and also on copy of plans, once position of pipe has been established. IN AN EMERGENCY CALL 0800 111999 IMMEDIATELY

Maintain any existing floor ventilation from the existing dwelling with 100mm dia PVC duct over / under new floor and extending telescopic air vents and air bricks with cavity trays over at maximum 1500mm centres. all vegetable strip to be removed from site of slab & ground to be treated were necessary with proprietary weedkiller

Rev	Date	Description
Issued For INFORMATION PURPOSES ONLY		

Client
Mr. Tom Lindsay

Project
16 Cranbourne Road,
Chorlton. M21 8AP
Proposed single story rear
and side extension.

Scheme - Drawing Title
Proposed Floor Plan and Section.

02	Date	24.06.24
Drawing No.	Revision	Scale 1:50 @A2



Plans To Build It Ltd
Tel: 0161 728 5730
Mob: 07741175755
www.planstobuildit.com