


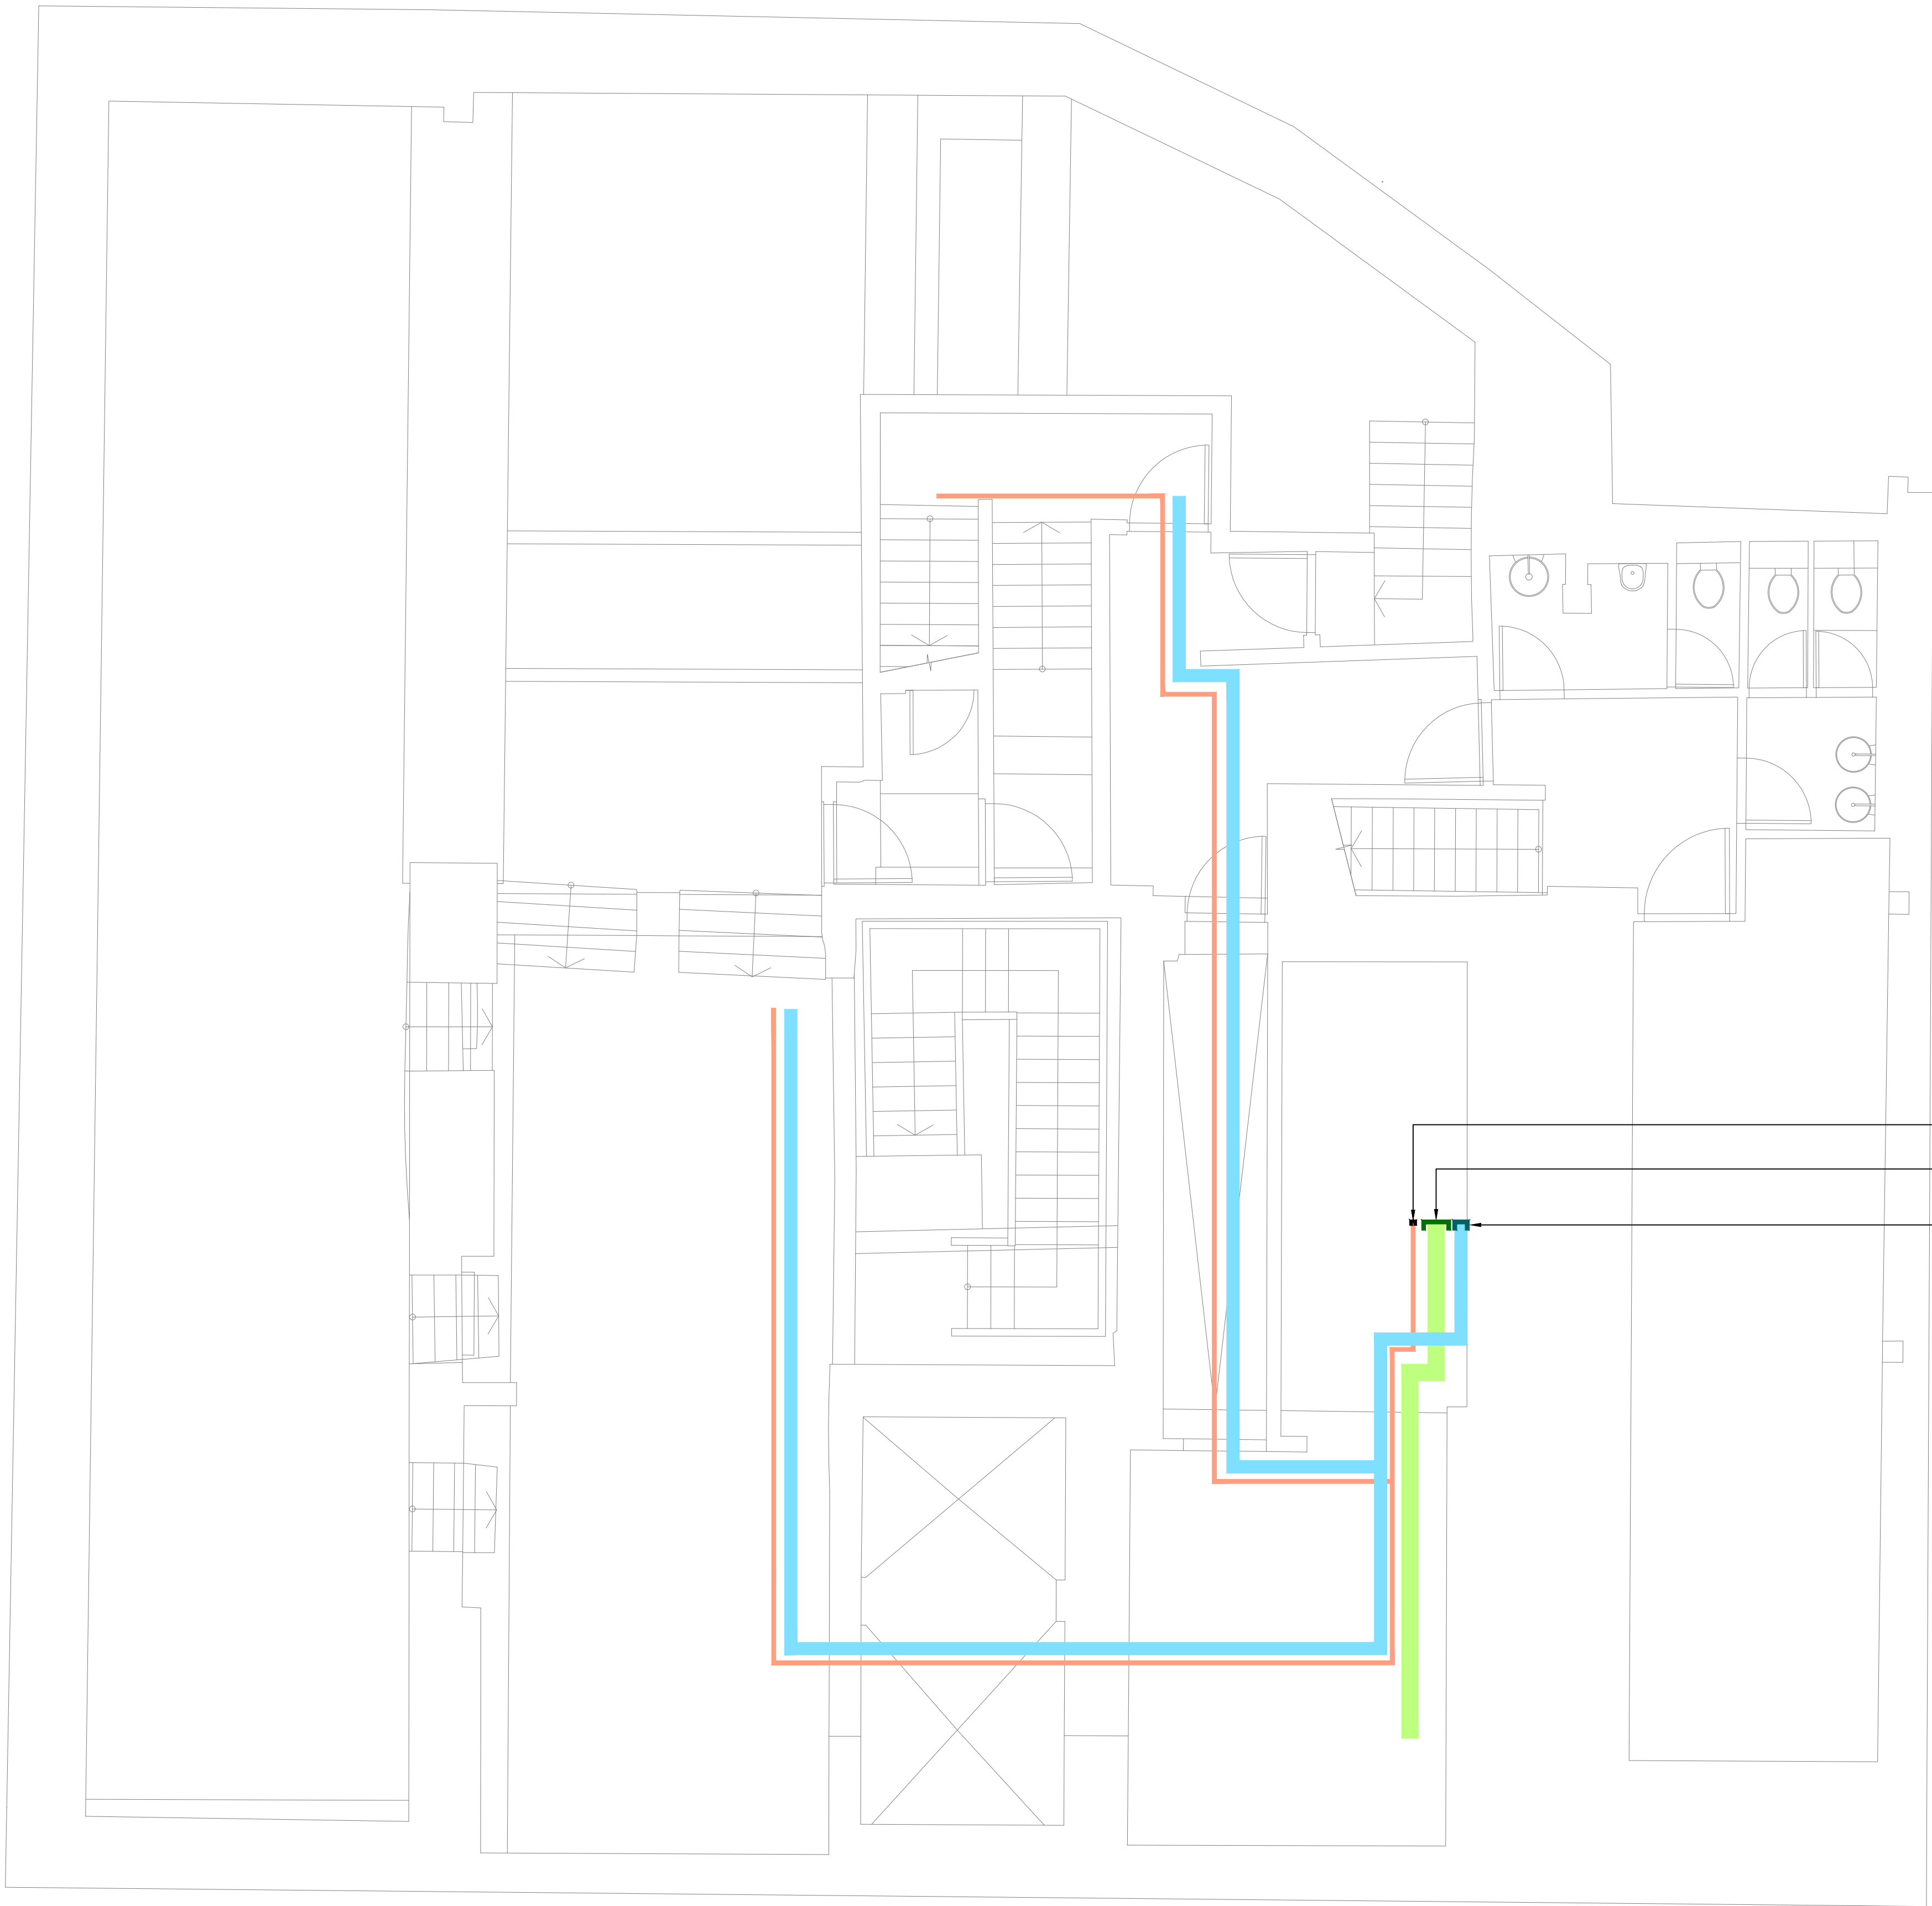

FIRE ALARM TRAY RISING TO ABOVE
SUBMAIN CABLE TRAY RISING TO ABOVE
SECURITY CABLE TRAY RISING TO ABOVE

DRAWING BACKGROUND INFO

LEGEND

- HEAVEY DUTY GALVANISED STEEL TRAY FOR SUBMAINS
- GALVANISED BASKET CABLE TRAY FOR LV FINAL CIRCUITS
- GALVANISED BASKET CABLE TRAY FOR DATA & ALARM CABLING
- GALVANISED STEEL CABLE TRAY FOR FIRE ALARM
- SIZE OF CONTAINMENT

PL	30.05.24	DH	PLANNING
----	----------	----	----------

Rev	Date	Dnn	Description
-----	------	-----	-------------

Client
WATCHES OF SWITZERLAND GROUP

Architect
JOHNSON PINNEY ARCHITECTS

Project
KINGS STREET, MANCHESTER



London, Bexley, Birmingham, Glasgow, Leeds, Manchester, Waltham Abbey
0808 175 1000 drawings@fhpress.com www.fhpress.com


Drawing Title
ELECTRICAL SERVICES
CONTAINMENT LAYOUT
BASEMENT

Scale 1:50@A1 Drawn AutoCAD/NS

Date APR' 2024 Checked MC

Status
PLANNING

Project number/Drawing number
44758-E-610-B1-100
Revision
PL

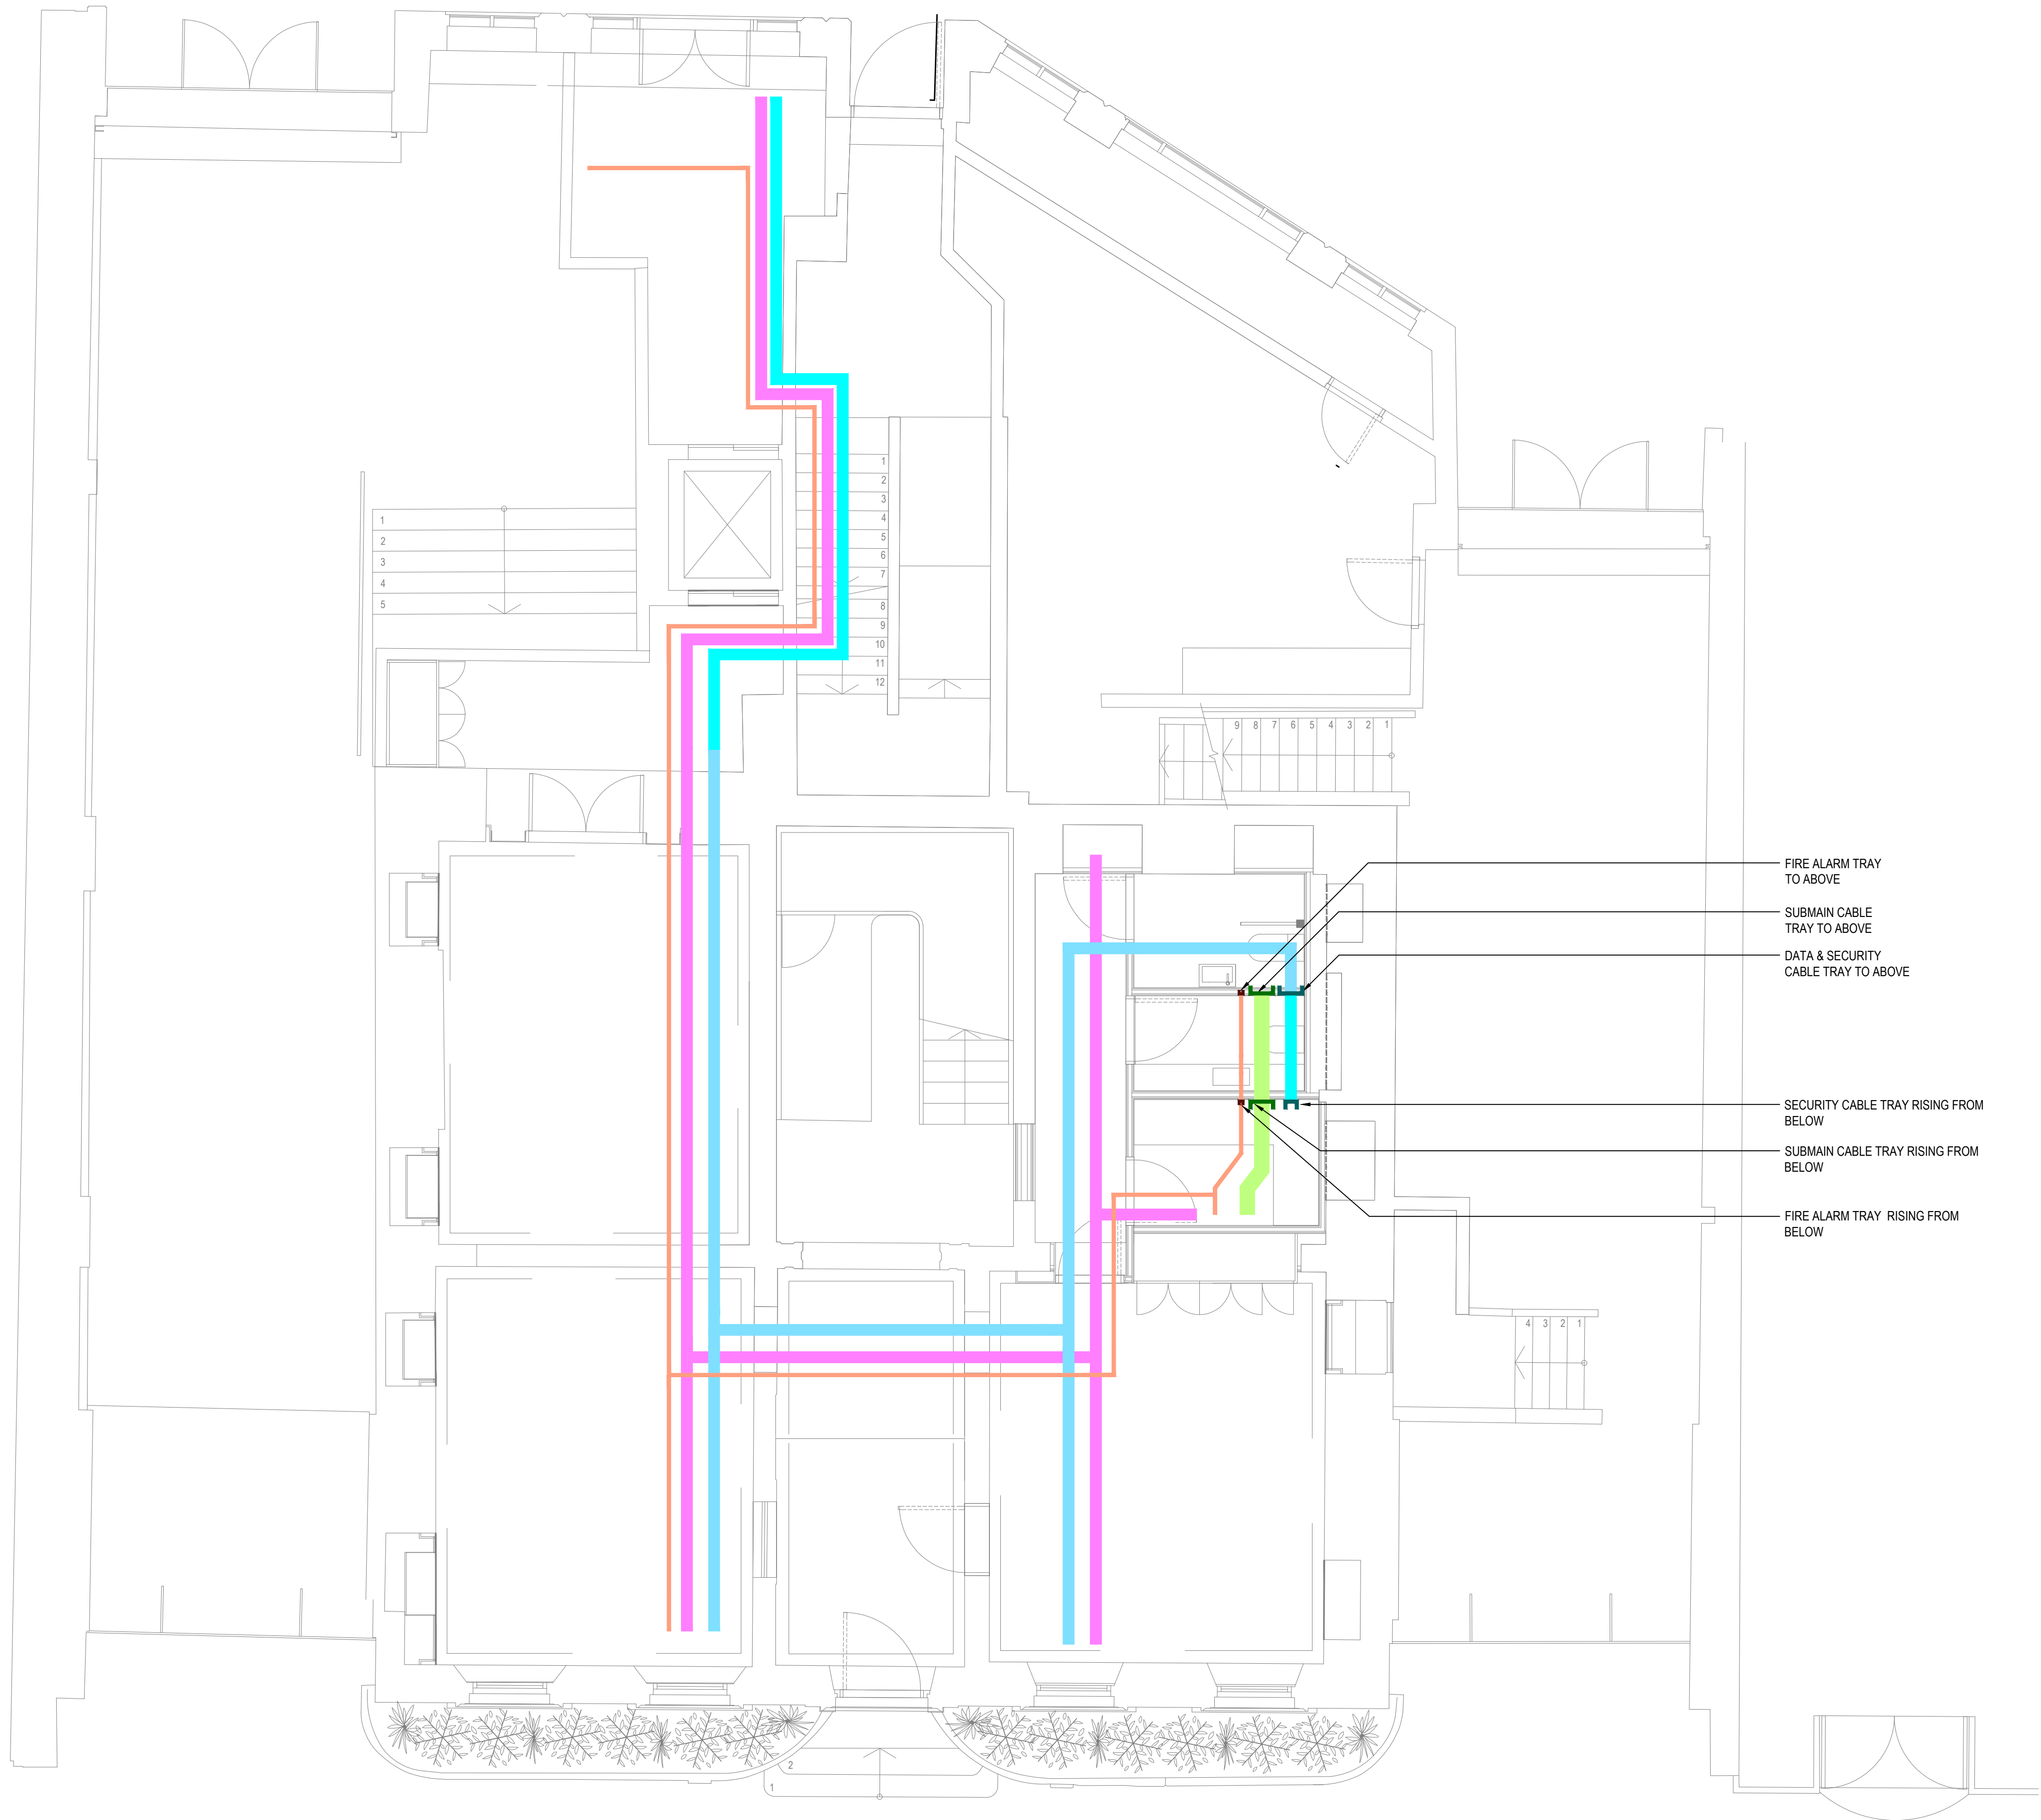

FIRE ALARM TRAY
TO ABOVE

SUBMAIN CABLE
TRAY TO ABOVE

DATA & SECURITY
CABLE TRAY TO ABOVE

SECURITY CABLE TRAY RISING FROM
BELOW

SUBMAIN CABLE TRAY RISING FROM
BELOW

FIRE ALARM TRAY RISING FROM
BELOW

DRAWING BACKGROUND INFO

LEGEND

- HEAVEY DUTY GALVANISED STEEL TRAY FOR SUBMAINS
- GALVANISED BASKET CABLE TRAY FOR LV FINAL CIRCUITS
- GALVANISED BASKET CABLE TRAY FOR DATA & ALARM CABLING
- GALVANISED STEEL CABLE TRAY FOR FIRE ALARM
- SIZE OF CONTAINMENT

PL	30.05.24	DH	PLANNING
Rev	Date	Dnn	Description

Client
WATCHES OF SWITZERLAND GROUP

Architect
JOHNSON PINNEY ARCHITECTS

Project
KINGS STREET, MANCHESTER

FHP  **ESS**


London, Bexley, Birmingham, Glasgow, Leeds, Manchester, Waltham Abbey
0808 175 1000 drawings@fhpress.com www.fhpress.com

Drawing Title
ELECTRICAL SERVICES
CONTAINMENT LAYOUT
GROUND FLOOR

Scale	1:50@A1	Drawn	AutoCAD/NS
Date	APR' 2024	Checked	MC

Status
PLANNING

Project number/Drawing number	Revision
44758-E-610-00-100	PL

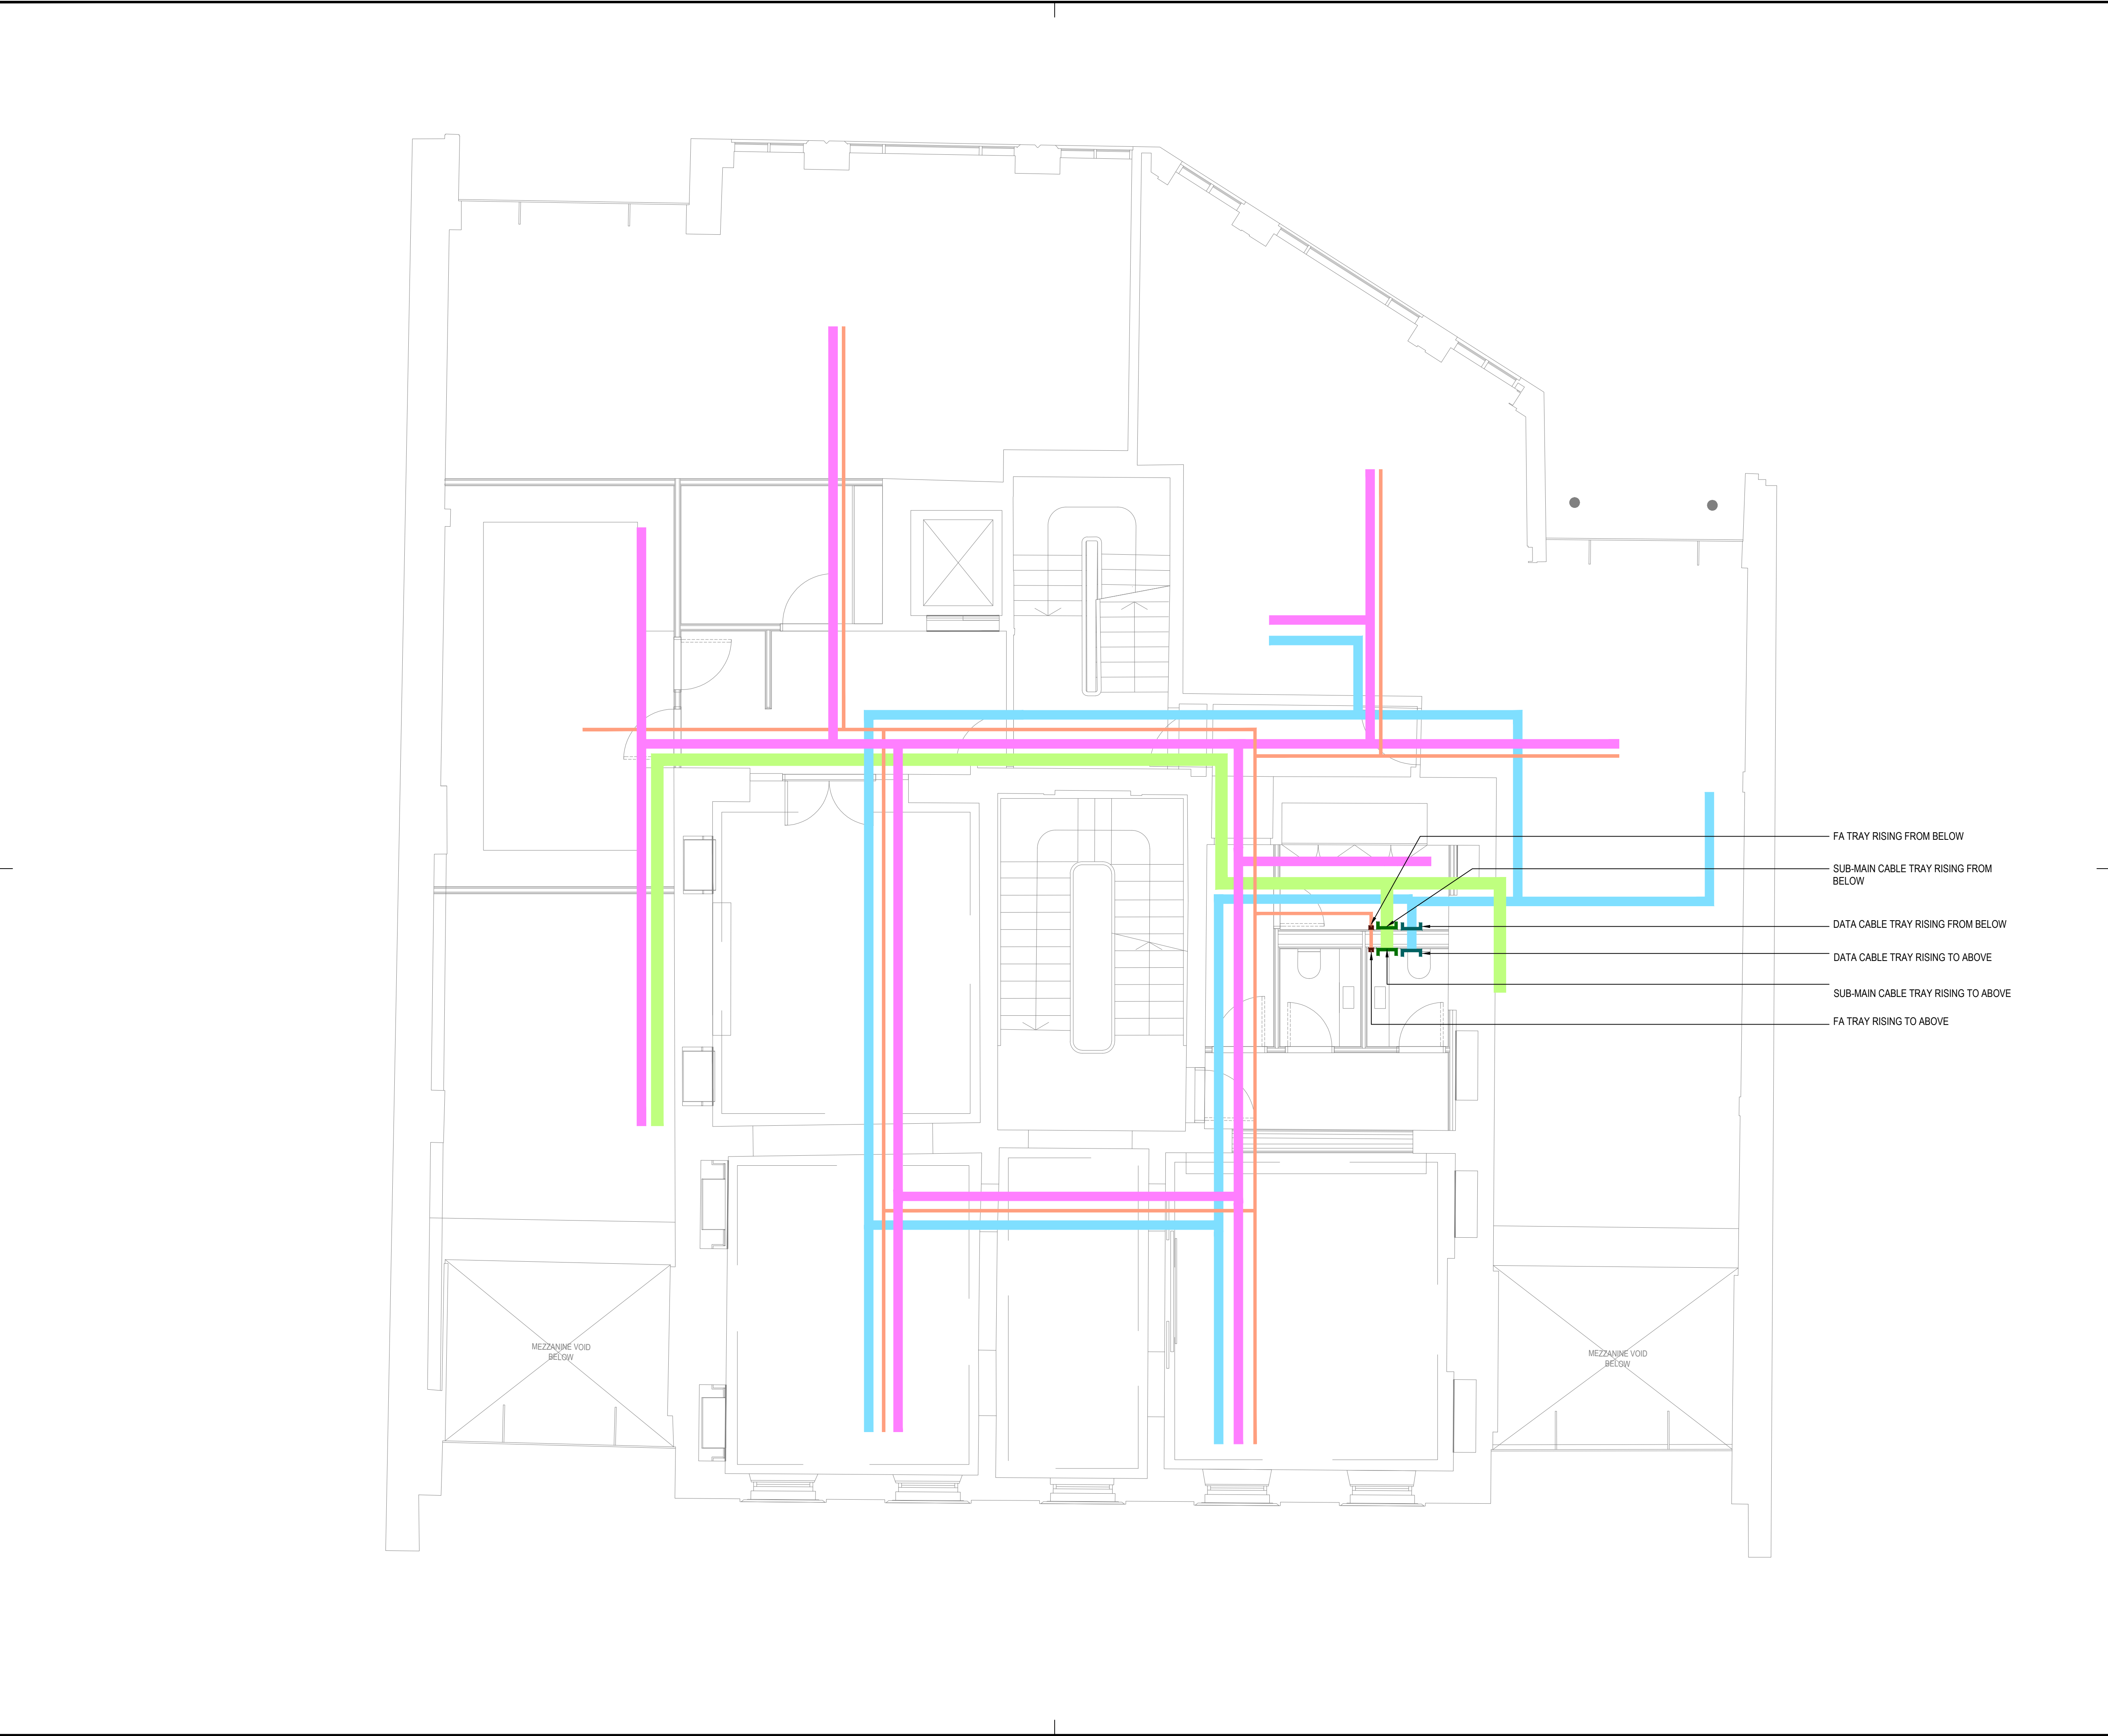

DRAWING BACKGROUND INFO

LEGEND

- HEAVEY DUTY GALVANISED STEEL TRAY FOR SUBMAINS
- GALVANISED BASKET CABLE TRAY FOR LV FINAL CIRCUITS
- GALVANISED BASKET CABLE TRAY FOR DATA & ALARM CABLING
- GALVANISED STEEL CABLE TRAY FOR FIRE ALARM
- SIZE OF CONTAINMENT

PL	30.05.24	DH	PLANNING
Rev	Date	Dnn	Description

Client
WATCHES OF SWITZERLAND GROUP

Architect
JOHNSON PINNEY ARCHITECTS

Project
KINGS STREET, MANCHESTER

FHPESS


London, Bexley, Birmingham, Glasgow, Leeds, Manchester, Waltham Abbey
0808 175 1000 drawings@fhpress.com www.fhpress.com

Drawing Title
ELECTRICAL SERVICES
CONTAINMENT LAYOUT
FIRST FLOOR

Scale	1:50@A1	Drawn	AutoCAD/NS
Date	APR' 2024	Checked	MC

Status
PLANNING

Project number/Drawing number	Revision
44758-E-610-01-100	PL

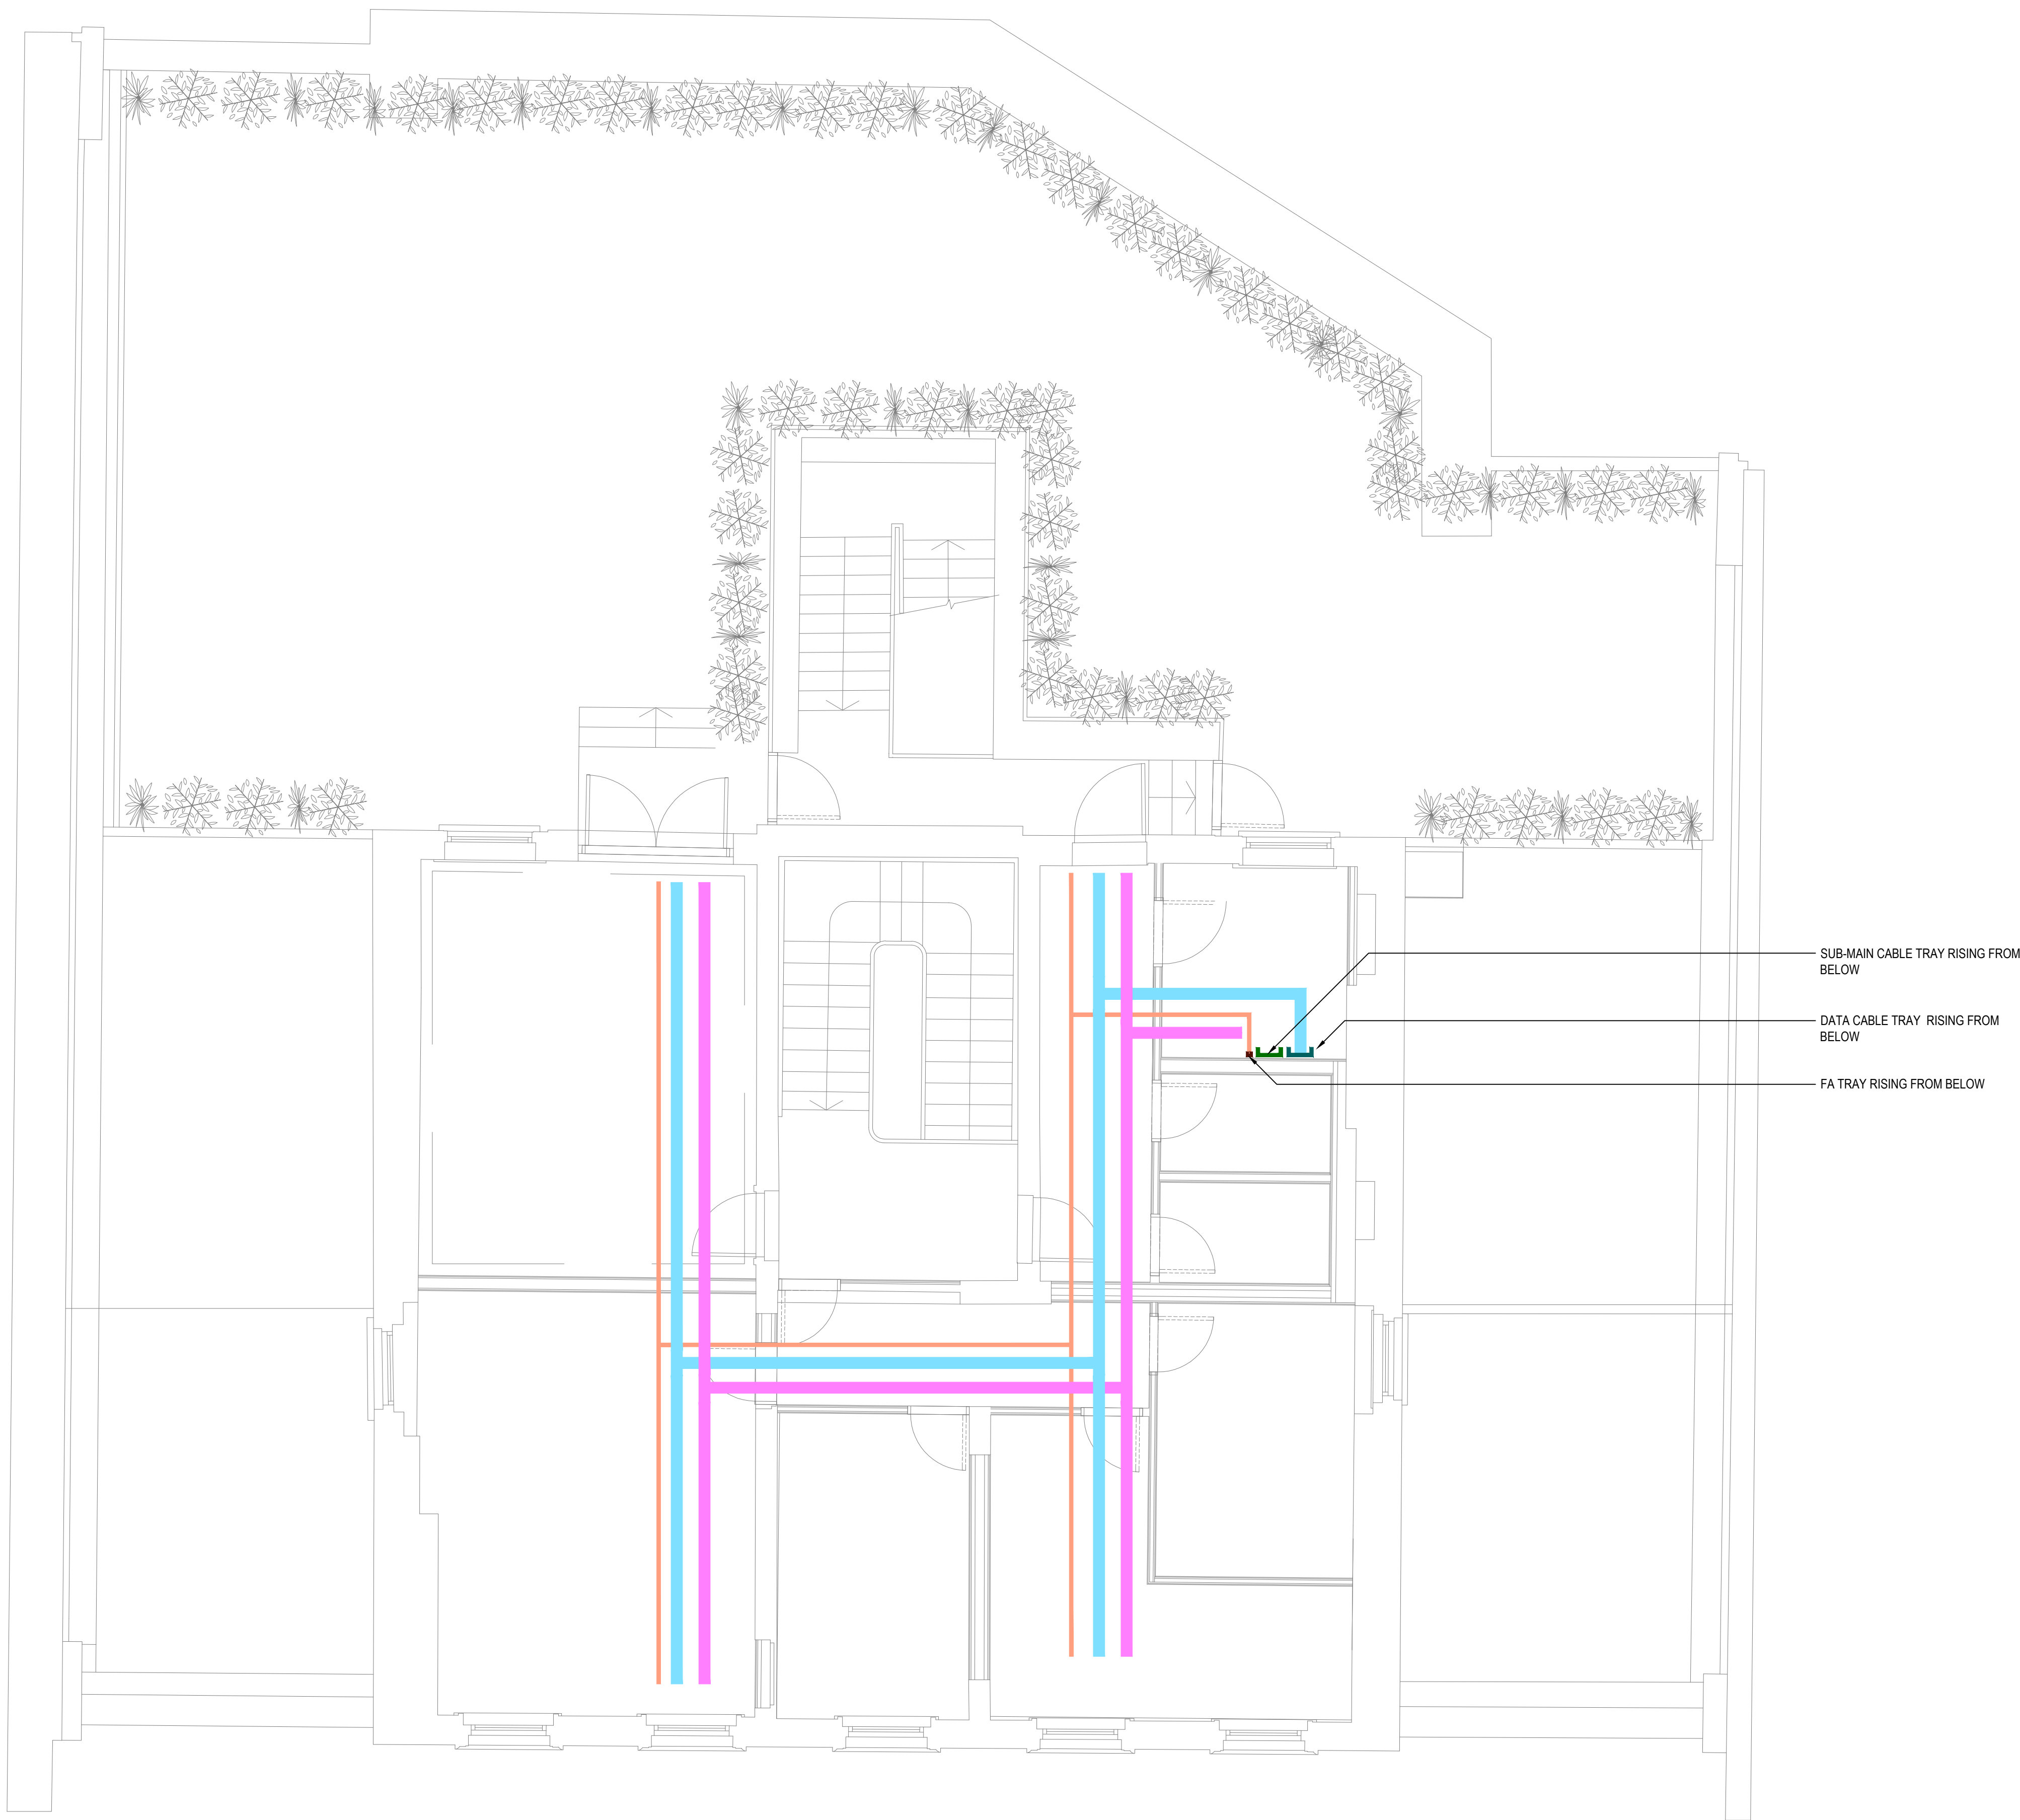

DRAWING BACKGROUND INFO

LEGEND

- HEAVEY DUTY GALVANISED STEEL TRAY FOR SUBMAINS
- GALVANISED BASKET CABLE TRAY FOR LV FINAL CIRCUITS
- GALVANISED BASKET CABLE TRAY FOR DATA & ALARM CABLING
- GALVANISED STEEL CABLE TRAY FOR FIRE ALARM
- SIZE OF CONTAINMENT

PL	30.05.24	DH	PLANNING
Rev	Date	Dnn	Description

Client
WATCHES OF SWITZERLAND GROUP

Architect
JOHNSON PINNEY ARCHITECTS

Project
KINGS STREET, MANCHESTER

FHP  **ESS**


London, Bexley, Birmingham, Glasgow, Leeds, Manchester, Waltham Abbey
0808 175 1000 drawings@fhpress.com www.fhpress.com

Drawing Title
**ELECTRICAL SERVICES
CONTAINMENT LAYOUT
SECOND FLOOR**

Scale	1:50@A1	Drawn	AutoCAD/NS
Date	APR' 2024	Checked	MC

Status
PLANNING

Project number/Drawing number	Revision
44758-E-610-02-100	PL

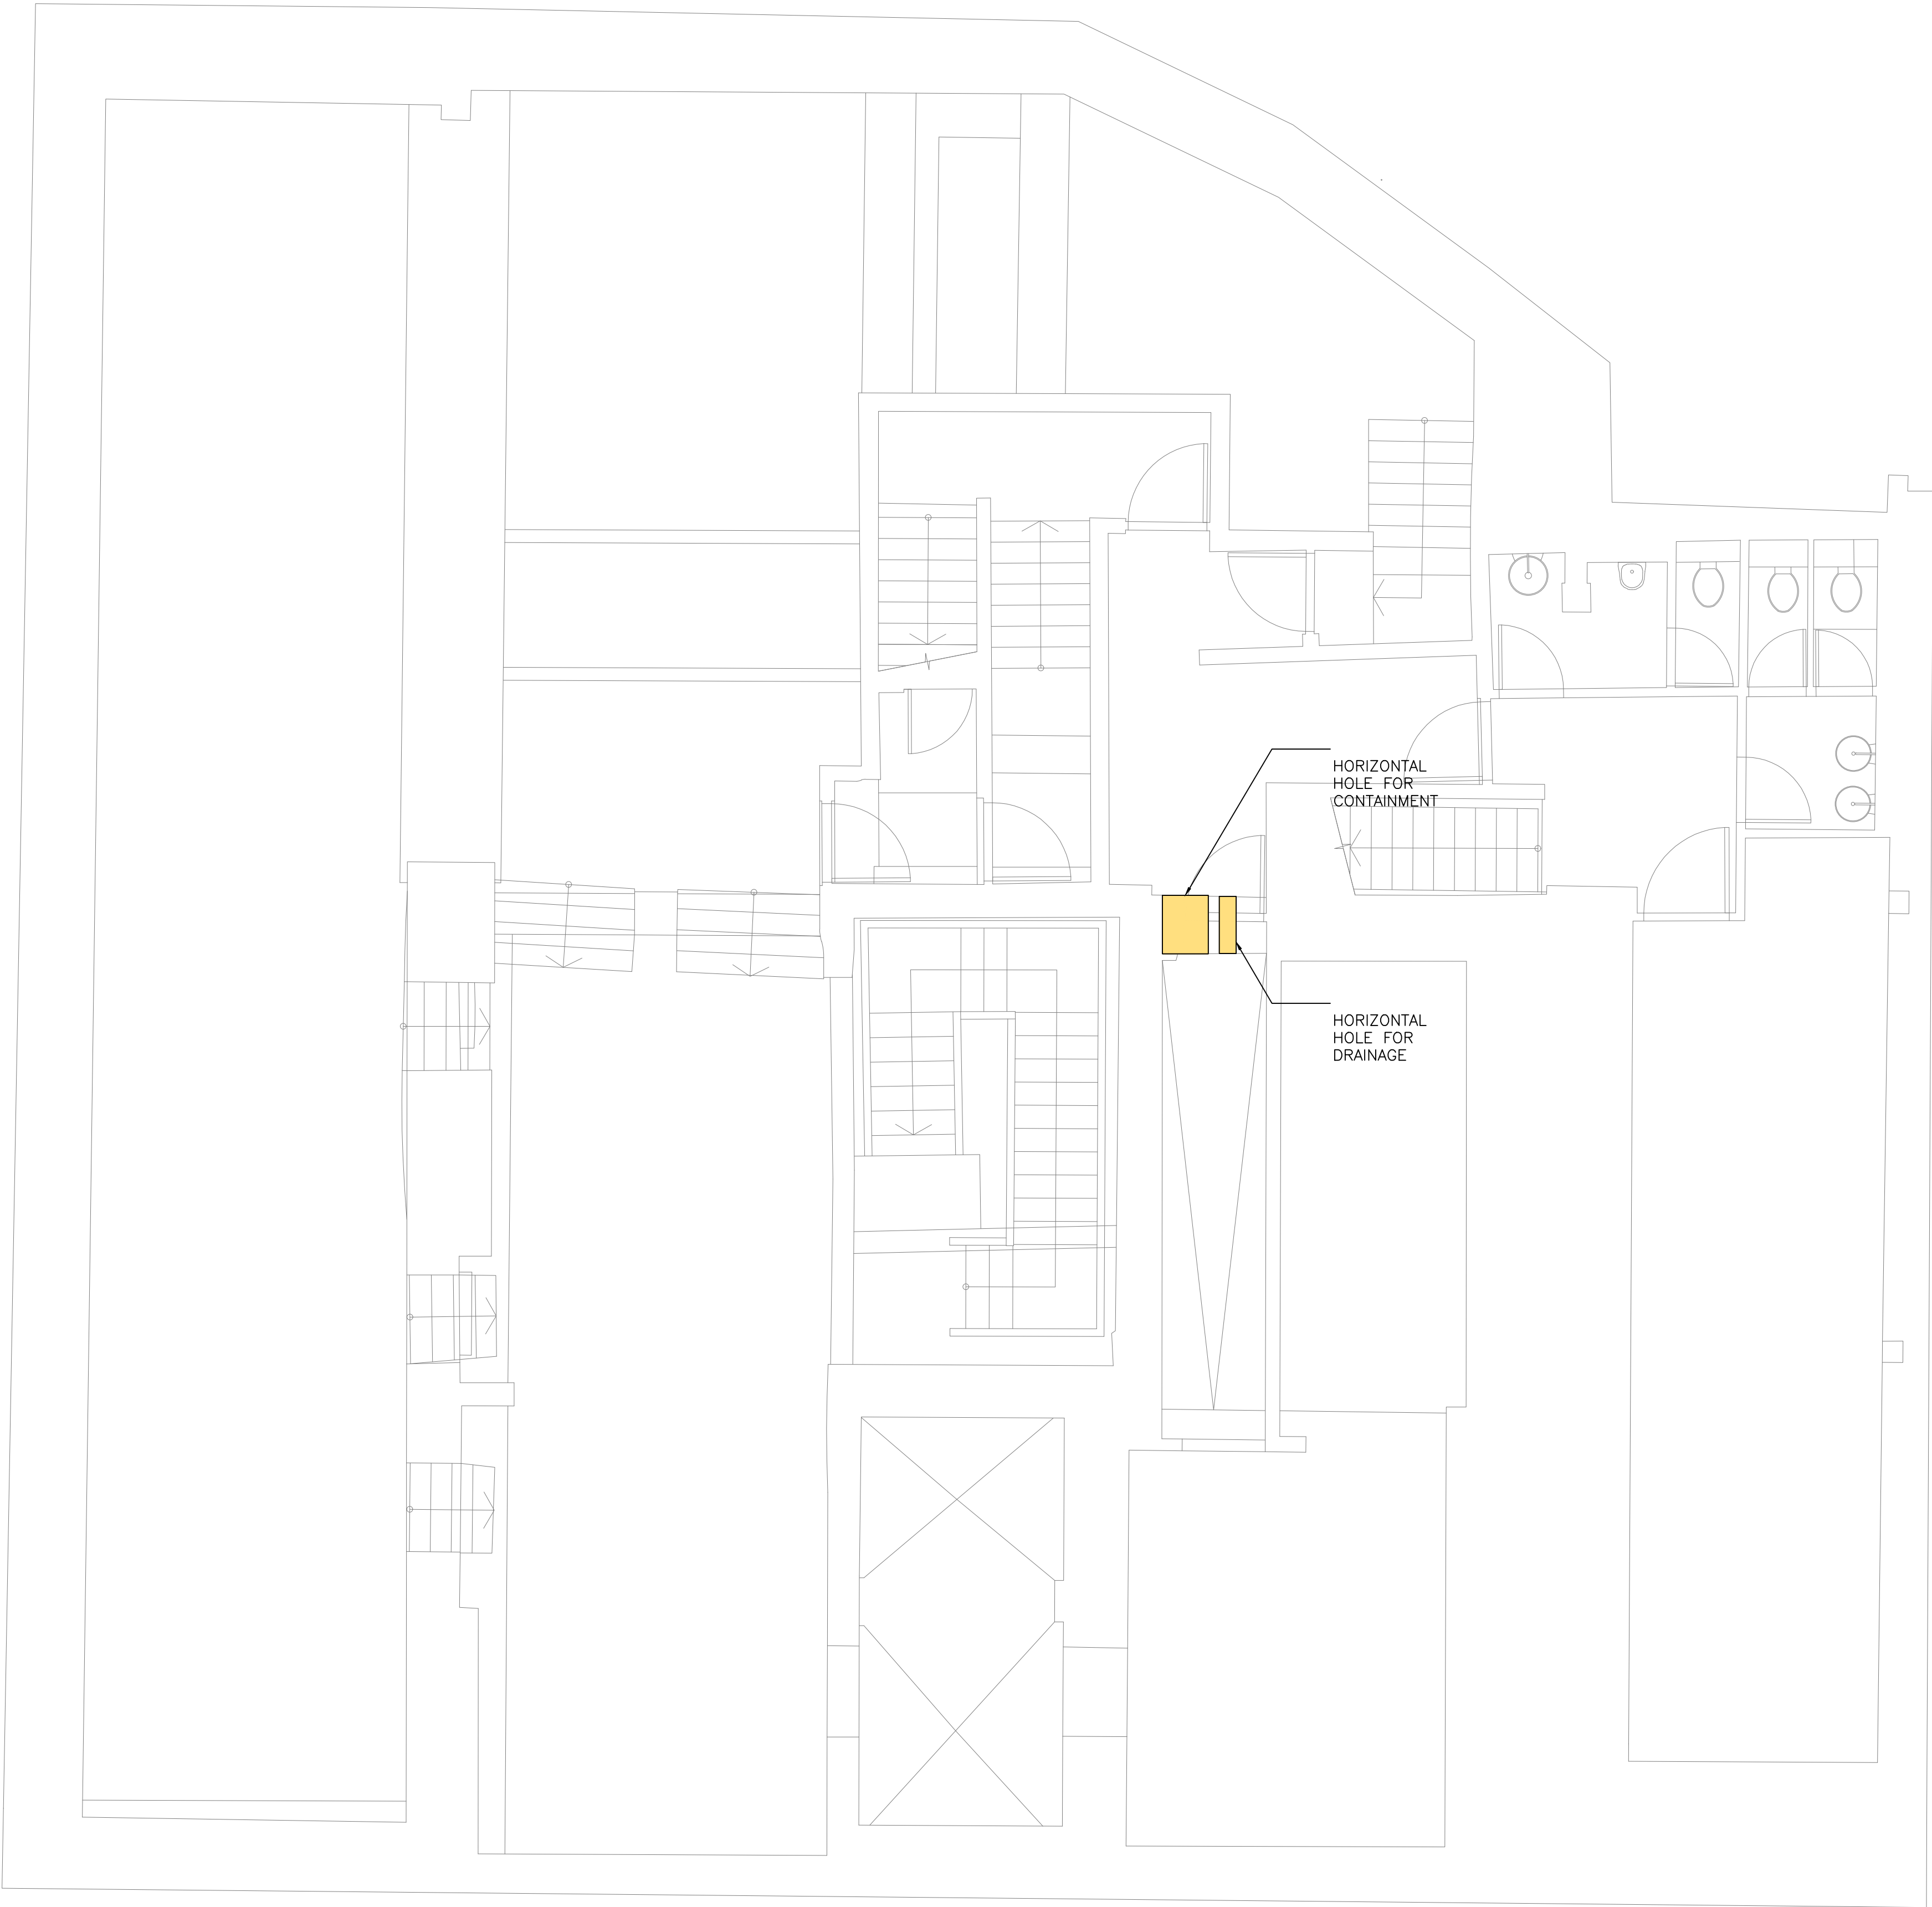

DRAWING BACKGROUND INFO

SERVICES PENETRATIONS

PENETRATIONS SHOWN FOR SERVICES THROUGH WALLS AND FLOORS ARE INDICATIVE ONLY AT THIS STAGE AND AS SUCH ARE SUBJECT TO FINAL CONFIRMATION UPON FURTHER INVESTIGATIVE WORKS OF PROPOSED LOCATIONS

FINAL LOCATIONS AND SIZES ARE TO BE CONFIRMED

PL	30.05.24	DH	PLANNING
----	----------	----	----------

Rev	Date	Dnn	Description
-----	------	-----	-------------

Client
WATCHES OF SWITZERLAND GROUP

Architect
JOHNSON PINNEY ARCHITECTS

Project
KINGS STREET, MANCHESTER

FHP**ESS**

London, Bexley, Birmingham, Glasgow, Leeds, Manchester, Waltham Abbey

 0808 175 1000  drawings@fhpress.com  www.fhpress.com

Drawing Title


COMBINED SERVICES
SERVICES PENETRATIONS
BASEMENT

Scale	1:50@A1	Drawn	AutoCAD/NS
Date	APR' 2024	Checked	MC

Status

PLANNING

Project number/Drawing number	Revision
	PL

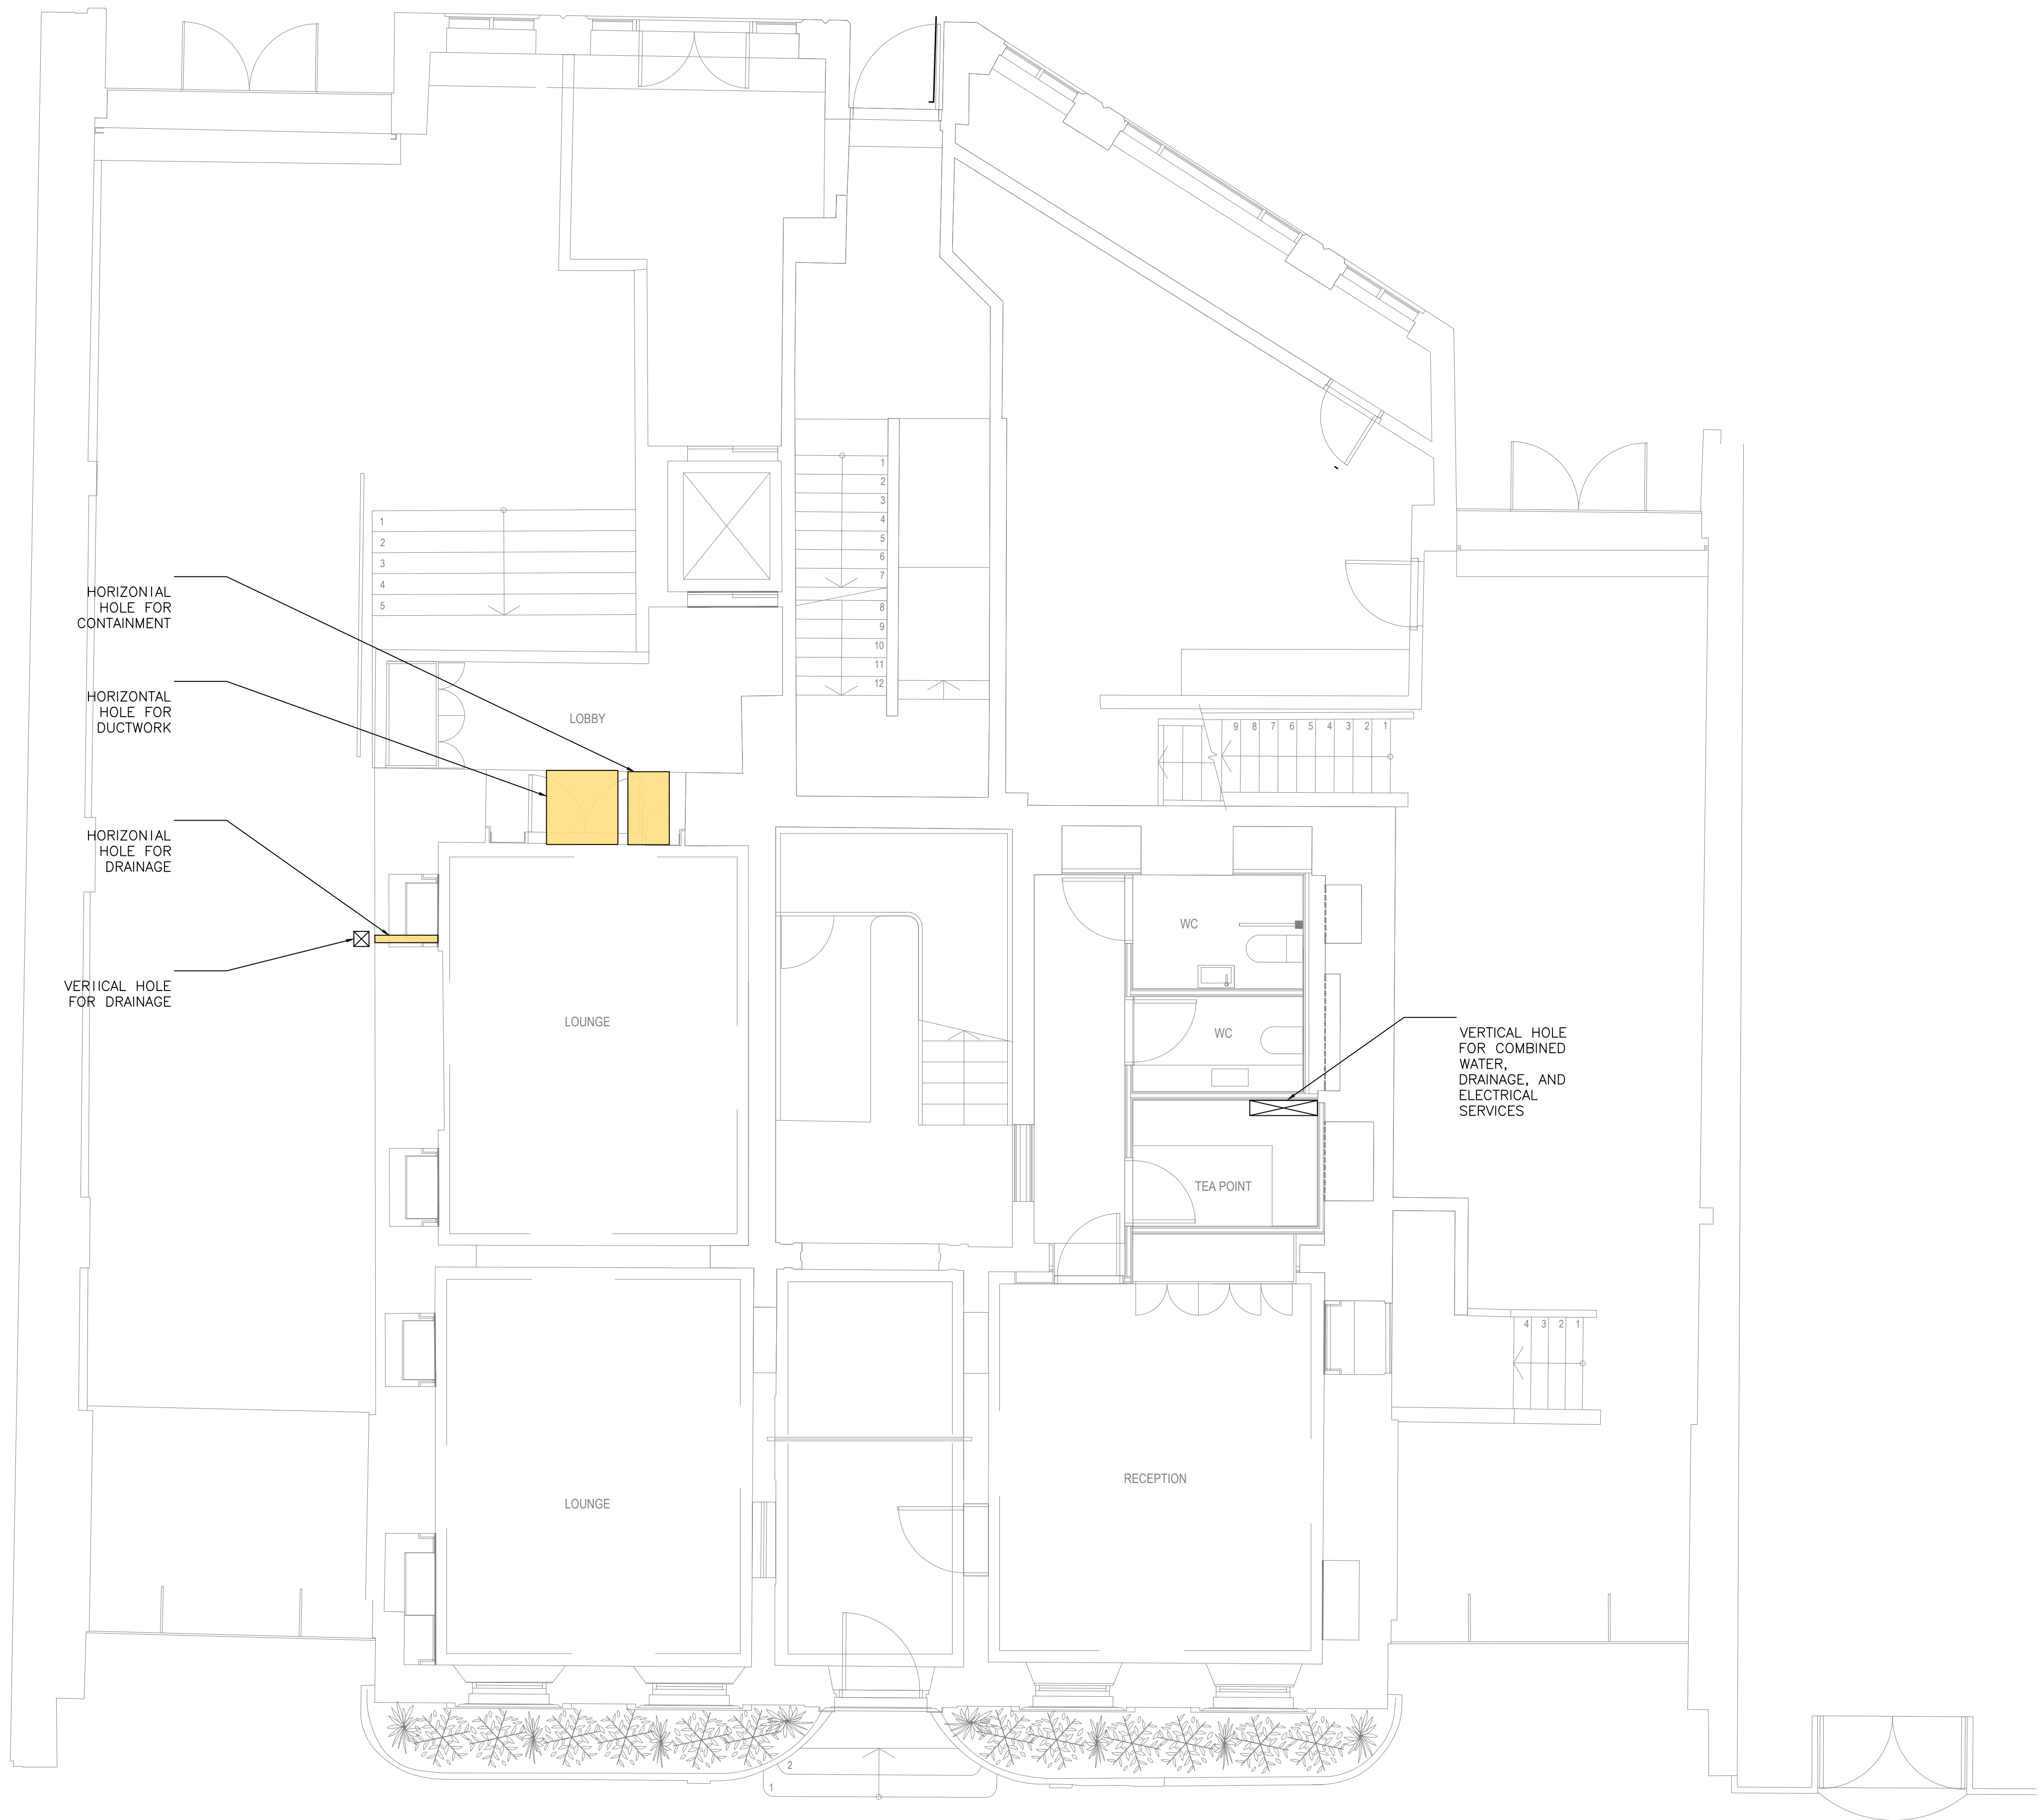

DRAWING BACKGROUND INFO

SERVICES PENETRATIONS

PENETRATIONS SHOWN FOR SERVICES THROUGH WALLS AND FLOORS ARE INDICATIVE ONLY AT THIS STAGE AND AS SUCH ARE SUBJECT TO FINAL CONFIRMATION UPON FURTHER INVESTIGATIVE WORKS OF THE PROPOSED LOCATIONS

PL 30.05.24 DH PLANNING

Rev Date Drn Description

Client
WATCHES OF SWITZERLAND GROUP

Architect
JOHNSON PINNEY ARCHITECTS

Project
KINGS STREET, MANCHESTER

FHP  **ESS**

London, Bexley, Birmingham, Glasgow, Leeds, Manchester, Waltham Abbey
0808 175 1000 drawings@fhpress.com www.fhpress.com


Drawing Title
**COMBINED SERVICES
SERVICES PENETRATIONS LAYOUT
GROUND FLOOR**

Scale 1:50@A1 Drawn AutoCAD/NS

Date APR' 2024 Checked MC

Status
PLANNING

Project number/Drawing number Revision
PL

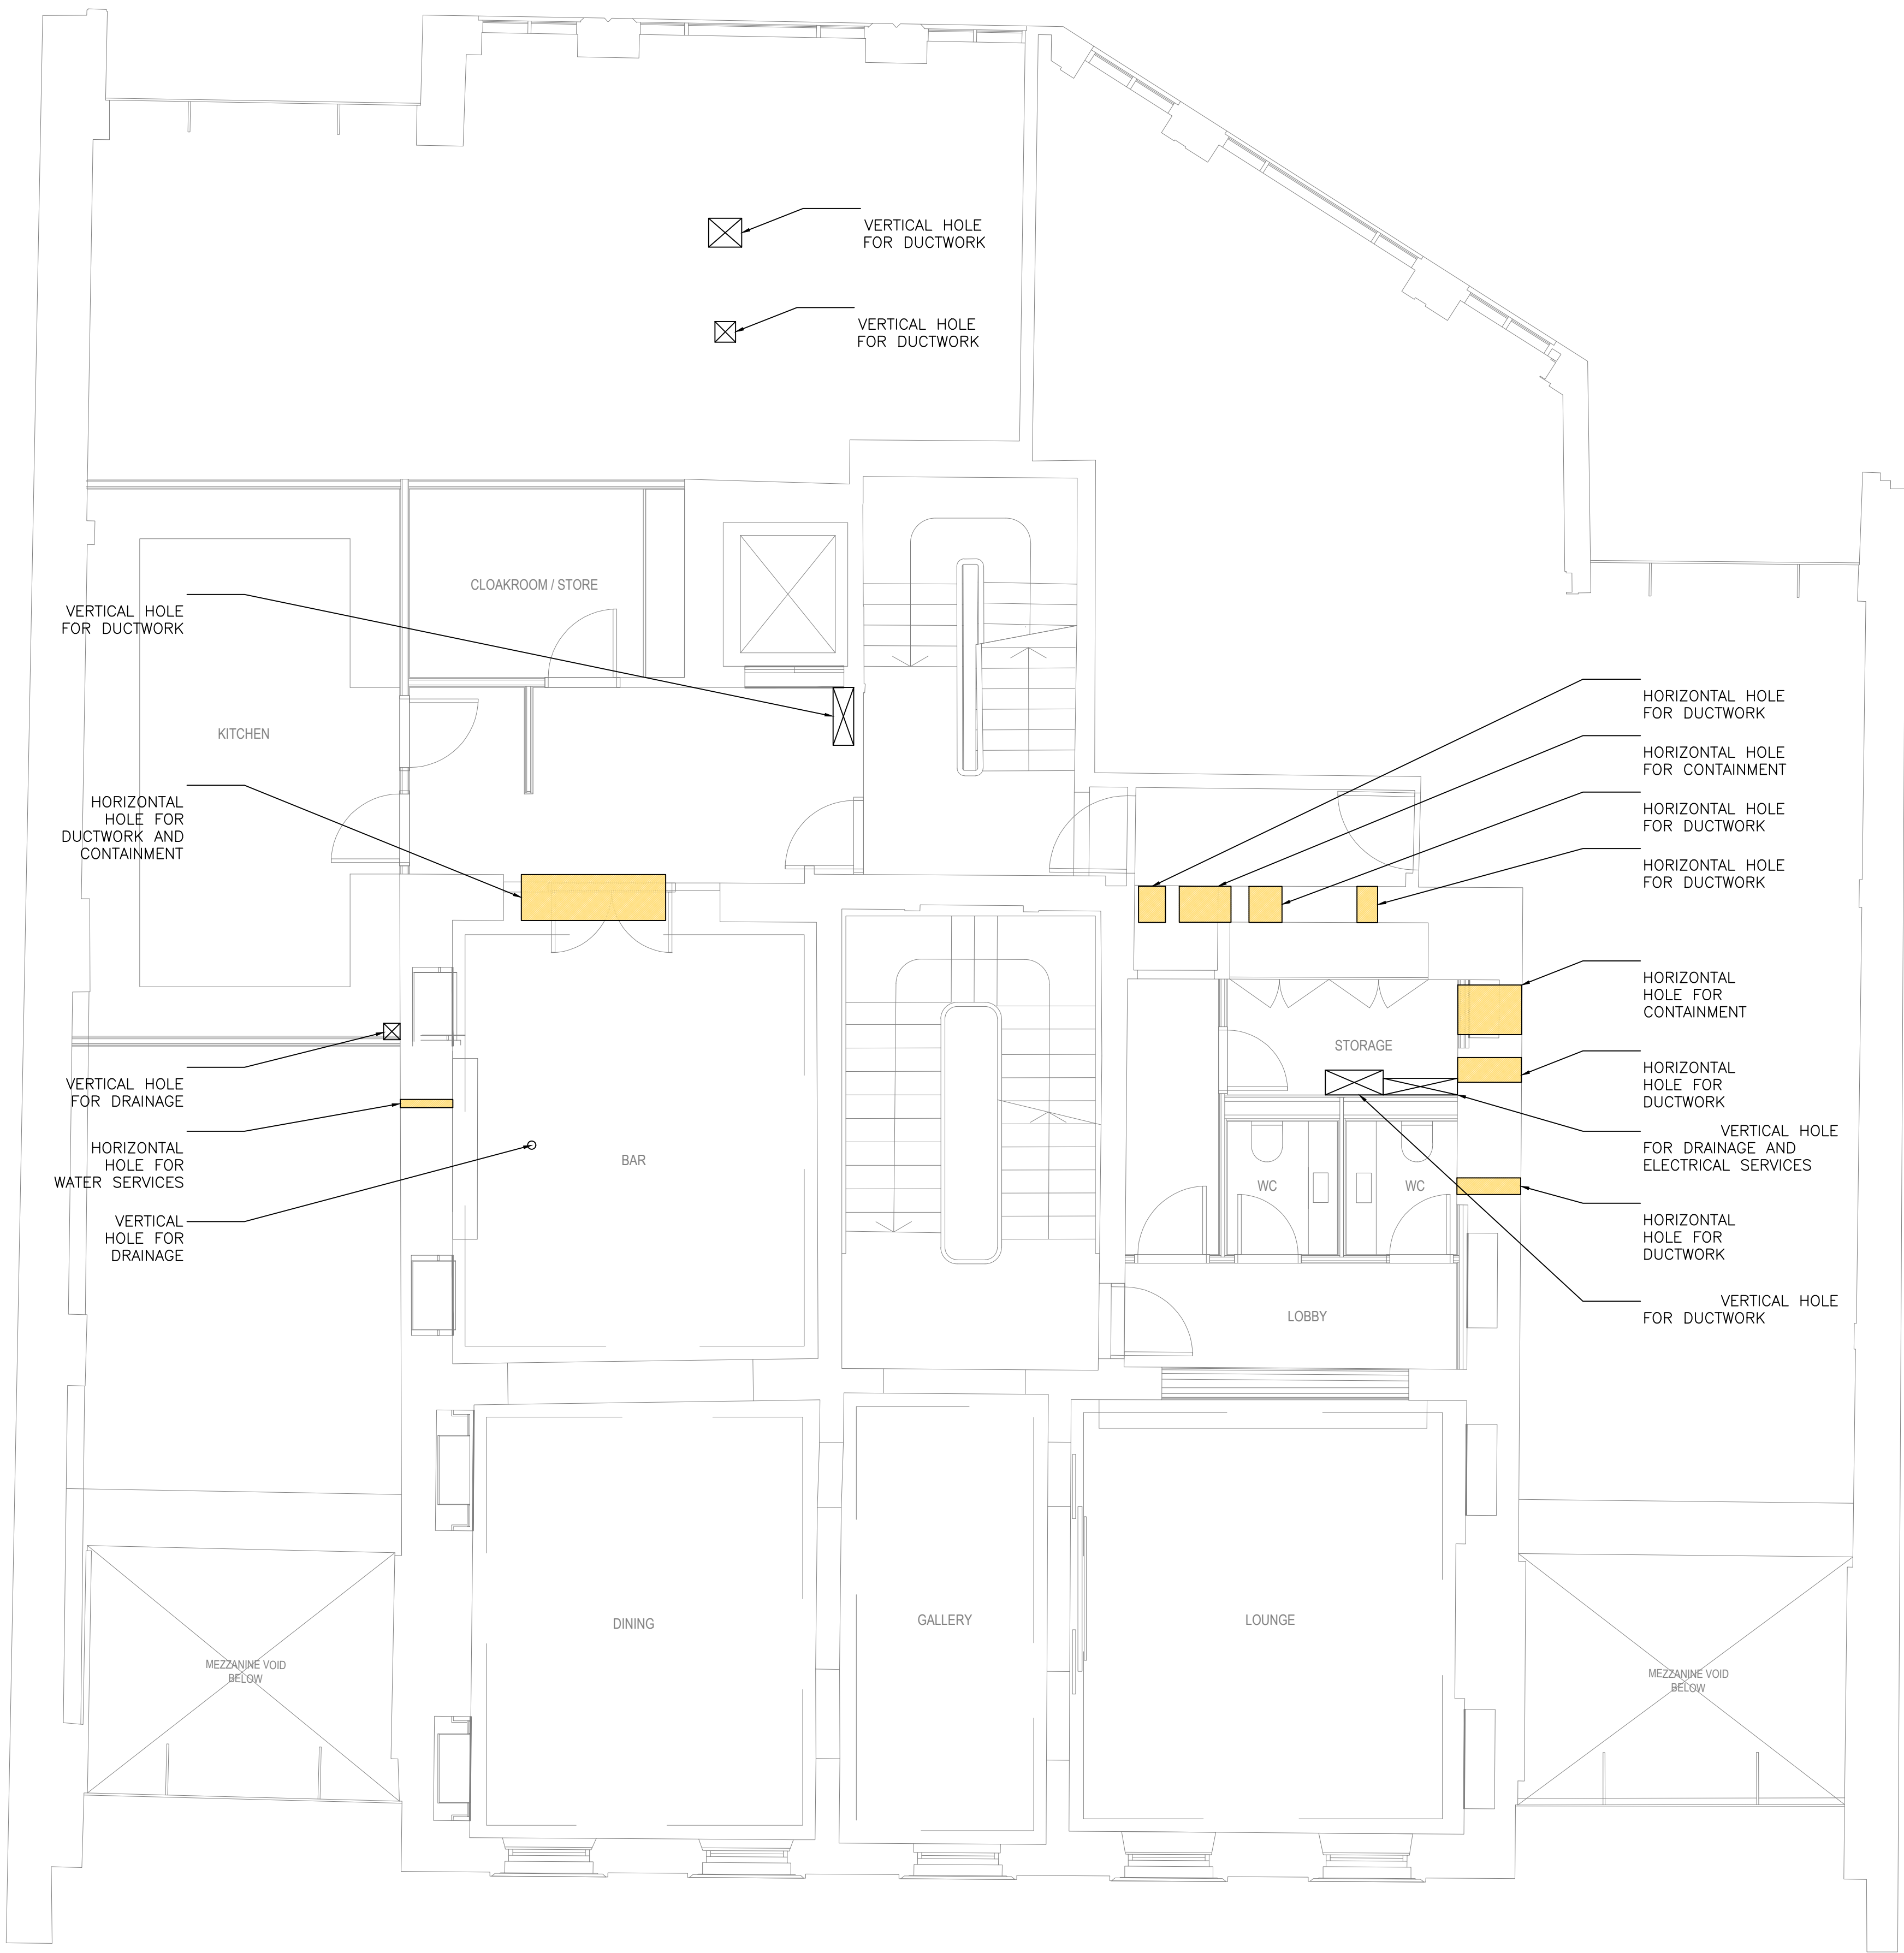

DRAWING BACKGROUND INFO

SERVICES PENETRATIONS

PENETRATIONS SHOWN FOR SERVICES THROUGH WALLS AND FLOORS ARE INDICATIVE ONLY AT THIS STAGE AND AS SUCH ARE SUBJECT TO FINAL CONFIRMATION UPON FURTHER INVESTIGATIVE WORKS OF THE PROPOSED LOCATIONS


PL	30.05.24	DH	PLANNING
----	----------	----	----------

Rev	Date	Drn	Description
-----	------	-----	-------------

Client
WATCHES OF SWITZERLAND GROUP

Architect
JOHNSON PINNEY ARCHITECTS

Project
KINGS STREET, MANCHESTER

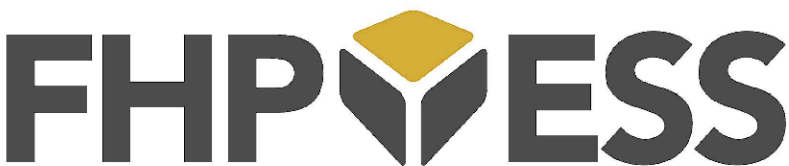

London, Bexley, Birmingham, Glasgow, Leeds, Manchester, Waltham Abbey
0808 175 1000 drawings@fhpress.com www.fhpress.com


Drawing Title
COMBINED SERVICES
SERVICES PENETRATIONS LAYOUT
FIRST FLOOR

Scale	1:50@A1	Drawn	AutoCAD/NS
-------	---------	-------	------------

Date	APR' 2024	Checked	MC
------	-----------	---------	----

Status
PLANNING

Project number/Drawing number	Revision PL
-------------------------------	----------------

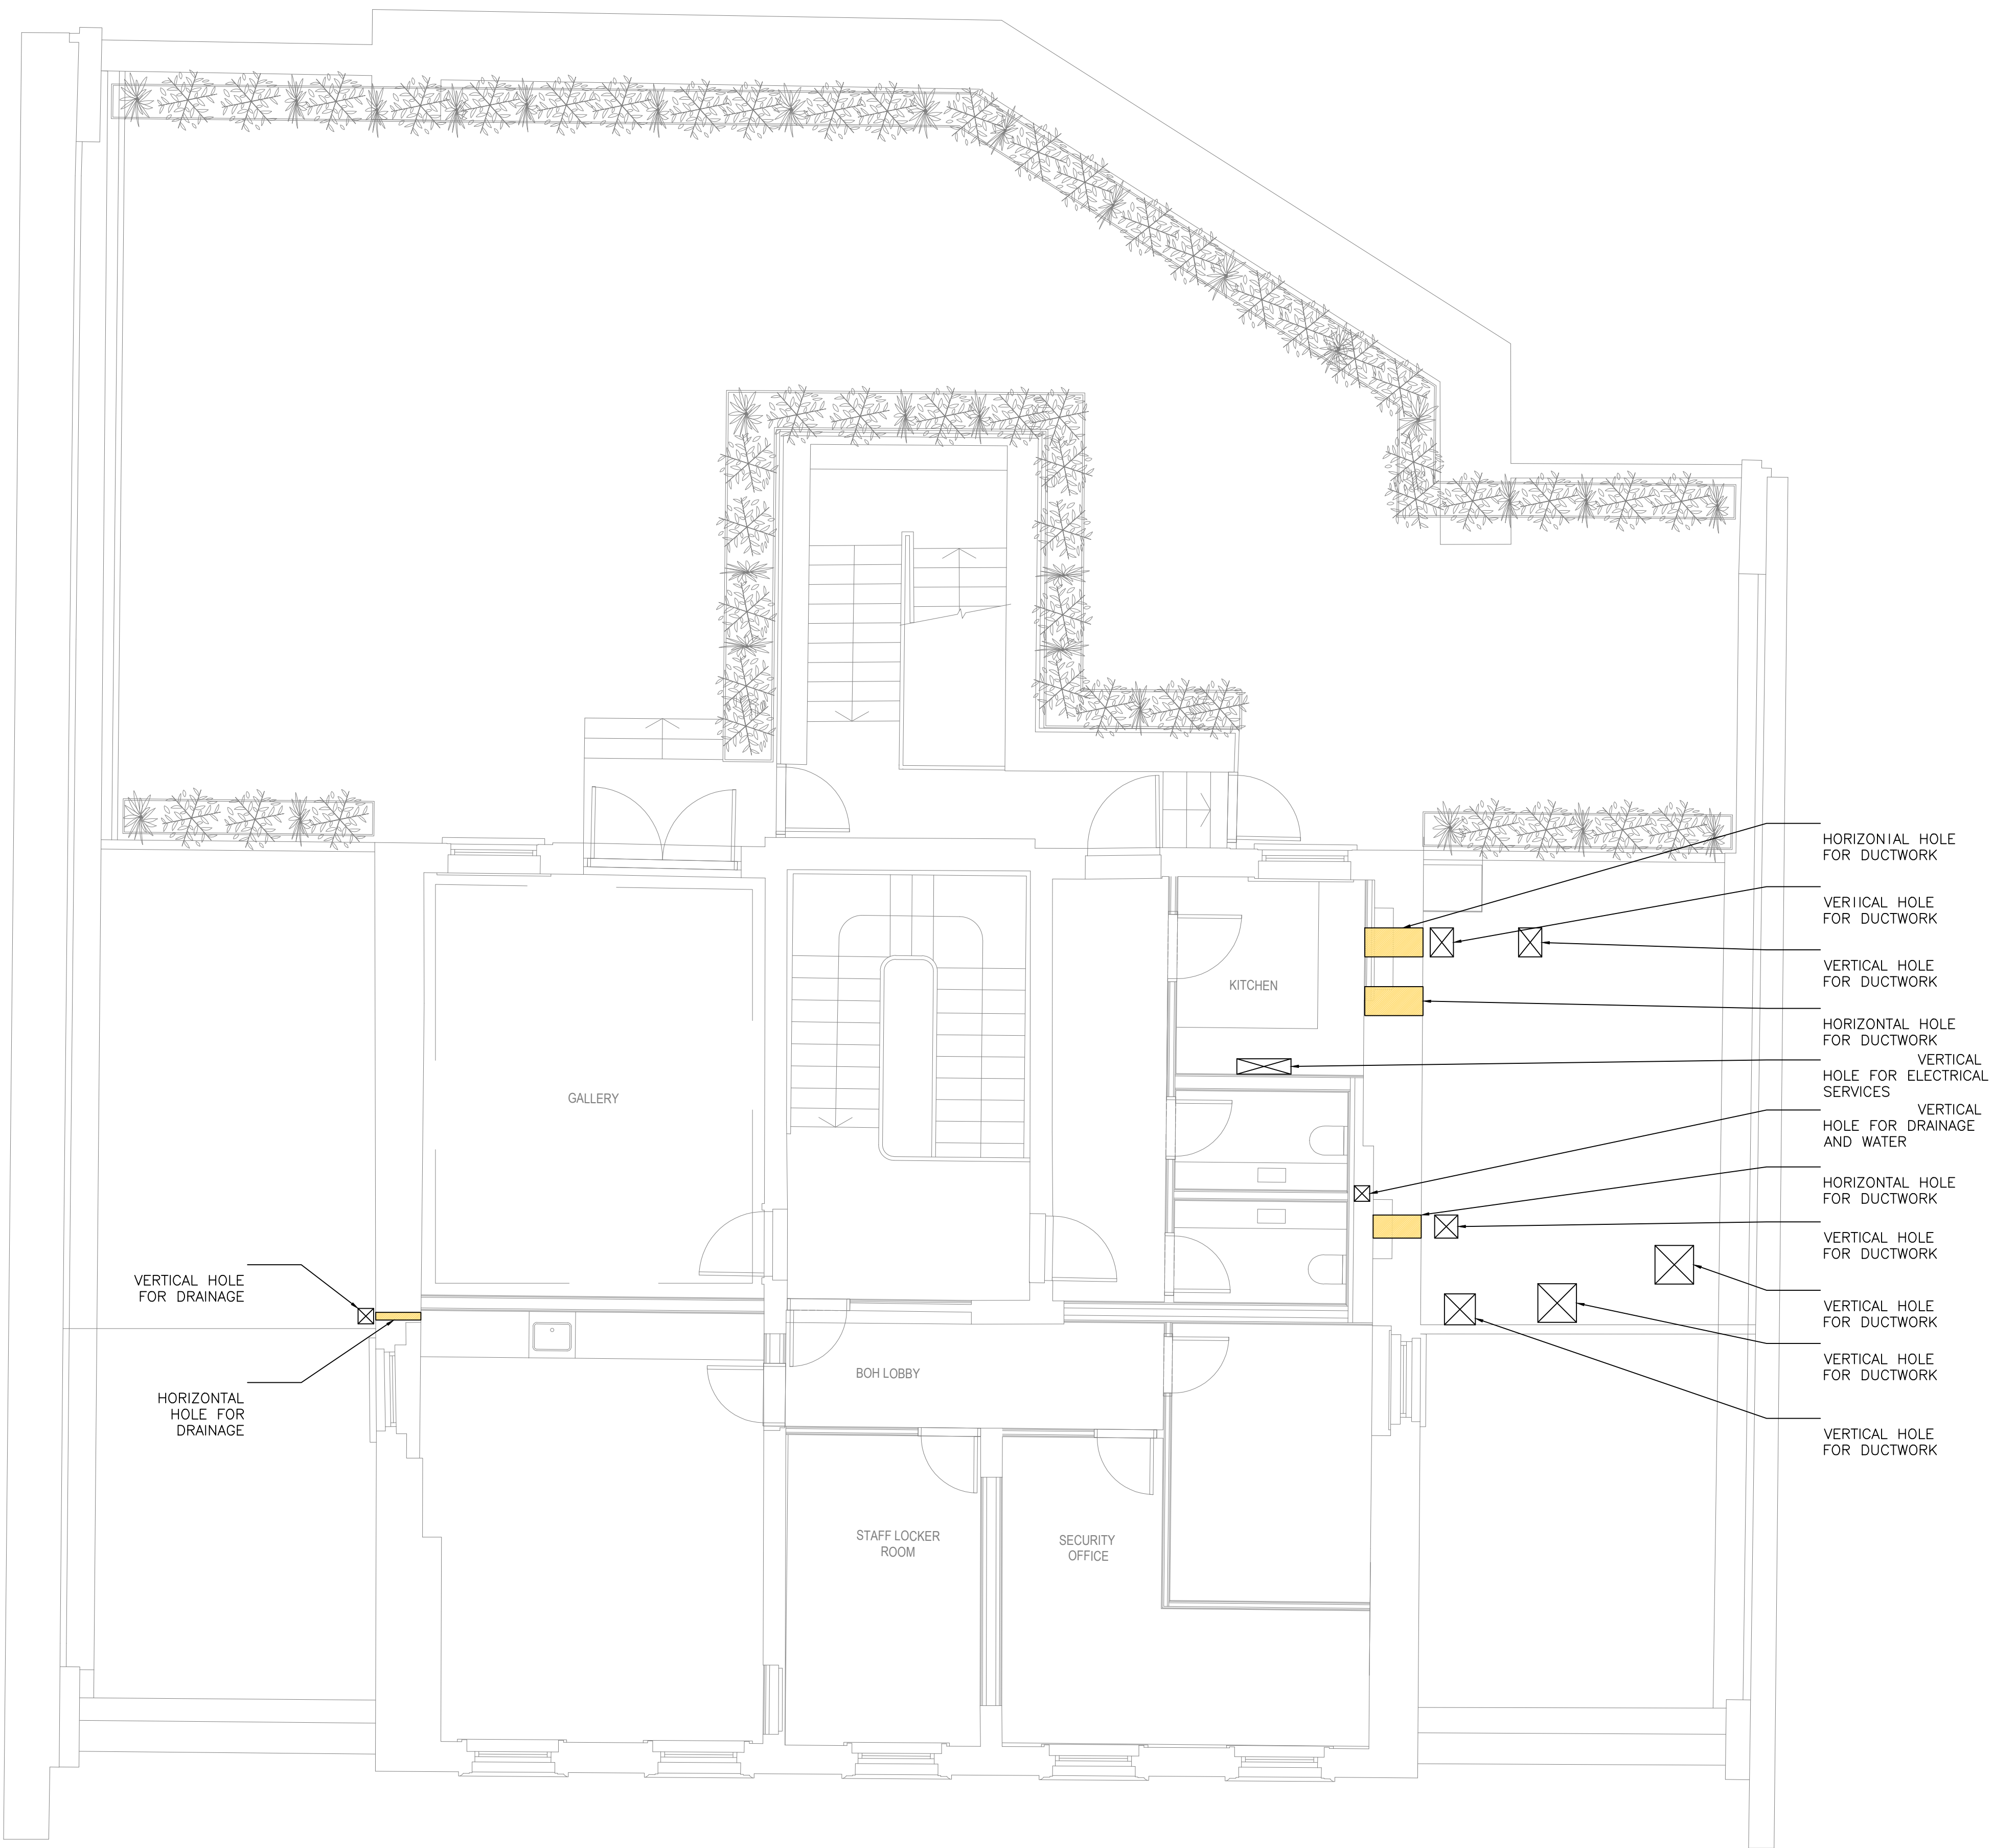

DRAWING BACKGROUND INFO

SERVICES PENETRATIONS

PENETRATIONS SHOWN FOR SERVICES THROUGH WALLS AND FLOORS ARE INDICATIVE ONLY AT THIS STAGE AND AS SUCH ARE SUBJECT TO FINAL CONFIRMATION UPON FURTHER INVESTIGATIVE WORKS OF THE PROPOSED LOCATIONS

PL	30.05.24	DH	PLANNING
Rev	Date	Dnn	Description

Client
WATCHES OF SWITZERLAND GROUP

Architect
JOHNSON PINNEY ARCHITECTS

Project
KINGS STREET, MANCHESTER

FHP
ESS


London, Bexley, Birmingham, Glasgow, Leeds, Manchester, Waltham Abbey
0808 175 1000 drawings@fhpress.com www.fhpress.com

Drawing Title
COMBINED SERVICES
SERVICES PENETRATIONS LAYOUT
SECOND FLOOR

Scale	1:50@A1	Drawn	AutoCAD/NS
Date	APR' 2024	Checked	MC

Status
PLANNING

Project number/Drawing number	Revision PL
-------------------------------	----------------

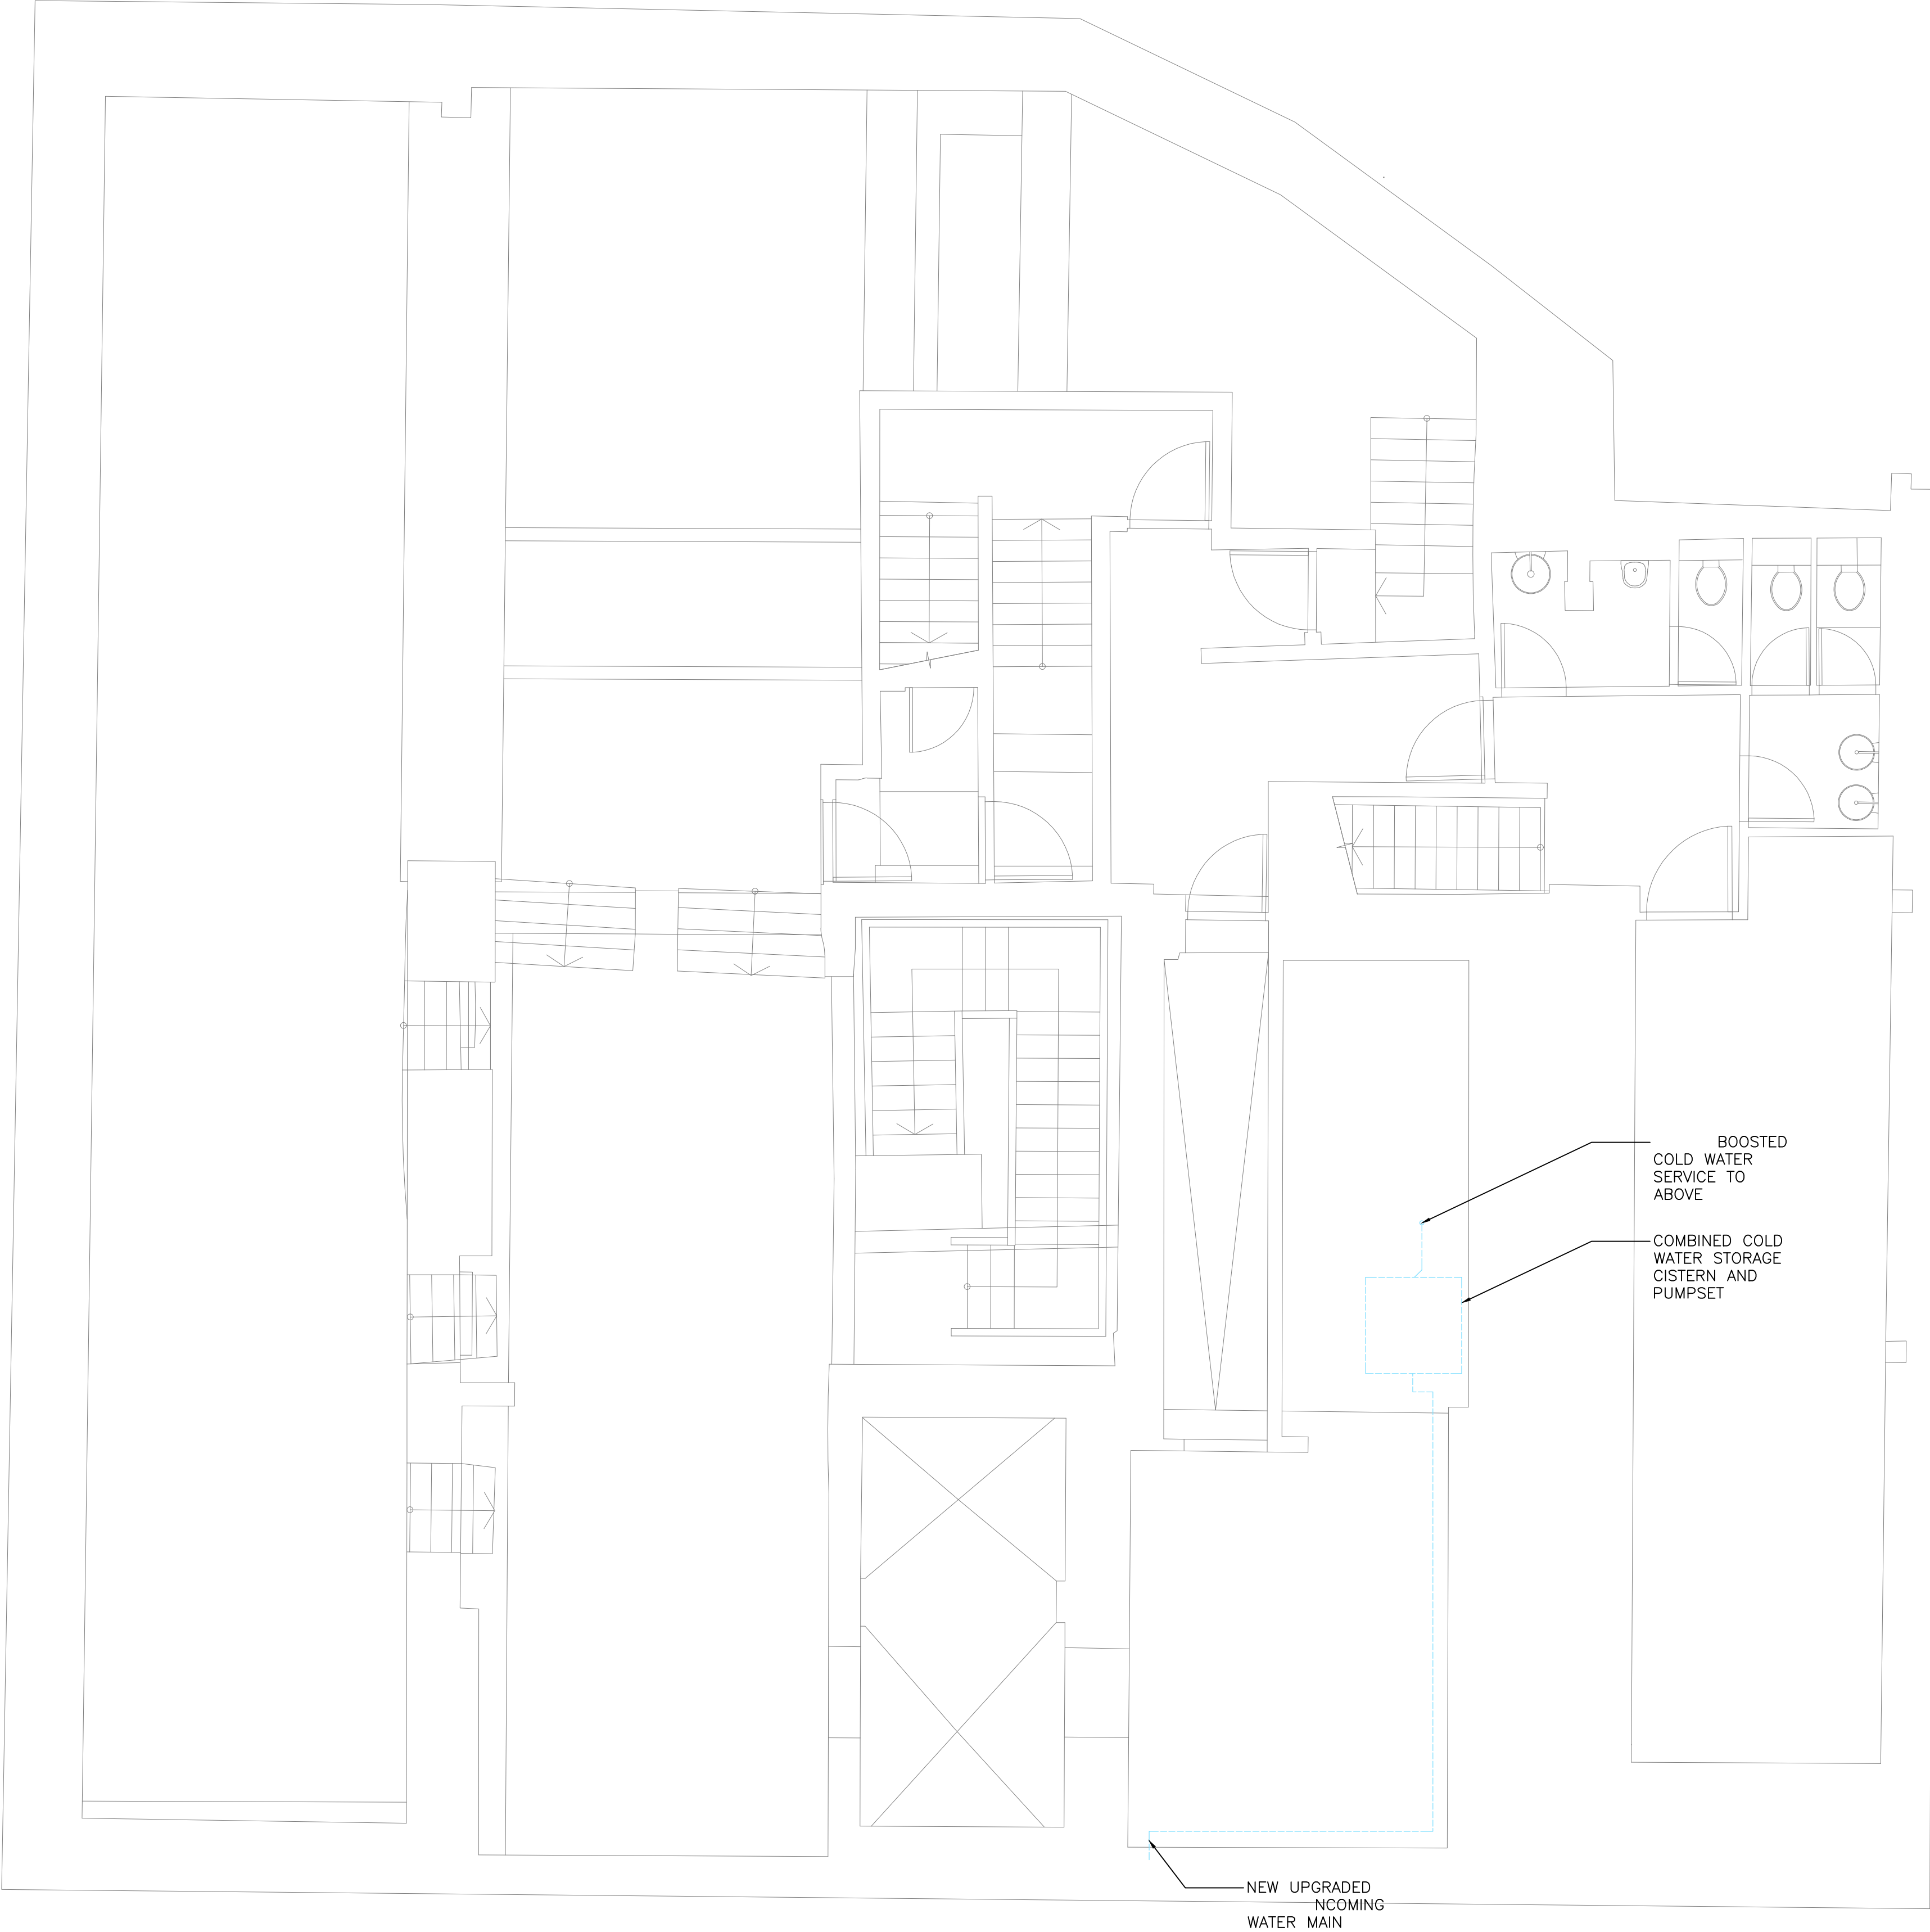

DRAWING BACKGROUND INFO

PL 30.05.24 DH PLANNING

Rev	Date	Drn	Description
-----	------	-----	-------------

Client
WATCHES OF SWITZERLAND GROUP
Architect
JOHNSON PINNEY ARCHITECT
Project
KINGS STREET, MANCHESTER


FHP**ESS**

London, Bexley, Birmingham, Glasgow, Leeds, Manchester, Waltham Abbey
☎ 0808 175 1000 ✉ drawings@fhpress.com 🌐 www.fhpress.com

Drawing Title	
PUBLIC HEALTH SERVICES DOMESTIC WATER SERVICES LAYOUT BASEMENT	
Scale 1:50@A1	Drawn AutoCAD/
Date FEB '24	Checked D.H

Status
PLANNING

Project number/Drawing number	Revision
44758-P-530-B1-100	PL

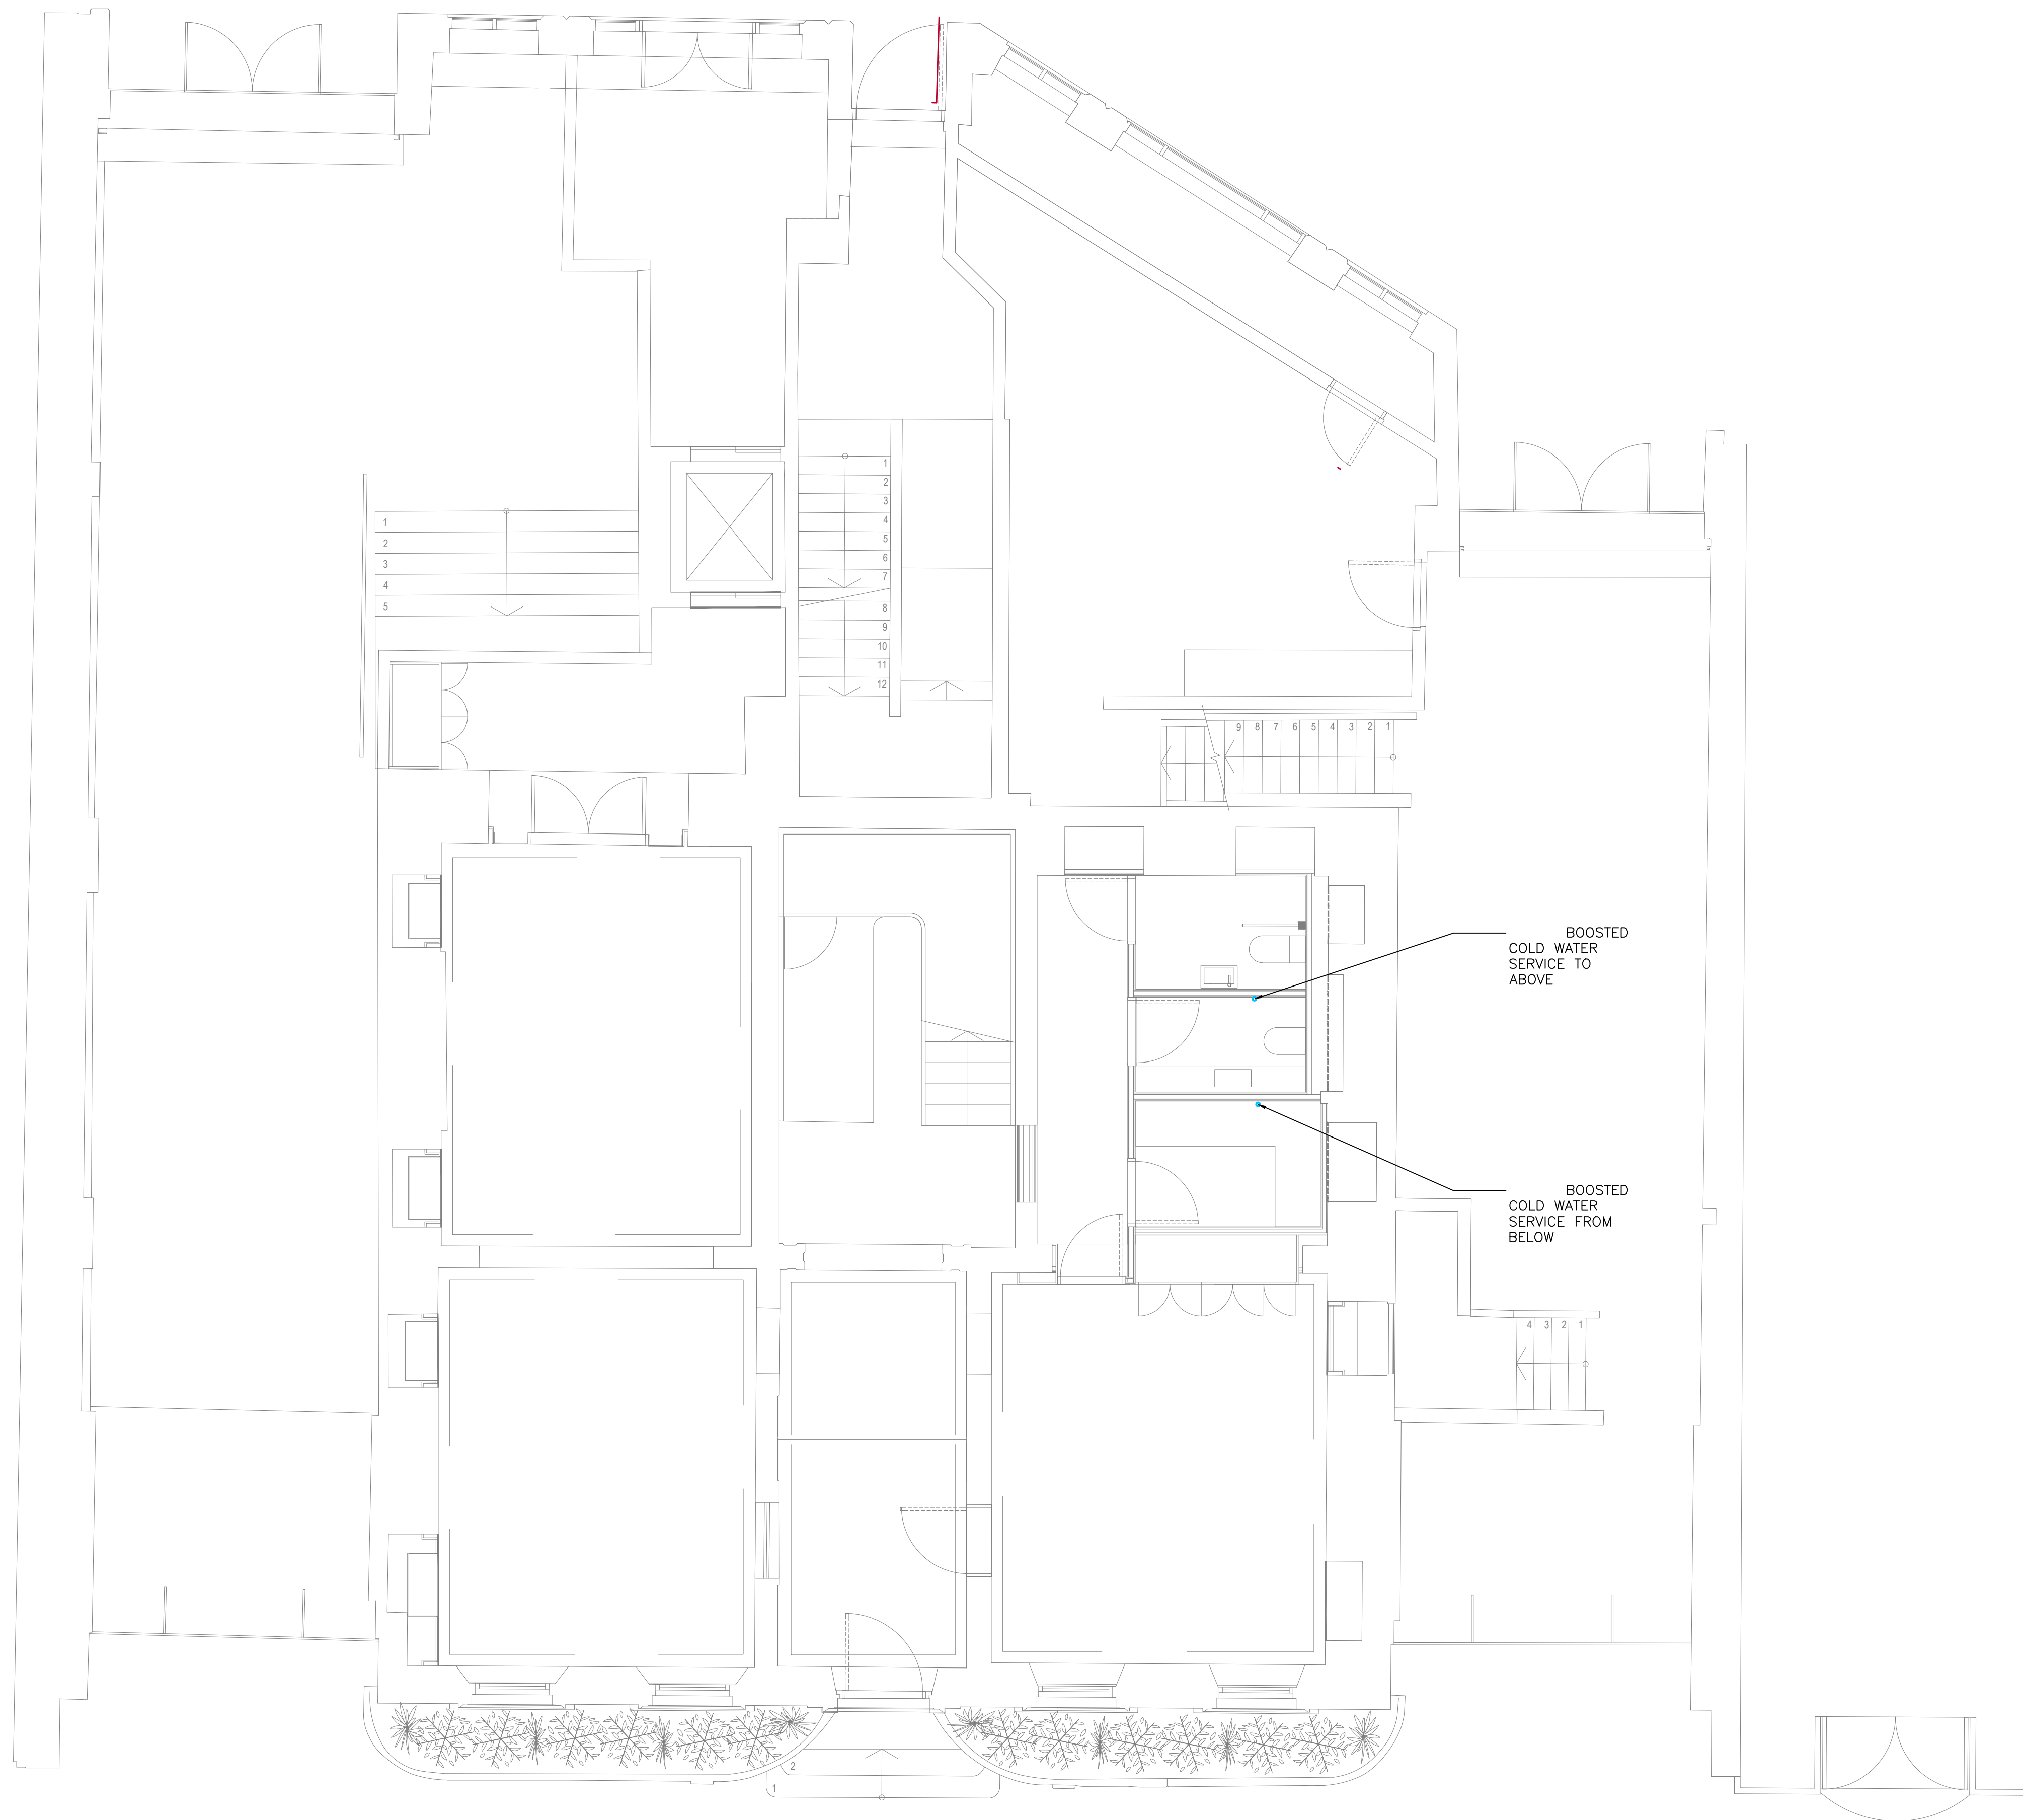

DRAWING BACKGROUND INFO

PL 30.05.24 DH PLANNING

Rev	Date	Drn	Description
-----	------	-----	-------------

Client
WATCHES OF SWITZERLAND GROUP

Architect
JOHNSON PINNEY ARCHITECTS

Project
KINGS STREET, MANCHESTER

FHP **ESS**


London, Bexley, Birmingham, Glasgow, Leeds, Manchester, Waltham Abbey
0808 175 1000 drawings@fhpress.com www.fhpress.com

Drawing Title
PUBLIC HEALTH SERVICES
DOMESTIC WATER SERVICES LAYOUT
GROUND FLOOR

Scale	1:50@A1	Drawn	AutoCAD/
Date	FEB '24	Checked	D.H

Status
PLANNING

Project number/Drawing number	Revision
44758-P-530-00-100	PL

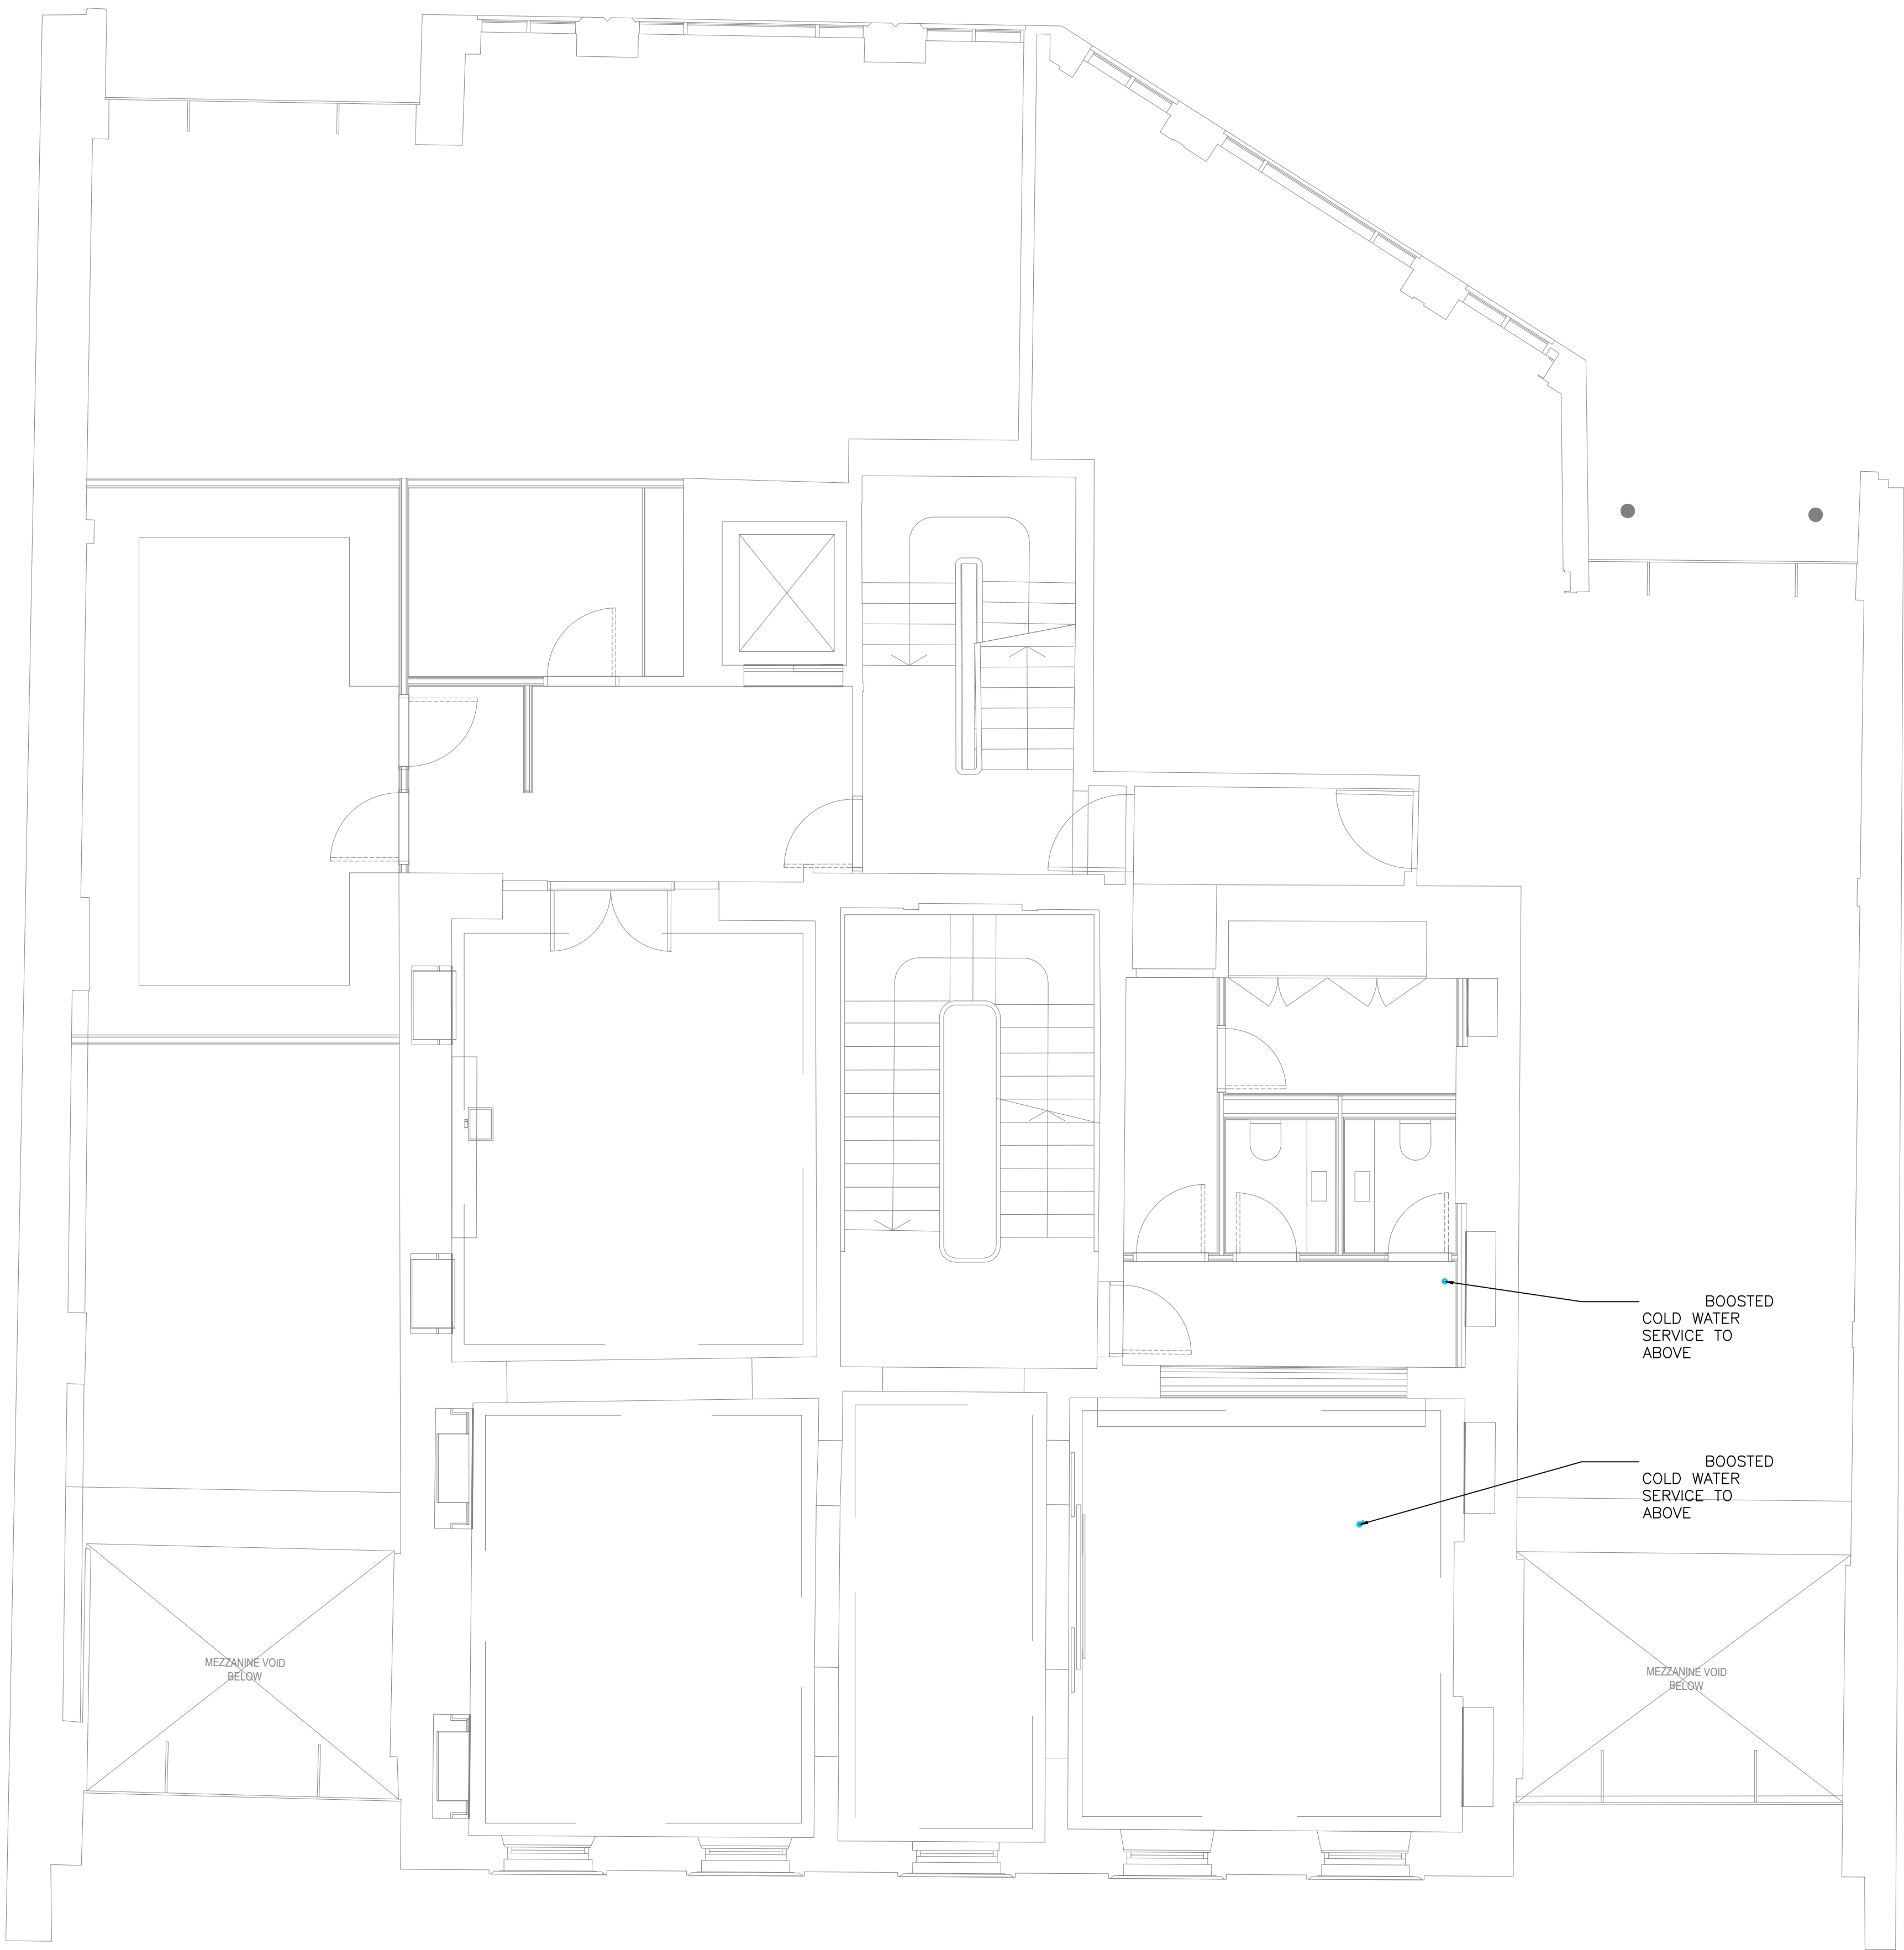

DRAWING BACKGROUND INFO

PL 30.05.24 DH PLANNING

Rev	Date	Drn	Description
-----	------	-----	-------------

Client	WATCHES OF SWITZERLAND GROUP
Architect	JOHNSON PINNEY ARCHITECTS
Project	KINGS STREET, MANCHESTER

FHP **ESS**

London, Bexley, Birmingham, Glasgow, Leeds, Manchester, Waltham Abbey
☎ 0808 175 1000 📧 drawings@fhpress.com 🌐 www.fhpress.com

Drawing Title


PUBLIC HEALTH SERVICES
DOMESTIC WATER SERVICES LAYOUT
FIRST FLOOR

Scale	1:50@A1	Drawn	AutoCAD/
Date	FEB '24	Checked	D.H

Status

PLANNING

Project number/Drawing number	Revision
44758-P-530-01-100	PL

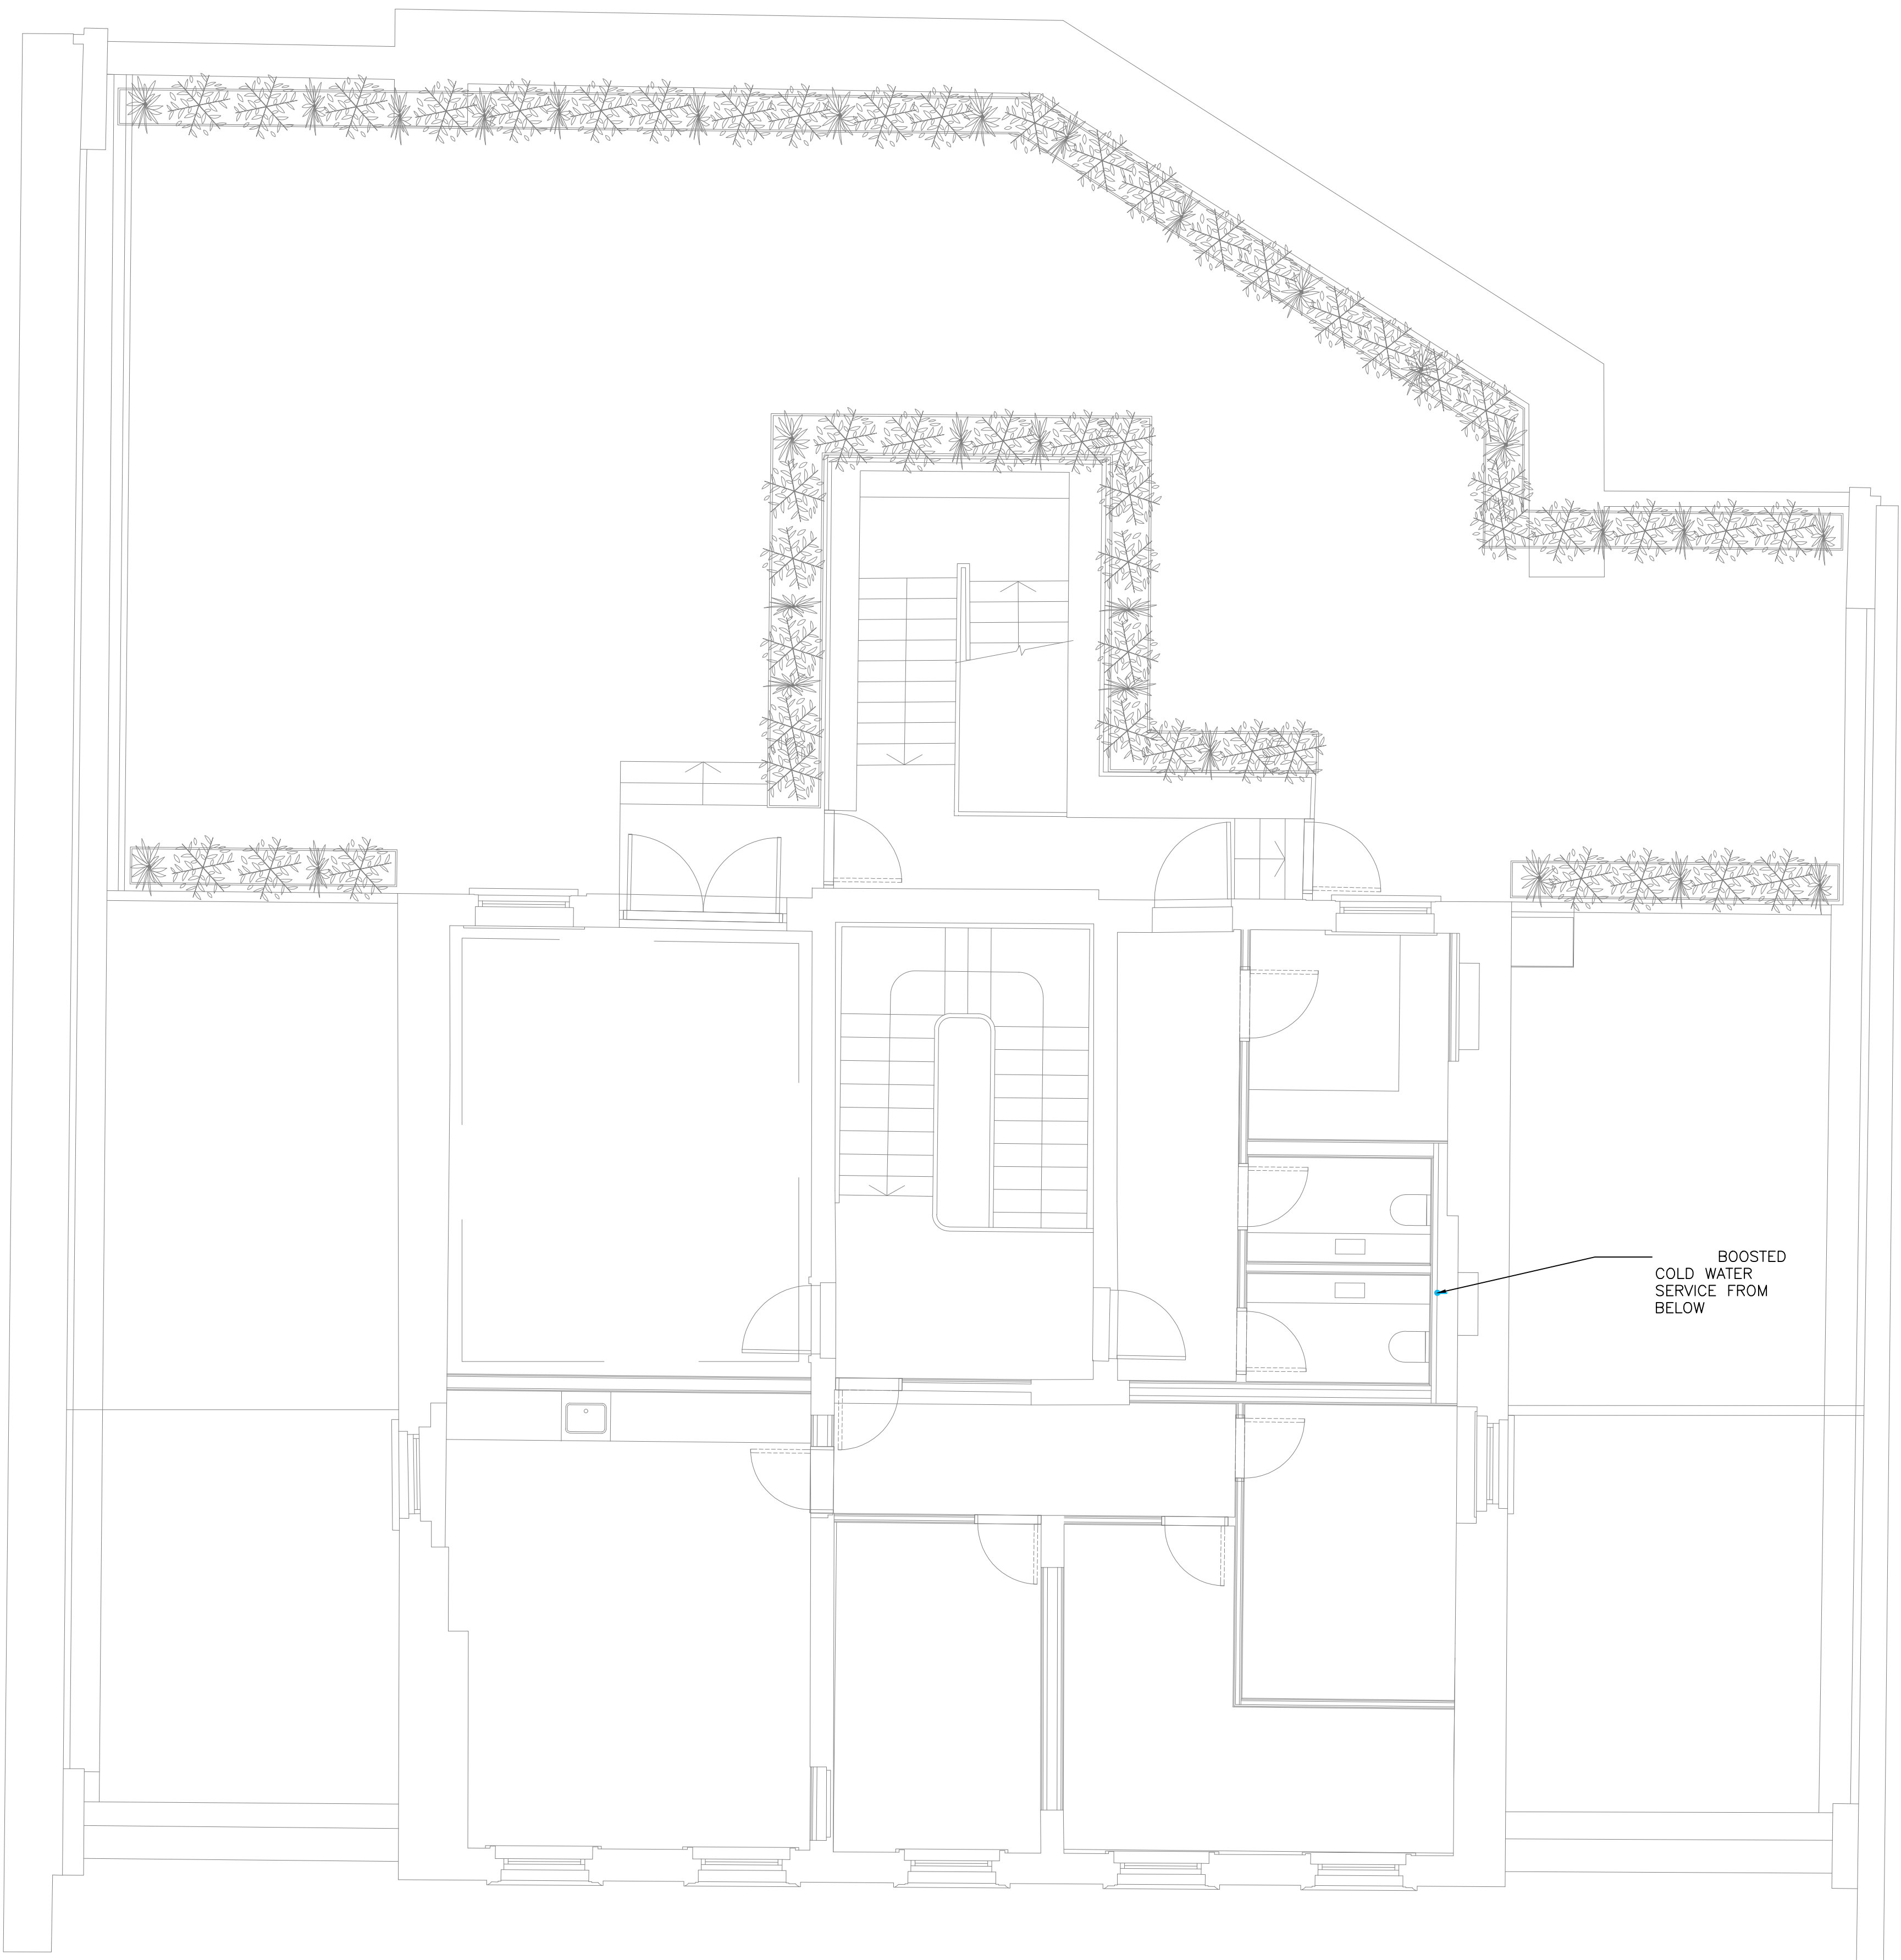

DRAWING BACKGROUND INFO

PL	30.05.24	DH	PLANNING
Rev	Date	Drn	Description

Client
WATCHES OF SWITZERLAND GROUP
Architect
JOHNSON PINNEY ARCHITECTS
Project
KINGS STREET, MANCHESTER


FHP**ESS**

London, Bexley, Birmingham, Glasgow, Leeds, Manchester, Waltham Abbey
☎ 0808 175 1000 ✉ drawings@fhpress.com 🌐 www.fhpress.com

Drawing Title	
PUBLIC HEALTH SERVICES DOMESTIC WATER SERVICES LAYOUT SECOND FLOOR	
Scale	1:50@A1
Drawn	AutoCAD/
Date	FEB '24
Checked	D.H

Status
PLANNING

Project number/Drawing number	Revision
44758-P-530-02-100	PL

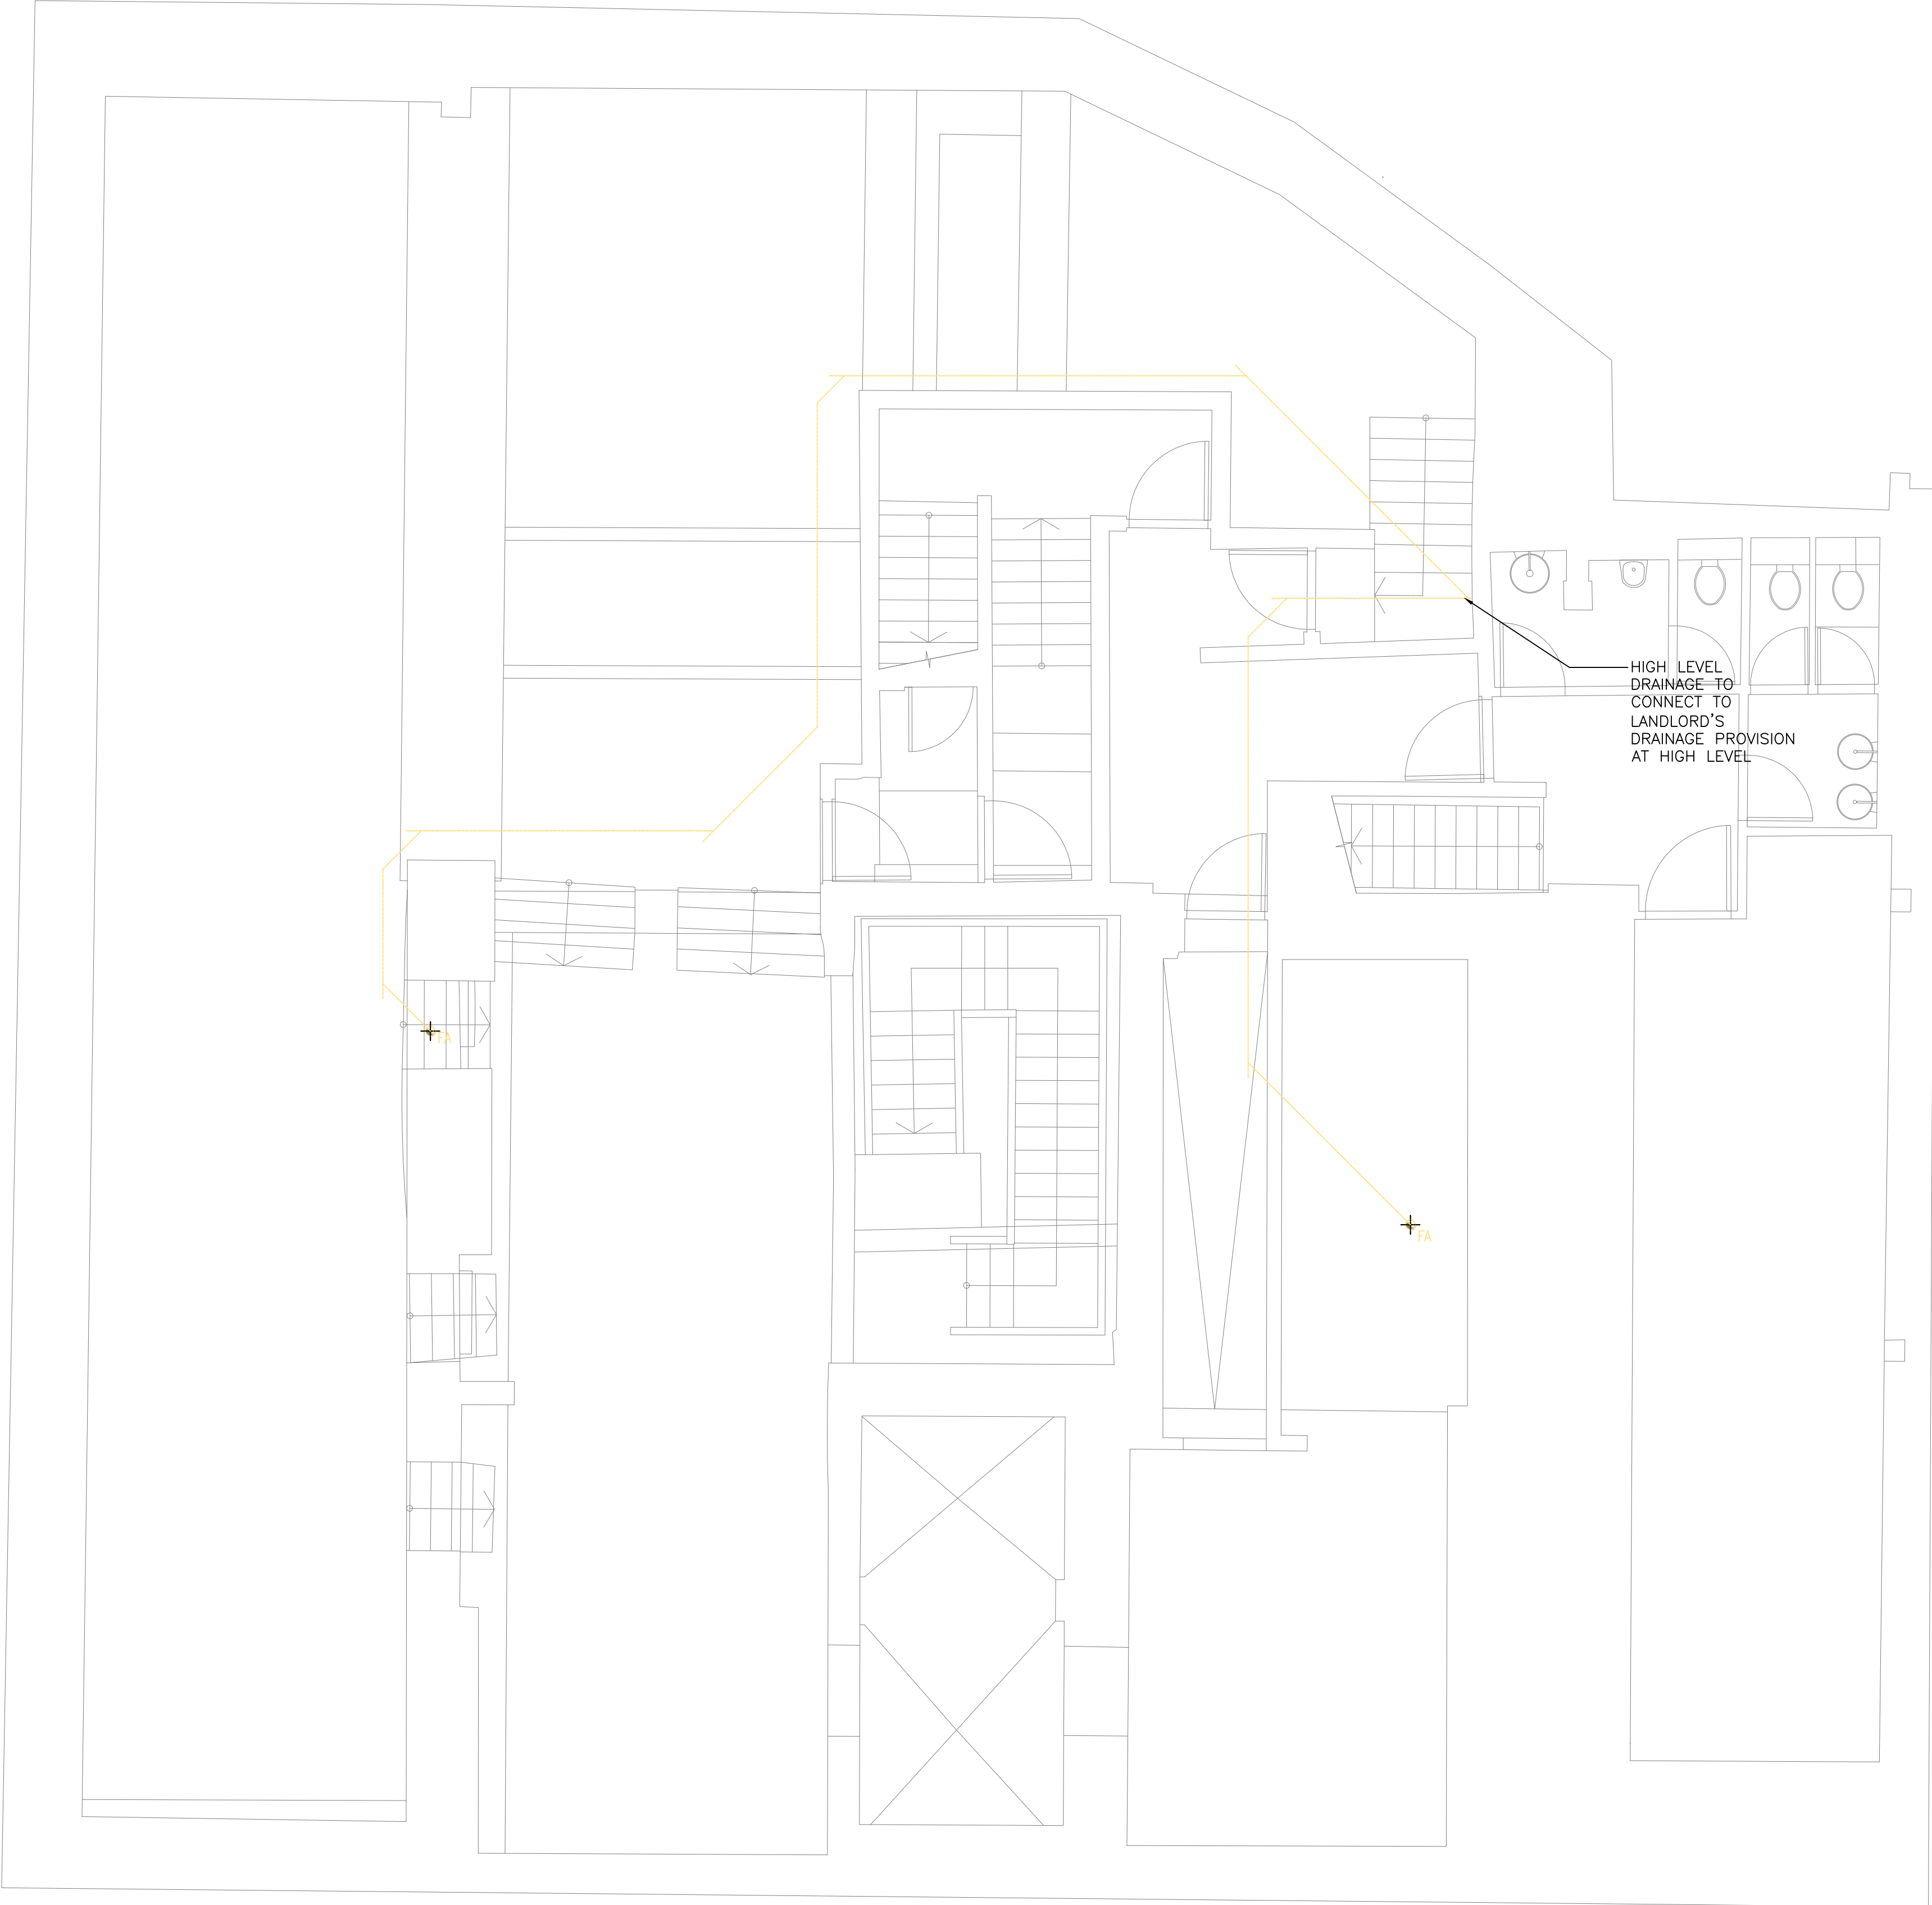

DRAWING BACKGROUND INFO

PL 30.05.24 DH PLANNING

Rev	Date	Drn	Description
-----	------	-----	-------------

Client	WATCHES OF SWITZERLAND GROUP
Architect	JOHNSON PINNEY ARCHITECT
Project	KINGS STREET, MANCHESTER


FHP**ESS**

London, Bexley, Birmingham, Glasgow, Leeds, Manchester, Waltham Abbey
☎ 0808 175 1000 ✉ drawings@fhpress.com 🌐 www.fhpress.com

Drawing Title	
PUBLIC HEALTH SERVICES DRAINAGE SERVICES LAYOUT BASEMENT	
Scale 1:50@A1	Drawn AutoCAD/
Date FEB '24	Checked D.H

Status
PLANNING

Project number/Drawing number	Revision
44758-P-520-B1-100	PL

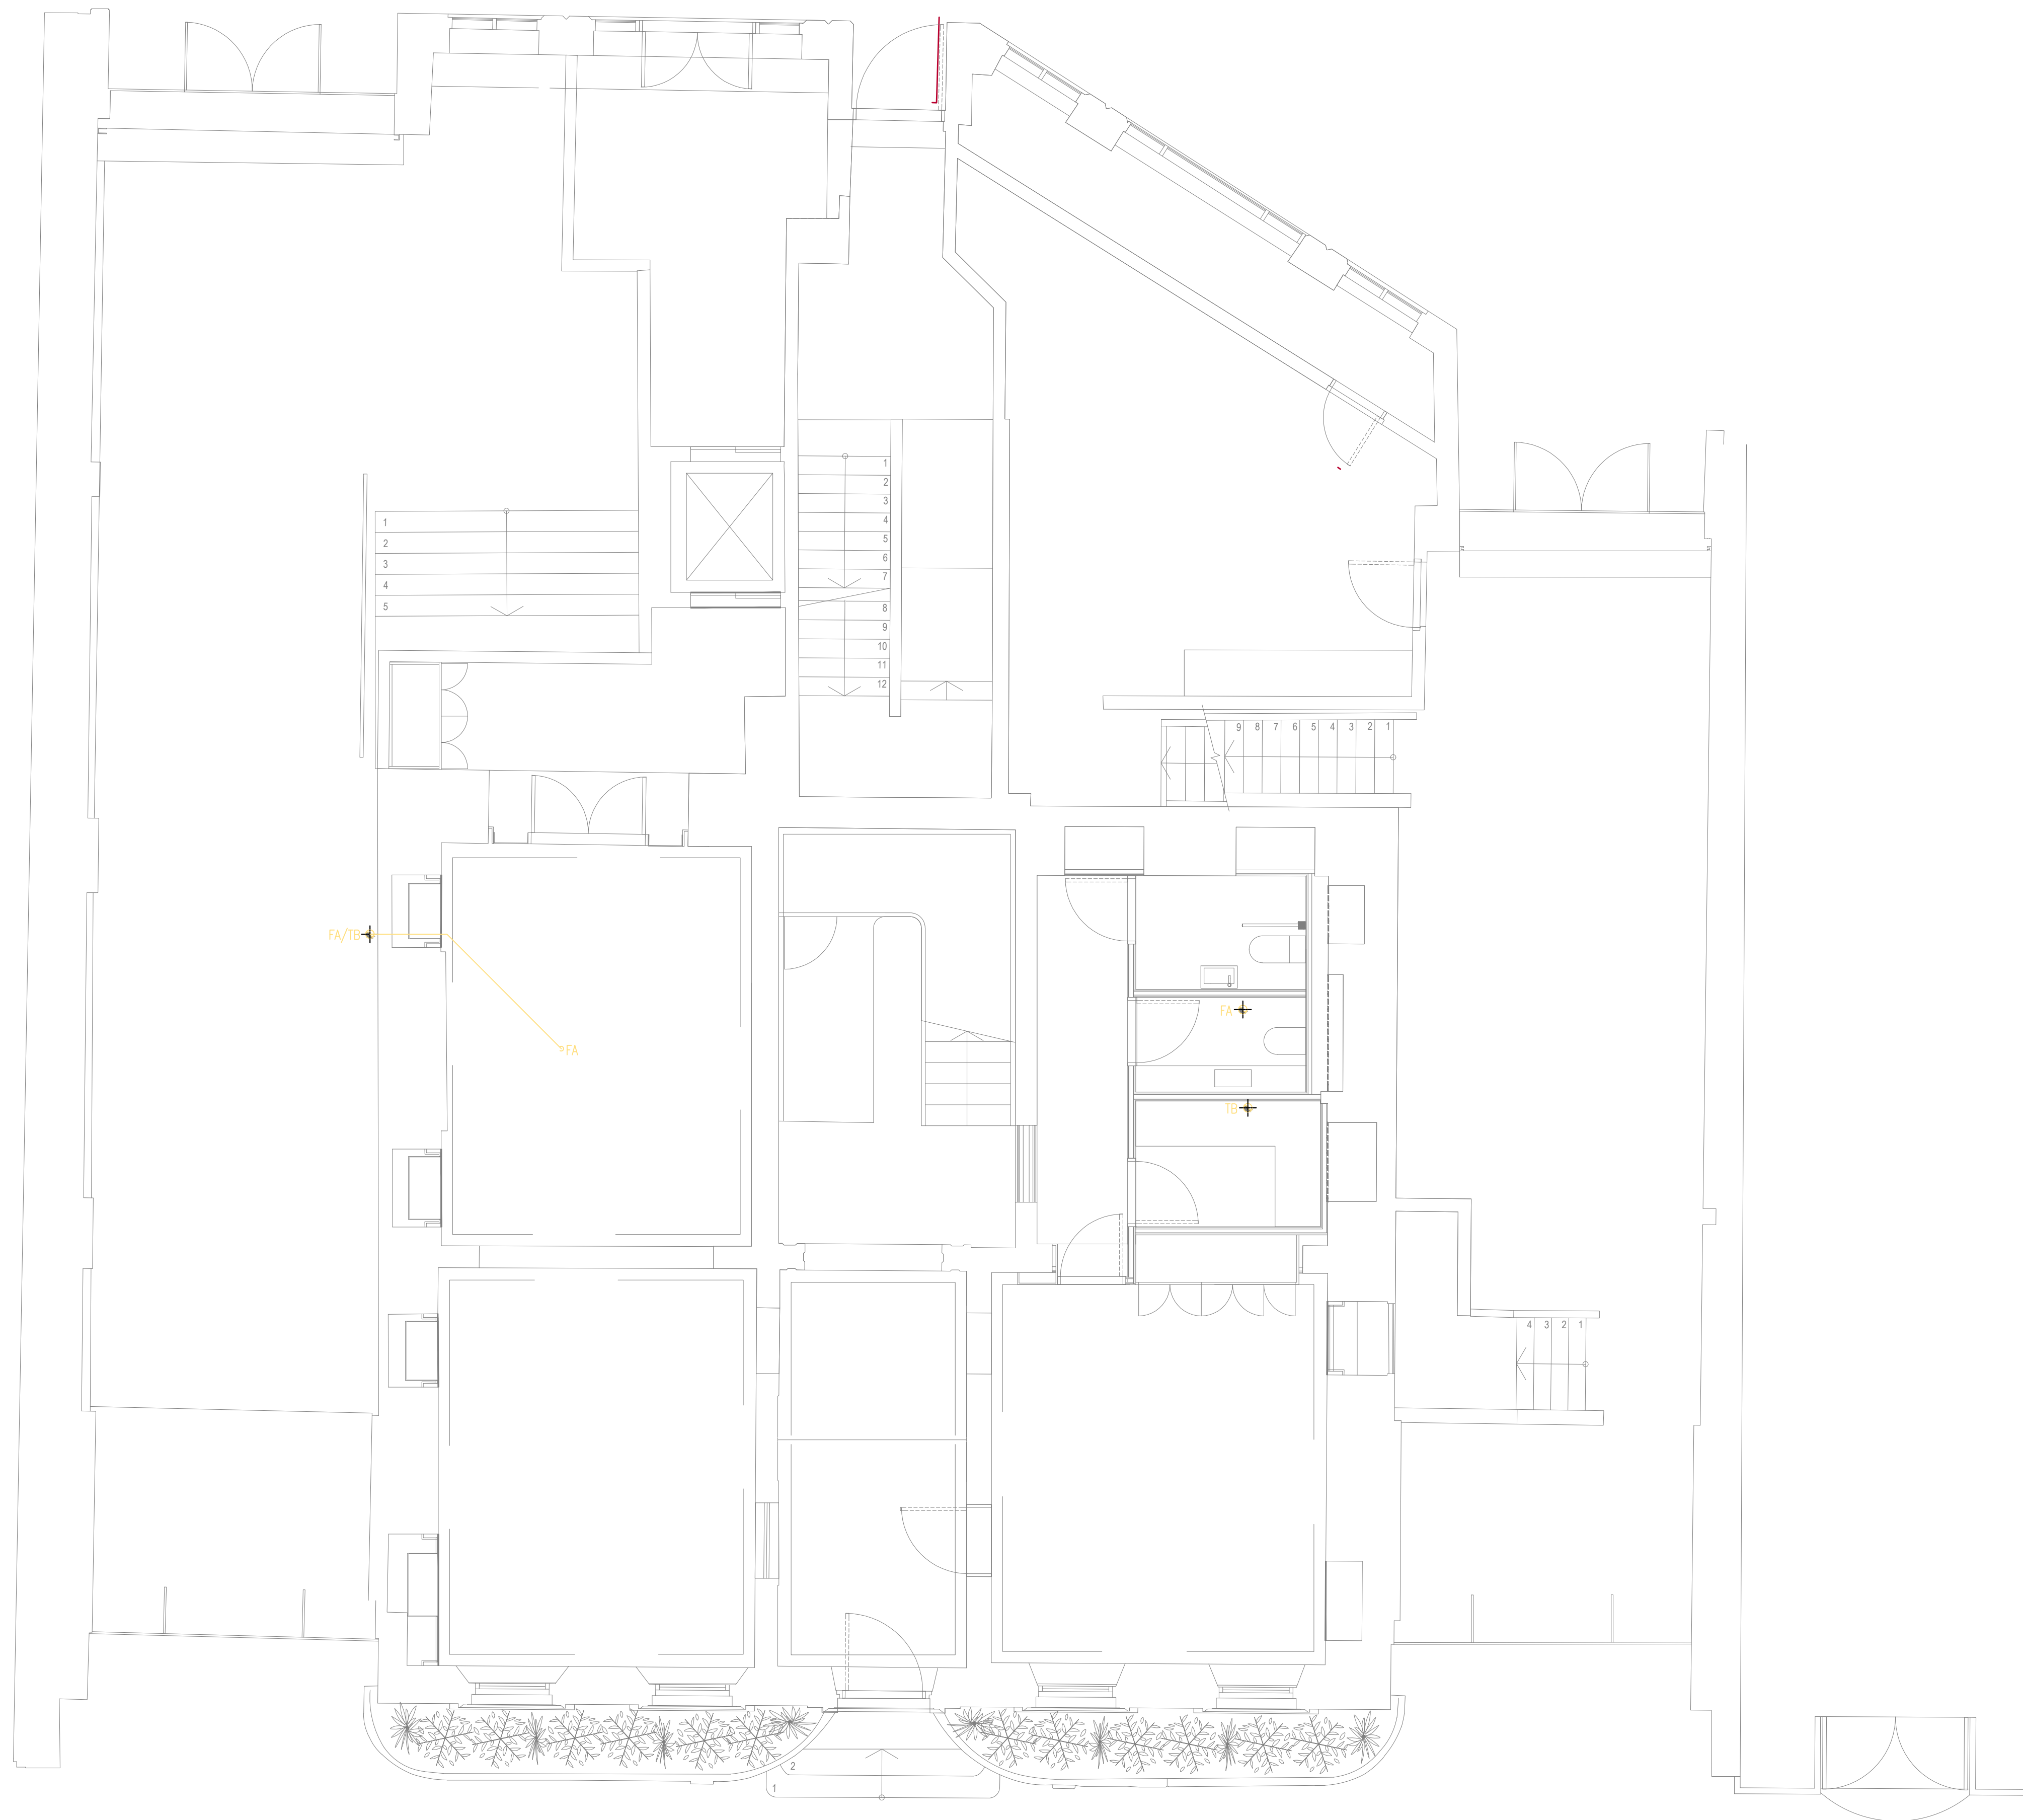

DRAWING BACKGROUND INFO

PL 30.05.24 DH PLANNING

Rev	Date	Drn	Description
-----	------	-----	-------------

Client	WATCHES OF SWITZERLAND GROUP
Architect	JOHNSON PINNEY ARCHITECT
Project	KINGS STREET, MANCHESTER

FHP **ESS**

London, Bexley, Birmingham, Glasgow, Leeds, Manchester, Waltham Abbey
☎ 0808 175 1000 📧 drawings@fhpress.com 🌐 www.fhpress.com

Drawing Title


**PUBLIC HEALTH SERVICES
DRAINAGE SERVICES LAYOUT
GROUND FLOOR**

Scale	1:50@A1	Drawn	AutoCAD/
Date	FEB '24	Checked	D.H

Status

PLANNING

Project number/Drawing number	Revision
44758-P-520-00-100	PL

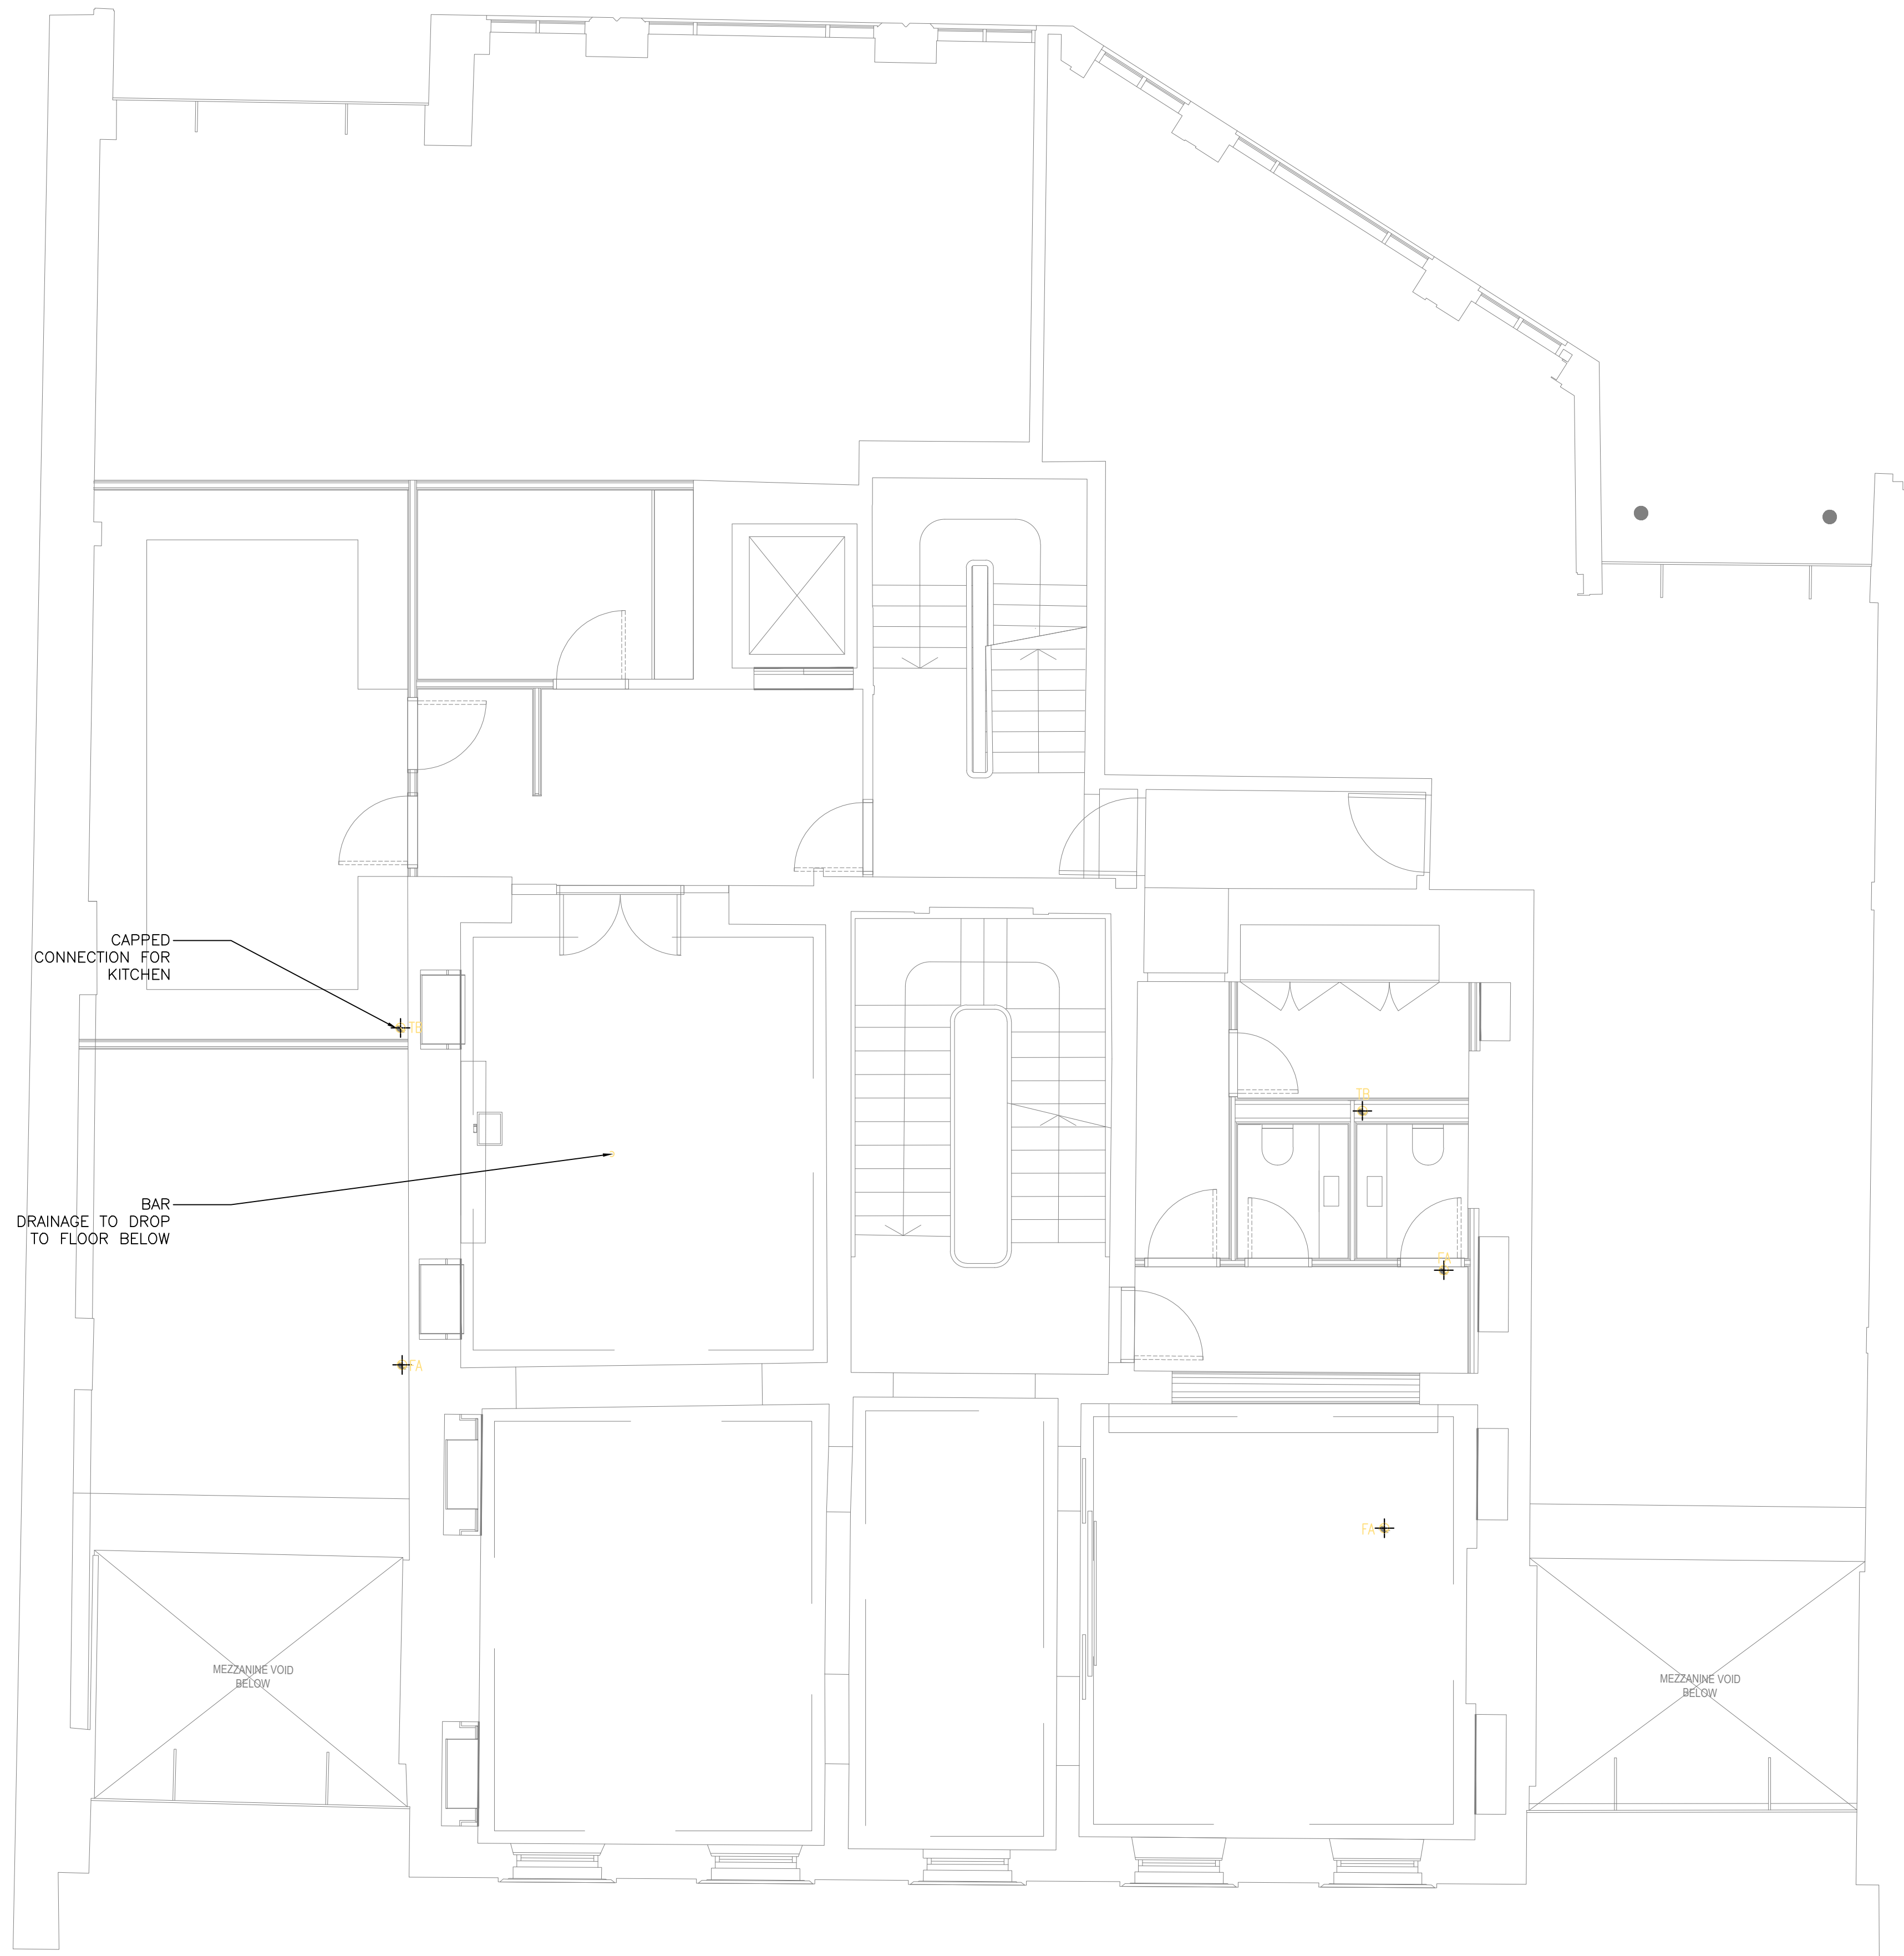

DRAWING BACKGROUND INFO

PL 30.05.24 DH PLANNING

Rev	Date	Drn	Description
-----	------	-----	-------------

Client	WATCHES OF SWITZERLAND GROUP
Architect	JOHNSON PINNEY ARCHITECT
Project	KINGS STREET, MANCHESTER

FHP **ESS**

London, Bexley, Birmingham, Glasgow, Leeds, Manchester, Waltham Abbey
☎ 0808 175 1000 📧 drawings@fhpress.com 🌐 www.fhpress.com

Drawing Title


**PUBLIC HEALTH SERVICES
DRAINAGE SERVICES LAYOUT
FIRST FLOOR**

Scale	1:50@A1	Drawn	AutoCAD/
Date	FEB '24	Checked	D.H

Status

PLANNING

Project number/Drawing number	Revision
44758-P-520-01-100	PL

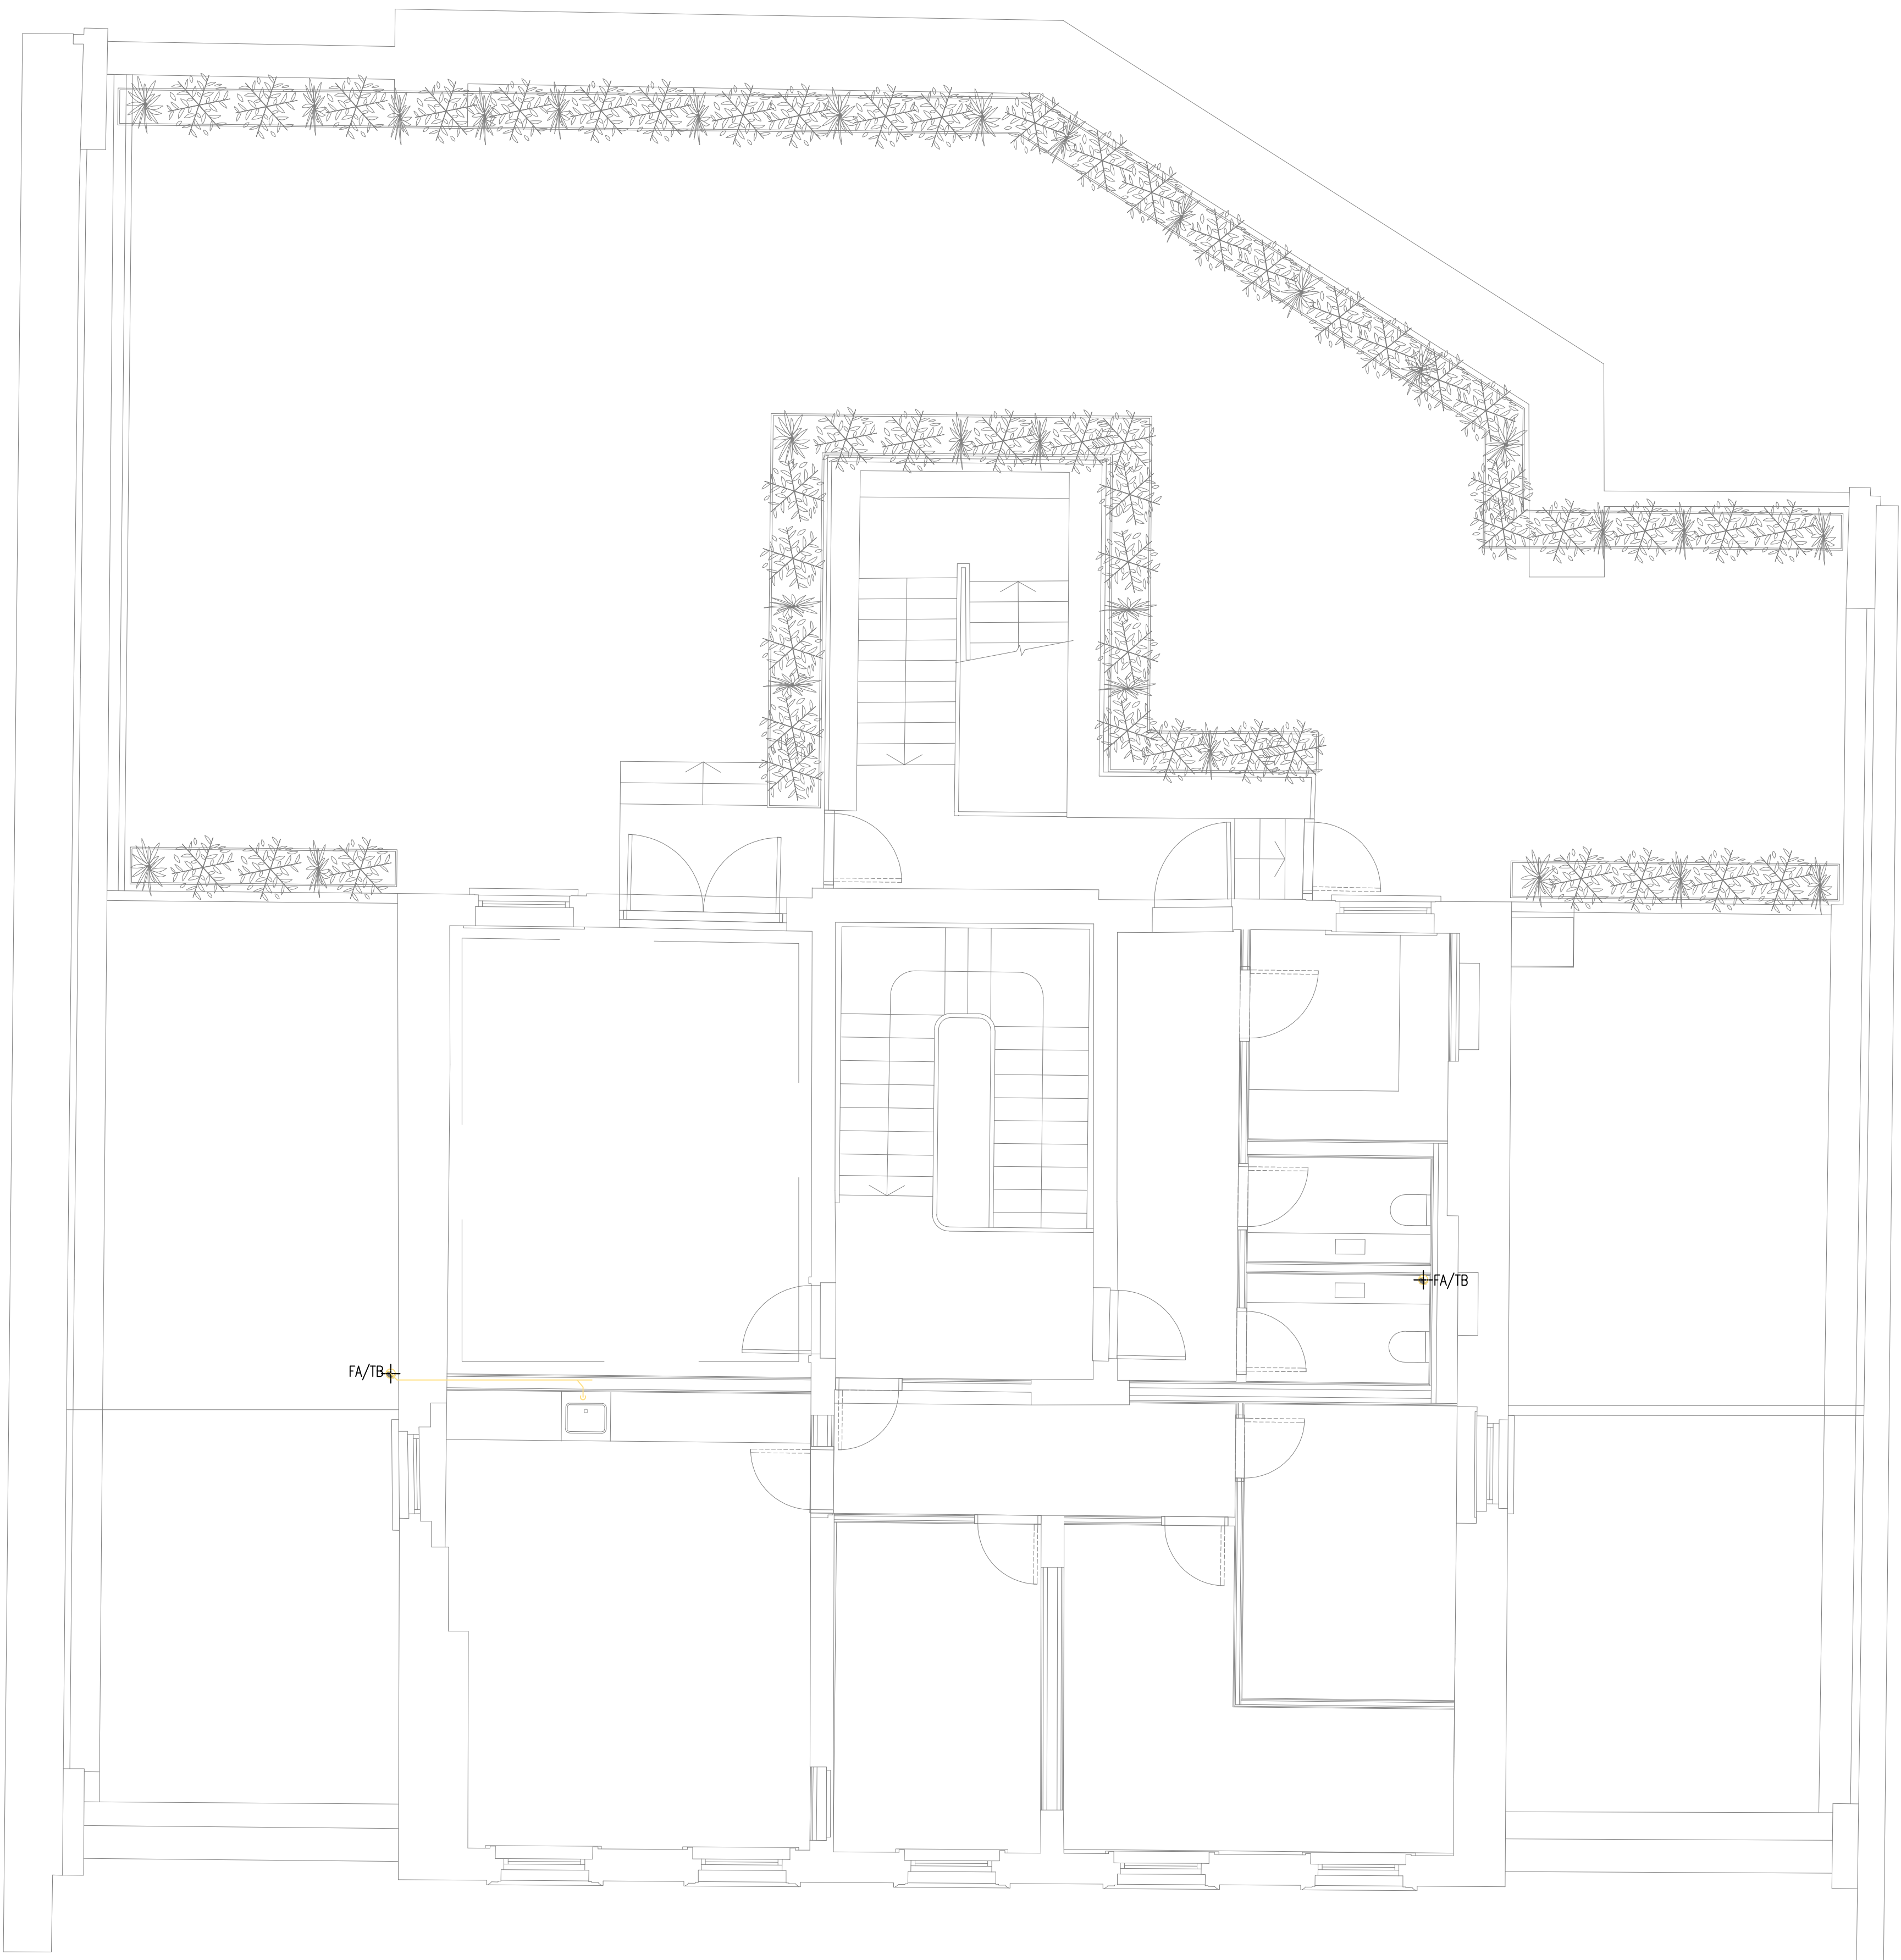

DRAWING BACKGROUND INFO

PL 30.05.24 DH PLANNING

Rev Date Drn Description

Client
WATCHES OF SWITZERLAND GROUP
Architect
JOHNSON PINNEY ARCHITECT
Project
KINGS STREET, MANCHESTER

FHP **ESS**
London, Bexley, Birmingham, Glasgow, Leeds, Manchester, Waltham Abbey
0808 175 1000 drawings@fhpress.com www.fhpress.com

Drawing Title
PUBLIC HEALTH SERVICES
DRAINAGE SERVICES LAYOUT
SECOND FLOOR

Scale	1:50@A1	Drawn	AutoCAD/
Date	FEB '24	Checked	D.H

Status
PLANNING

Project number/Drawing number	Revision
44758-P-520-02-100	PL



DRAWING BACKGROUND INFO

PL	30.05.24	DH	PLANNING
Rev	Date	Drn	Description

Client	WATCHES OF SWITZERLAND GROUP
Architect	JOHNSON PINNEY ARCHITECT
Project	KINGS STREET, MANCHESTER

FHP**ESS**

London, Bexley, Birmingham, Glasgoy, Leeds, Manchester, Waltham Abbey
0808 175 1000 drawings@fhpress.com www.fhpress.com

Drawing Title	
MECHANICAL SERVICES HEATING, COOLING & VENTILATION LAYOUT GROUND FLOOR	
Scale	1:50@A1
Date	MAR '24
Drawn	AutoCAD/
Checked	D.H

Status
PLANNING

Project number/Drawing number	Revision
44758-M-500-00-100	PL



DRAWING BACKGROUND INFO

PL	30.05.24	DH	PLANNING
Rev	Date	Drn	Description


Client	WATCHES OF SWITZERLAND GROUP
Architect	JOHNSON PINNEY ARCHITECT
Project	KINGS STREET, MANCHESTER

FHP**ESS**

London, Bexley, Birmingham, Glasgow, Leeds, Manchester, Waltham Abbey
☎ 0808 175 1000 ✉ drawings@fhpress.com 🌐 www.fhpress.com

Drawing Title	
MECHANICAL SERVICES HEATING, COOLING & VENTILATION LAYOUT FIRST FLOOR	
Scale	1:50@A1
Date	MAR '24
Drawn	AutoCAD/
Checked	D.H

Status	PLANNING
Project number/Drawing number	Revision
44758-M-500-01-100	PL

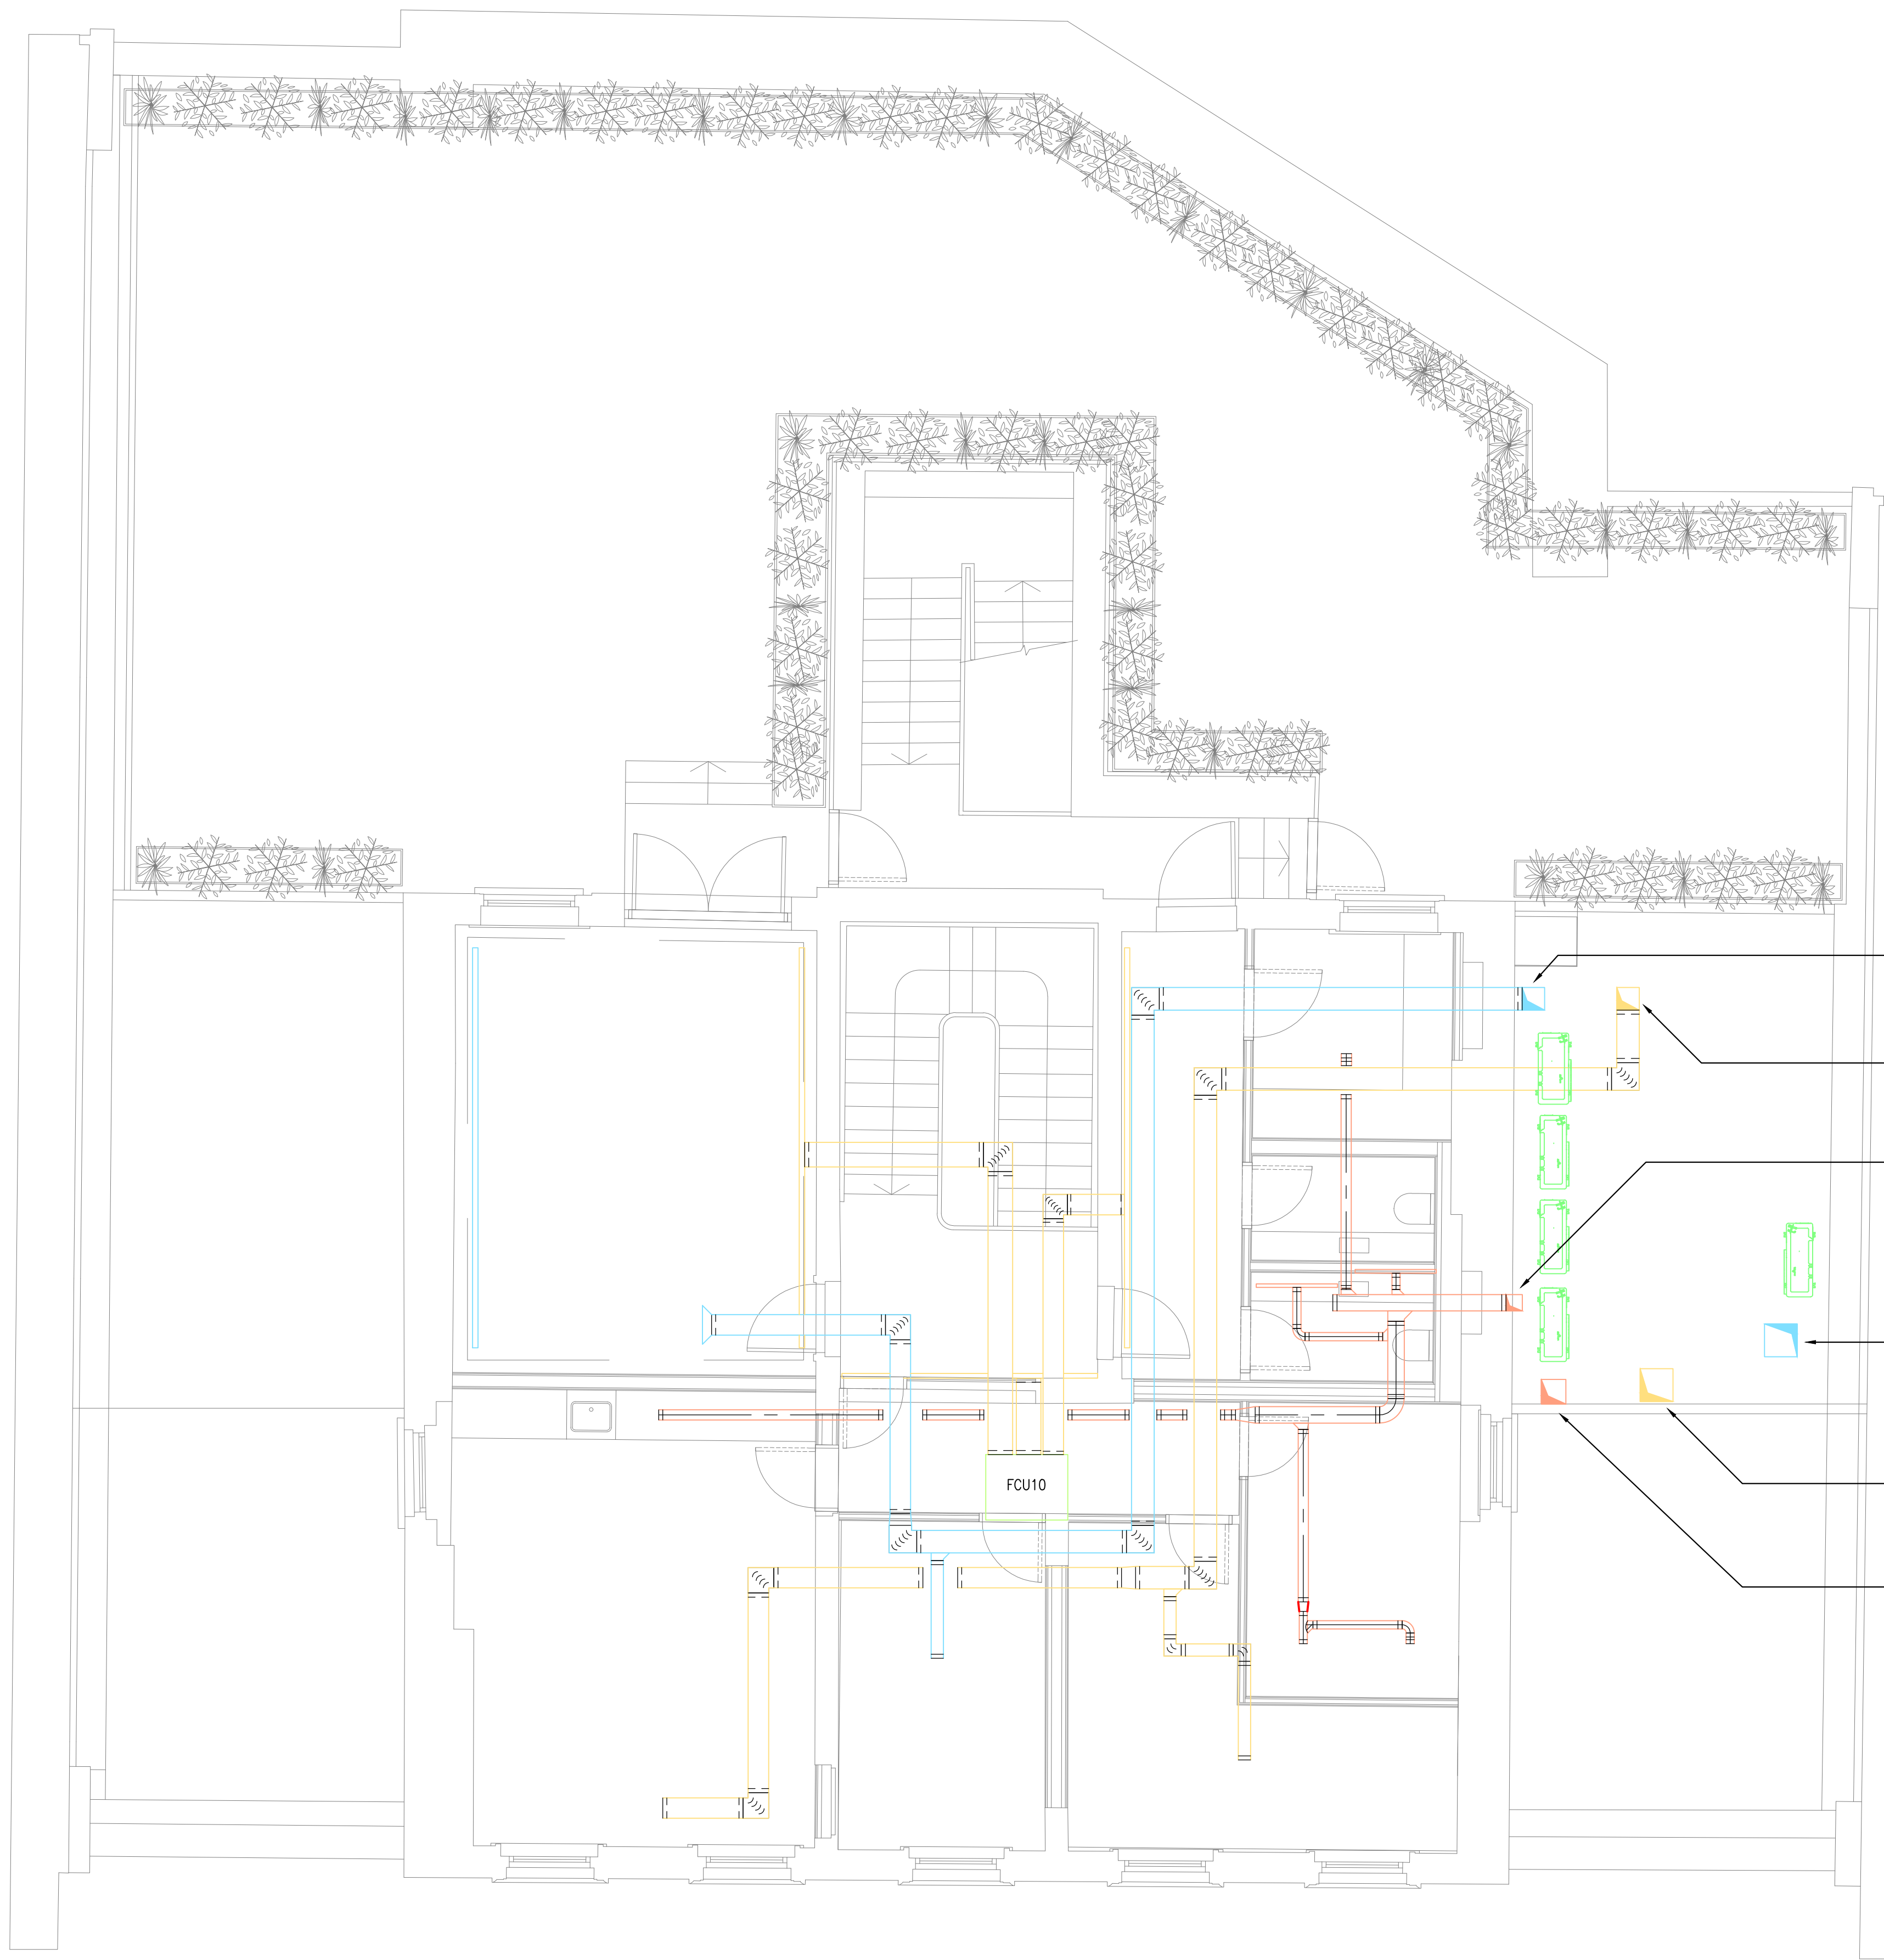

- DUCT FROM BELOW TO RISE TO HIGH LEVEL AND OFFSET INTO THE BUILDING
- DUCT FROM BELOW TO RISE TO HIGH LEVEL AND OFFSET INTO THE BUILDING
- DUCT FROM BELOW TO RISE TO HIGH LEVEL AND OFFSET INTO THE BUILDING
- DUCT FROM BELOW FOR SUPPLY AIR FROM EXTERNAL
- DUCT FROM BELOW FOR EXHAUST AIR TO EXTERNAL
- DUCT FROM BELOW FOR WC/KITCHENETTE EXHAUST AIR TO EXTERNAL

DRAWING BACKGROUND INFO

PL	30.05.24	DH	PLANNING
Rev	Date	Drn	Description

Client
WATCHES OF SWITZERLAND GROUP

Architect
JOHNSON PINNEY ARCHITECT

Project
KINGS STREET, MANCHESTER

FHP **ESS**

London, Bexley, Birmingham, Glasgow, Leeds, Manchester, Waltham Abbey
☎ 0808 175 1000 📧 drawings@fhpress.com 🌐 www.fhpress.com

Drawing Title
MECHANICAL SERVICES
HEATING, COOLING & VENTILATION LAYOUT
SECOND FLOOR

Scale	1:50@A1	Drawn	AutoCAD/
Date	MAR '24	Checked	D.H

Status
PLANNING

Project number/Drawing number	Revision
44758-M-500-02-100	PL