

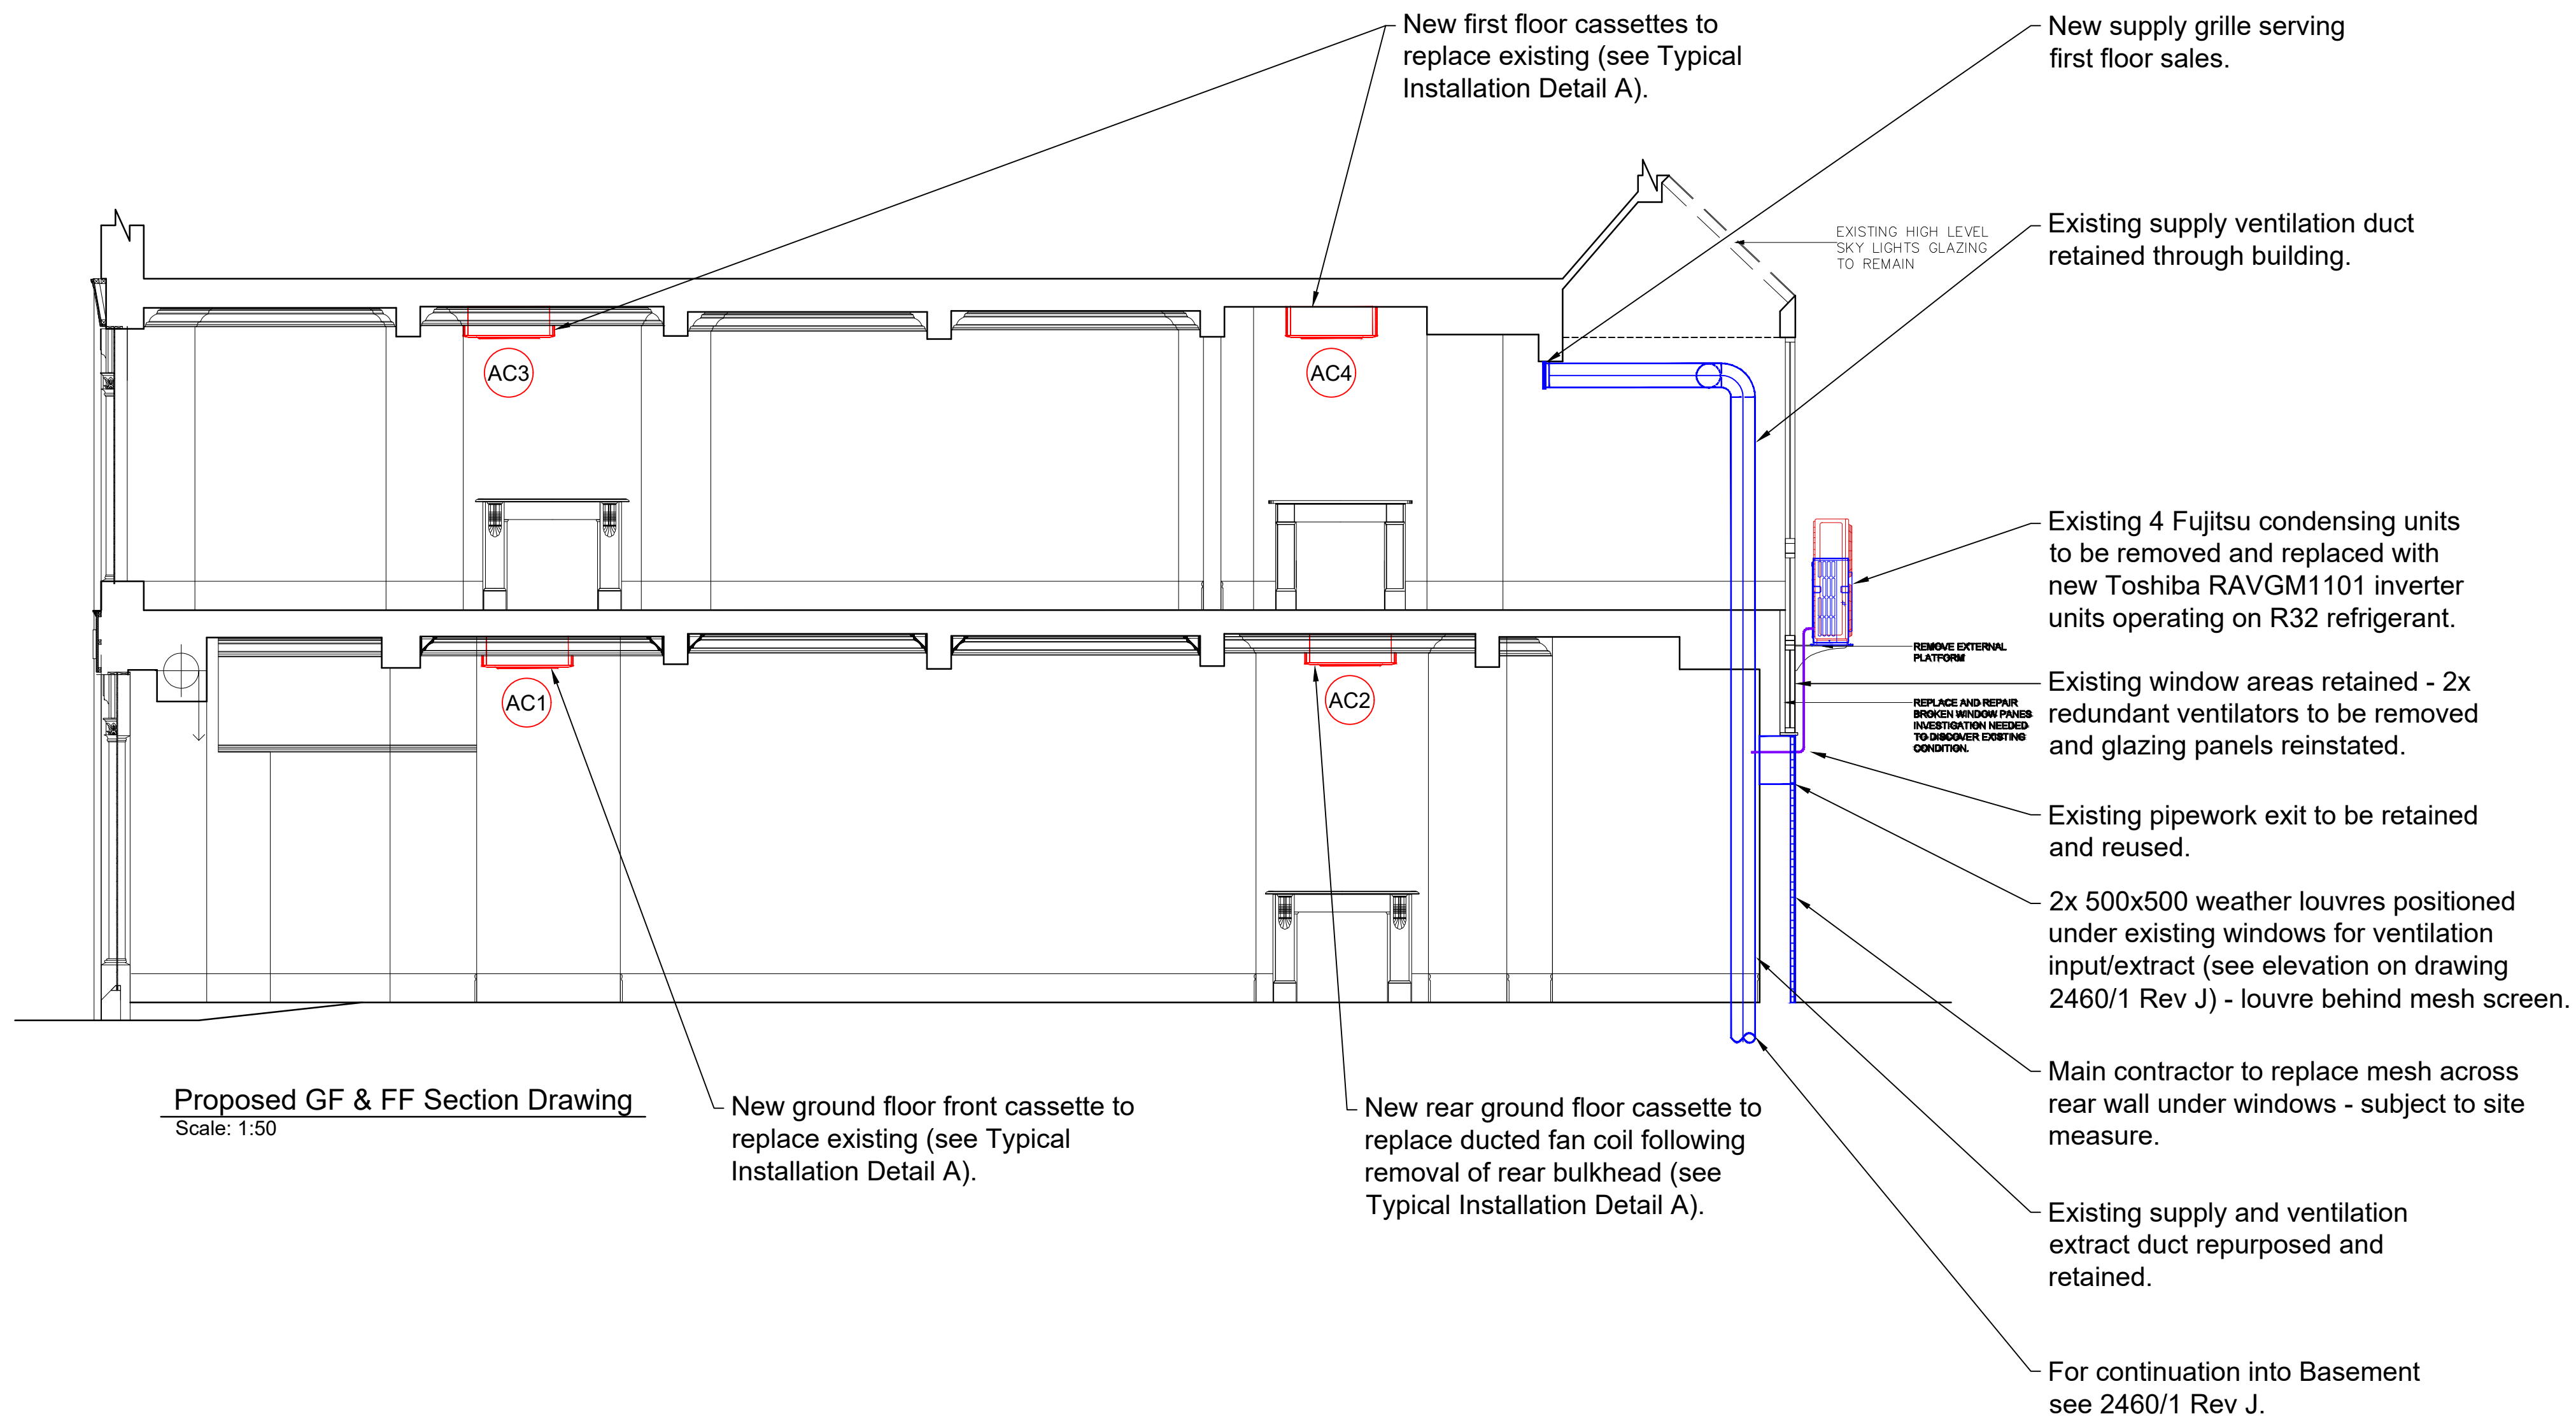
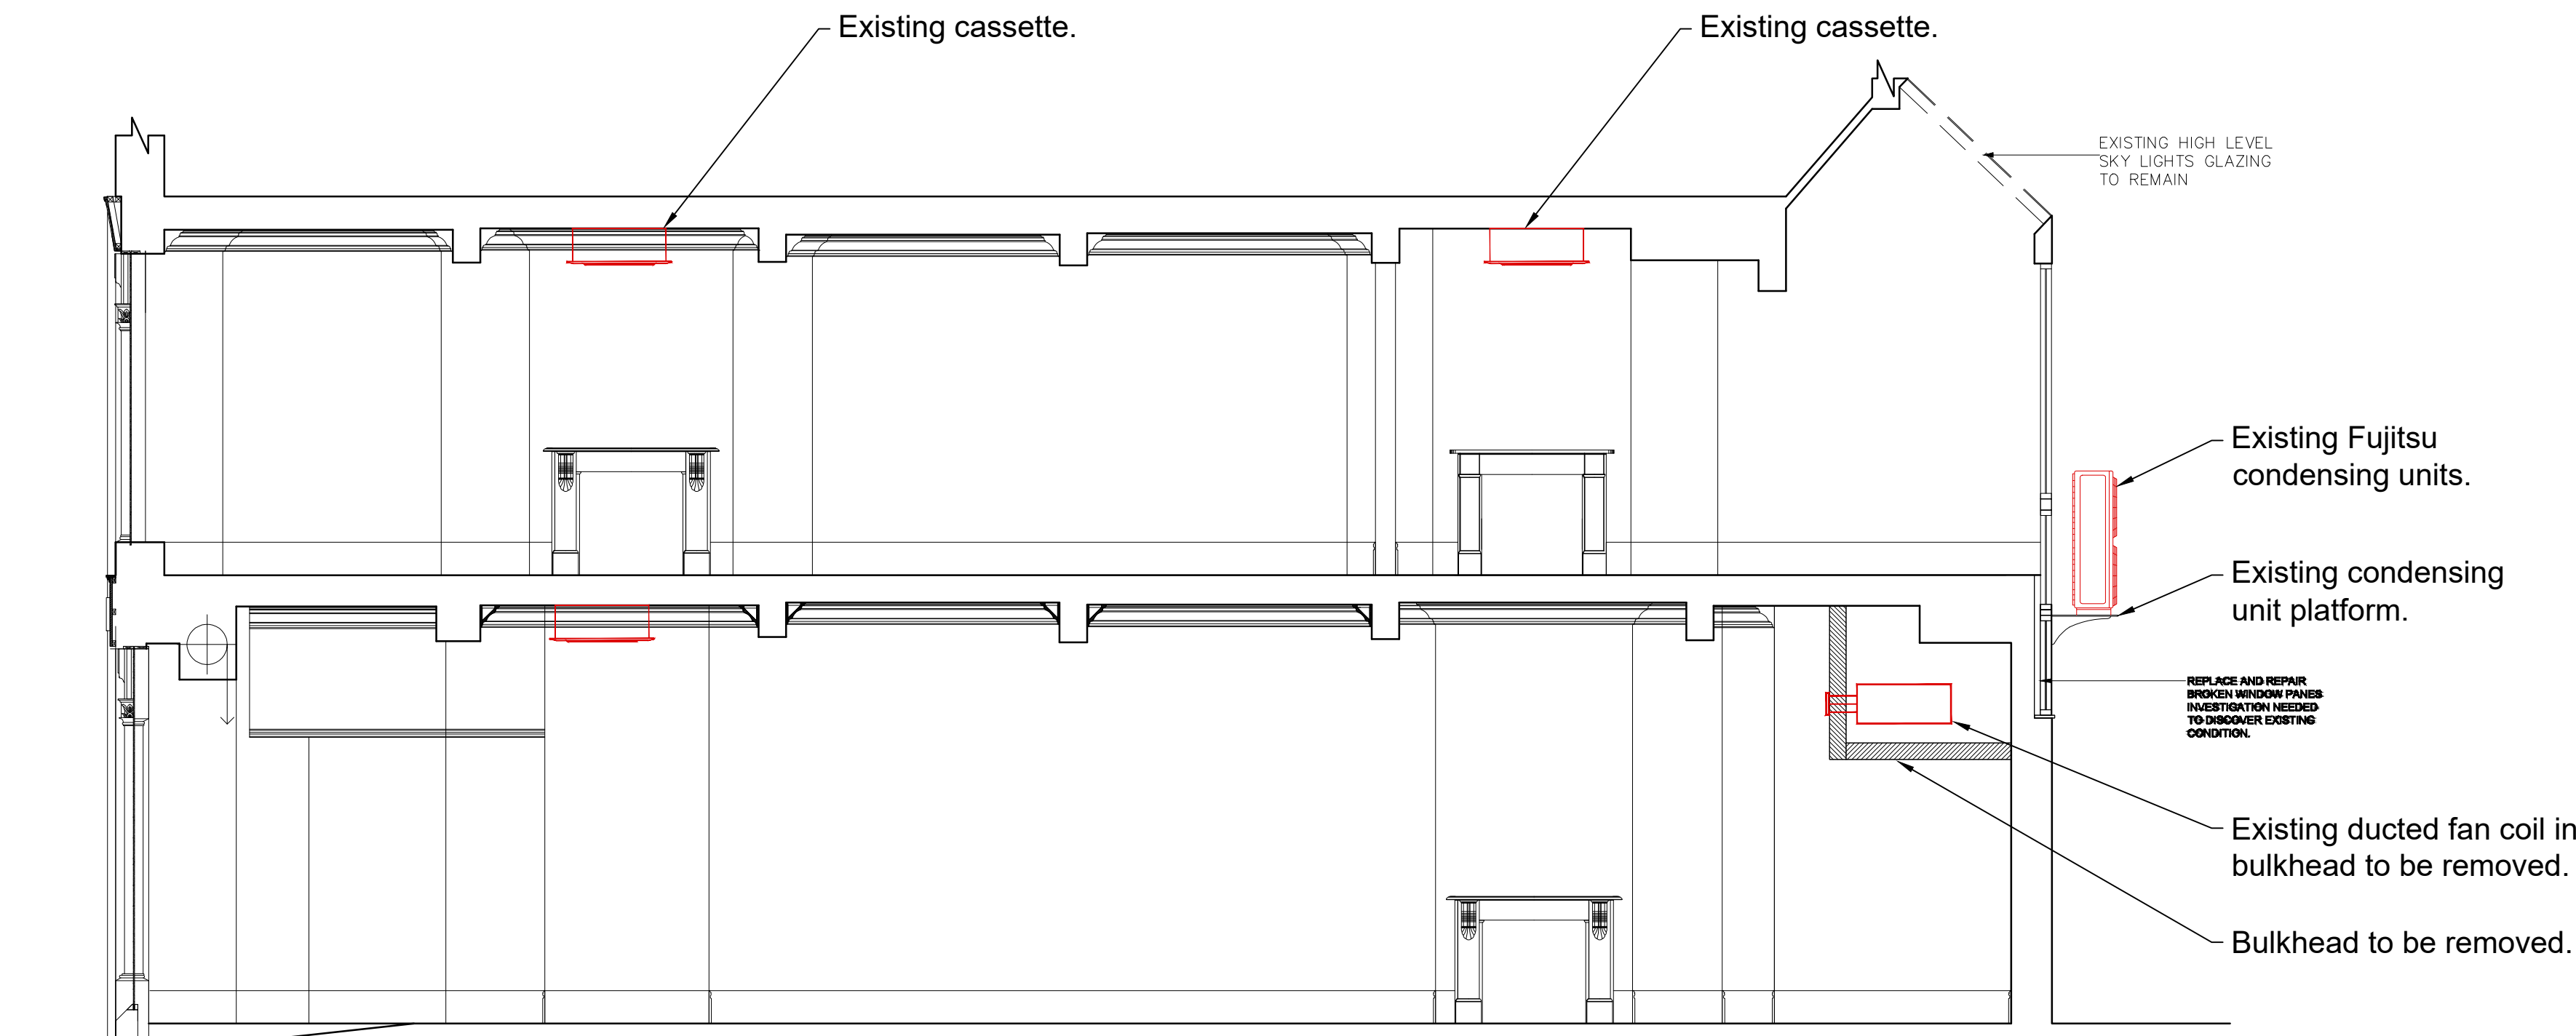


DO NOT SCALE FROM
PRINT IF
IN DOUBT ASK

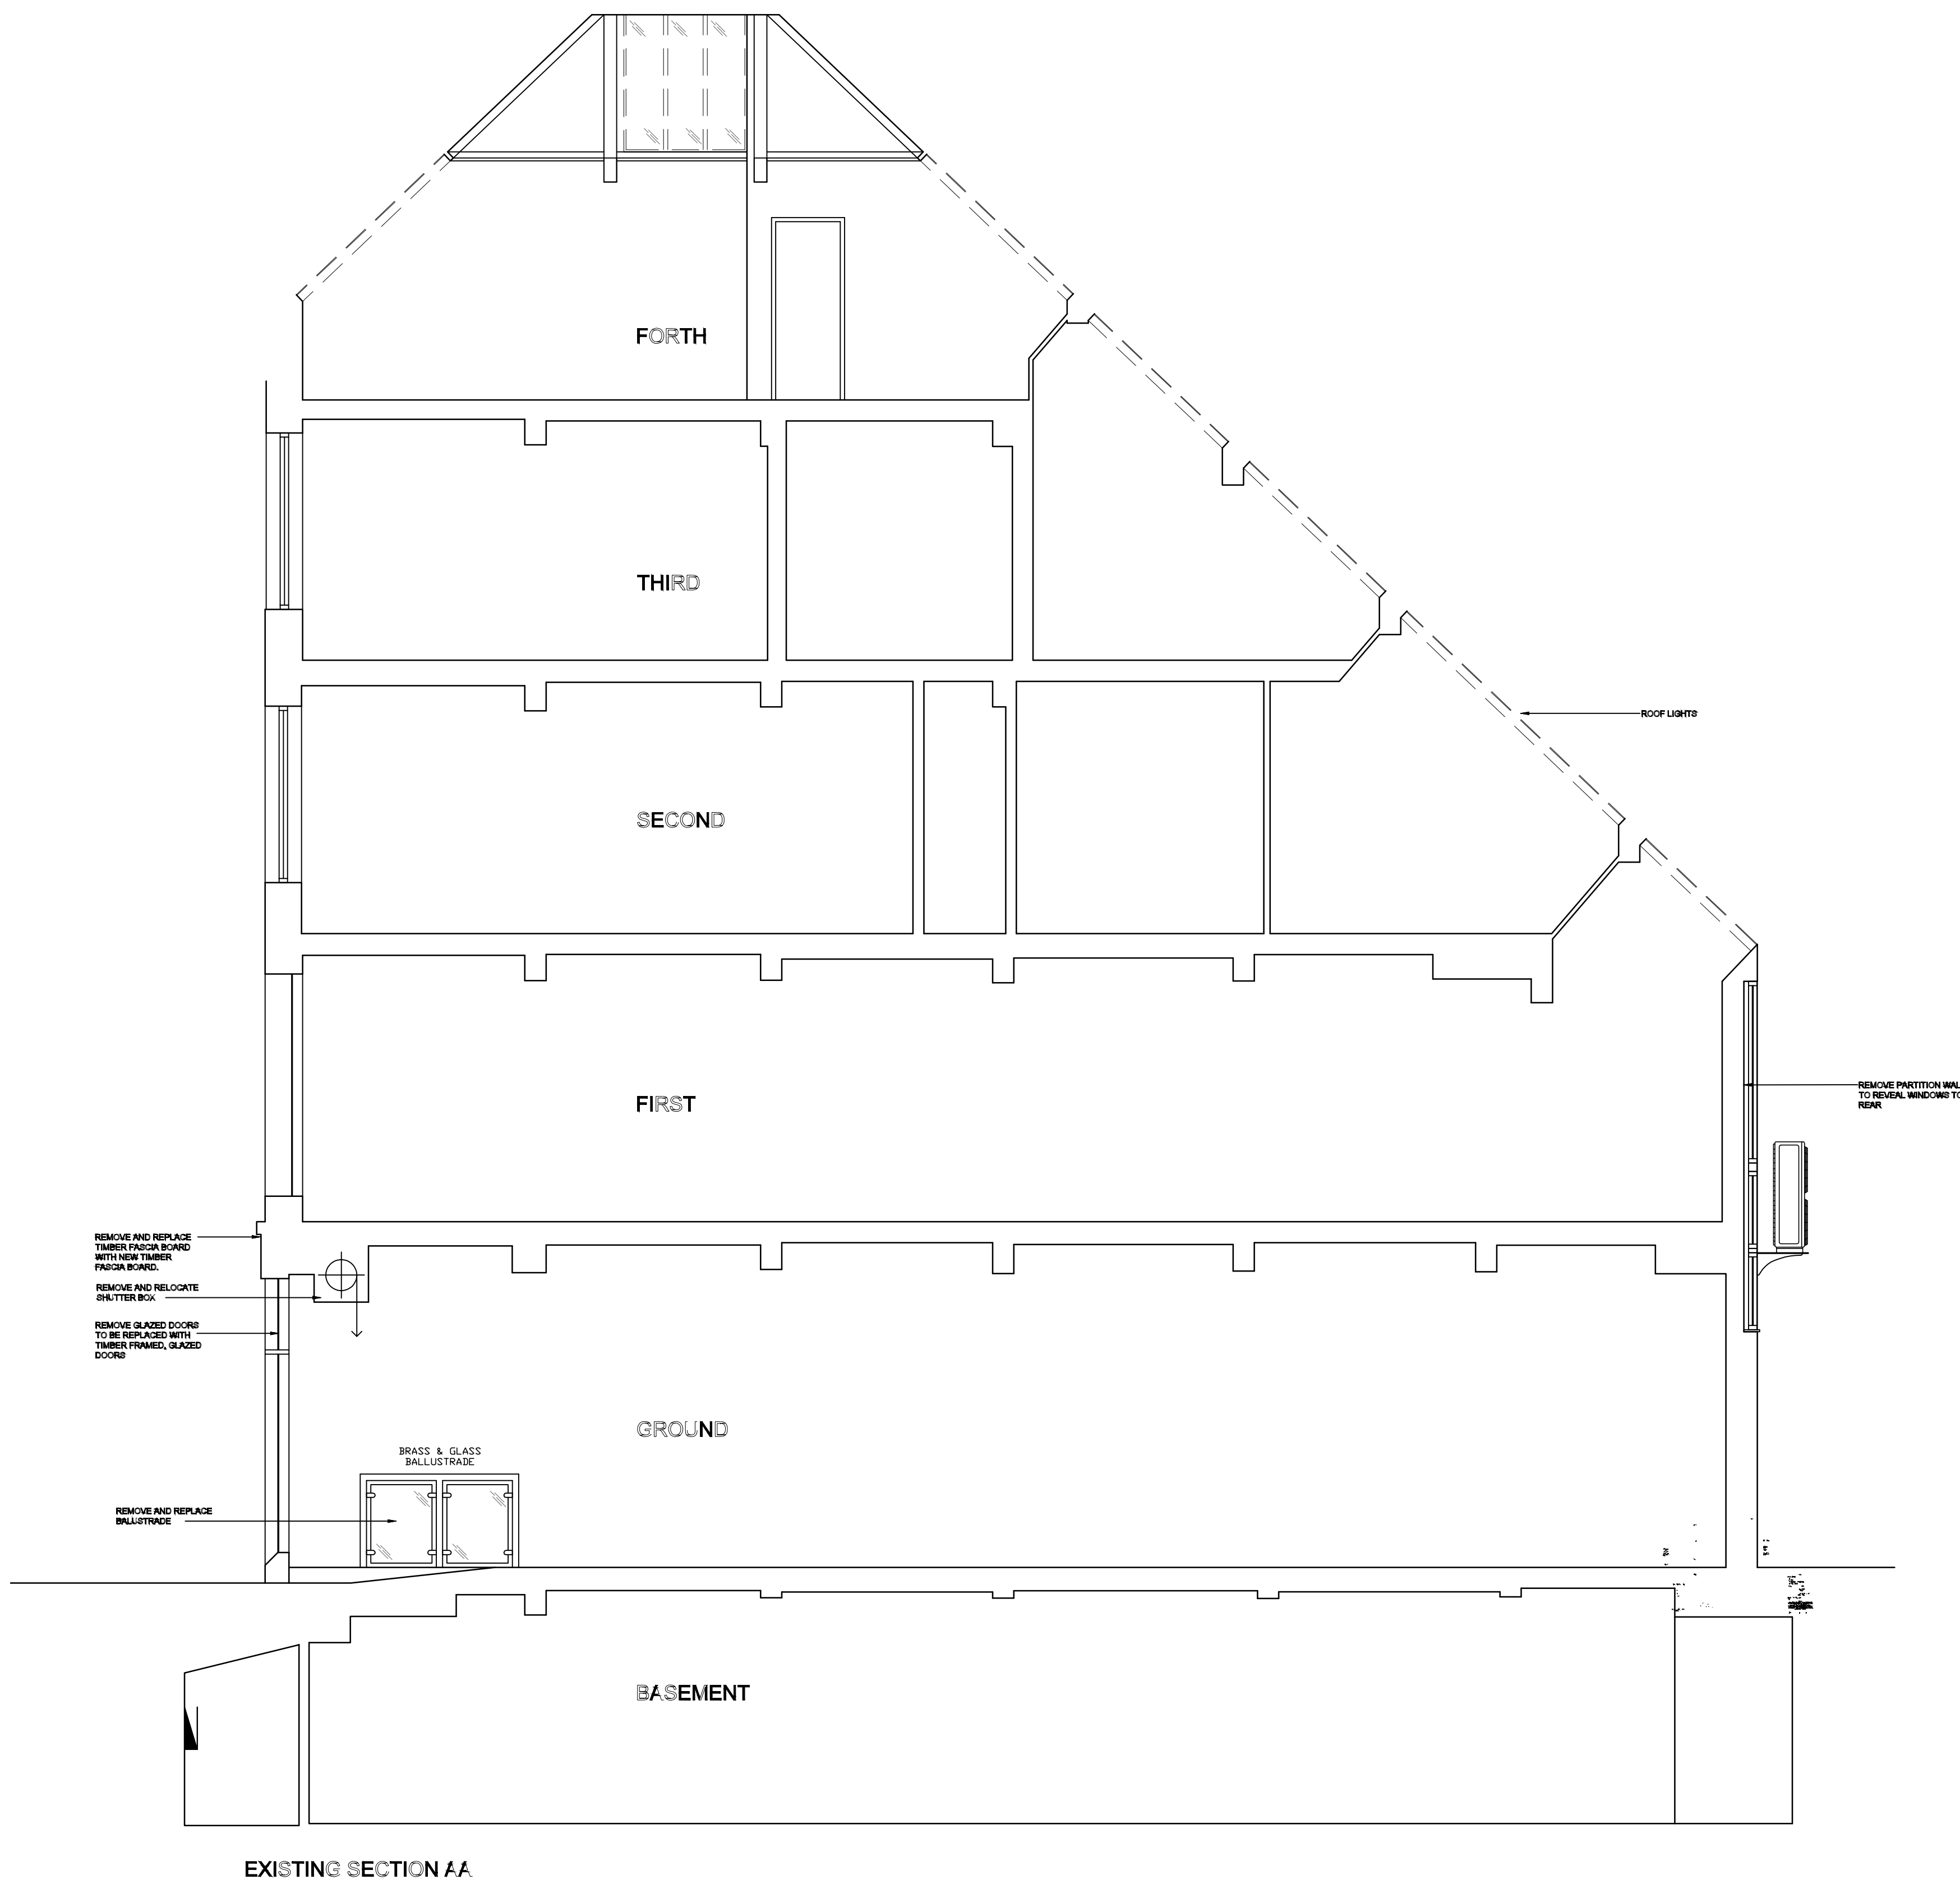

REV.	DATE	REVISION	CHECKED	DRAWN
L	06/08/24	Screen and louvre amendments.	CHECKED	DRAWN
K	06/08/24	Minor amendments.	CHECKED	DRAWN
J	06/08/24	Option A replacement strategy.	CHECKED	DRAWN
I	06/07/24	Modified to the latest layout.	CHECKED	DRAWN
H	06/07/24	Ventilation system amended and rotation updated.	CHECKED	DRAWN
G	06/05/24	Proposed section through building amended.	CHECKED	DRAWN
F	06/05/24	Section through building added.	CHECKED	DRAWN
E	06/05/24	First floor ductwork amended.	CHECKED	DRAWN
D	22/04/24	Modifications to duct routes and rotation added.	CHECKED	DRAWN
C	05/01/24	External elevation modified.	CHECKED	DRAWN
B	20/11/24	Rear existing and proposed elevations added.	CHECKED	DRAWN
A	22/01/24	Ducted AC option removed.	CHECKED	DRAWN

REVISIONS

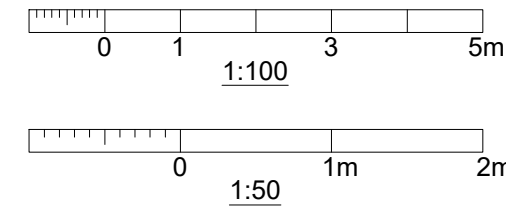

BRANCH	JO MALONE KING STREET MANCHESTER
PROJECT TITLE	PROPOSED HVAC LAYOUT
DRAWING TITLE	WORKING
DRAWING NUMBER	2460/2
SCALE	1:50 @ A0
DATE	06/08/24
INITIALS	R.H
REVISION	L