


SECURITY

- CCTV CAMERA PTZ
- CCTV CAMERA FIX
- CCTV CAMERA IN A DOME PTZ
- CCTV CAMERA IN A DOME FIX
- PRESENCE INFRARED DETECTOR CEILING MOUNTED. 360° COVERAGE
- PRESENCE INFRARED DETECTOR
- INTRUDER ALARM PANEL
- POWER SUPPLY UNIT
- ACCESS CONTROL SWIPE READER
- SECURE SIDE EMERGENCY RELEASE (GREEN BGU)
- MAGNETIC DOOR HOLDER
- PUSH BUTTON/ DOOR RELEASE BUTTON
- INTRUDER ALARM KEY PAD
- MONITORED DOOR CONTACT
- VIDEO ENTRY SYSTEM
- VIDEO ENTRY HANDSET
- VIDEO ENTRY SPEECH PANEL
- EXTERNAL BELL / BEACON UNIT
- EXTERNAL SOUNDER STROBE UNIT
- ACCESS CONTROL
- G2 GRADE 2 MONITORED
- G3 GRADE 3 MONITORED

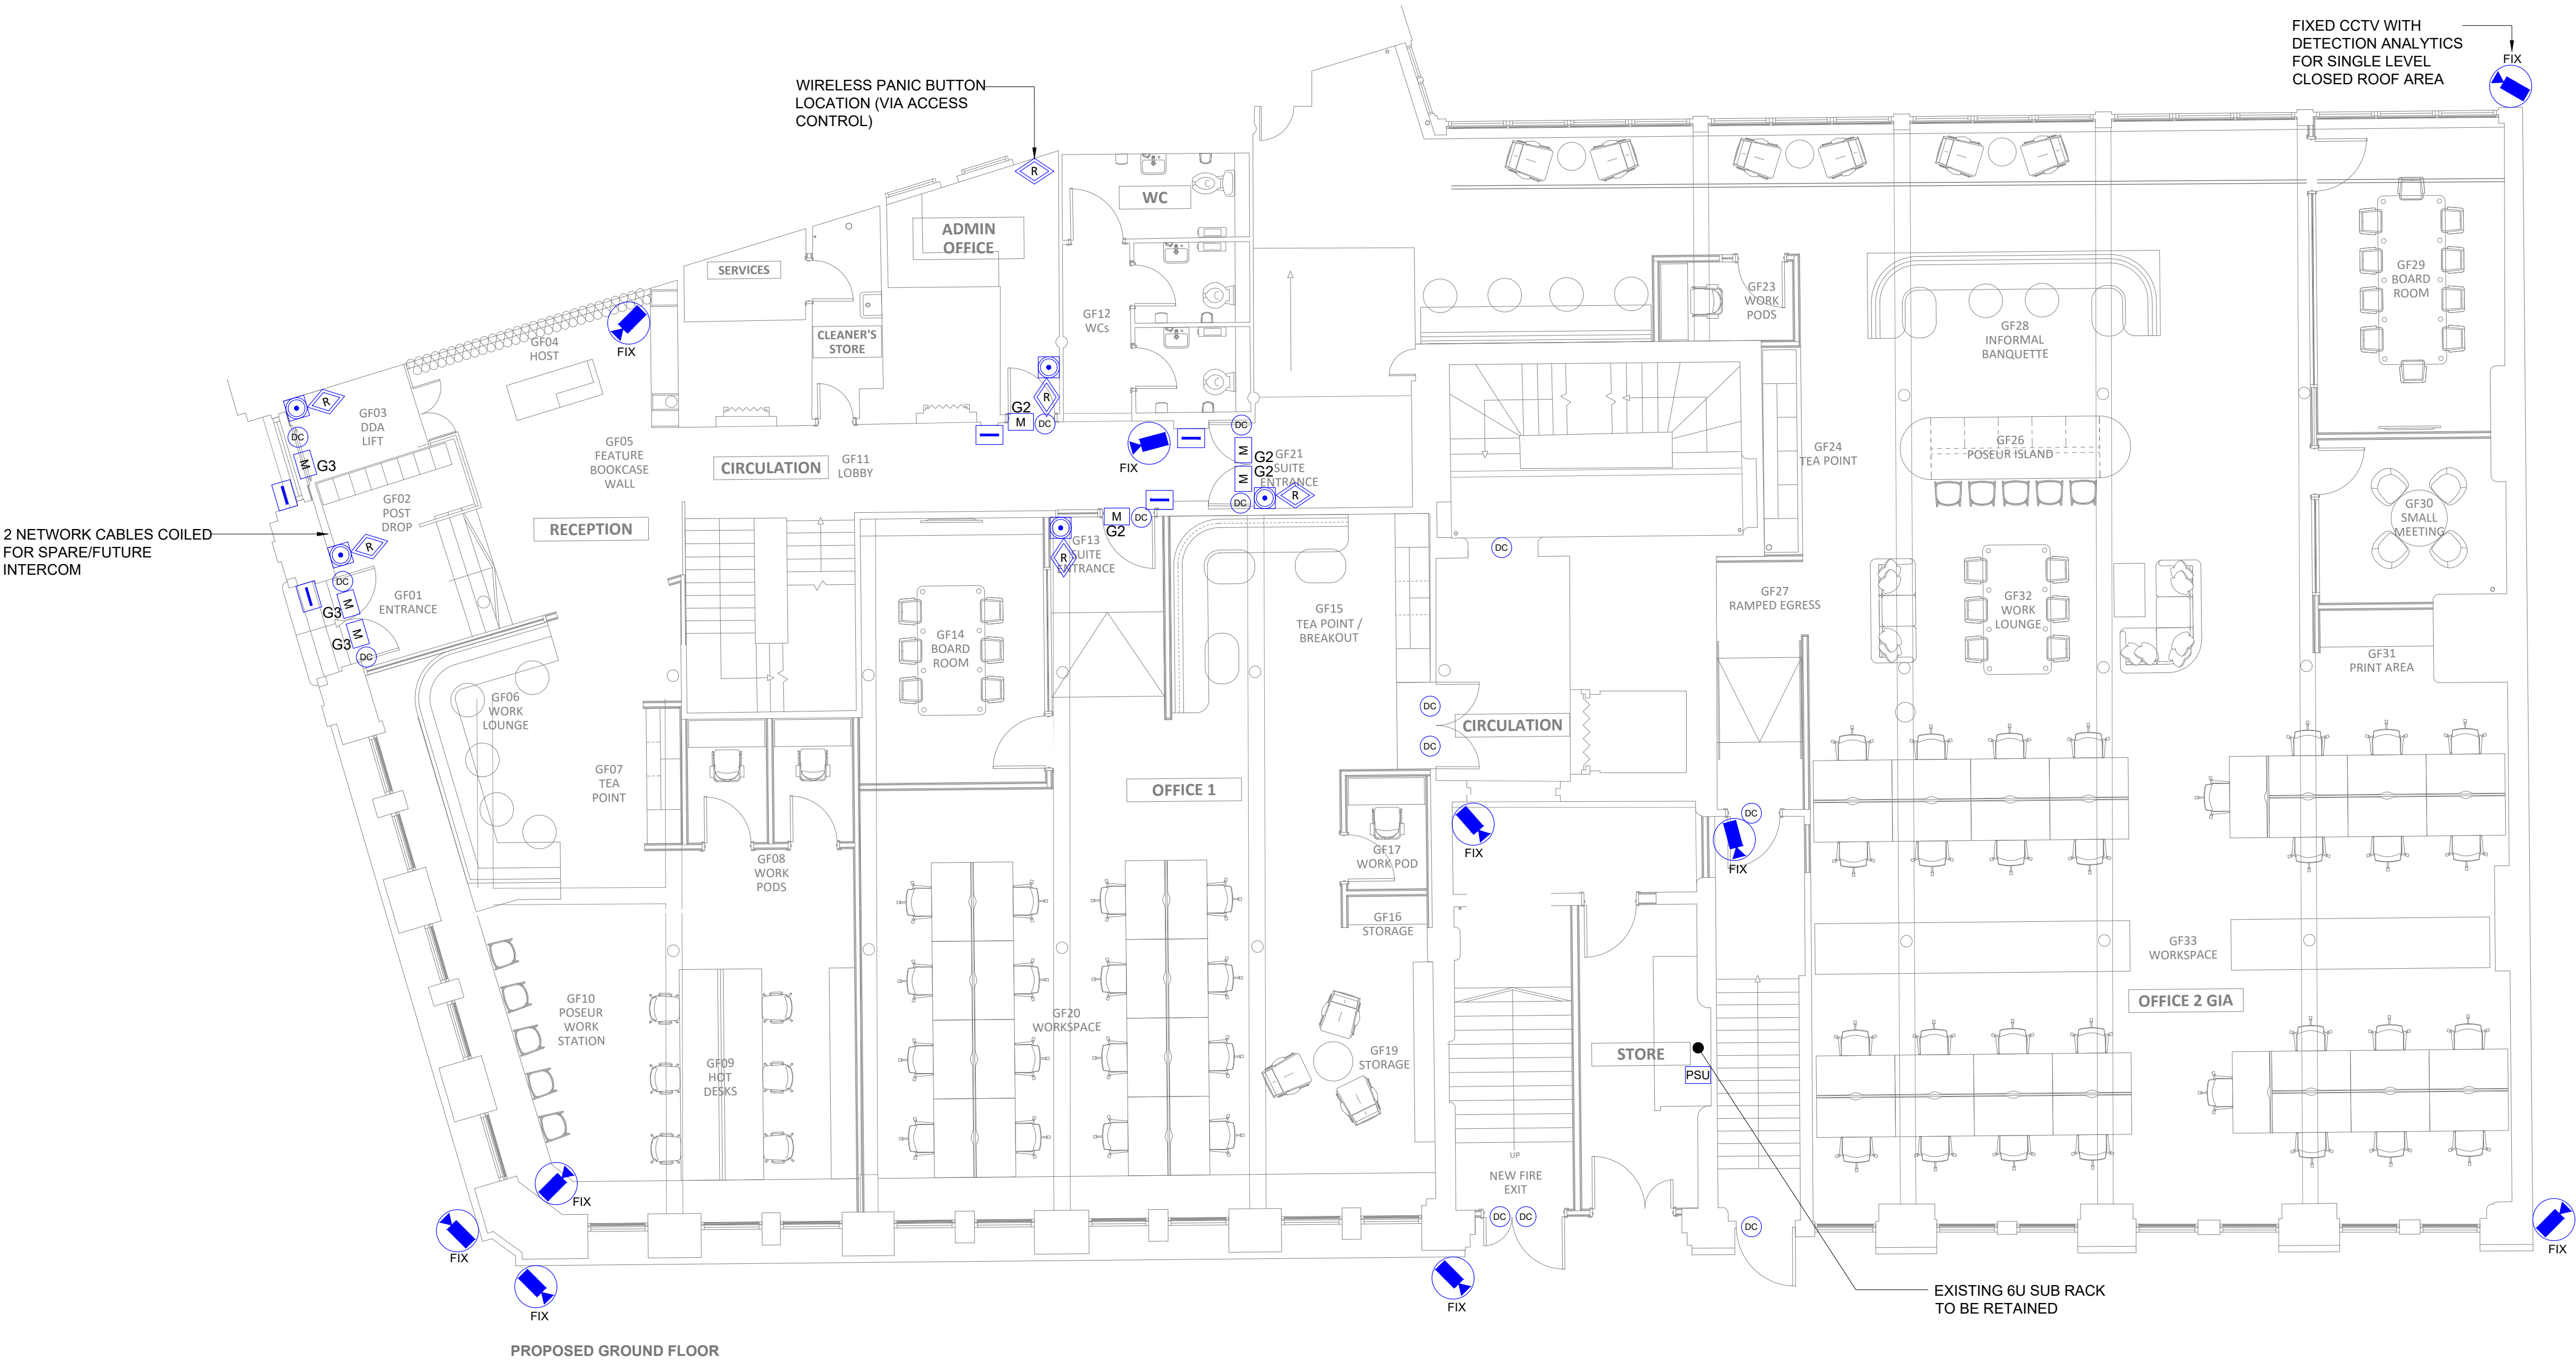

PROPOSED GROUND FLOOR

P1 ISSUE FOR PLANNING		LF	17.05.24
REV	DESCRIPTION	BY	DATE
KAIZEN Consulting Engineers www.kaizen-ce.come: info@kaizen-ce.com			
CLIENT			
bruntwood SciTech			
ARCHITECT			
A × I			
PROJECT			
117-119 PORTLAND STREET MANCHESTER			
DRAWING TITLE			
ELECTRICAL SERVICES GROUND FLOOR SECURITY LAYOUT			
CHECKED	DATE	DRAWN	SCALE
LF	FEB 24	MN	1:75@A1
STAGE 4			
DRAWING NUMBER		STATUS	REV.
1168-KCE-ZZ-00-DR-E-6801		S4	P1