


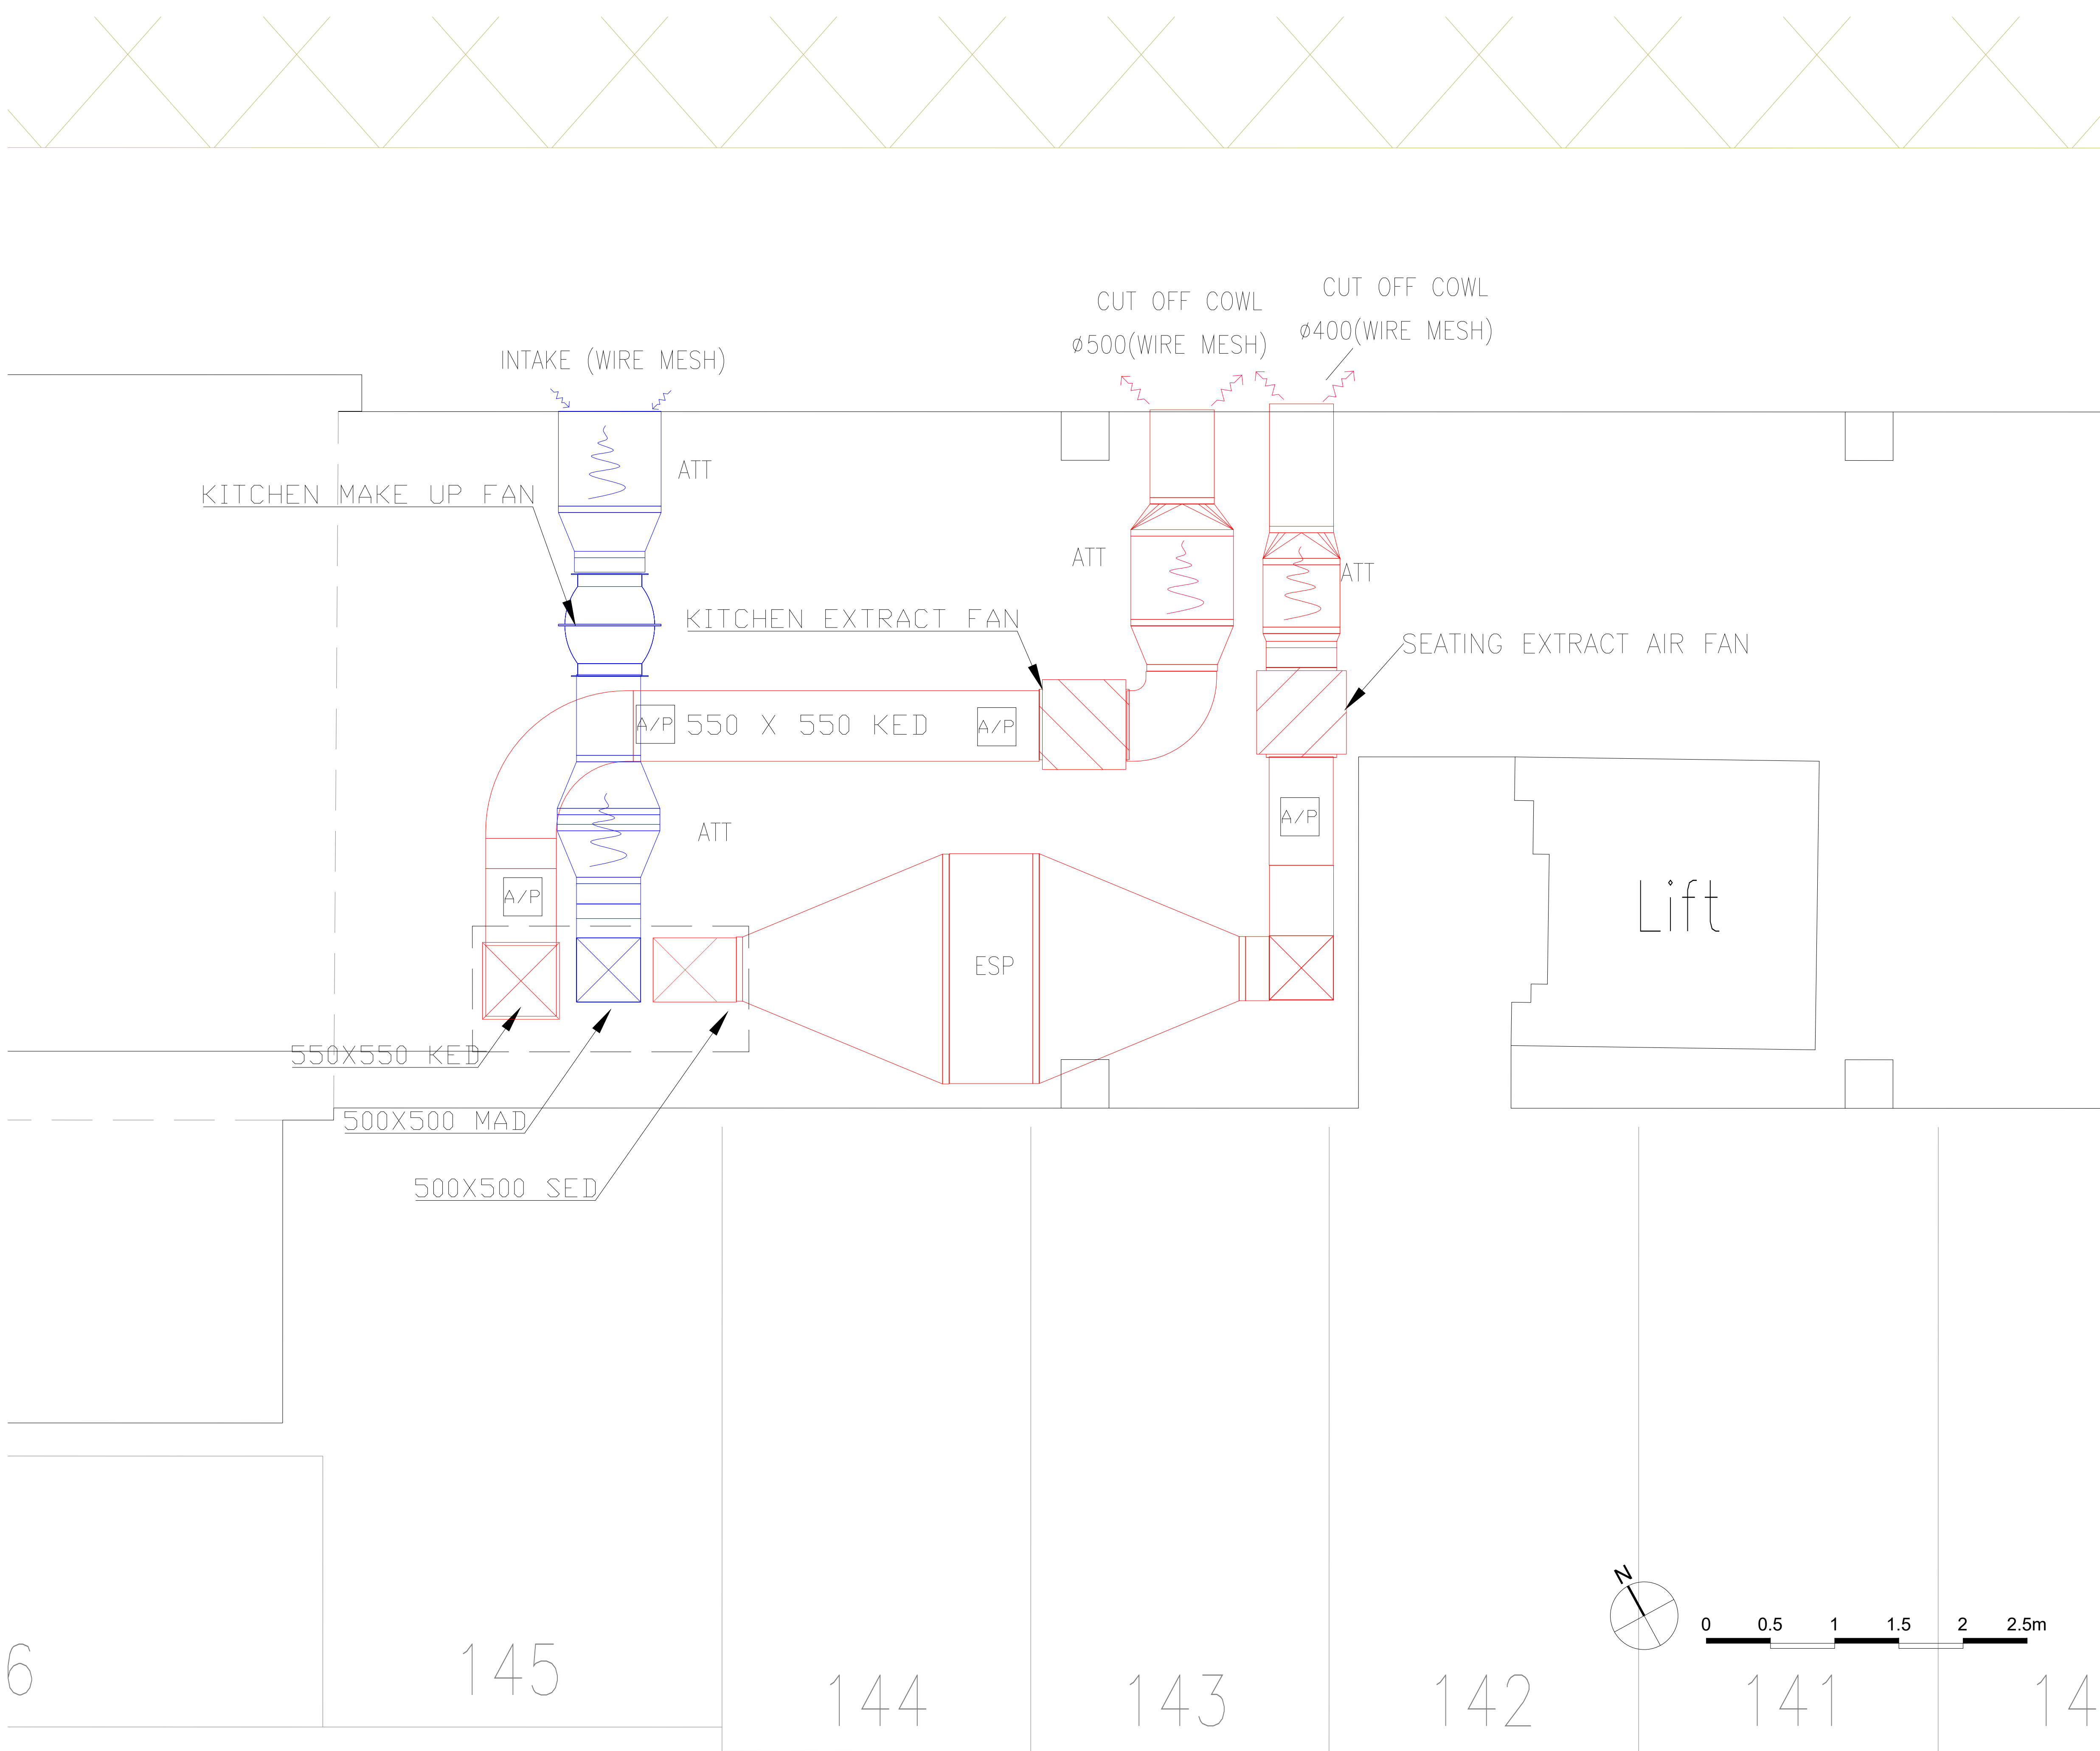

- NOTES:
- Legend
- KED – KITCHEN EXTRACT DUCT
 - MAF – MAKE UP AIR DUCT
 - SED – SEATING EXTRACT DUCT
 - FAD – FRESH AIR DUCT
 - ATT – ATTEUNATOR
 - F/B – FROM BELOW
 - T/B – TO BELOW
 - ESP – ELECTRO STATIC PRECIPITATOR
 - A/P – ACCESS PANEL

01	Updated as per Consultant comments
00	Tender Design
Ref	Revision

CLIENT

MAGURO GROUP

ARCHITECT

JAIA

CONSULTANT

SEA CONSULTING.CO.UK

CHARTERED BUILDING SERVICES ENGINEERS

Tel: +44 (0) 208 744 0544

Email: info@seaconsulting.co.uk

Project Title

BULLGOGI, MANCHESTER

Drawing Title

**ROOF (PLANT ROOM)
KITCHEN VENTILATION LAYOUT**

Scale	Drawn By	Checked By	Date	Sheet
1:25@A1	JS	AR	12.04.2024	1 OF 1
Drawing Number				
project	Originator	system	level	type
6150-SEA-ME-B-HVAC-MEP-003-B				