


LEGEND	
	NEW PIPEWORK
	EXISTING PIPEWORK
	CONDENSATE PIPEWORK
	FAN COIL UNIT

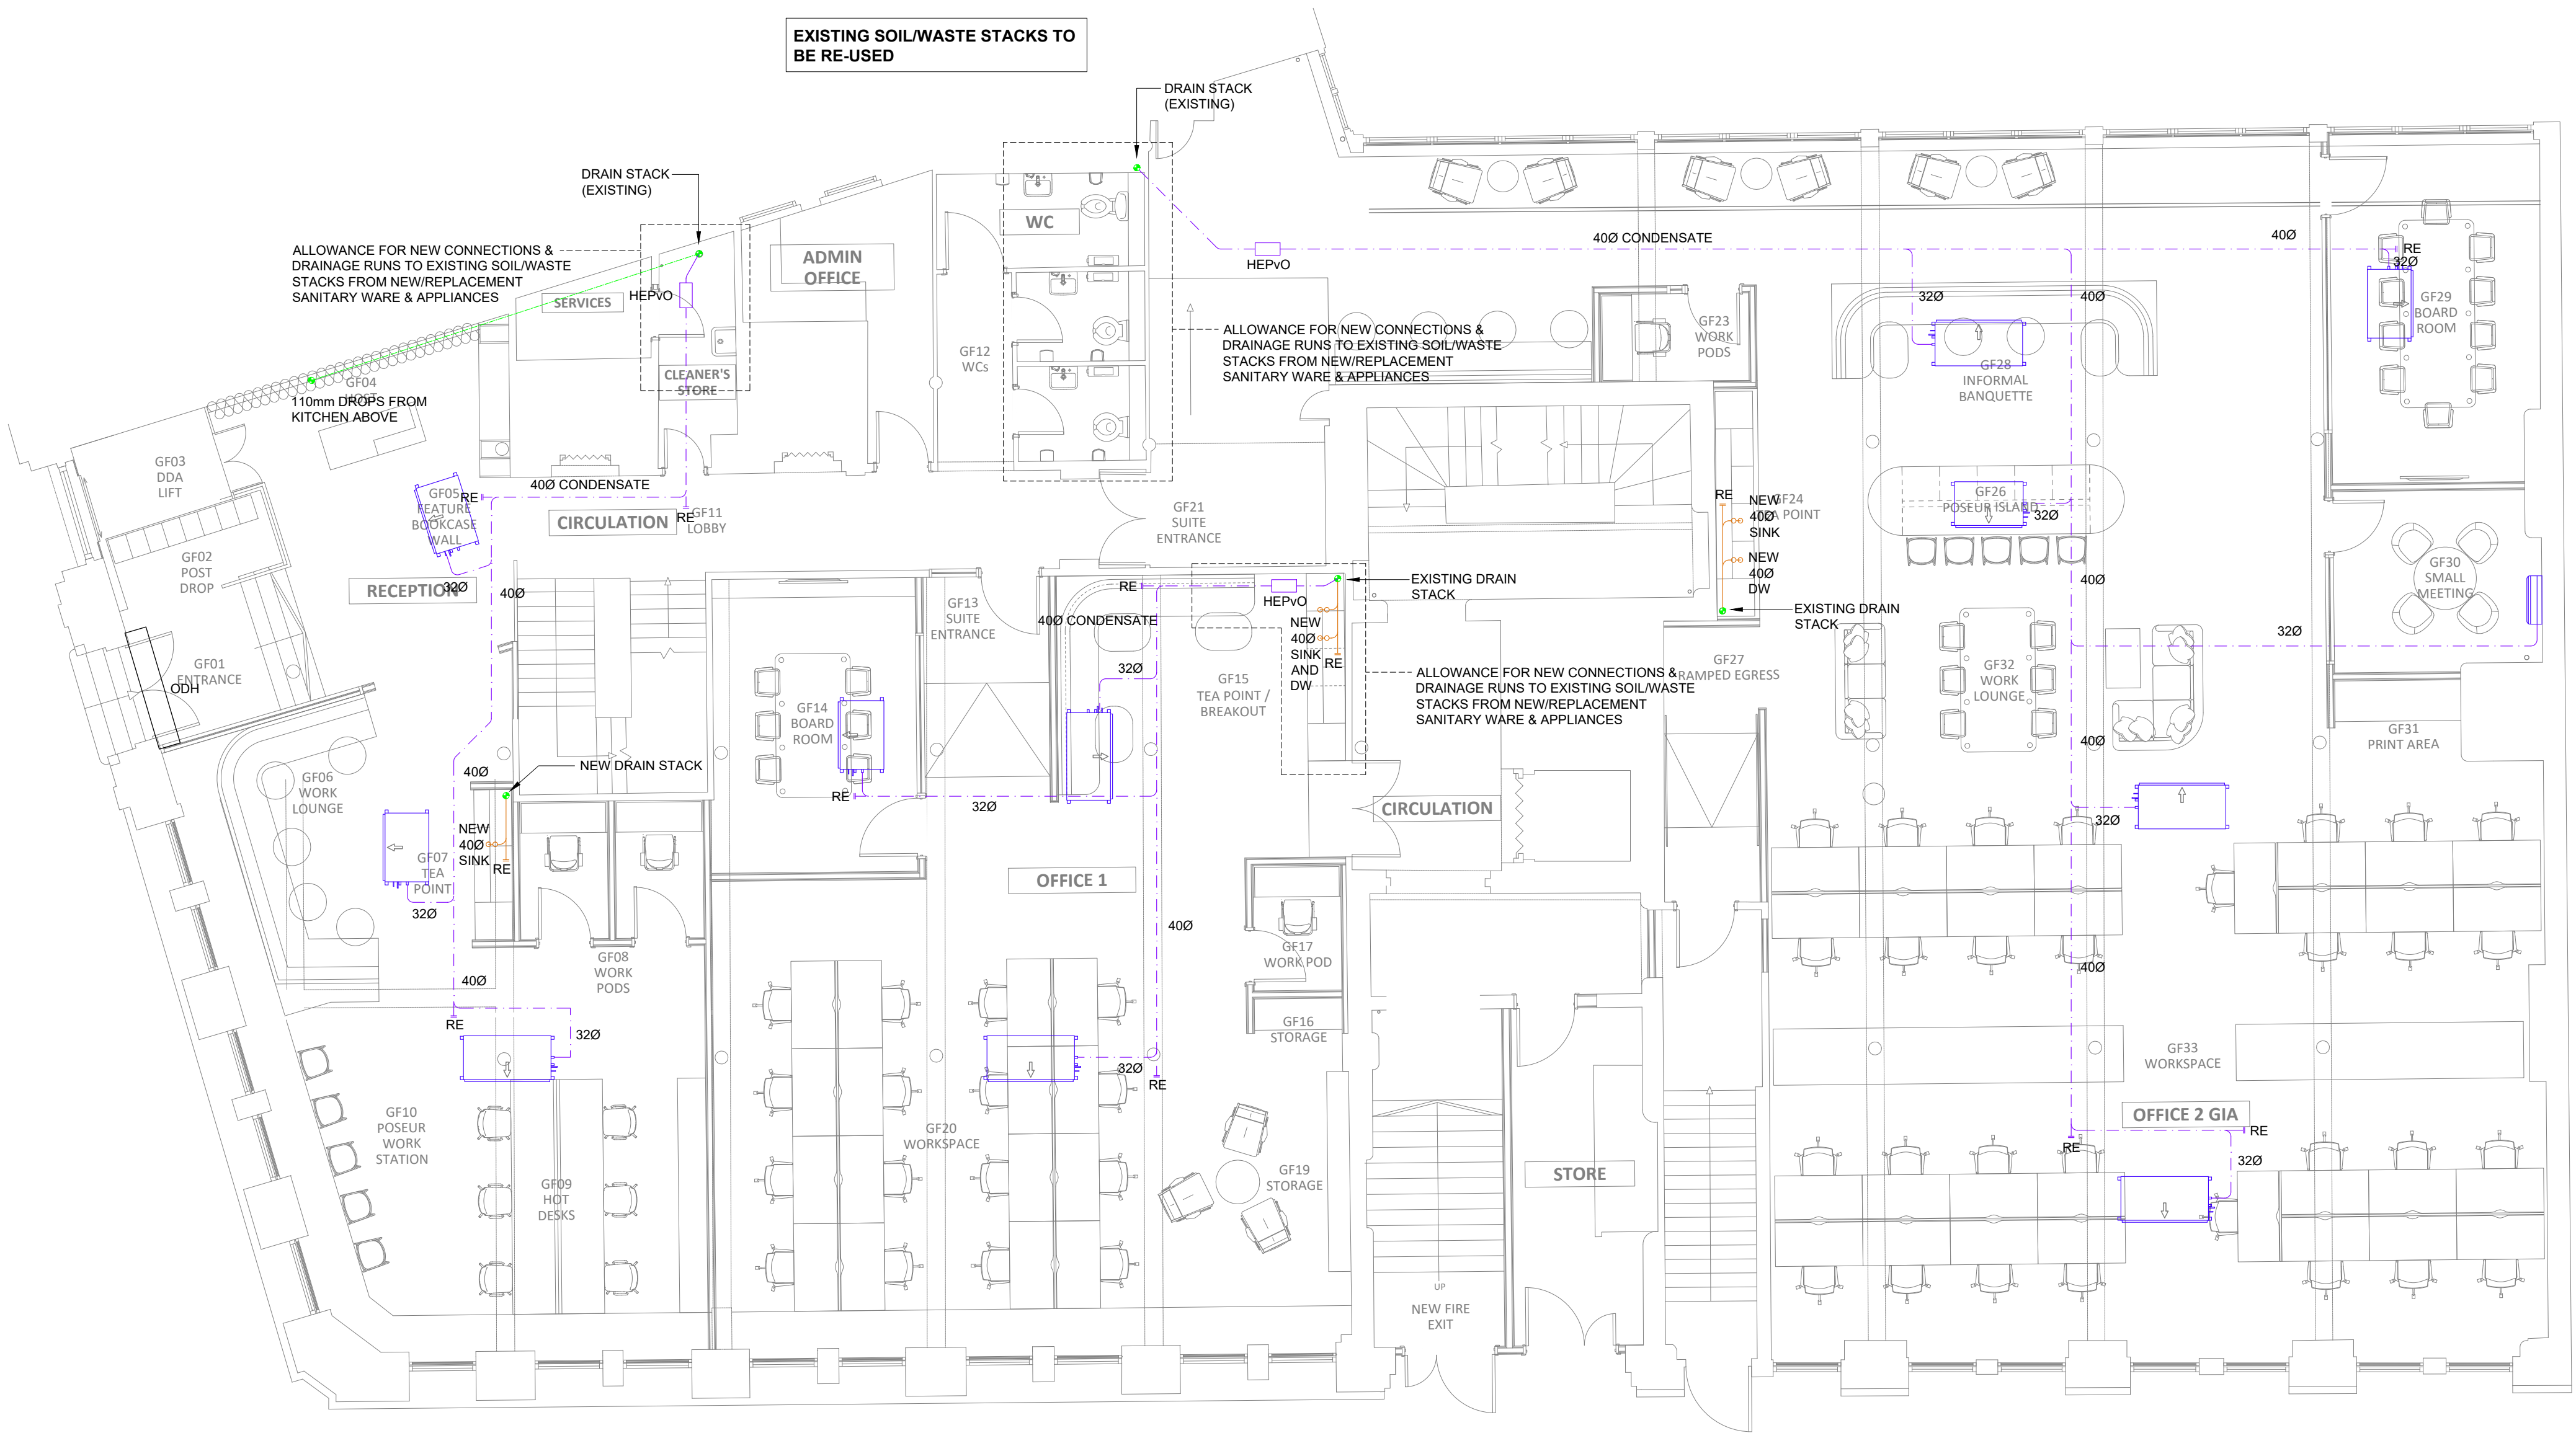

PROPOSED GROUND FLOOR

P1	ISSUE FOR PLANNING	SR	17.05.24
REV	DESCRIPTION	BY	DATE

KAIZEN
Consulting Engineers

www.kaizen-ce.com[e: info@kaizen-ce.com](mailto:info@kaizen-ce.com)

CLIENT

bruntwood
SciTech

ARCHITECT

A X I

PROJECT

117-119 PORTLAND STREET
MANCHESTER

DRAWING TITLE

MECHANICAL SERVICES
GROUND FLOOR
ABOVE GROUND DRAINAGE LAYOUT

CHECKED	DATE	DRAWN	SCALE
SR	FEB 24	MN	1:75@A1

STAGE 4			
DRAWING NUMBER	STATUS	REV.	
1168-KCE-ZZ-00-DR-M-5201	S4	P1	