

All dimensions are in millimetres unless stated otherwise. No dimensions to be scaled from drawings. All dimensions to be checked on site prior to manufacture.

Any discrepancies between drawings and site conditions are to be reported to the contract manager.

This drawing is to be read in conjunction with all relevant Structural Engineers and Mechanical & Electrical Engineers drawings and specification.

© COPYRIGHT
The copyright in this drawing is vested in OBI Property Ltd and no licence or assignment of any kind has been, or is, granted to any third party whether by provision of copies or originals of the drawings or otherwise unless otherwise agreed in writing.

Ceiling Finishes



Existing ceiling to remain

Ceiling Finishes



CF01 Dulux Paint Colour Tbc 0



CF02 Dulux Paint Colour Tbc TBC m2



CF03 Dulux Paint Colour Tbc TBC m2



CF04 Dulux Paint Colour Tbc TBC m2



CF05 Dulux Paint Colour rail 7024 Graphite Grey TBC m2

Ceiling Rails



CF04 SAS Mesh ceiling tiles TO BE PAINTED IN THE SAME COLOUR AS THE CEILING CF03 QTY 12 @ 1000 x 1500 QTY 3 @ 1500 x 1500



CF05 SAS Mesh ceiling tiles TO BE PAINTED IN THE SAME COLOUR AS THE CEILING CF03 QTY 0



CF05b SAS Mesh ceiling tiles TO BE PAINTED IN THE SAME COLOUR AS THE CEILING CF03 QTY 1



CF06 bespoke shaped Mesh ceiling tiles TO BE PAINTED IN THE SAME COLOUR AS THE CEILING CF03 QTY 3

Studio specification

Intelligent LED Lighting - Sound Reactive

4no ArtNet Integrated Driver - 2 output (will illuminate 1000 LED's)
8no 5m reel 12v RGB Addressable Pixel Strip -60 LED P/M (WS2815)
1no Madrix Key Basic software for (single pixel control)
20no 2m length deep extrusion (frosted extrusion)
1no INTEL 7 processor Laptop computer
Installation & Commissioning - 2 engineers - 4 days
Programming - 2 days

Wexer Virtual Fitness

1no 21" Wexer Virtual player, wall mounted
1no Cable set for the above Wexer
Installation & Commissioning - 2 engineers - 1 day

Large Screen Display

1no LG Commercial grade 75" display screen, c/w RS232 for automatic on/off when used with the Wexer Virtual Fitness.
1no Heavy duty mounting bracket for the above display
Installation & Commissioning - 1 engineer - 4 hours

Spin Room Audio Systems - Automatic Mute Connection to the existing Fire Alarm System

4no JBL Control pendant speakers
1no 12U Wall mounted lockable equipment rack c/w 1U; 2U & 3U
Rack shelves, 6 way power bar & rack screws
1no QSC Amplifier with relay connection to the existing fire alarm
1no Cable set
Installation & commissioning - 2 engineers - 3

Please note, we will have to liaise with the mirror manufacturer to ensure the depth and spacing between each mirror is correct, so that we can flush mount the Intelligent Lighting correctly.

Wall Lights



LF11 Buster and Punch Hooked wall / nude graphite brass crystal bulbs QTY 0



LF11A Buster and Punch Hooked wall / nude graphite / smoked bronze with crystal bulbs QTY 0



LF12 up down wall lights Project collection products - strand OD-STR-G QTY 0



LF13 up down wall lights Project collection products - mayfair OD-MAY-G QTY 8



LF06c Intelligent LED Lighting - Sound Reactive QTY 4

Projector



LF14 Projected Letters (LG) QTY 1
LF14b Projected bike store logo QTY 1

Other Lights



LF15 Linear strip light - to illuminate the lifts QTY 0




LF16 BLACK aluminum extrusion u profile for glass channel k-slot, LED Profile Edge Strip light for the glass screen to be housed within QTY 0



LF17 Buster and Punch caged wall X-large LED Marble black QTY 2



LF18 CIRCLE LIGHT QTY 0

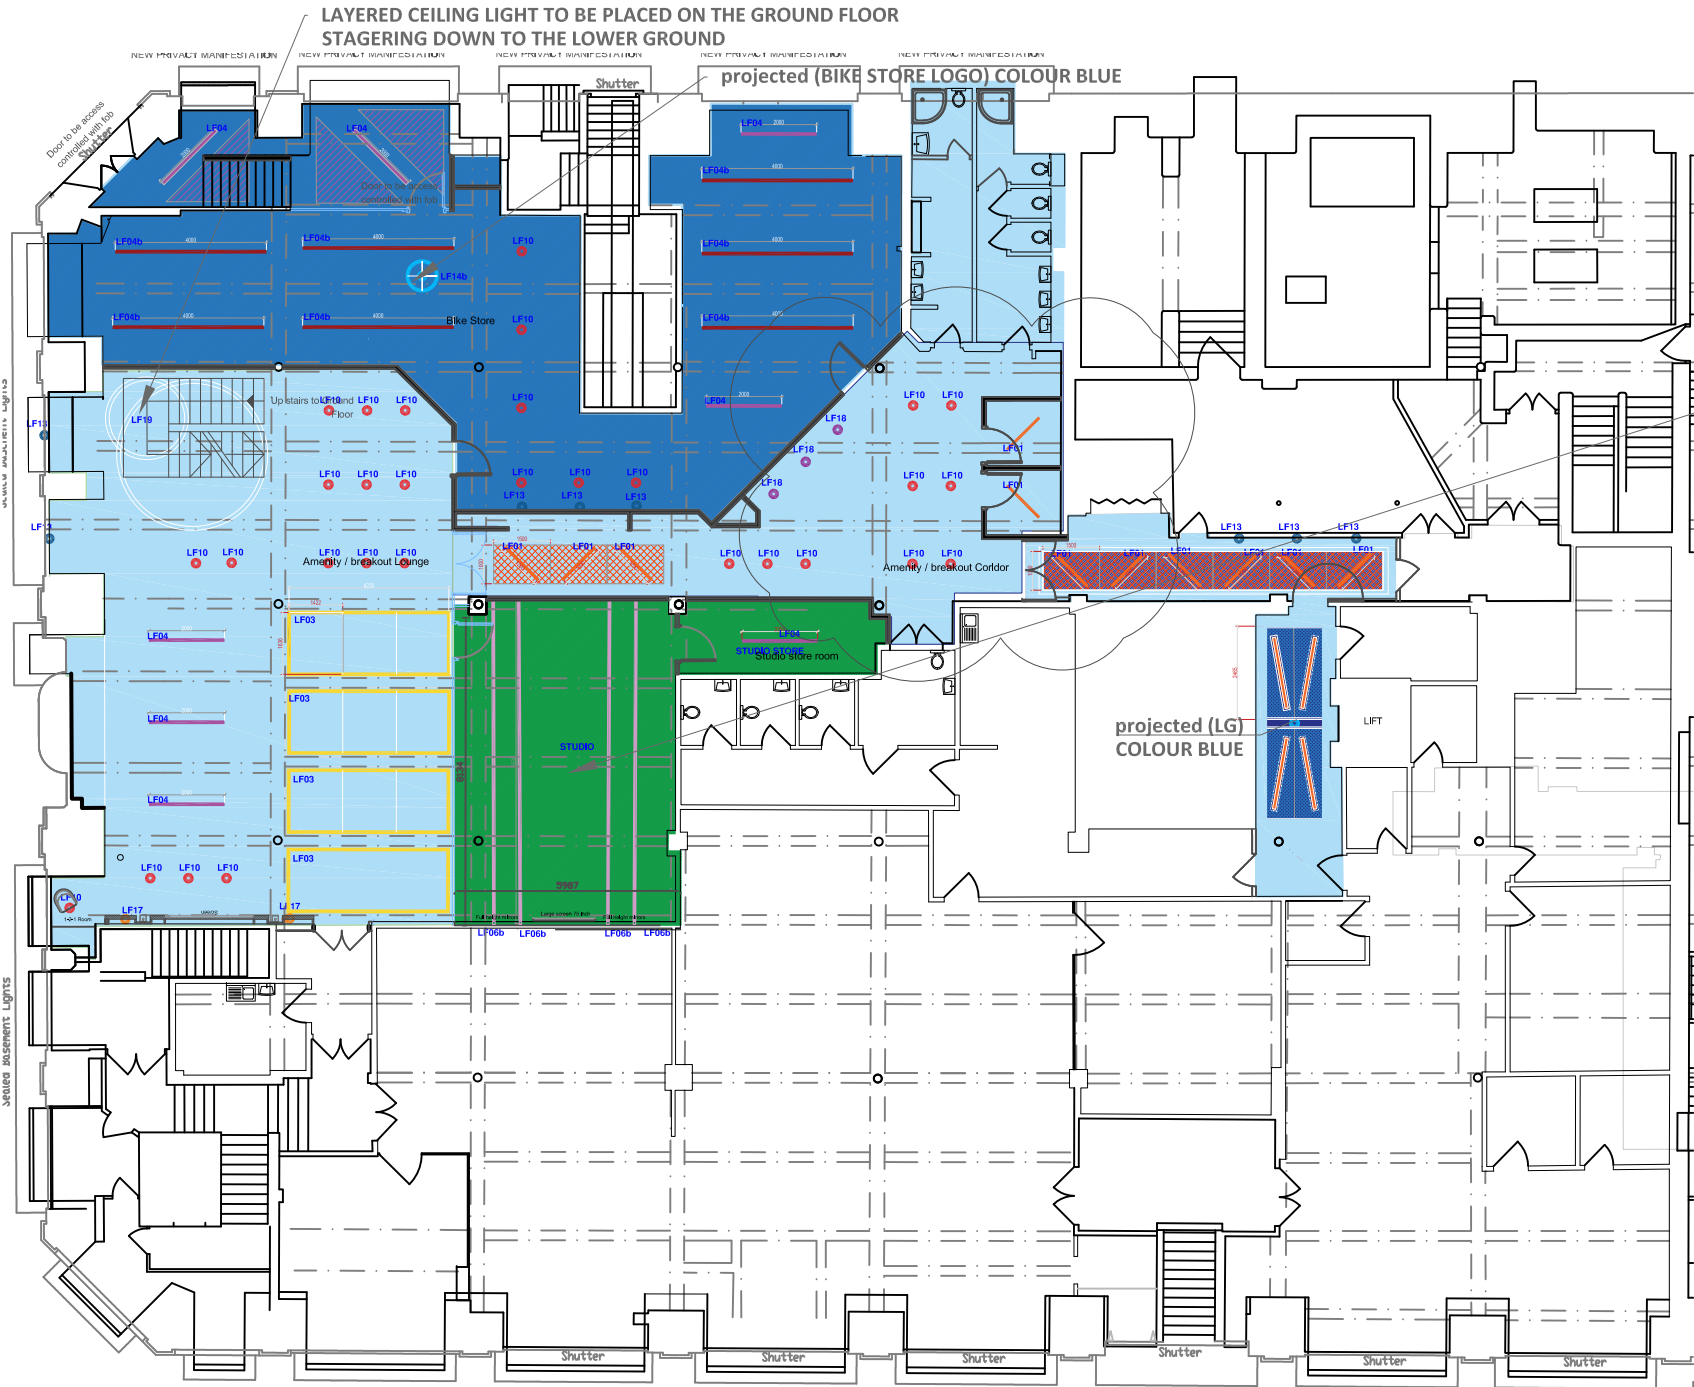

PHASE 1
scale 1/200



Lighting



LF01 TBC - 1200L Black lights QTY 11



LF02 TBC - 800L Black lights QTY 4



LF03 Black linear light continuous length QTY 6



LF04 Black linear light QTY 8



LF04b Black linear light QTY 7



LF05 Blue Coloured light TBC QTY 0



LF06 White Coloured light TBC QTY 0



LF06b Intelligent LED Lighting - Sound Reactive QTY 4

Feature Pendants



LF07 Buster and Punch Heavy Metal Cross Steel with crystal TUBE bulbs QTY 1



LF07A Buster and Punch Heavy Metal Linear Burnt Steel with crystal TUBE bulbs QTY 0



LF07B Buster and Punch Heavy Metal Cross Black with crystal TUBE bulbs QTY 0



LF08 Buster and Punch caged with extension kit QTY 0



LF08A Buster and Punch caged QTY 0



LF09 Buster and Punch exhaust pendant graphite Brass QTY 0



LF10 Buster and Punch exhaust surface Graphite burnt steel QTY 31



LF18 Buster and Punch EXHAUST SPOT / LINEAR / GRAPHITE / BURNT STEEL QTY 3

D	Area Updated	11/01/23	RG
C	Area Updated	03/11/23	RG
B	UPDATED CORRIDOR	17/10/23	RG
A	UPDATED CORRIDOR	15/10/23	RG
-	First issue	20/09/23	RG

REV	DESCRIPTION	DATE	BY	CHK
-----	-------------	------	----	-----

CLIENT NAME

Philip J Davies Holdings plc

PROJECT NAME

Sevendale House

DWG TITLE:
Ground Floor - Reflective Ceiling Plan

DWG NO: 14_001 REVISION: -
SCALE 1 : 200 @A3 DRAWN: RG

DWG STATUS:
TENDER

© OBI Property Limited
80 Mosley Street, Manchester, M2 3FX
t: 0161 237 1717 e: info@obiproperty.co.uk

