


AS EXISTING SITE PLAN

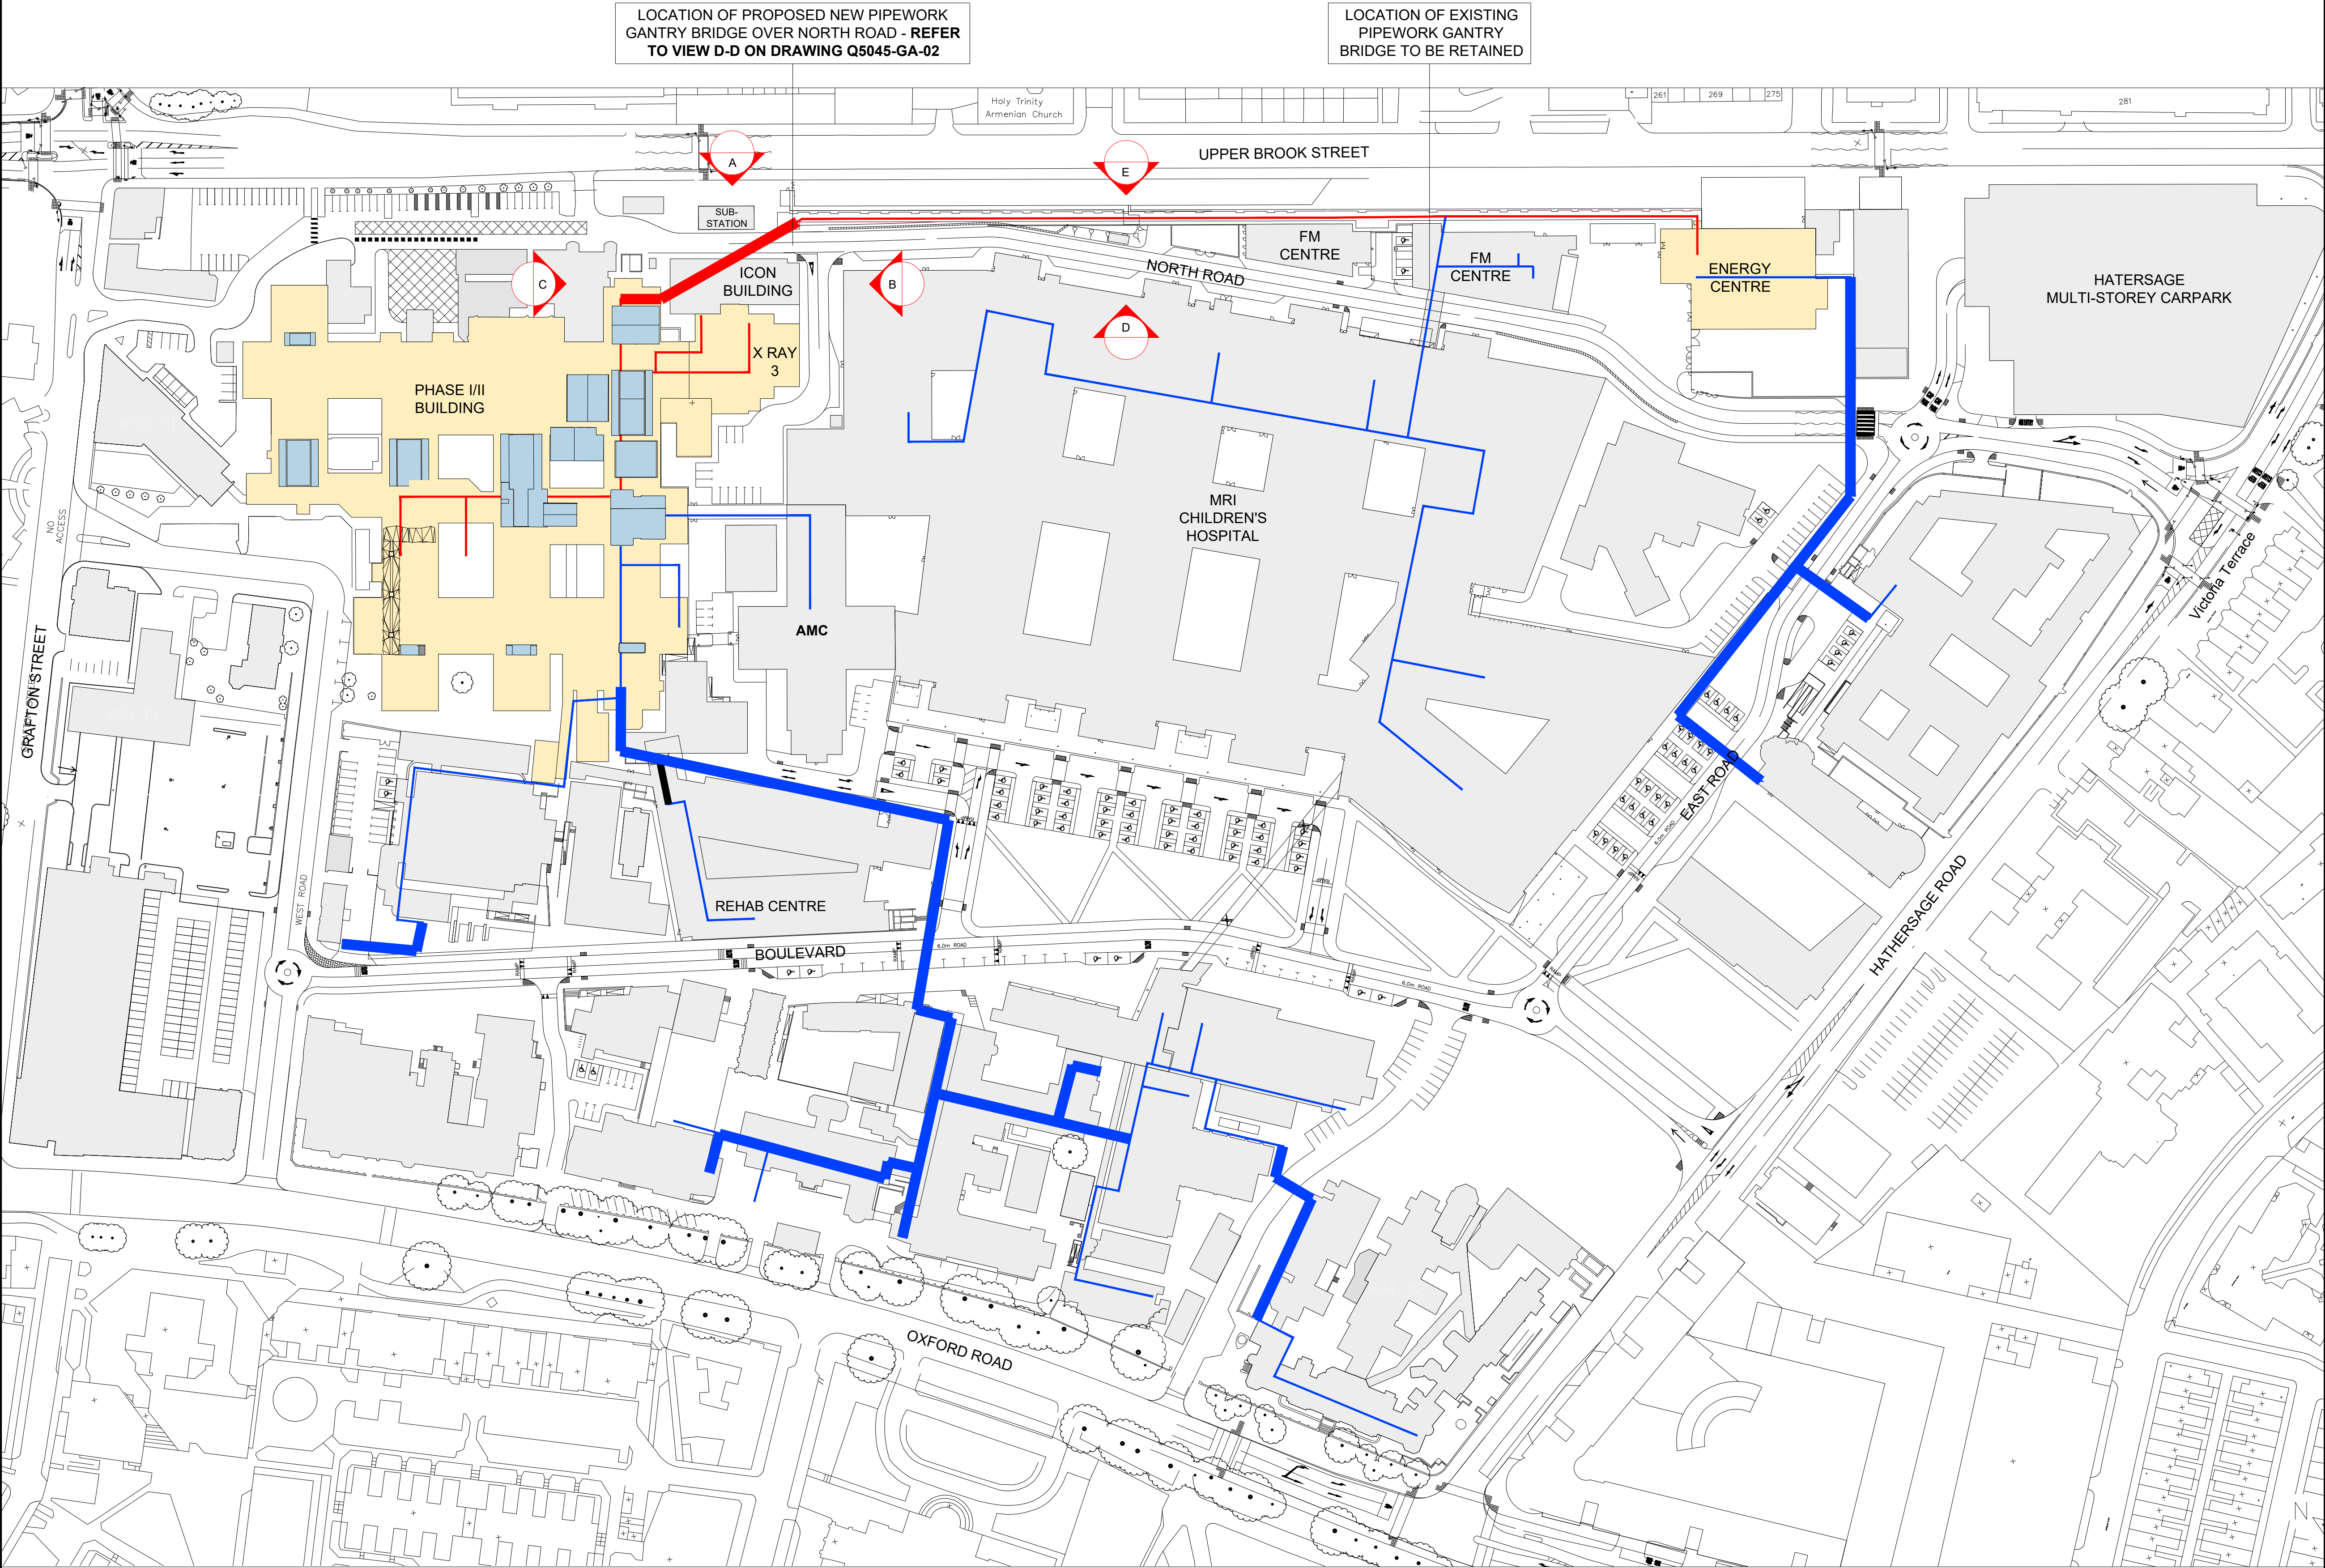

Note:
Contractor is to verify all dimensions and levels on site prior to site works commencement. Under no circumstances are any dimensions or levels to be scaled from this drawing number for the purpose of manufacturing components. Contractor to report any discrepancies to the Designer.

KEY:

- MANCHESTER UNIVERSITY NHS FOUNDATION TRUST BUILDINGS NOT ASSOCIATED WITH APPLICATION
- EXTENT OF BUILDINGS ASSOCIATED WITH PROPOSED SCHEME OF PIPEWORK REPLACEMENT WORKS
- EXTENT OF EXISTING ROOFTOP PLANTROOMS TO PHASE I/II BUILDING TO RECEIVE NEW STEAMLINE CONNECTIONS
- EXTENT OF EXISTING ABOVE GROUND SERVICE CORRIDOR HOUSING EXISTING STEAMLINE PIPEWORK RUNNING BETWEEN THE ENERGY CENTRE BUILDING AND THE FM CENTRE / PHASE I/II MRI BUILDING. TO BE RETAINED & NEW PIPEWORK MOUNTED ABOVE
- ROUTE OF EXISTING STEAMLINE PIPEWORK TO BE RETAINED
- ROUTE OF EXISTING BELOW GROUND SERVICE DUCT HOUSING STEAMLINE PIPEWORK TO BE RETAINED
- ROUTE OF EXISTING STEAMLINE PIPEWORK TO BE MADE REDUNDANT BY PROPOSED WORKS & REPLACED BY NEW STEAMLINE TO SERVE VARIOUS ROOFTOP PLANTROOMS
- ROUTE OF EXISTING BELOW GROUND SERVICE DUCT HOUSING STEAMLINE PIPEWORK TO BE MADE REDUNDANT BY PROPOSED WORKS & REPLACED BY NEW ABOVE GROUND PIPEWORK MOUNTED ABOVE

REVISION		DESCRIPTION		DATE
--		PLANNING		JUNE 24
SCALE	1:1000		SIGNATURE	DATE
		DRAWN	MP	JUNE 24
		CHECKED	MB	JUNE 24
ORIGINAL SIZE	A1	APPROVED	MB	JUNE 24
This drawing is copyright and may not be reproduced or made use of unless expressly agreed by M Bradbury Consulting Ltd				
CLIENT		CM Oxendale Ltd Unit 5 Dorian Court Alan Ramsbottom Way Great Harwood Blackburn BB6 7UR		
PROJECT		Manchester Royal Infirmary, Oxford Road, Manchester, M13 9WL Steamline Replacement Scheme		
<div> Bradbury CONSULTING CHARTERED SURVEYORS</div> <div>59 Wilmslow Road, Handforth, Cheshire, SK9 3EN</div> <div>WEB: www.bradbury-consulting.co.uk TEL: 01625 522 209</div>				
TITLE		AS EXISTING SITE PLAN		
JOB NUMBER		2022.096		
DRAWING NUMBER		2022.096.PL02		