


NOTES:

- THIS DRAWING IS TO BE READ IN CONJUNCTION WITH ALL OTHER RELEVANT PROJECT DRAWINGS AND THE PROJECT SPECIFICATION.
- ALL GAS TO BE INSTALLED IN ACCORDANCE WITH THE CURRENT GAS REGULATIONS.
- GAS PIPE WORK TO BE CONSTRUCTED OF STEEL AND PAINTED YELLOW. ALL GAS PIPE WORK SHALL BE VISIBLE OR RUN WITHIN VENTILATED SHAFTS OR PIPE IN PIPE. ANY PIPE WORK RUNNING THROUGH PROTECTED AREAS SHALL BE PROVIDED WITH THE REQUIRED FIRE PROTECTION BASED UPON THE FIRE CONSULTANTS FIRE STRATEGY. WHERE PIPE WORKS SIZES ALLOW GAS PIPE WORK TO BE INSTALLED FREE FROM JOINTS AND ENCLOSED WITH A GAS TIGHT SLEEVE AS PER 'TRACPIPE' OR SIMILAR APPROVED, KEEPING BENDS TO A MINIMUM.
- A GAS SAFETY CONTROL SYSTEM SHALL BE INSTALLED INTERLINKED TO THE FIRE ALARM SYSTEM WHICH WILL CUT THE SUPPLY OF GAS TO THE KITCHEN AND LEVEL 08 GAS WATER HEATERS, IF THE BUILDING GOES INTO A LIFE SAFETY MODE.

LEGEND:

- PV PURGE VALVE
- TP TEST POINT
- GC GAS COCK
- 2 PORT SHUT OFF VALVE

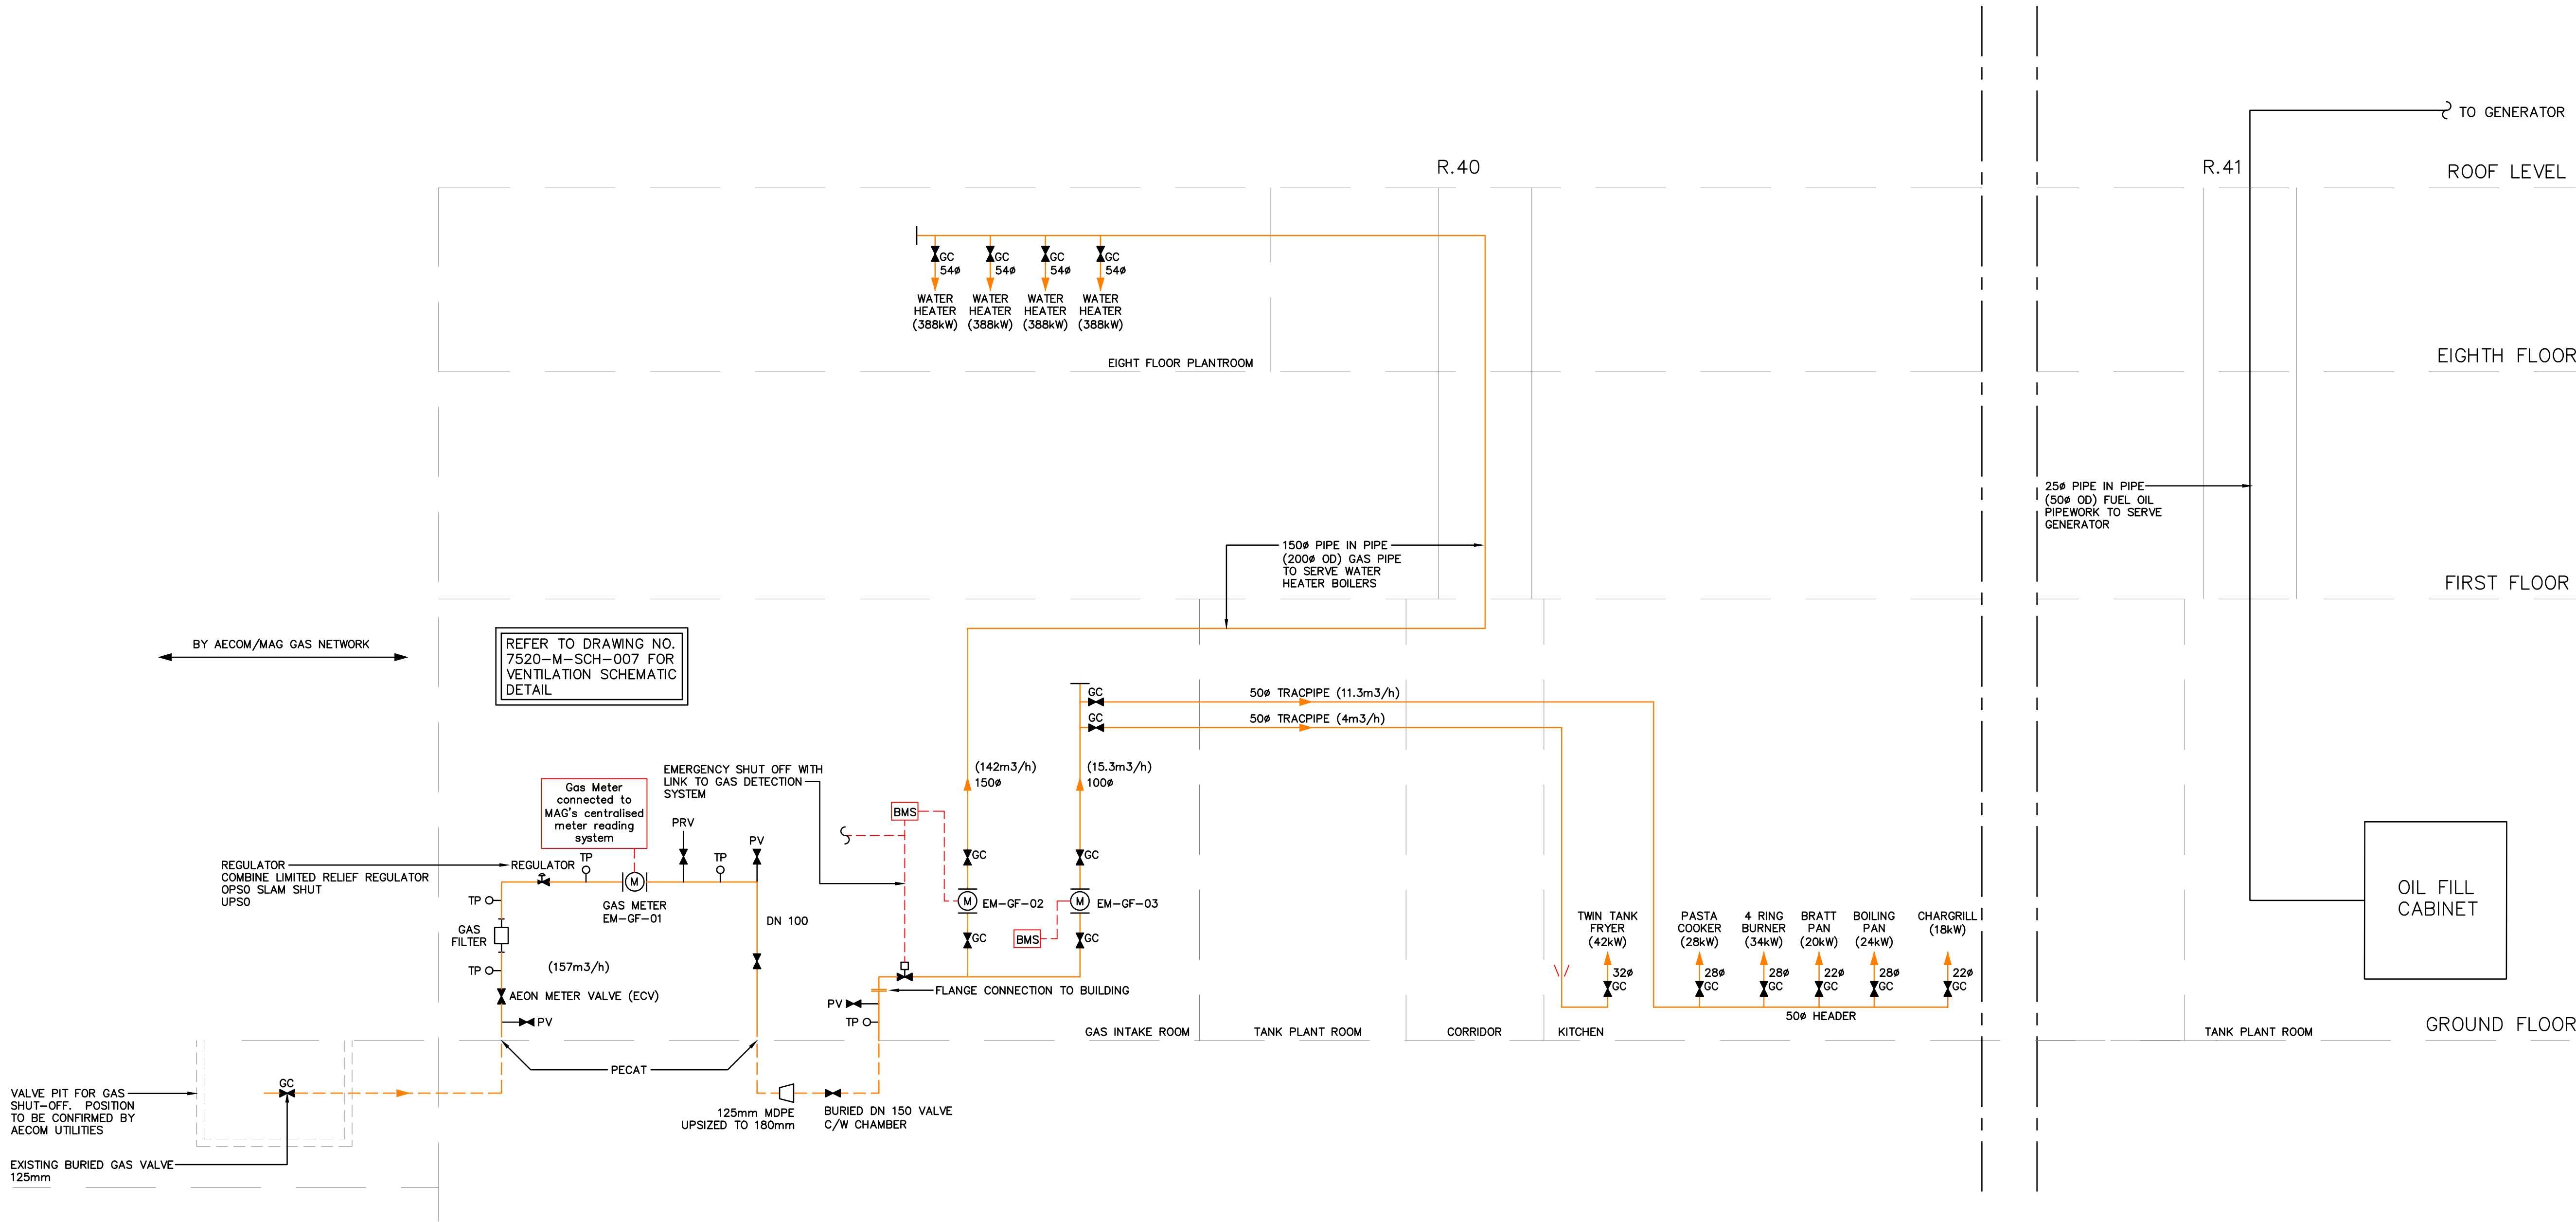

This Drawing was based upon the following drawings.					
Architects :	Revision				
.	.	.	.	.	.
Consultants :					
20250-Q00A-H3-ZZ-DR-M-0141	T	.	.	.	.

C3	UPDATED TO SUIT SUB-CONTRACTOR'S EXTERNAL PROPOSAL.	19/10/23	CL
C2	UPDATED TO SUIT AP KITCHEN EQUIPMENT SCHEDULE	03/10/23	CL
C1	STATUS A RECEIVED. ISSUED FOR CONSTRUCTION	21/09/22	CL
A2	GAS DEMAND RATES ADDED.	13/09/22	CL
A1	FOR APPROVAL	30/08/22	CL
Rev	DESCRIPTION	DATE	CHKD



MY CONSTRUCTION LIMITED
28 St Albans Lane, London NW11 7QE.
Tel: 020 8450 5747, Fax: 020 8450 0707, email: info@myconstruction.co.uk

Client:

MAG

Architect:

Dexter Moren Associates
57d Jamestown Road
London NW1 7DB

Project:

Tribe
Manchester Airport
Plot H3

Title:

**MECHANICAL SERVICES
GAS & FUEL OIL SERVICES
SCHEMATIC**

Drawn: dds7520	Date: Aug'22	Scale: NTS@A1	Checked: .	Auth: .
-------------------	-----------------	------------------	---------------	------------

Project No: 7520	Drawing No: M-SCH-002	Rev: C3
----------------------------	---------------------------------	-------------------

Status:

FOR CONSTRUCTION