


NOTES

1. THIS DRAWING SHALL BE READ IN CONJUNCTION WITH STUDIO DEKKA LIGHTING LAYOUT AND ARCHITECTS
DRAWINGS FOR DETAILS IN TERMS OF EQUIPMENT POSITIONS AND PROPOSED WORKS BY OTHERS.

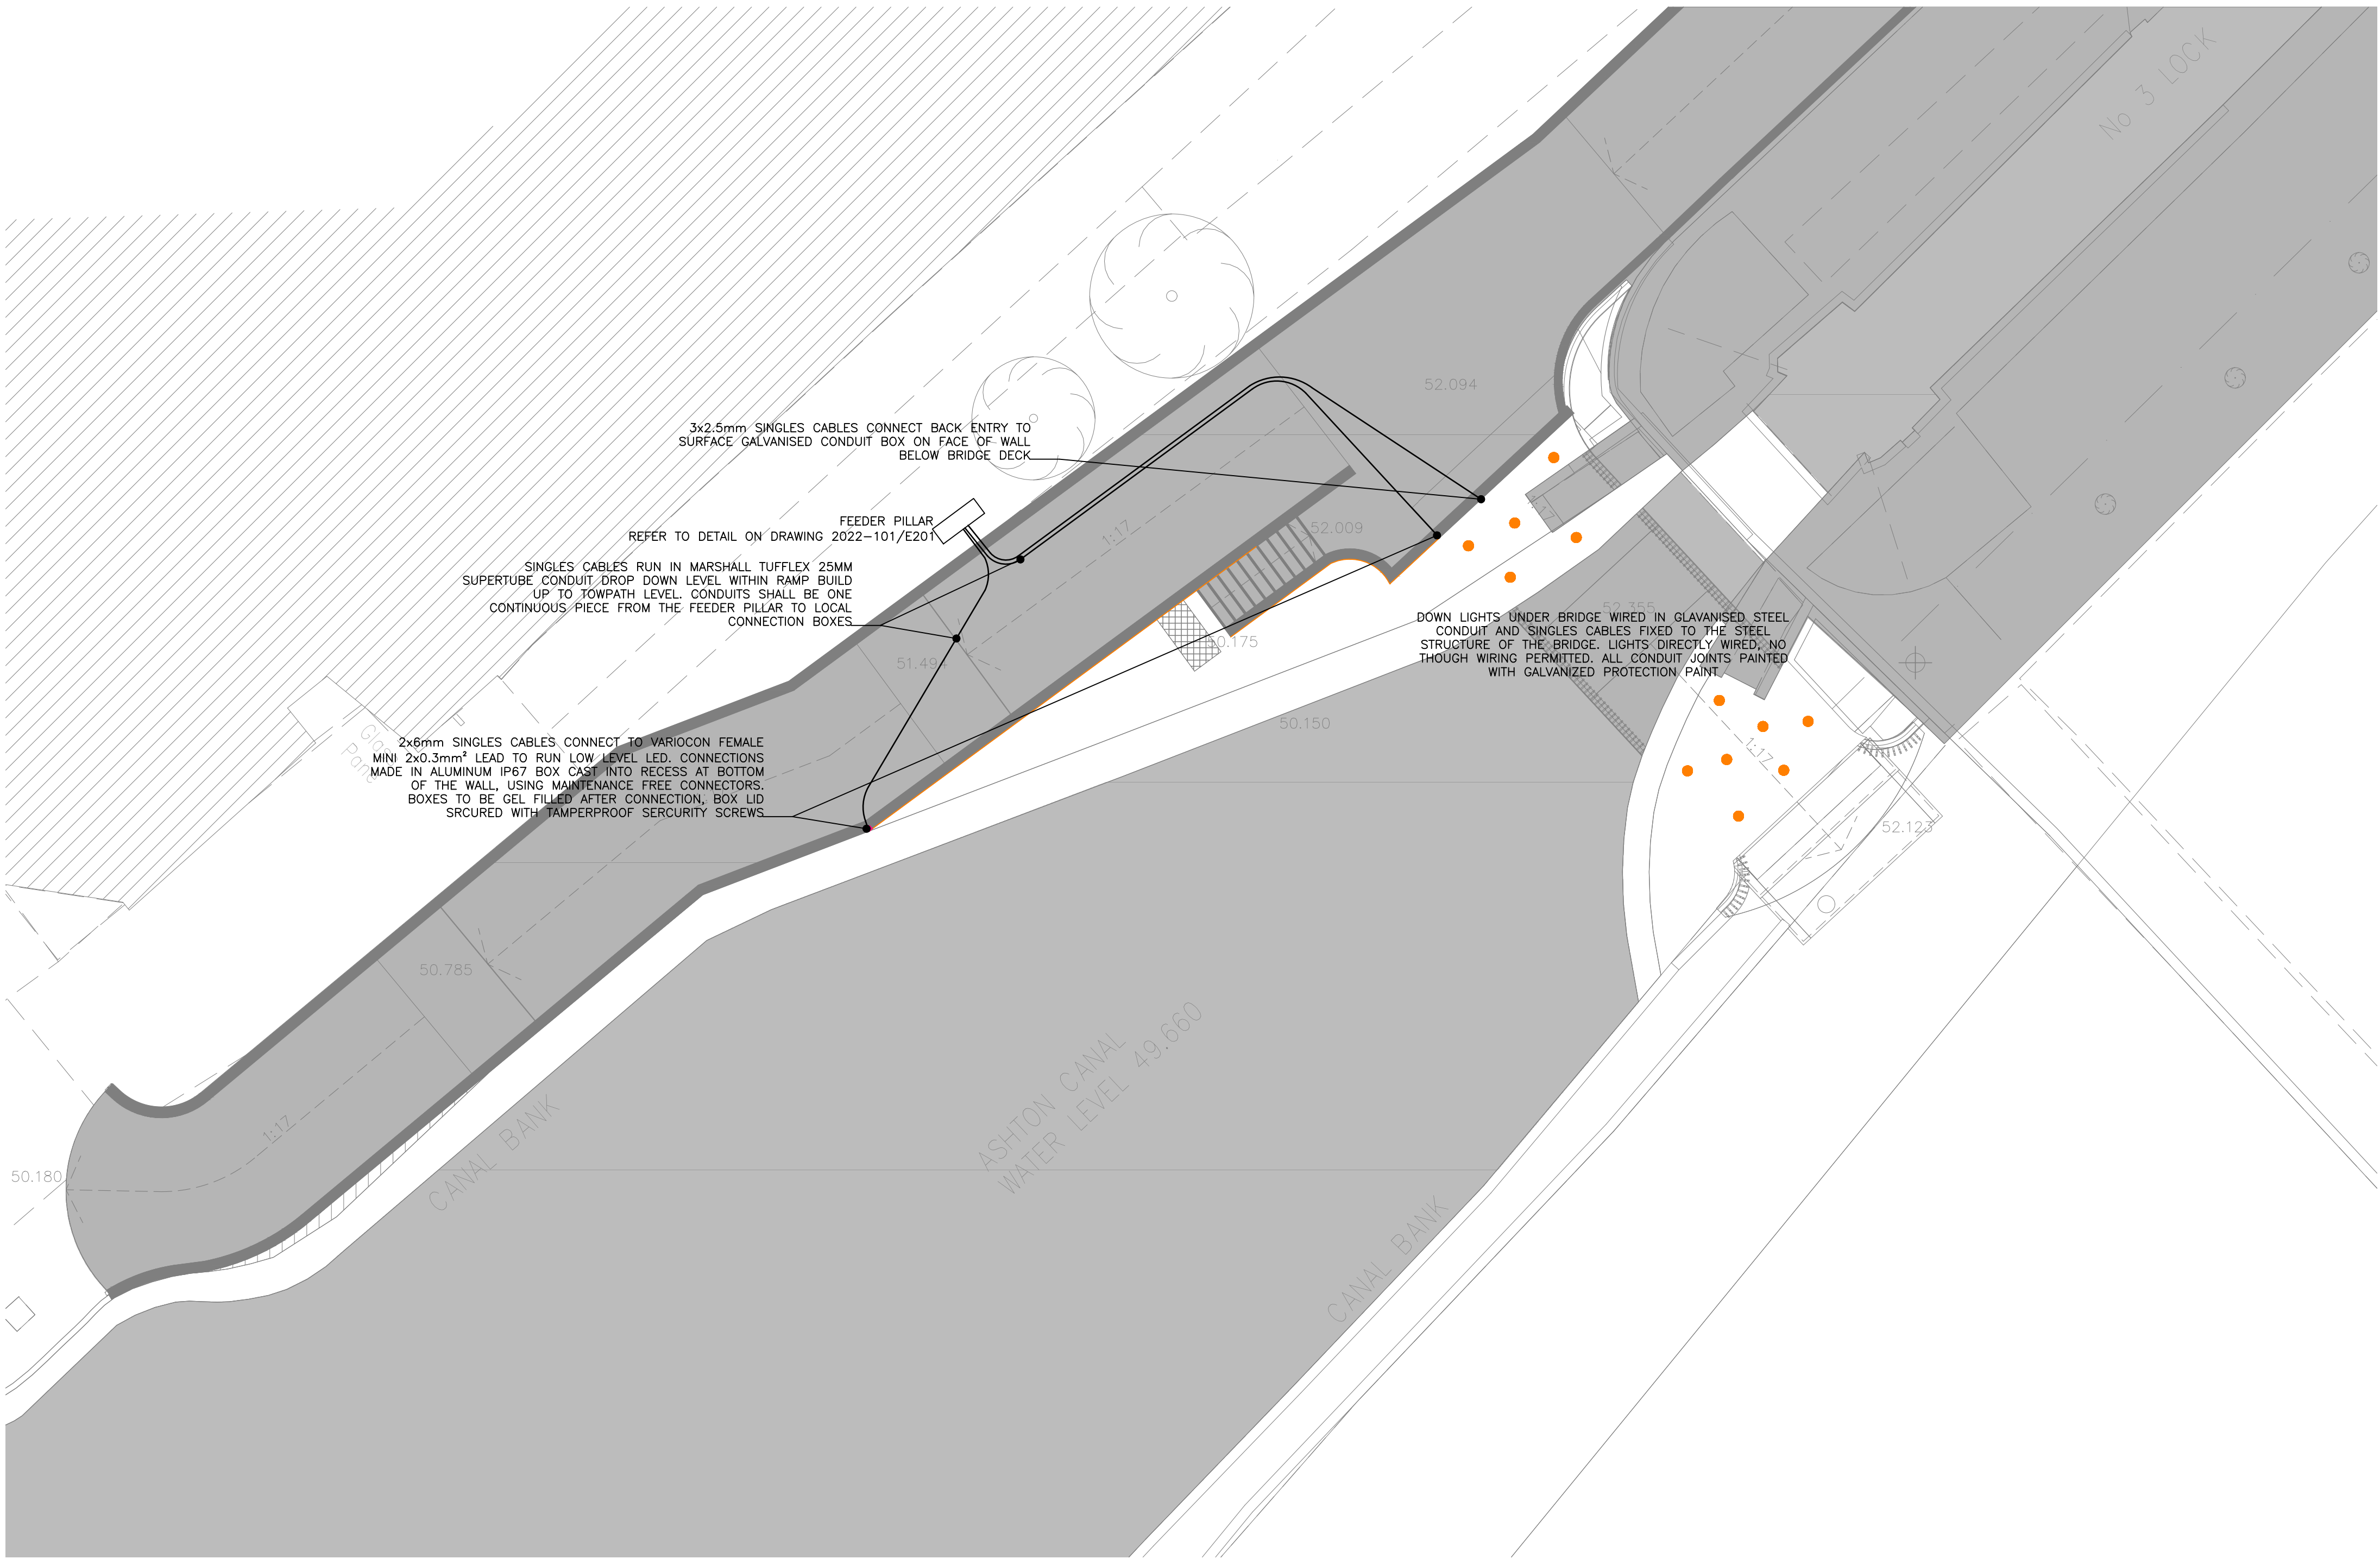

BMA Brian Mellor Associates CONSULTING ENGINEERS		2nd FLOOR BRIANNIC BUILDING 2 UPPER HEAD ROW HUDDERSFIELD HD1 2JL Tel: 01484 513973 Email: general@bmelloorasc.co.uk		PROJECT	
				ISLINGTON CYCLE BRIDGE LOCK No.3 ASHTON CANAL MANCHESTER	
Scale: 1:100 @ A1		Date: OCTOBER 2022		TITLE	
				ELECTRICAL REQUIREMENTS CANAL TOWPATH LEVEL 2 of 2	
Drawn: GPR		Chkd:		Drawing Issue Status	
				☐ PRELIMINARY	
				☒ TENDER	
				☐ CONSTRUCTION	
				Drg No.	Rev
				2022-101/E/201	PO1