

 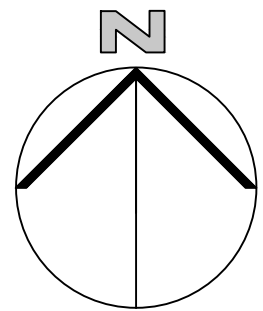


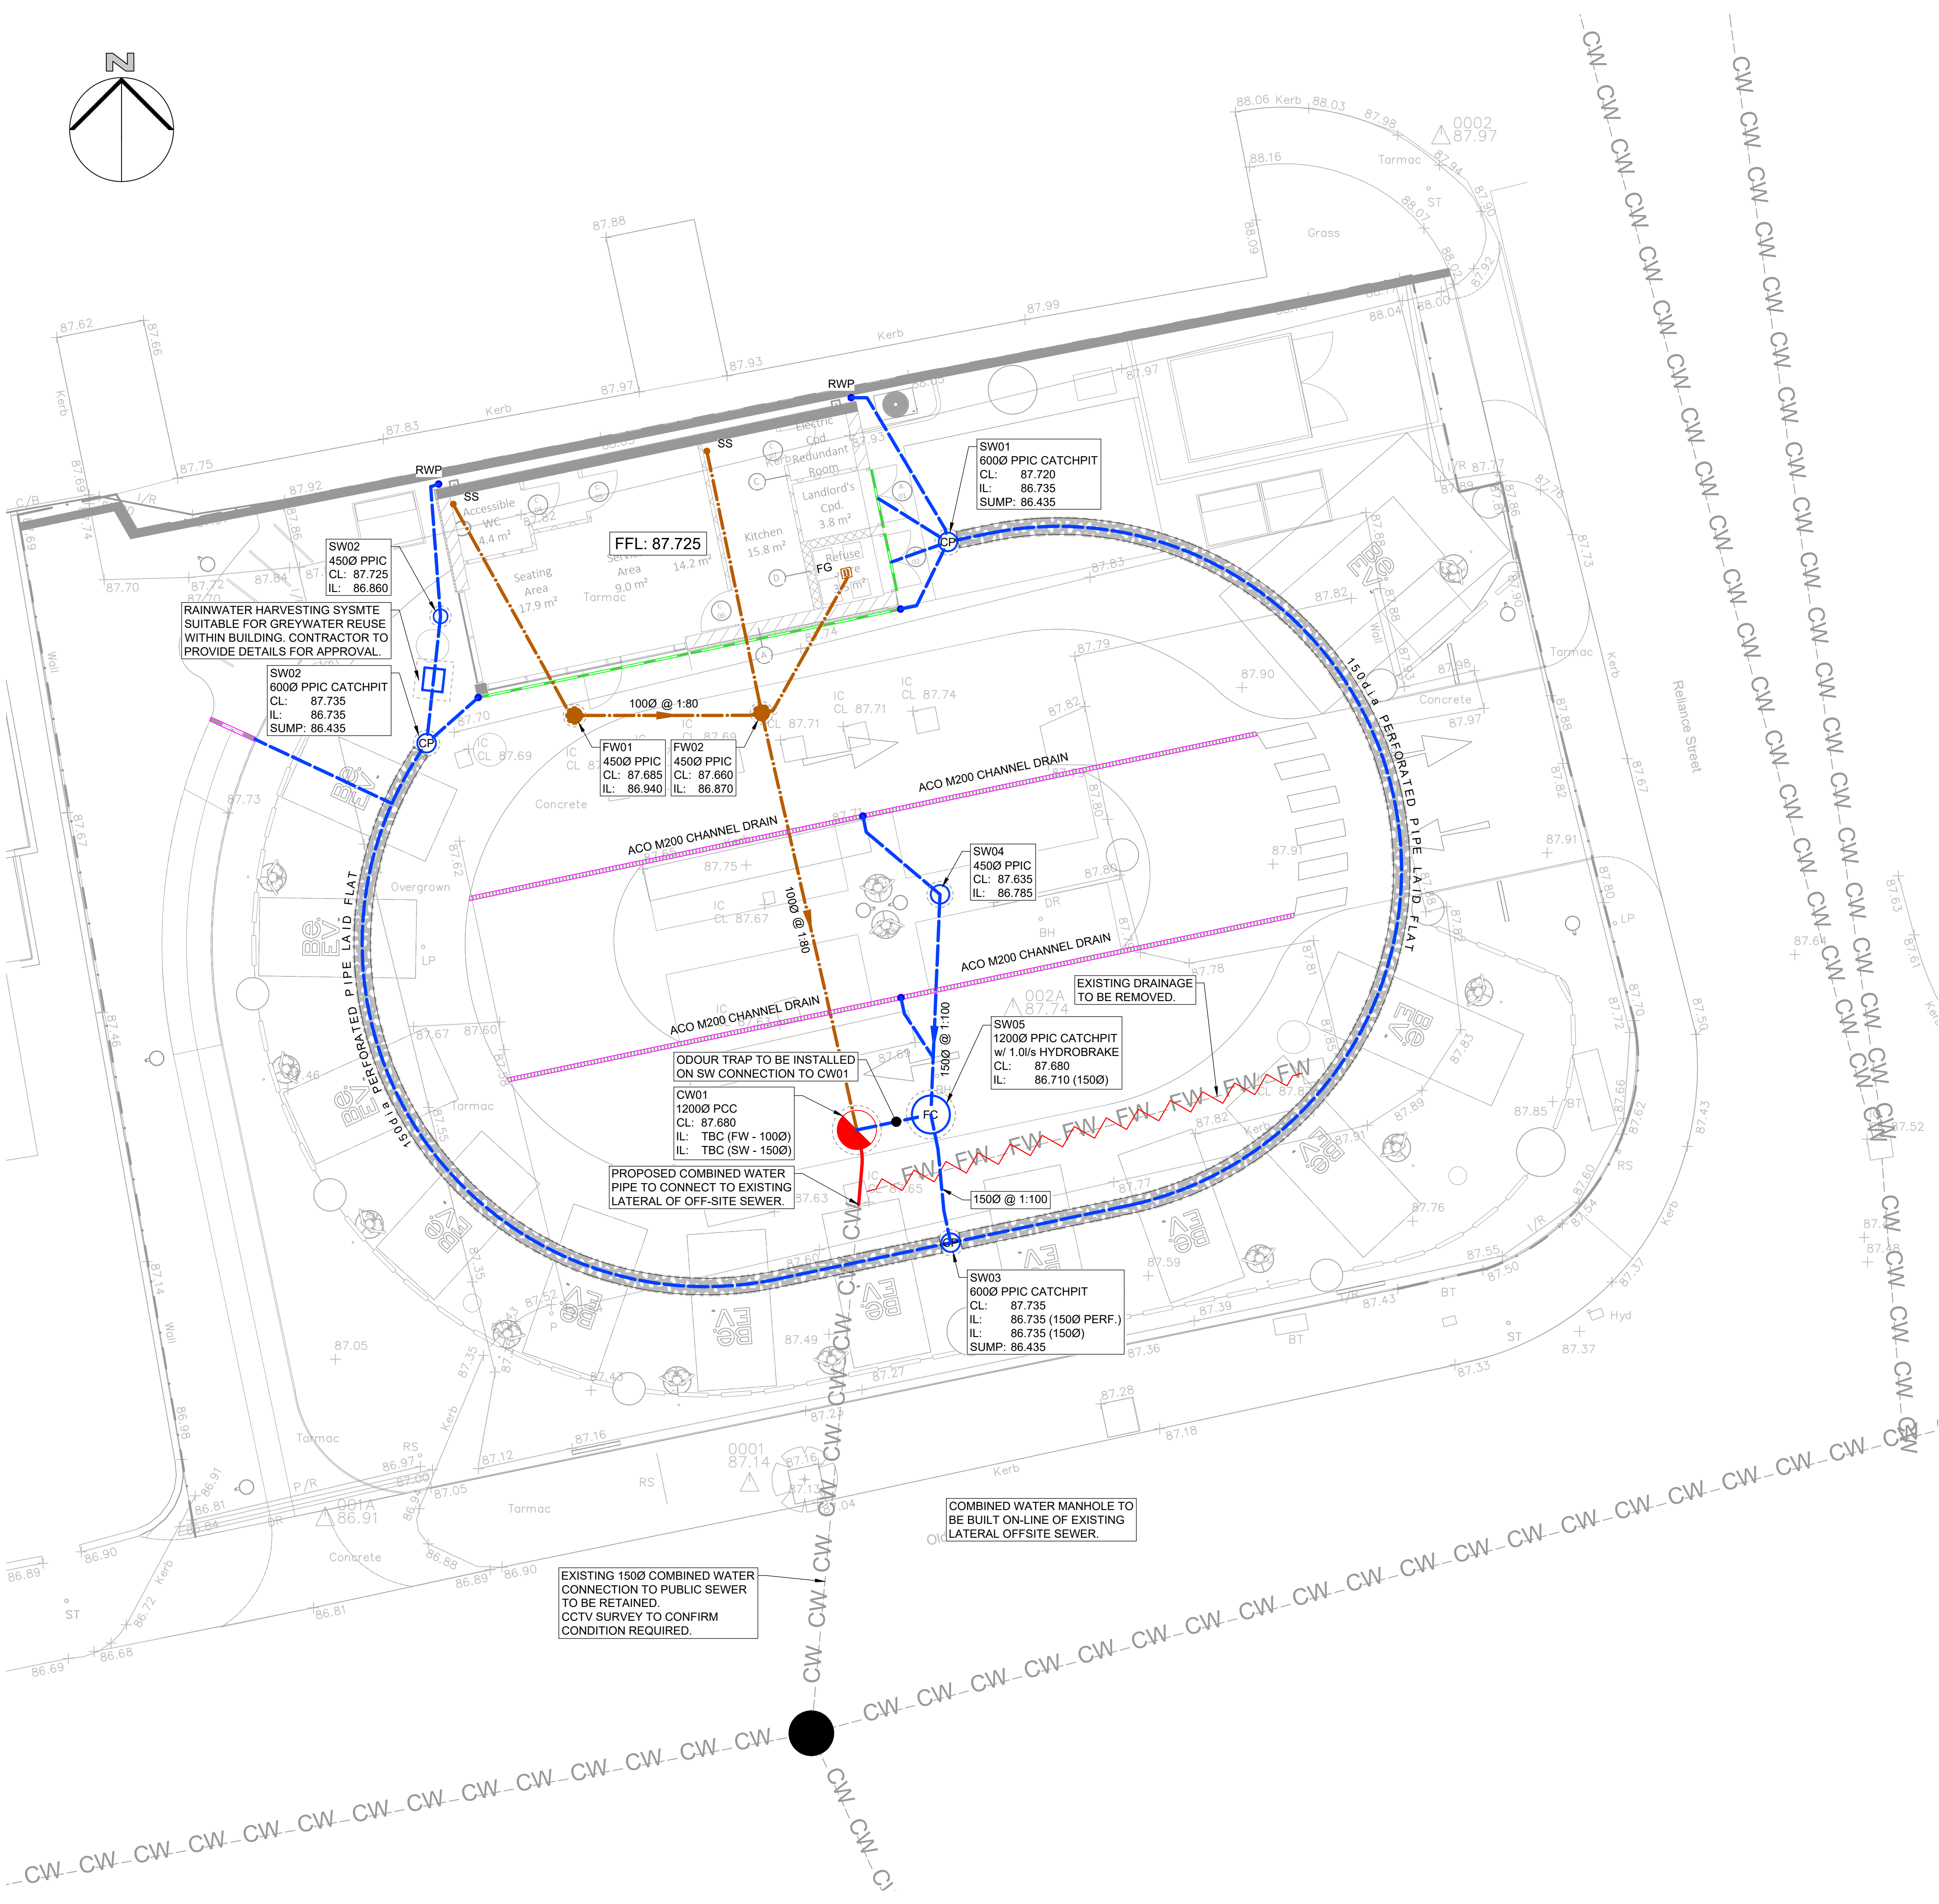

LEGEND

- SW --- SW --- EXISTING SURFACE SEWER
- CW --- CW --- EXISTING COMBINED SEWER
- FW --- FW --- EXISTING FOUL SEWER
- EXISTING SEWER TO BE ABANDONED
- PROPOSED PERFORATED PIPE
- PROPOSED SURFACE WATER SEWER
- PROPOSED FOUL WATER SEWER
- PROPOSED SURFACE WATER MANHOLES
- PROPOSED CATCHPIT MANHOLE
- PROPOSED COMBINED WATER MANHOLE
- PROPOSED FOUL WATER MANHOLES
- EXISTING ADOPTED MANHOLE
- RWP --- PROPOSED RAINWATER DOWNPIPE
- RG --- PROPOSED ROAD GULLY
- SVP --- PROPOSED SOIL VENT PIPE / STUB STACK
- FG --- PROPOSED FLOOR GULLY
- PROPOSED CHANNEL DRAIN
- PROPOSED THRESHOLD DRAIN
- FFL + 12.00 --- PROPOSED FINISHED FLOOR LEVEL

- GENERAL DRAINAGE NOTES**
- THIS DRAWING IS TO BE READ IN CONJUNCTION WITH ALL RELEVANT ARCHITECTS, ENGINEERS AND SPECIALIST DRAWINGS AND SPECIFICATIONS
 - DO NOT SCALE FROM THIS DRAWING IN EITHER PAPER OR DIGITAL FORM. USE WRITTEN DIMENSIONS ONLY.
 - INVERT LEVELS AND POSITIONS OF EXISTING DRAINS / CHAMBERS / SEWERS WHERE NEW CONNECTIONS ARE TO BE MADE MUST BE CHECKED AND CONFIRMED TO THE ENGINEER PRIOR TO THE COMMENCEMENT OF ANY WORKS.
 - ALL DRAINAGE SHALL COMPLY WITH THE TYPICAL DETAILS AND THE REQUIREMENTS OF BS EN 752 AND PART H OF THE BUILDING REGULATIONS.
 - ANY PART OF THE EXISTING DRAINAGE SYSTEM TO BE RETAINED AS PART OF THE NEW SCHEME SHALL BE CLEANED AND INSPECTED. ANY STRUCTURAL DEFECTS SHALL BE REPAIRED USING APPROPRIATE AND APPROVED MEANS
 - FOR SETTING-OUT DIMENSIONS OF SVP'S, RWP'S ETC., REFER TO ARCHITECT'S OR MECHANICAL ENGINEER'S DRAWINGS. POSITIONS SHOWN ARE INDICATIVE AND SUBJECT TO FINAL DESIGN.
 - ALL FOUL AND RWP CONNECTIONS SHALL BE 100MM DIAMETER UNLESS OTHERWISE SPECIFIED.
 - ALL PRECAST CONCRETE UNITS USED IN THE DRAINAGE WORKS SHALL BE MANUFACTURED USING SULPHATE RESISTING CEMENT.
 - MANHOLE COVERS AND FRAMES SHALL BE TO BS EN 124 AND SHALL BE KITEMARKED. COVERS AND FRAMES SHALL BE HEAVY DUTY D400 IN CARRIAGEWAYS AND VEHICULAR AREAS AND MEDIUM DUTY B125 IN FOOTWAYS AND SOFT LANDSCAPING. IN BLOCKED/CONCRETE PAVED AREAS COVERS SHALL BE RECESSED FABRICATED STEEL. ALL RECESSED COVERS SHALL IN ACCORDANCE WITH THE FACTA ASSOCIATION GRADINGS.
 - COVER LEVELS ARE TO BE ADJUSTED LOCALLY TO SUIT FINISHED GROUND LEVELS.
 - AT LEAST ONE SOIL PIPE AT THE HEAD OF EACH FOUL RUN SHALL VENT TO THE ATMOSPHERE.
 - EXISTING DRAINAGE TO BE REMOVED IS TO BE BROKEN OUT TO BED LEVEL AND VOID BACKFILLED WITH GRANULAR MATERIAL, COMPACTED IN LAYERS NOT EXCEEDING 250MM.
 - ALL DRAIN RUNS FROM SVP'S, STUB STACKS OR FW GULLIES TO BE LAID AT 1:40 GRADIENT UNLESS OTHERWISE STATED. ALL RWP'S TO BE LAID 1:80 MIN UNLESS OTHERWISE STATED.
 - ALL PRIVATE DRAINAGE TO BE LAID TO LEVELS SHOWN USING FLEXIBLY JOINTED PIPES, EITHER UPVC TO BS 4660 AND BS 5481 OR VITRIFIED CLAYWARE TO BS EN 295.
 - ALL PROPOSED TREES TO HAVE APPROPRIATE TREE BARRIER DETAILS LINKING PITS TO ENSURE ROOTS ARE DIRECTED AWAY FROM DRAINAGE.
 - WHERE NEW SEWERS ARE CONSTRUCTED WITHIN 5M OF A NEW OR EXISTING TREE THE SEWER SHALL BE CONCRETE ENCASED AGAINST ROOT INTRUSION. REFER TO DRAINAGE DETAILS.
 - ALL NEW DRAINAGE TO BE JETTED AND CCTV SURVEYED ON COMPLETION. CONTRACTOR TO MAKE SURE THAT THE DRAINAGE IS FULLY OPERATIONAL. REFER TO DRAINAGE MAINTENANCE MANUAL FOR MAINTENANCE DETAILS.
 - ALL RUNS CONNECTING INTO THE PUBLIC DRAINAGE NETWORK TO BE VITRIFIED CLAY, EXTRA LENGTH TO BS EN 295 OR BS65 WITH PLAIN SLEEVED OR SOCKETED FLEXIBLE JOINTS.



NOT FOR CONSTRUCTION

P07	11.07.24	CW01 & SW05 ADJUSTED	AS	-
P06	10.07.24	SITE LAYOUT UPDATED	AS	-
P05	08.07.24	CHANNEL DRAINS UPDATED	AS	-
P04	24.05.24	RWP POSITIONS AMENDED, HARVESTING ADDED	JT	AS
P03	18.04.24	AMENDED TO MATCH UPDATED SITE LAYOUT	JT	AS
P02	26.10.23	PERFORATED PIPE AMENDED, TREE PITS ADDED	JT	AS
P01	22.09.23	FIRST ISSUE	JT	AS
Rev	Date	Description	Drawn	Check

conisbee Consulting Structural Engineers
Consulting Civil Engineers

London • Cambridge • Norwich
1-5 Offord St London N1 1DH
Telephone 020 7700 6666
www.conisbee.co.uk

Drawing Status	
S3 - SUITABLE FOR REVIEW & COMMENT	
Project	Date SEPT 2023
Be.EV RELIANCE STREET MANCHESTER	Scale 1:100
	Drawn JT
Title	Engineer AS
DRAINAGE LAYOUT	Project No 220698
Drawing No 220698-CON-XX-00-DR-C-1000	Revision P07

1. DRAWING BASED ON TOPOGRAPHIC SURVEY BY SURVEY SOLUTIONS, REF. 42087MCLS-01-200-1:1:TOPO, DATED 18/07/22.
2. PROPOSED LAYOUT BASED ON ARCHITECT THAT DRAWING 612-AT-ZZ-R-DR-A-3.1.001, REV P11, DATED 08.04.2024.
3. POSITION OF EXISTING UNITED UTILITIES FOUL AND SURFACE WATER SEWERS BASED ON RECORD INFORMATION.
4. RWP / SVP / SS POSTIONS ARE SHOWN INDICATIVELY AND SUBJECT TO FINAL DESIGN.