
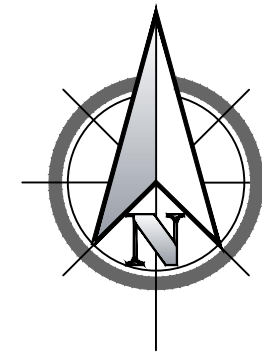


NOTES:
All dimensions must be checked on site and not scaled from this drawing.

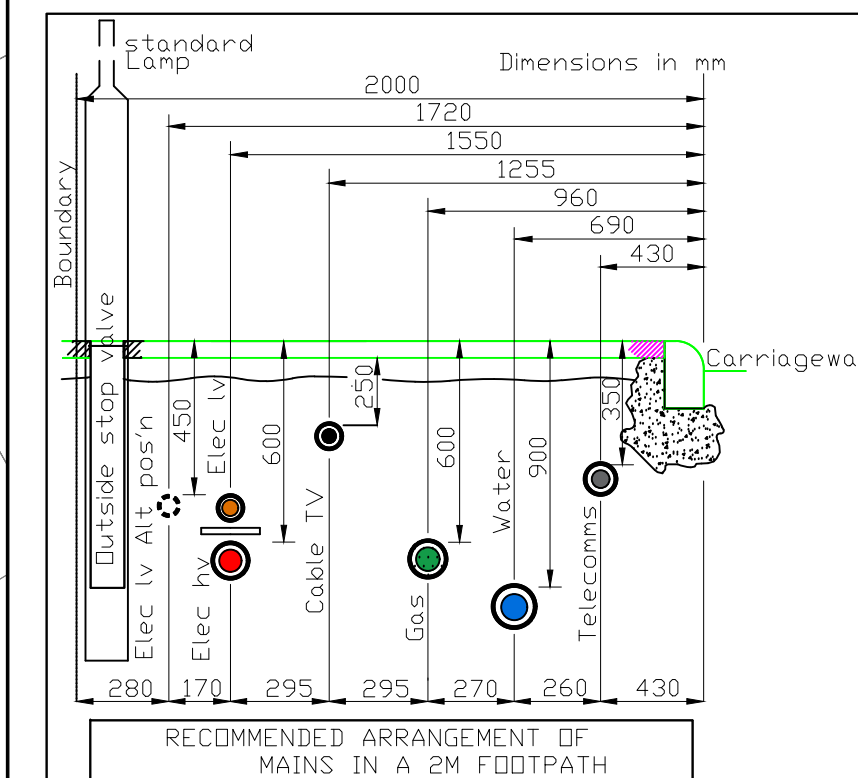


KEY	
LV EXISTING	
LV PROPOSED	
EARTH PROPOSED	
INSULATED EARTH PROPOSED	
SHORT CAP END/EARTH ROD	
BOTTLE END	
DUCTED CABLE	
POINT OF CONNECTION	

C1	11.10.23	PW	Issued For Construction	SM
Rev.	Date	R/By	Revisions	D/E

Client _____

WATES GROUP LIMITED

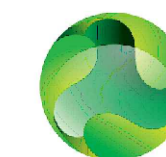

ameon
Utilities Engineering

Ameon Utilities
Olympic Court, Boardmans Way,
Whitehills Business Park, Blackpool, FY4 5GU
Tel: 01253 760160
E-mail: info@ameon.co.uk

Job Title	
-----------	--

RODNEY STREET
ANCOATS

Drawing Title

INCOMING LV SUPPLY
(SHEET 1 OF 3)

Scale 1:250 @ A1	Designed by PW
---------------------	-------------------


Date AUGUST 2023	Drawn by JD
---------------------	----------------

Drawing Number	Revision
----------------	----------

AU/2222/E002

Revision


C1

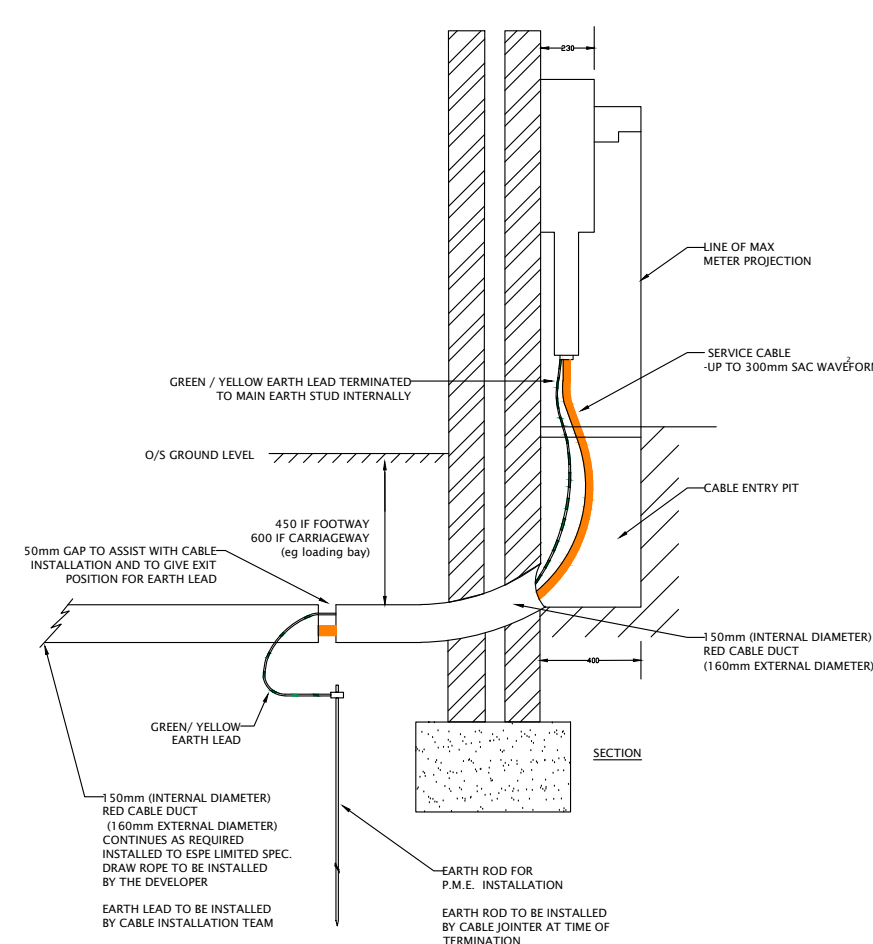


50.6m

NOTES:
All dimensions must be checked on site and not
scaled from this drawing.


CROSS SECTION A-A (SCALED 1:10 @ A1)

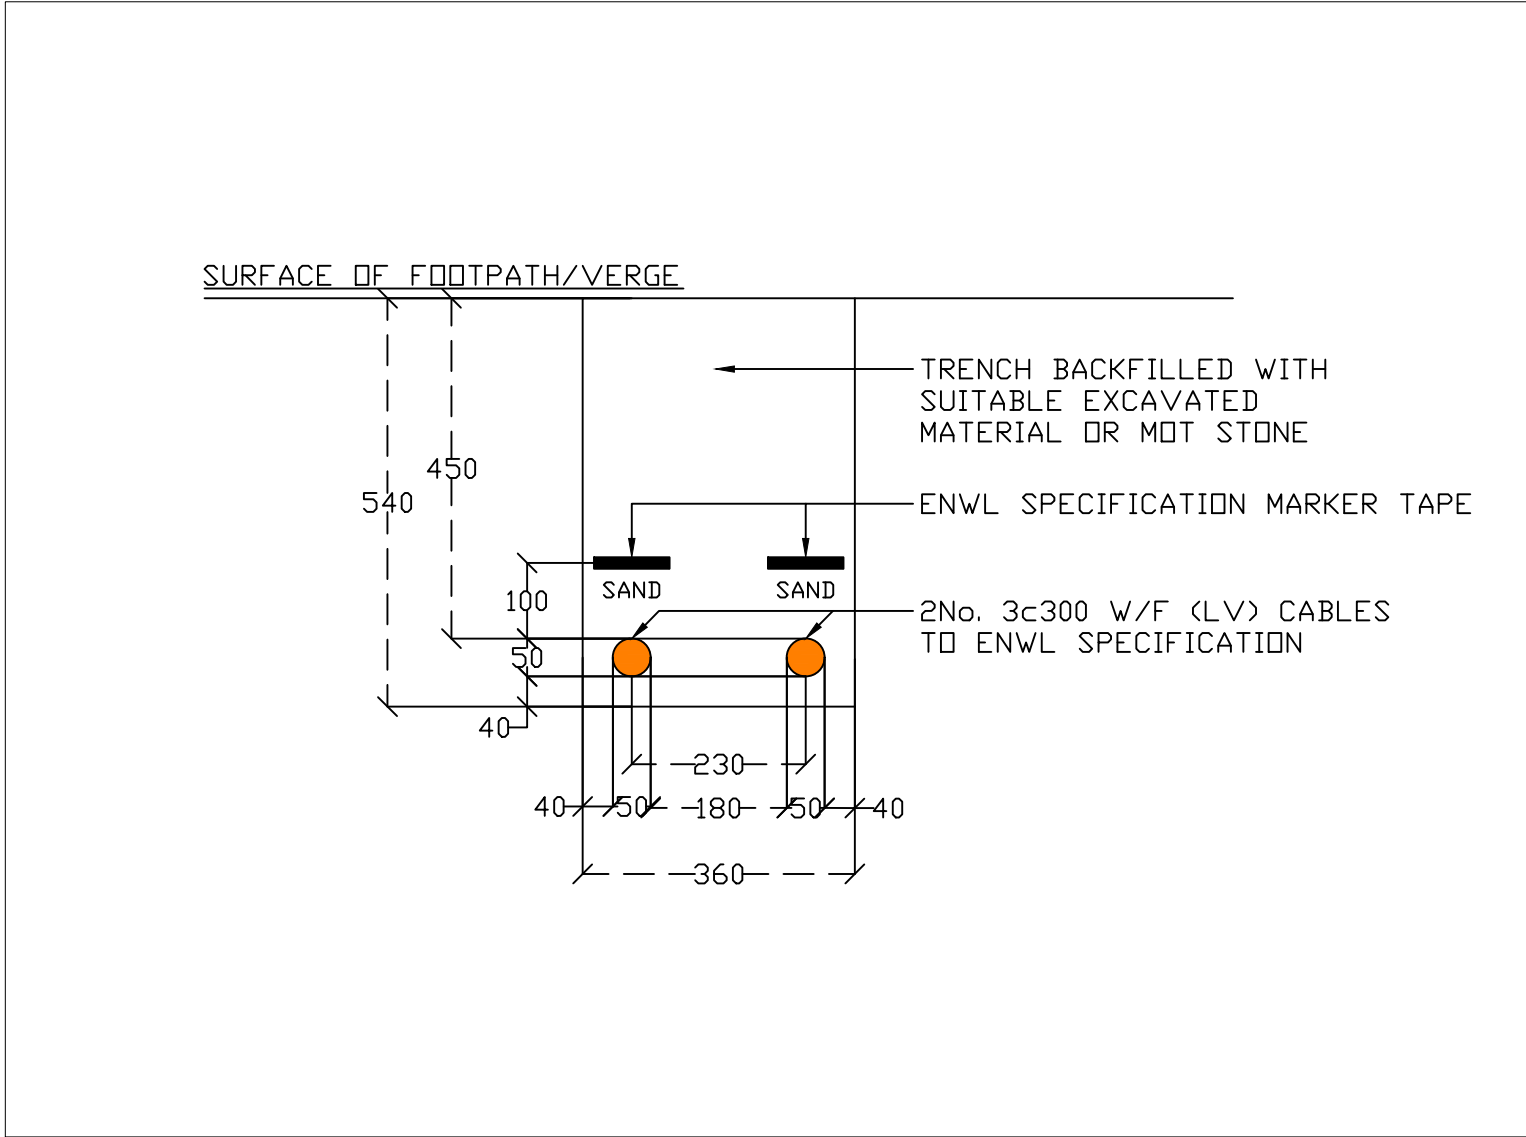


CROSS SECTION B-B (SCALED 1:10 @ A1)

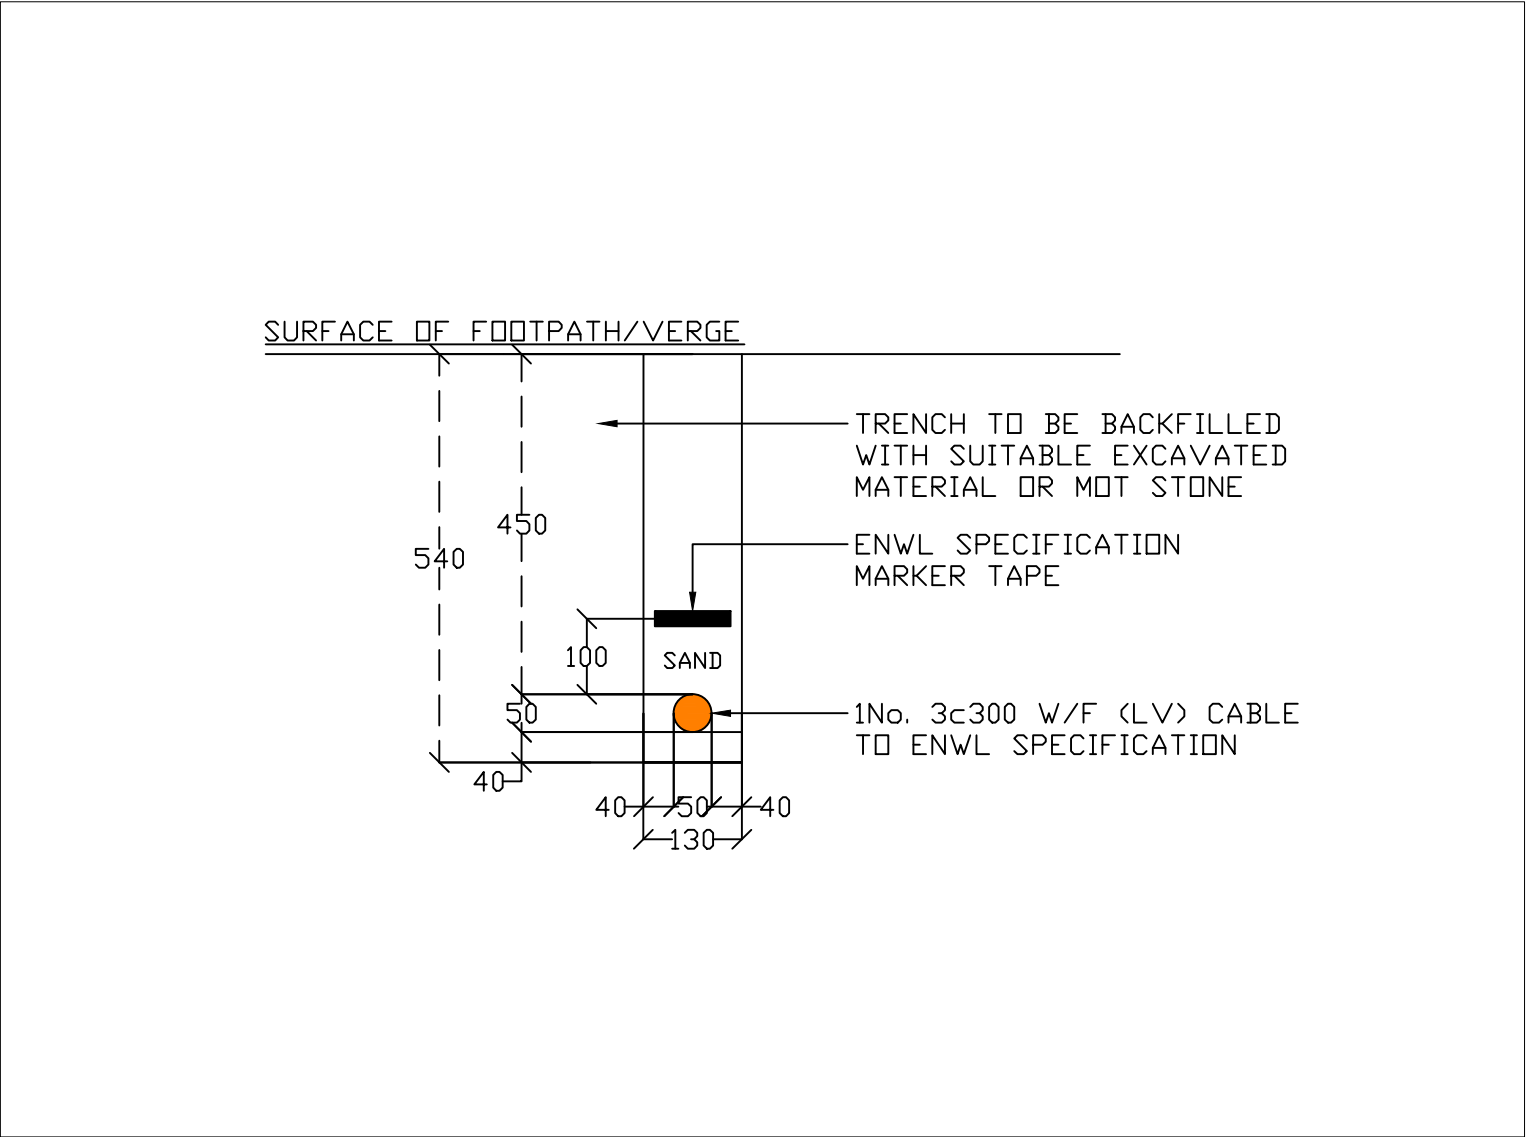


CROSS SECTION C-C (SCALED 1:10 @ A1)

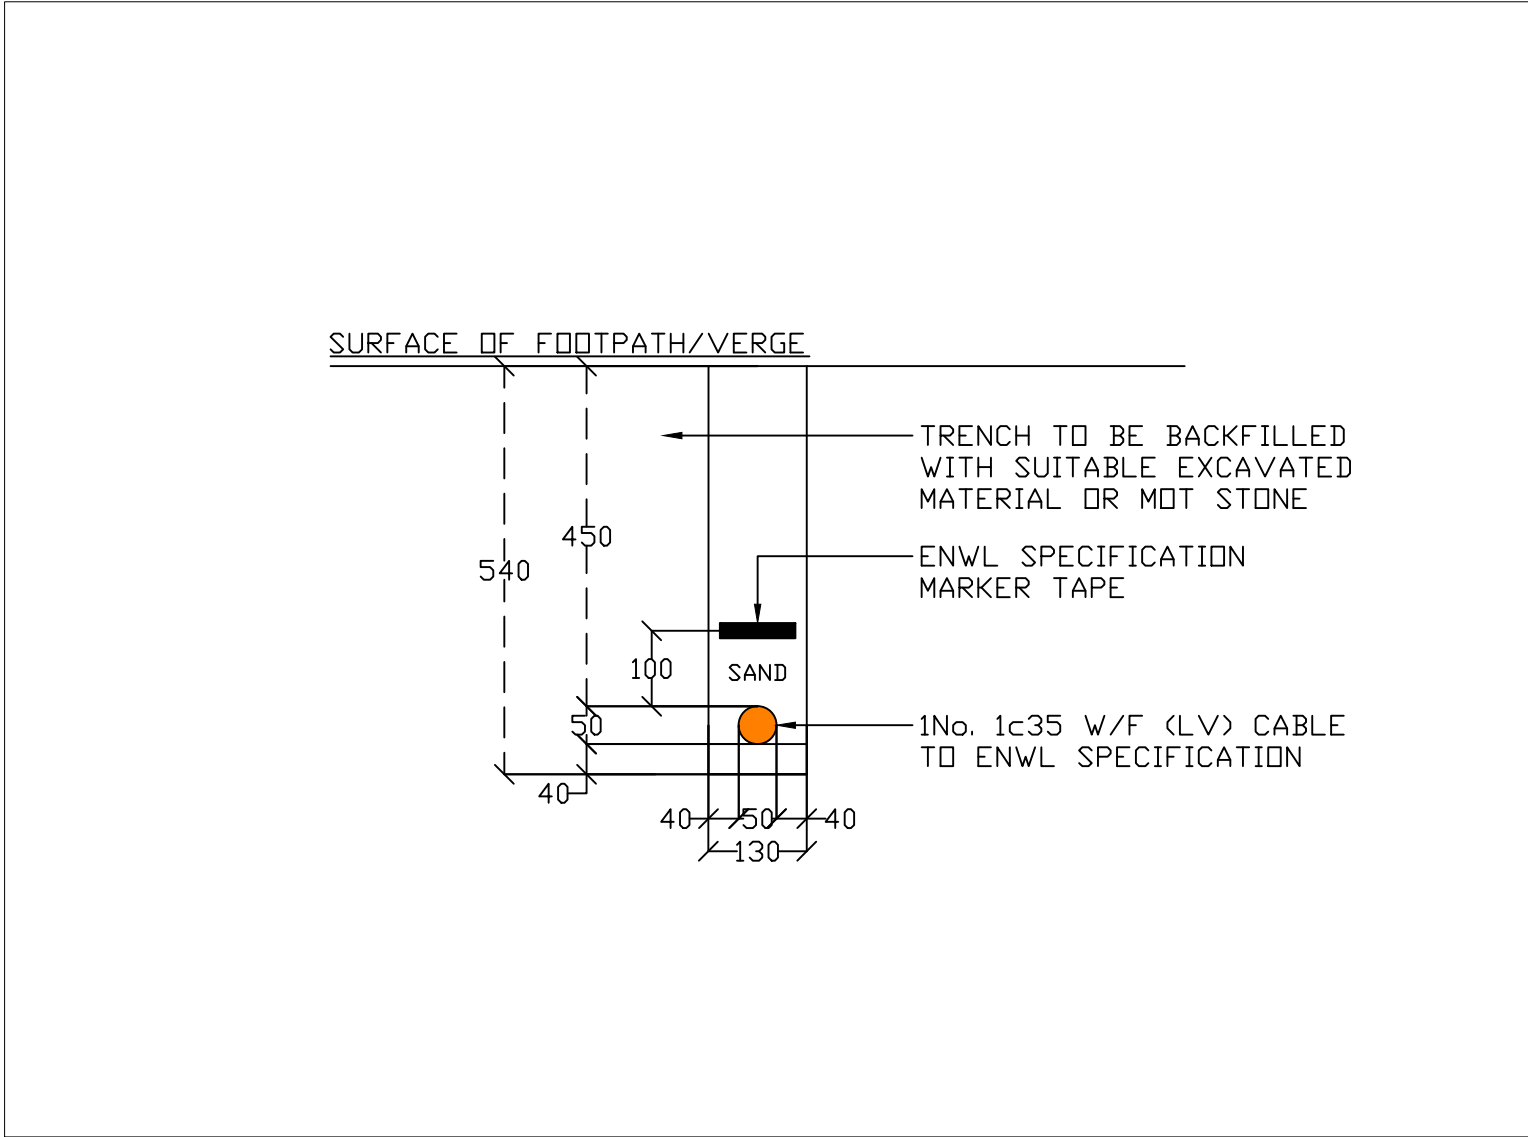


CROSS SECTION D-D (SCALED 1:10 @ A1)

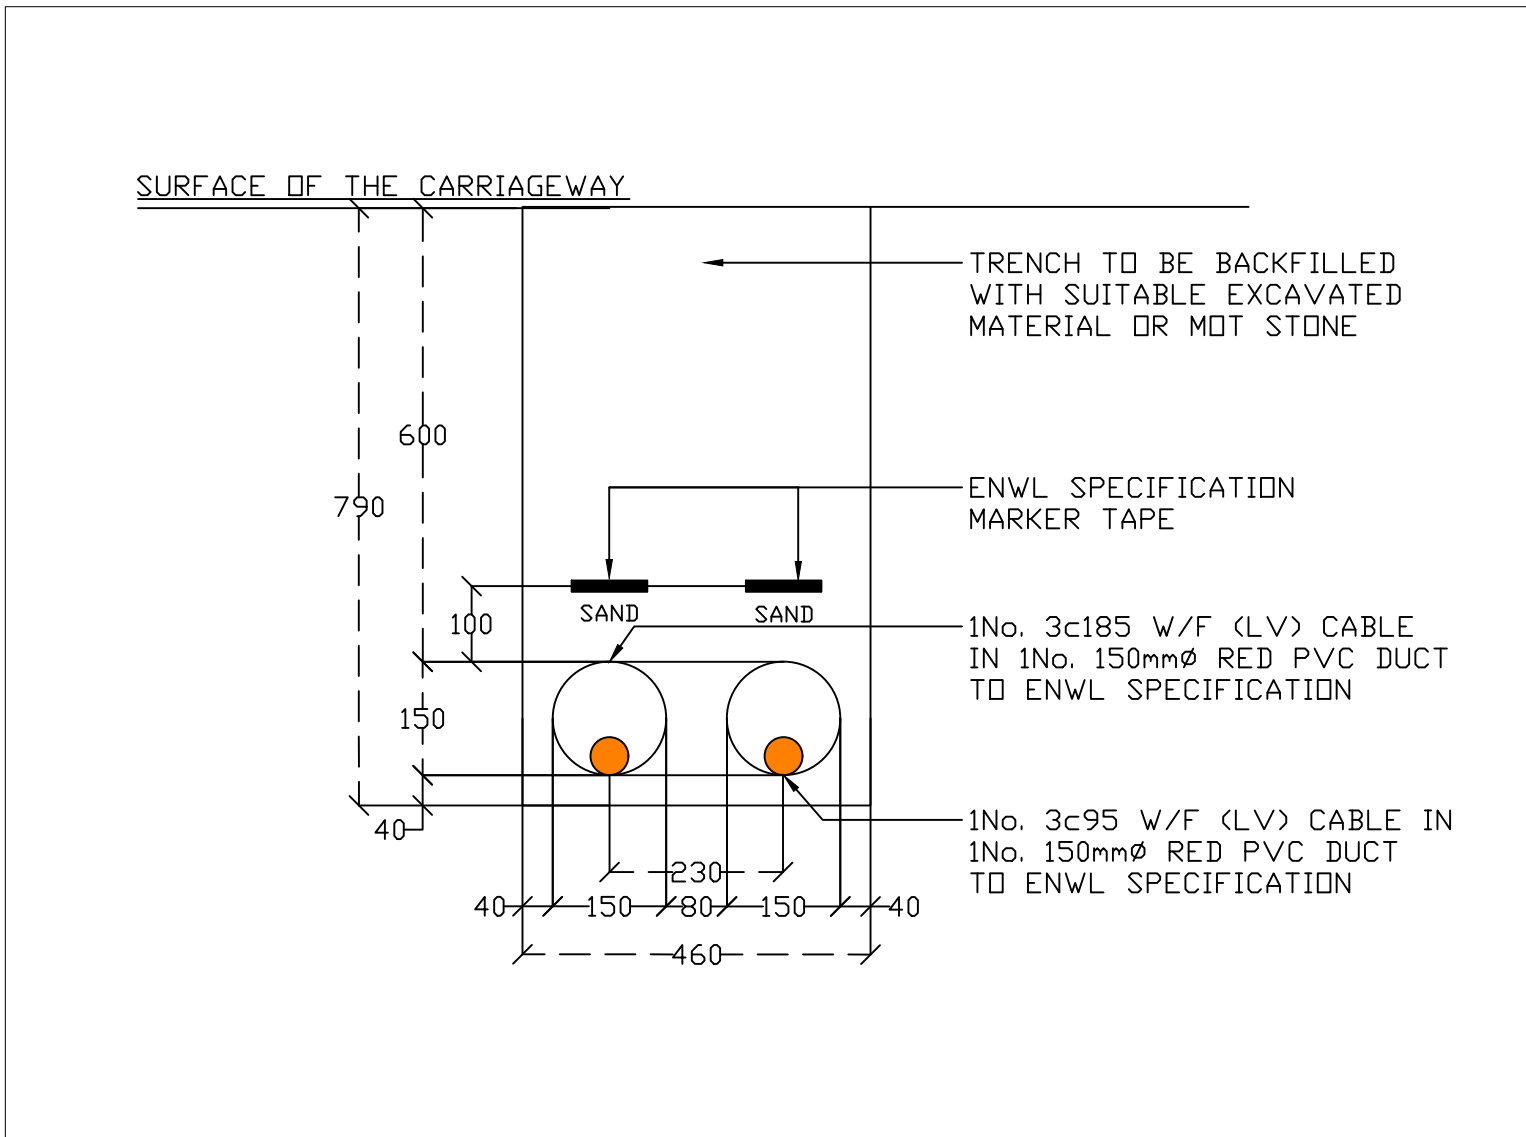


CROSS SECTION E-E (SCALED 1:10 @ A1)

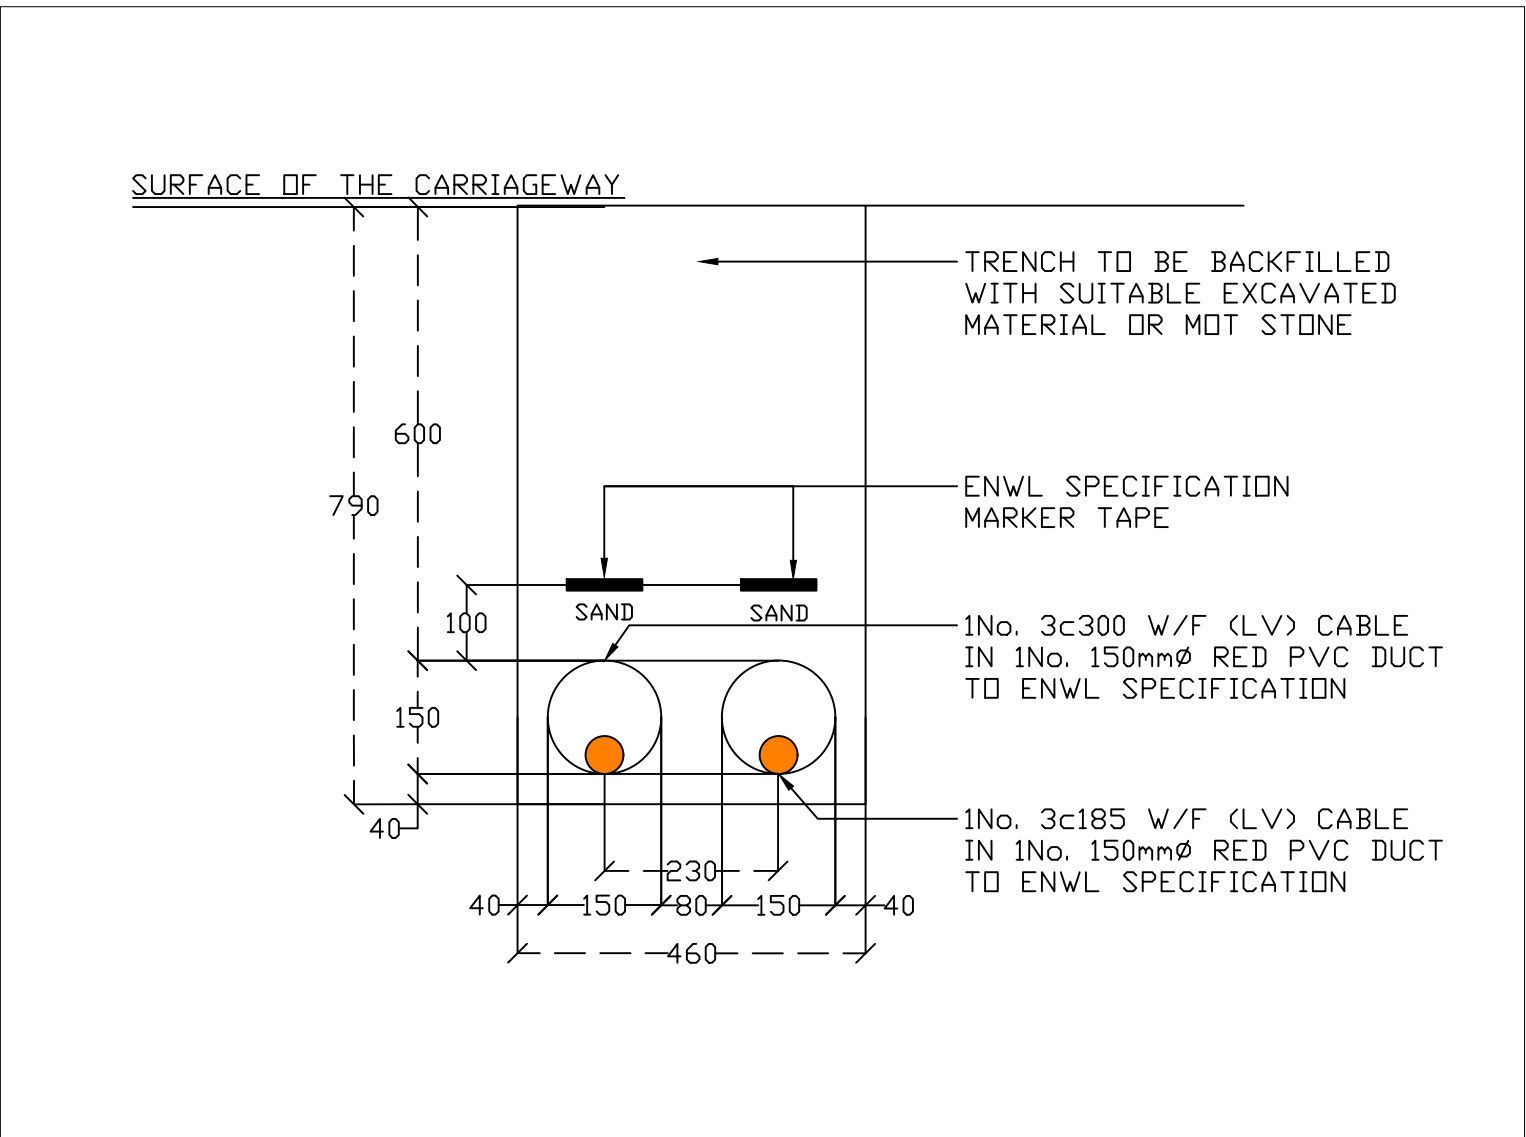



CROSS SECTION F-F (SCALED 1:10 @ A1)

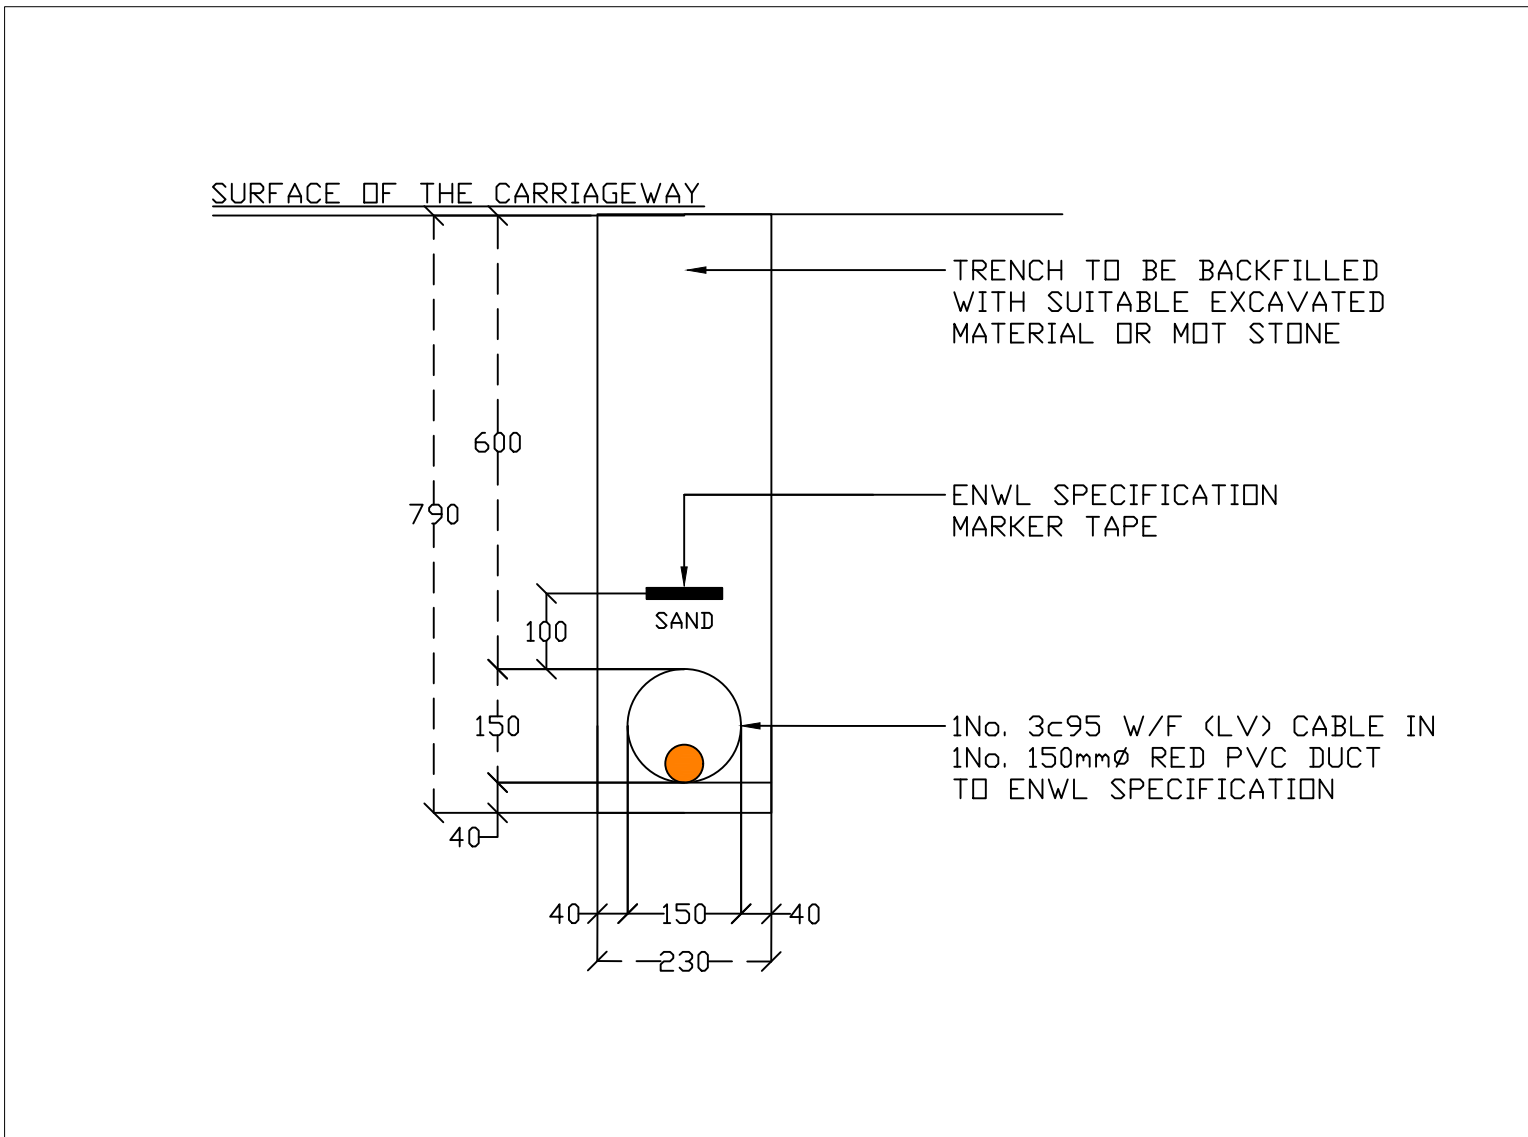

CROSS SECTION G-G (SCALED 1:10 @ A1)

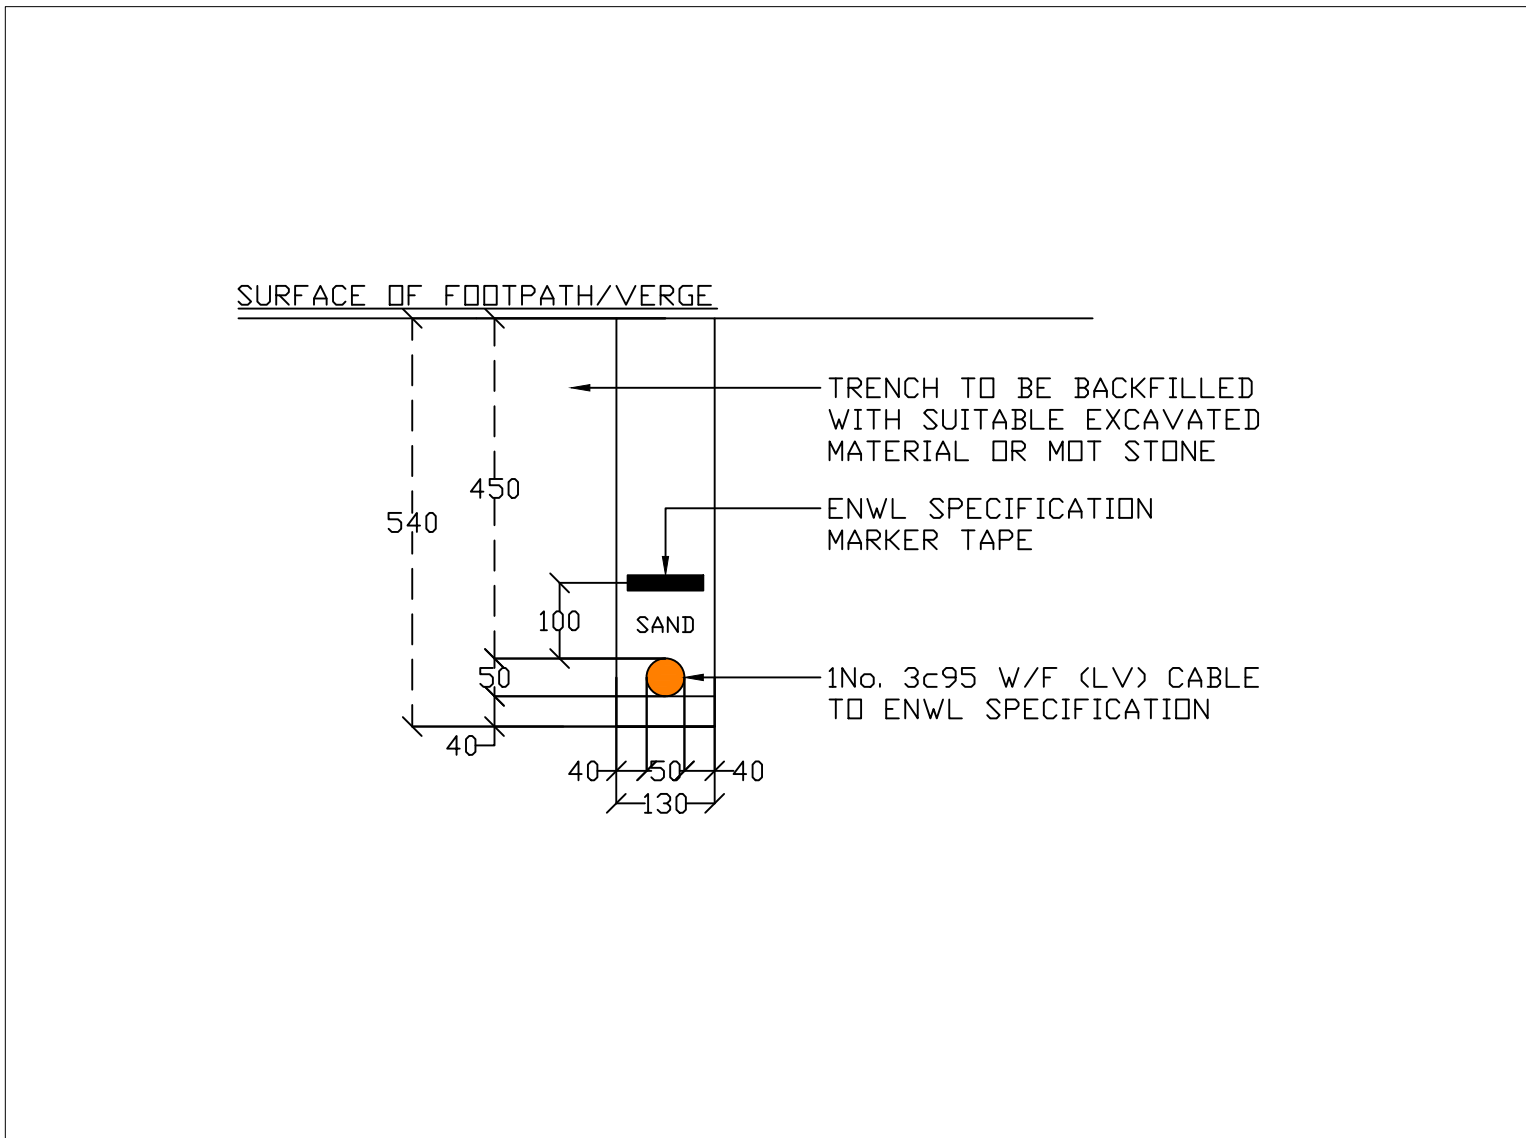

CROSS SECTION H-H (SCALED 1:10 @ A1)

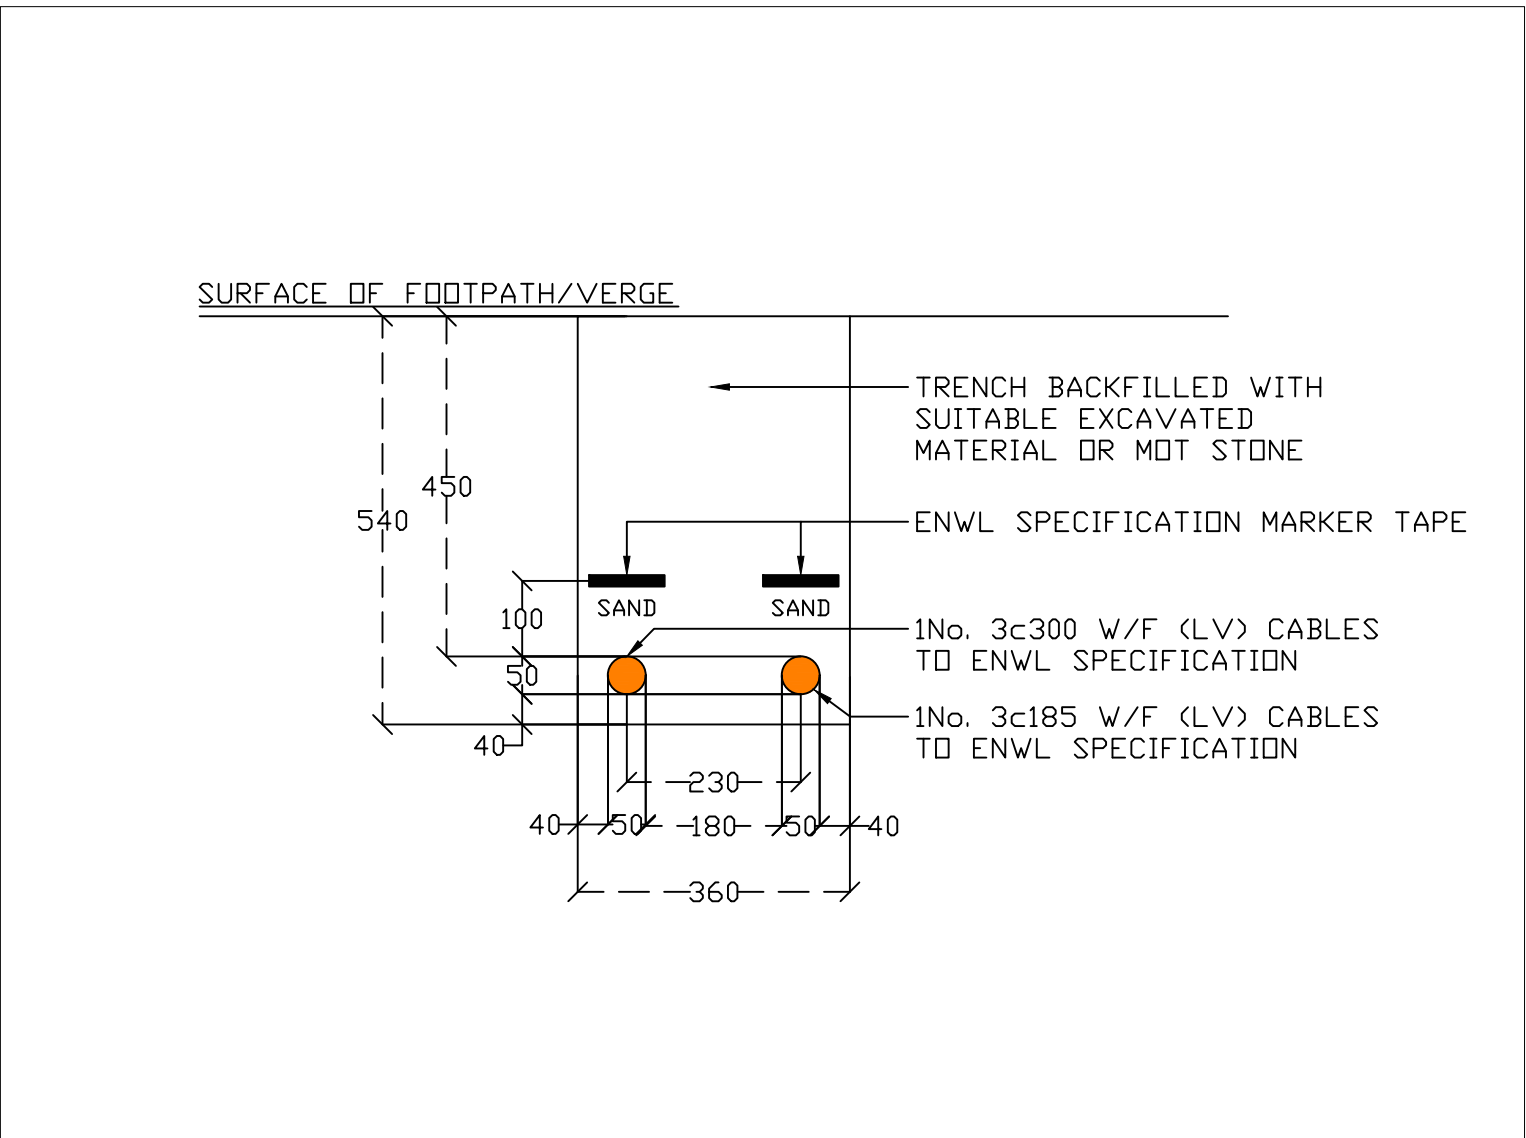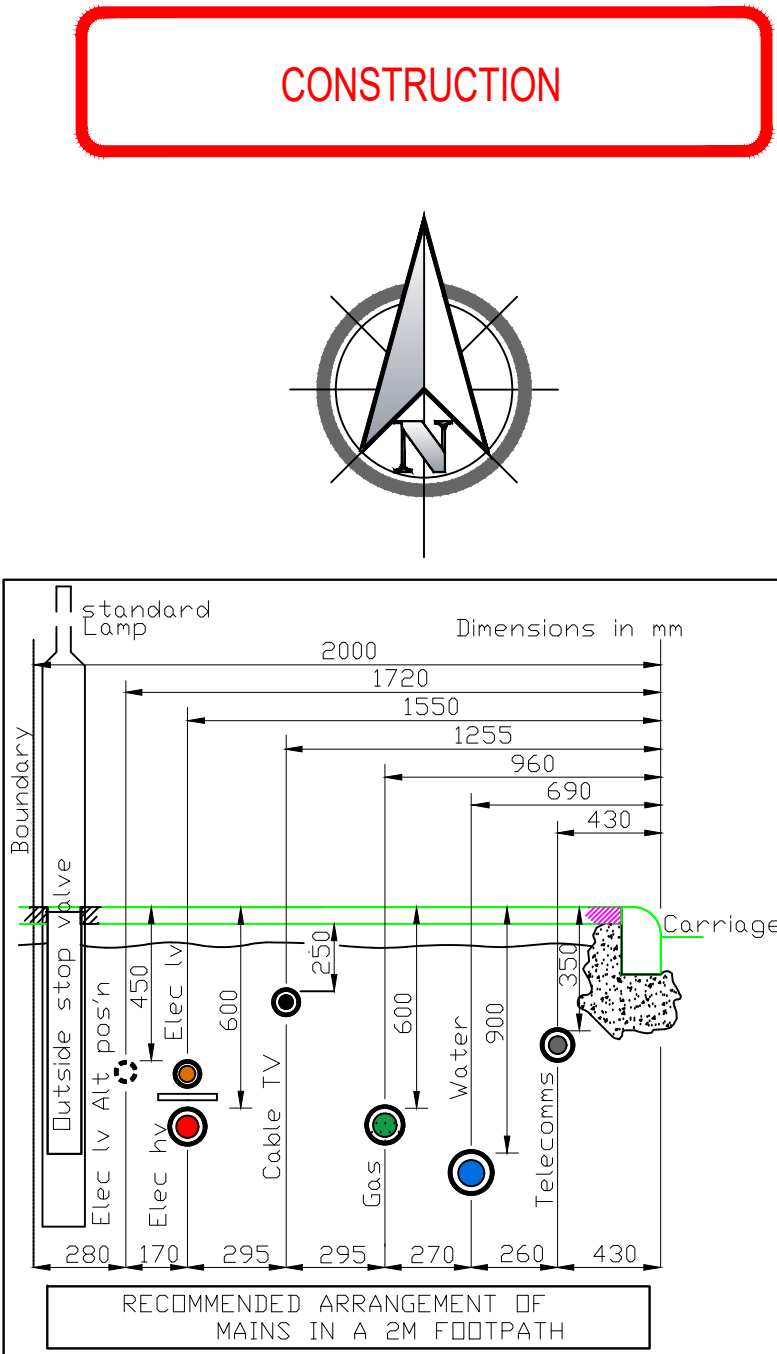


KEY	
LV EXISTING	—
LV PROPOSED	- - -
EARTH PROPOSED	- - -
INSULATED EARTH PROPOSED	- - -
SHORT CAP END/EARTH ROD	—
BOTTLE END	—
DUCTED CABLE	—
POINT OF CONNECTION	—

C1	24.08.23	PW	Issued For Construction	SM
Rev.	Date	R/By	Revisions	D/By


Client	
WATES GROUP LIMITED	
Job Title	
RODNEY STREET ANCOATS	
Drawing Title	
INCOMING LV SUPPLY (SHEET 2 OF 3)	
Scale	Designed by
1:10 @ A1	JD
Date	Drawn by
AUGUST 2023	JD
Drawing Number	
AU/2222/E002	
Revision	
C1	

NOTES:
All dimensions must be checked on site and not scaled from this drawing.


REAR ELEVATION
(KIOSK)

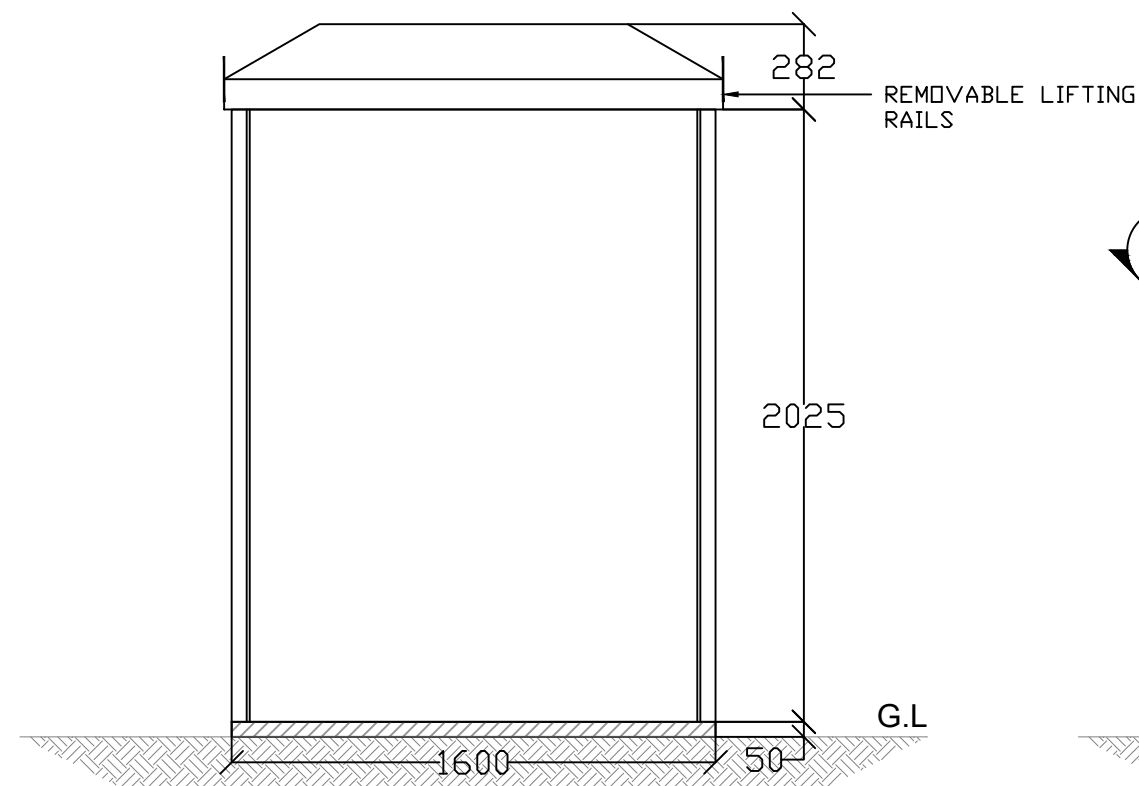


SIDE ELEVATION
(KIOSK)

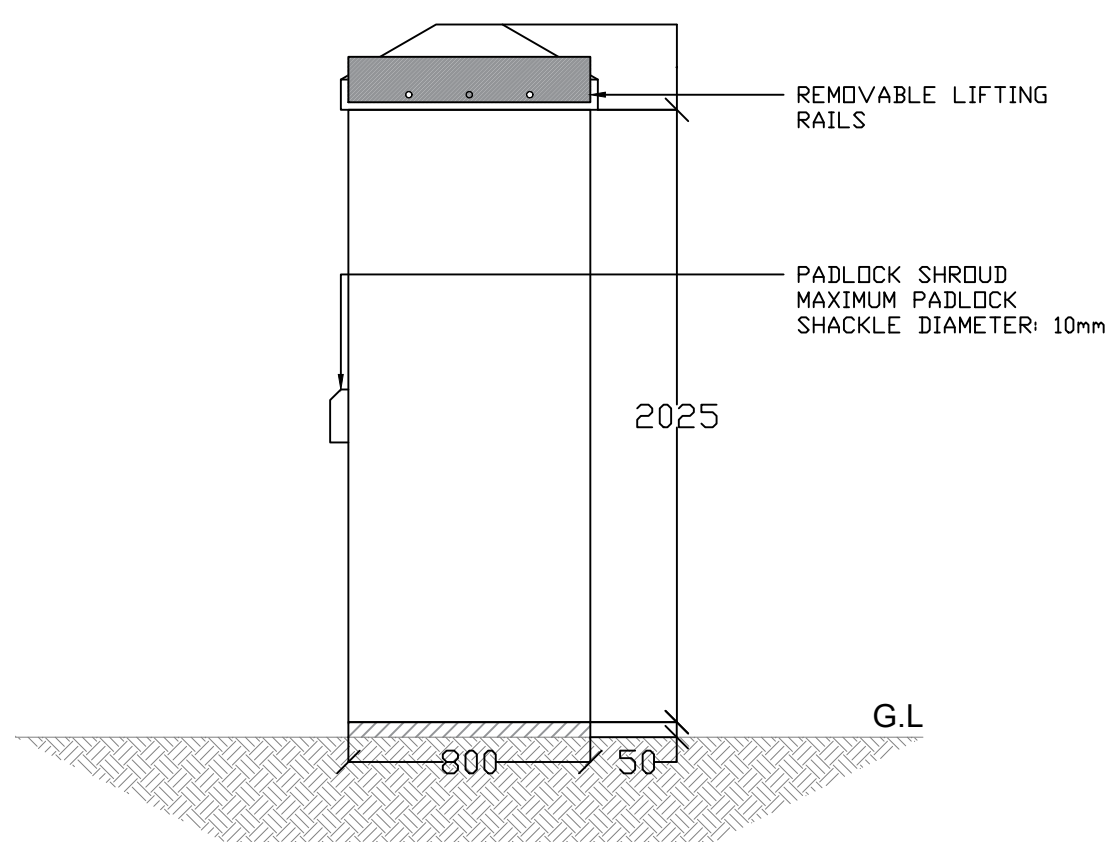


FRONT ELEVATION
(KIOSK BASE)

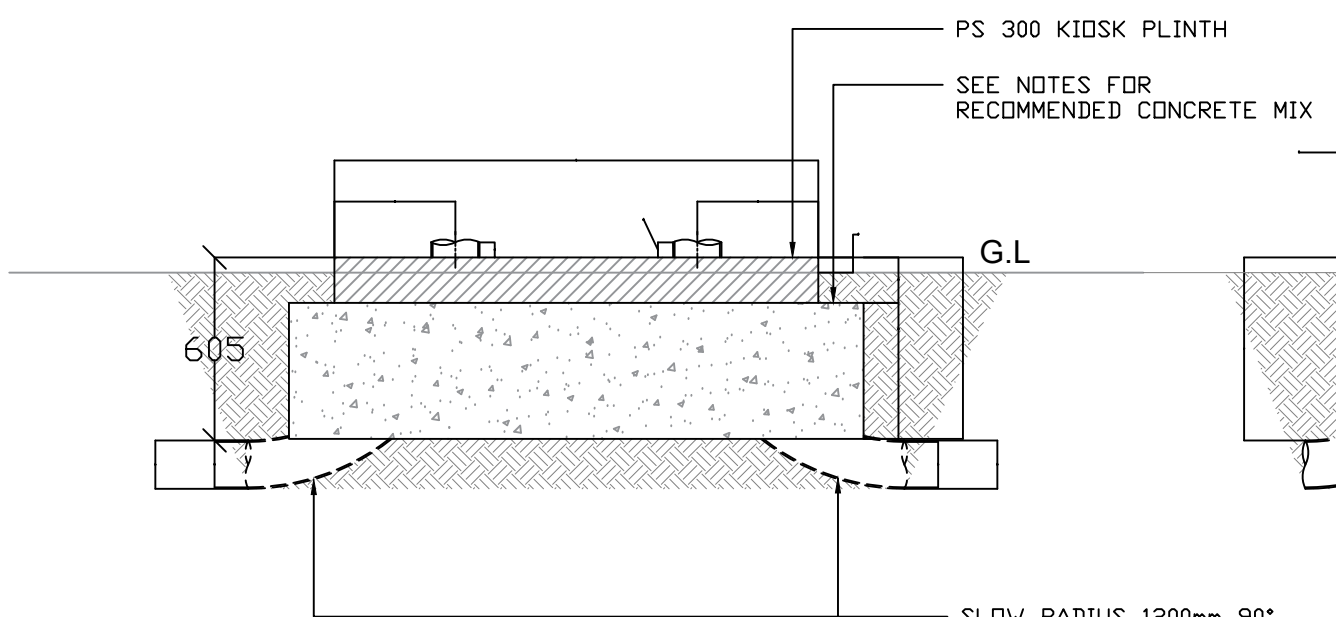


SIDE ELEVATION
(KIOSK BASE)

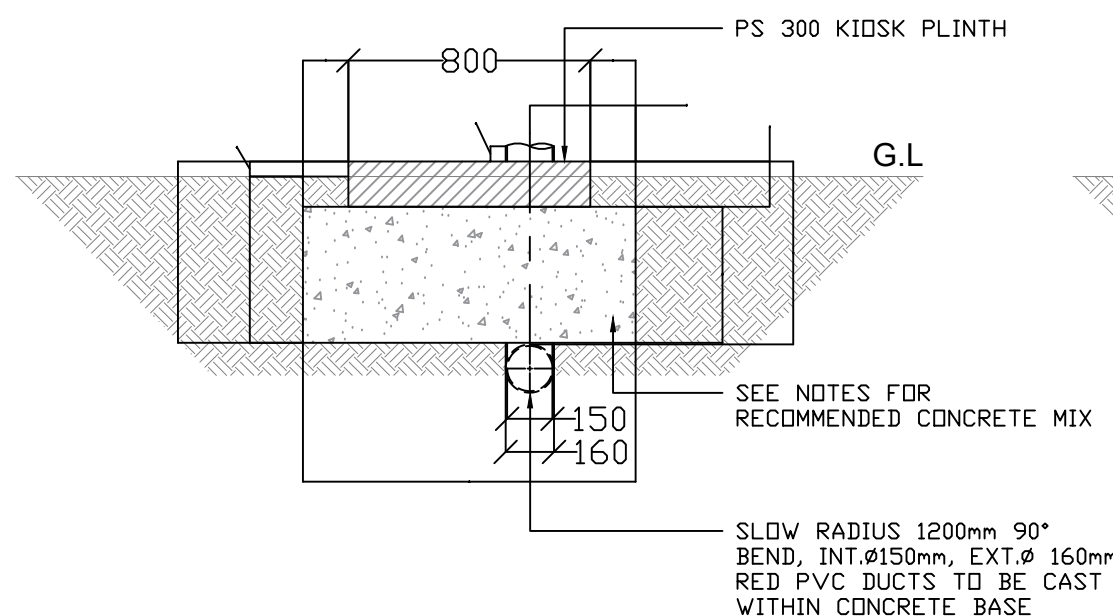


FRONT ELEVATION
(KIOSK)

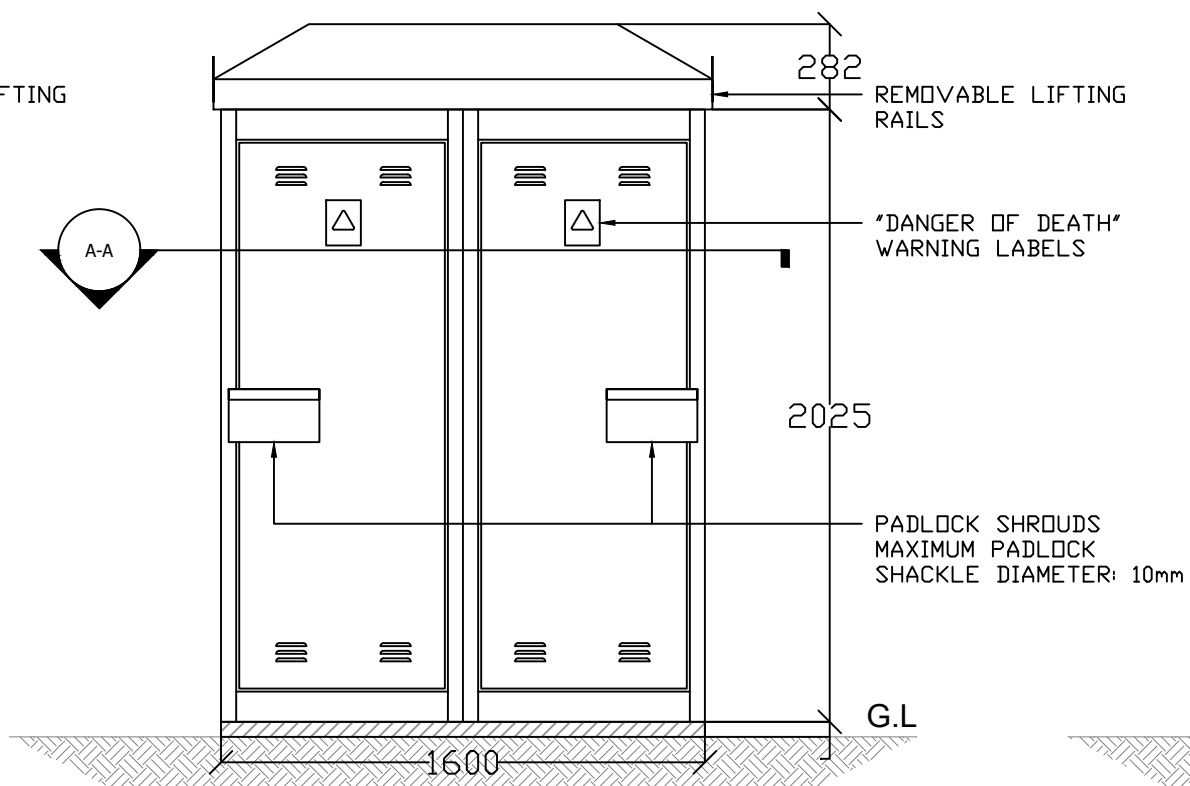


CROSS SECTION A-A
PLAN VIEW
(KIOSK)

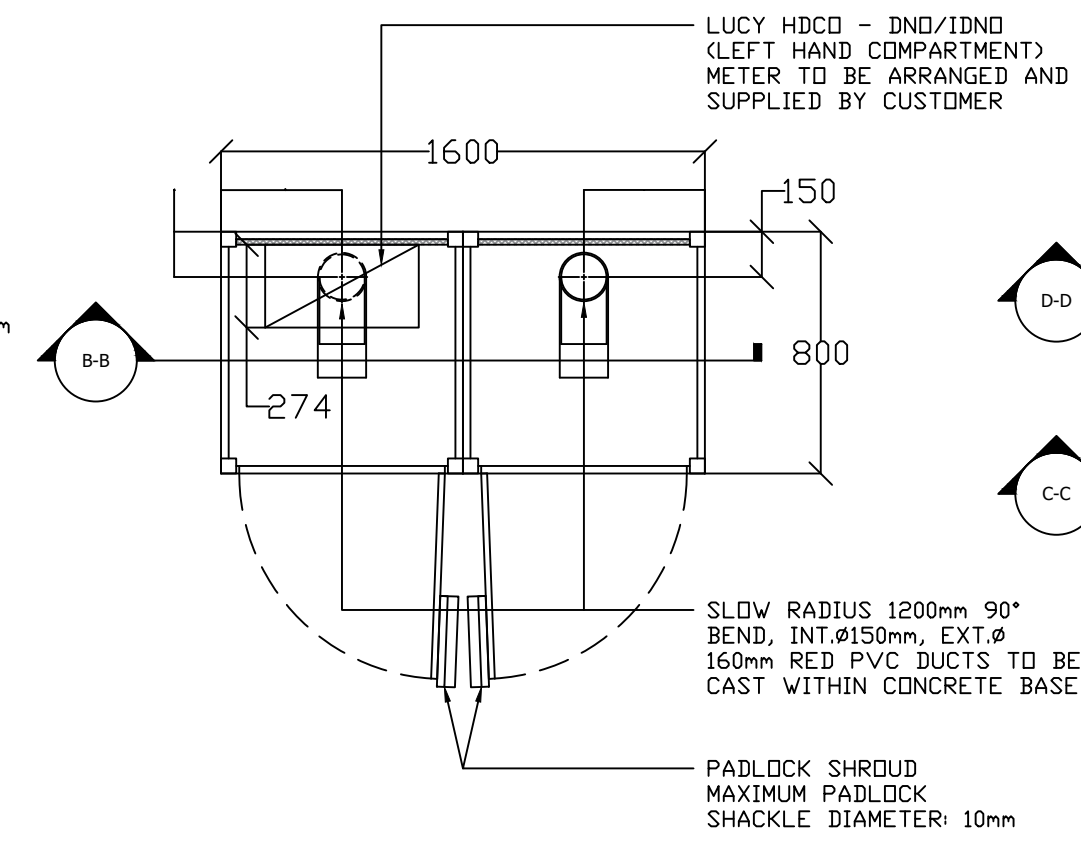


CROSS SECTION C-C

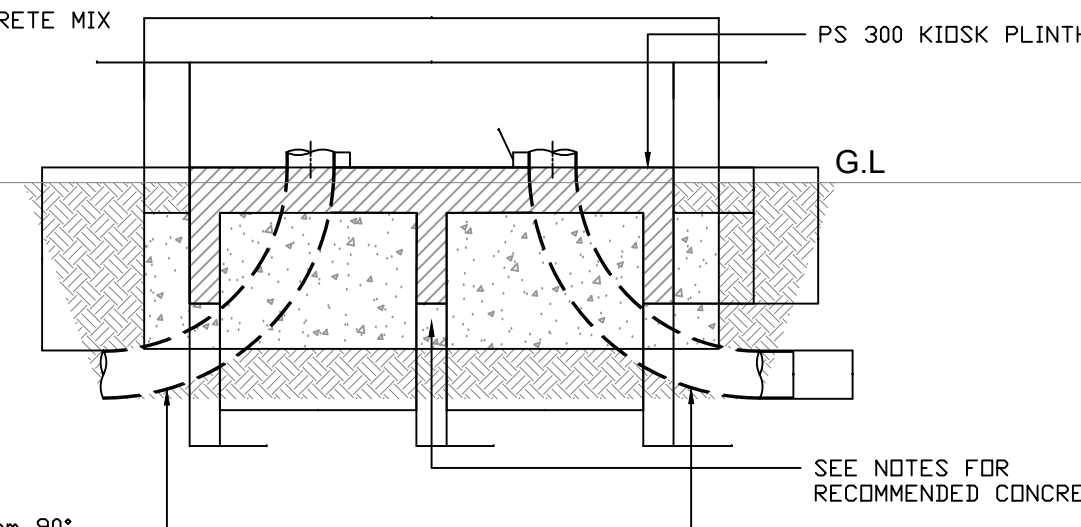


CROSS SECTION E-E

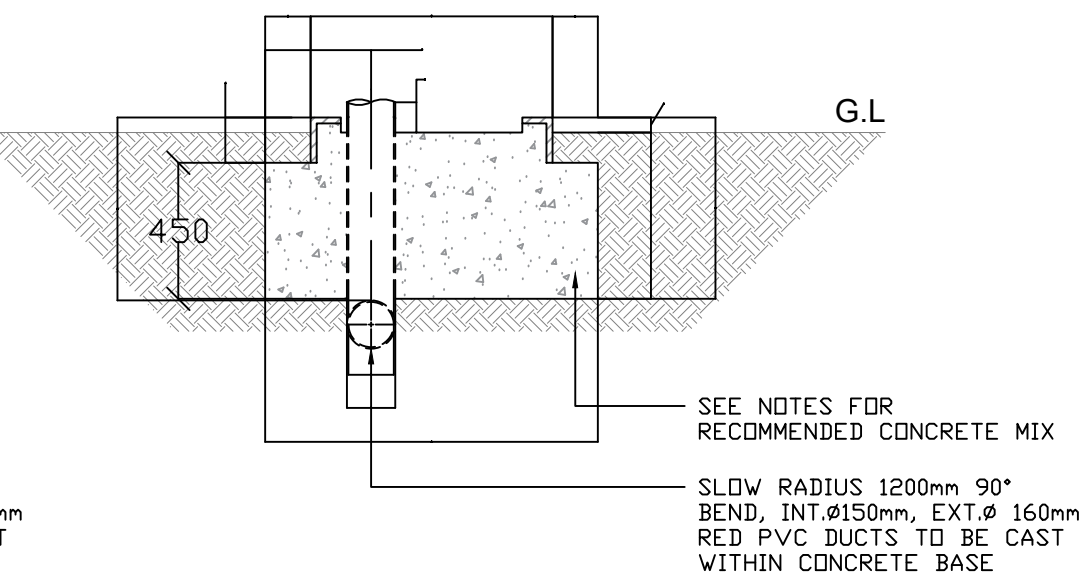


CROSS SECTION B-B

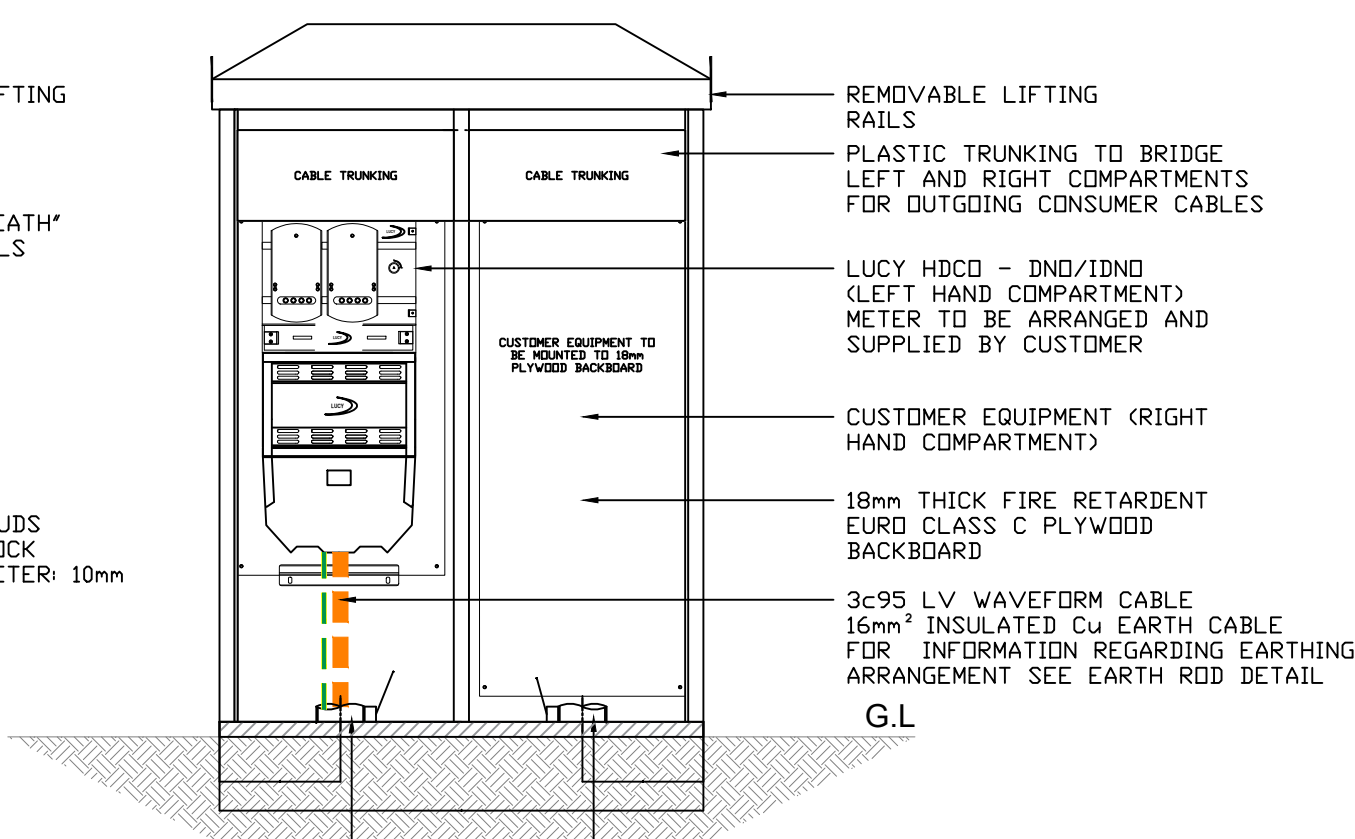


PLAN VIEW
(KIOSK BASE)

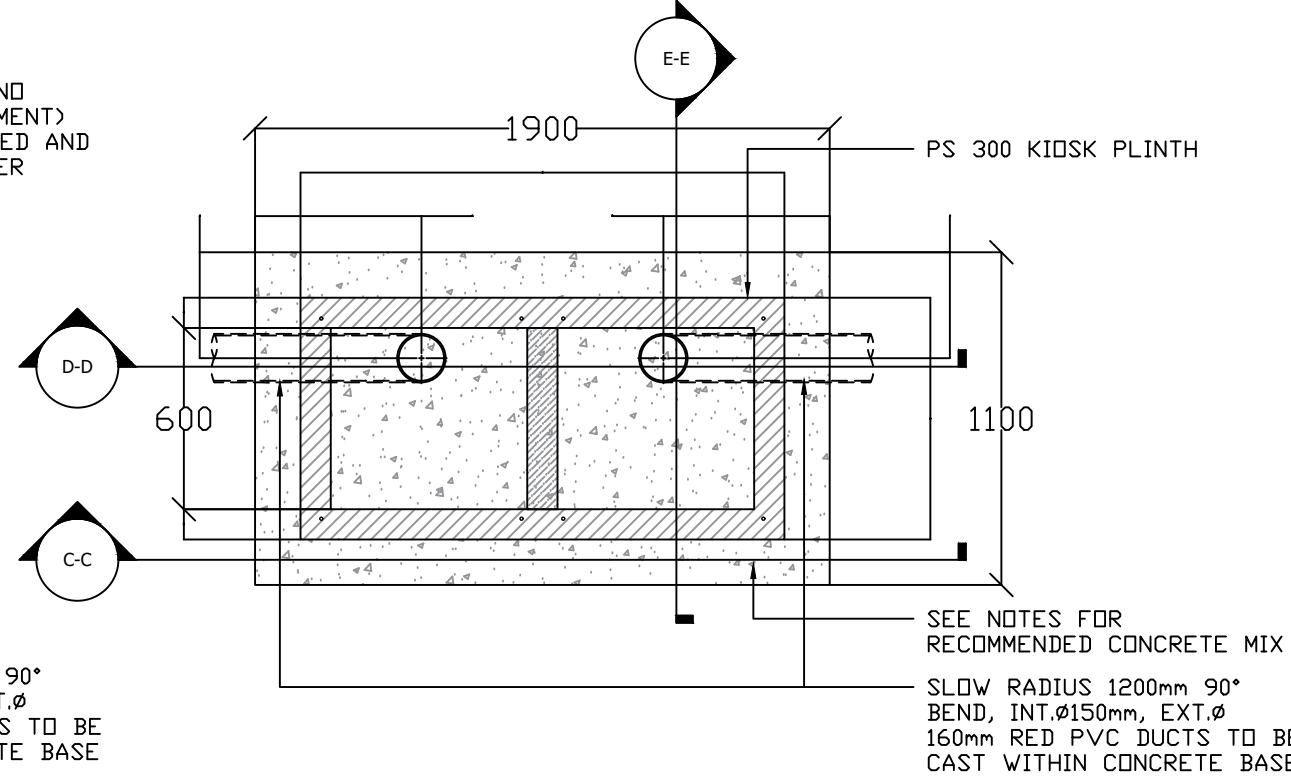


CROSS SECTION D-D

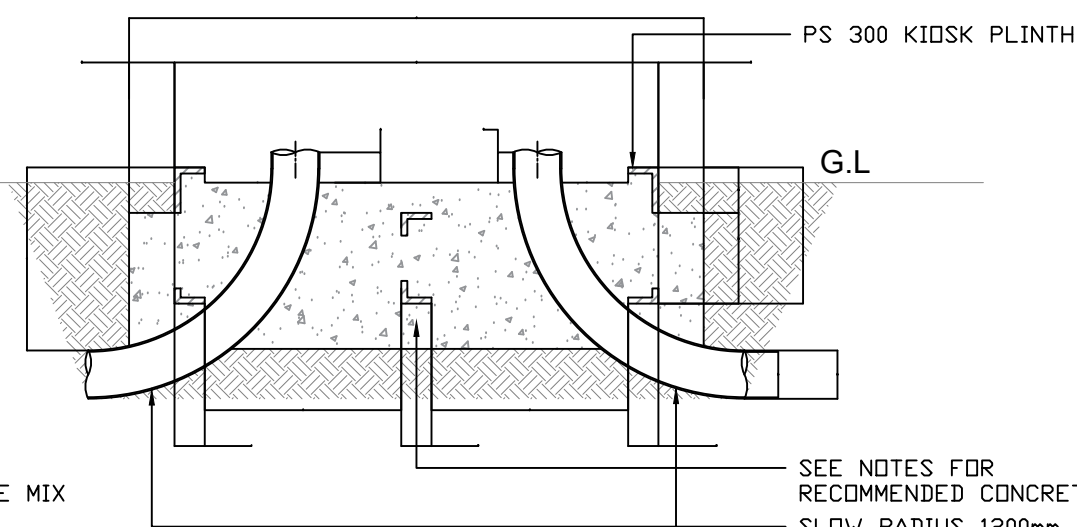


PLAN VIEW (KIOSK PLINTH)

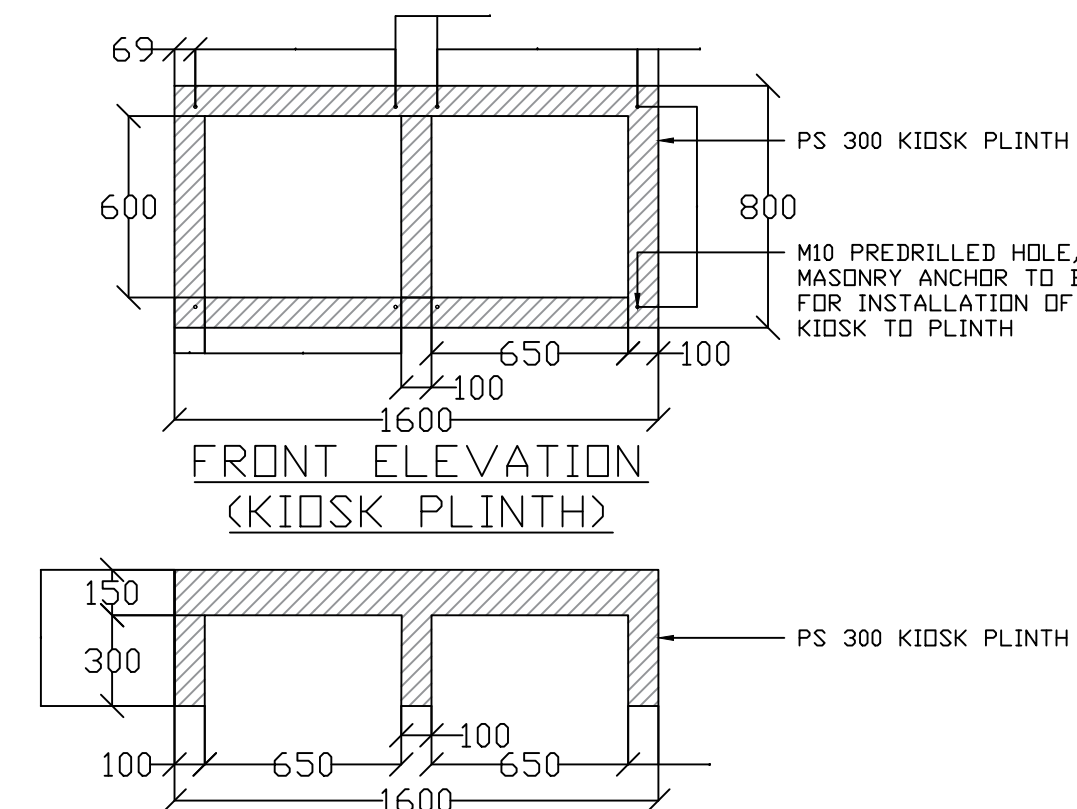


ISOMETRIC VIEW

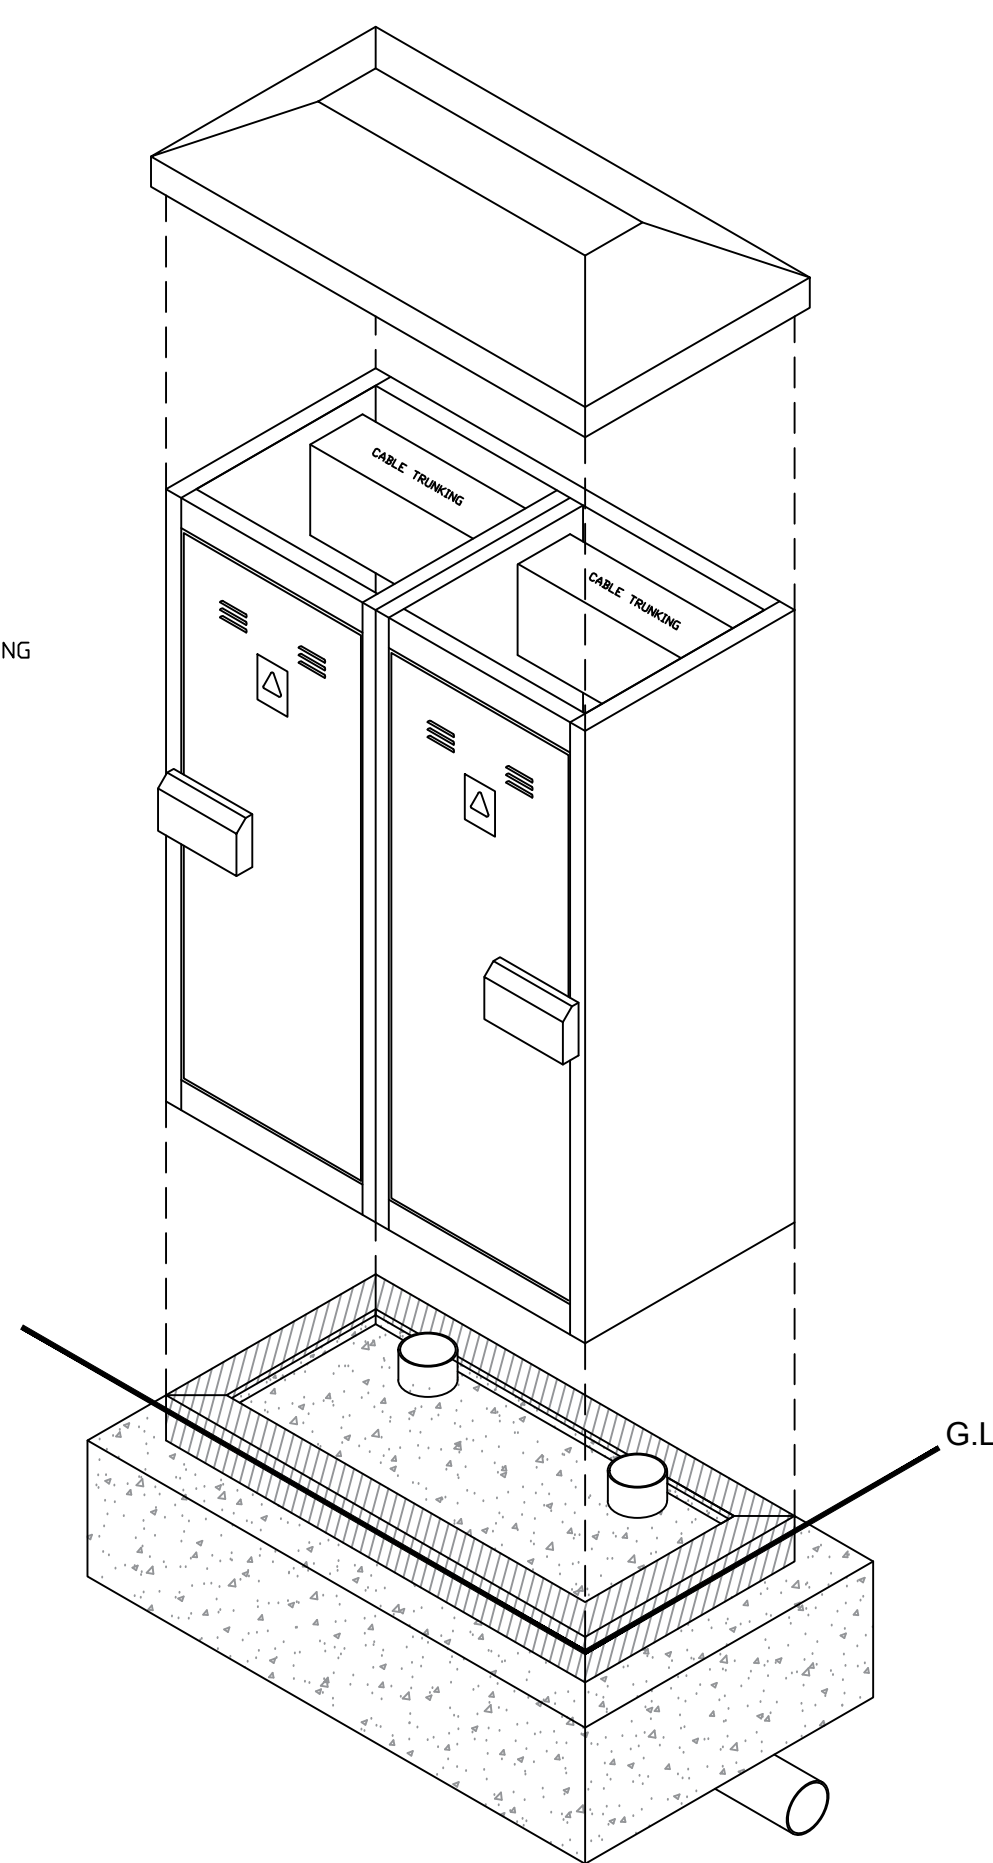



ISOMETRIC VIEW (KIOSK PLINTH)

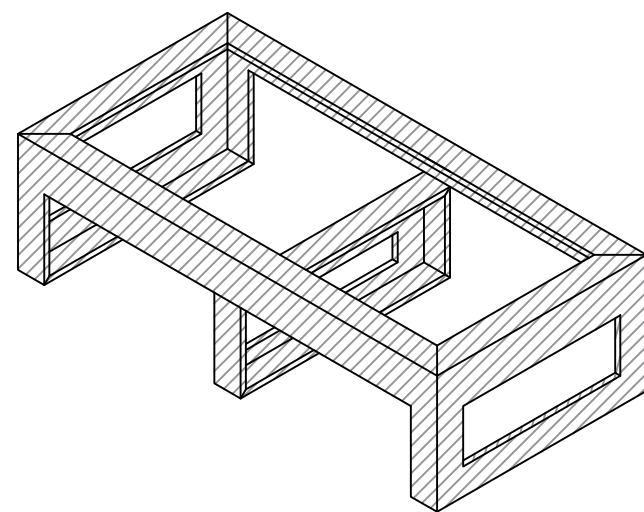

EARTH ROD DETAIL

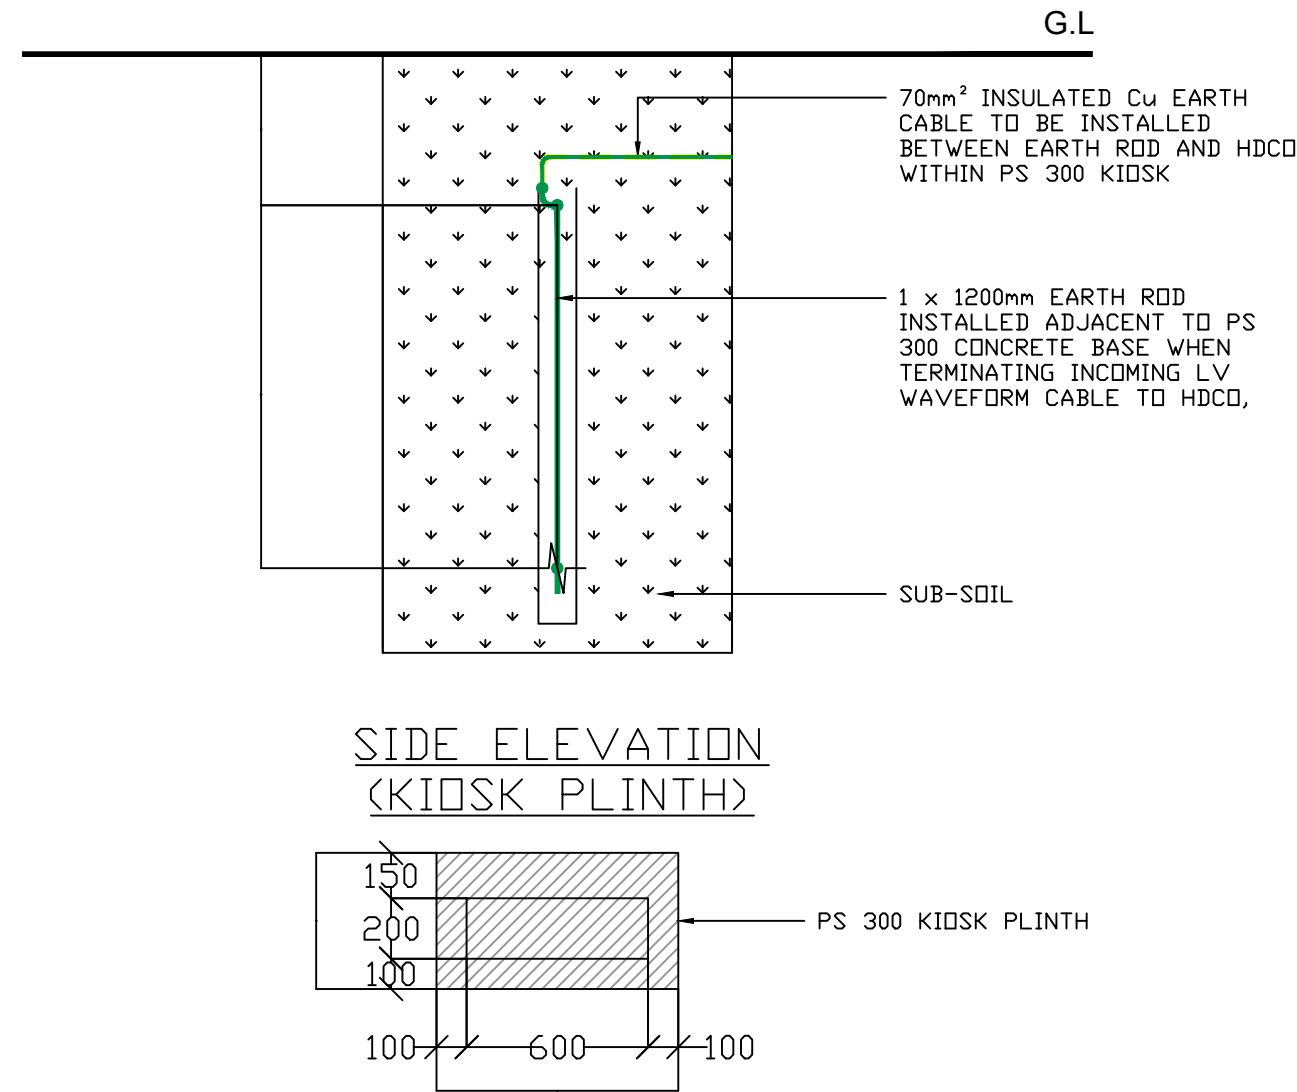

CONSTRUCTION

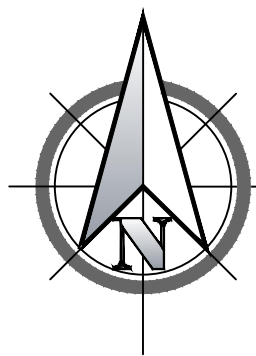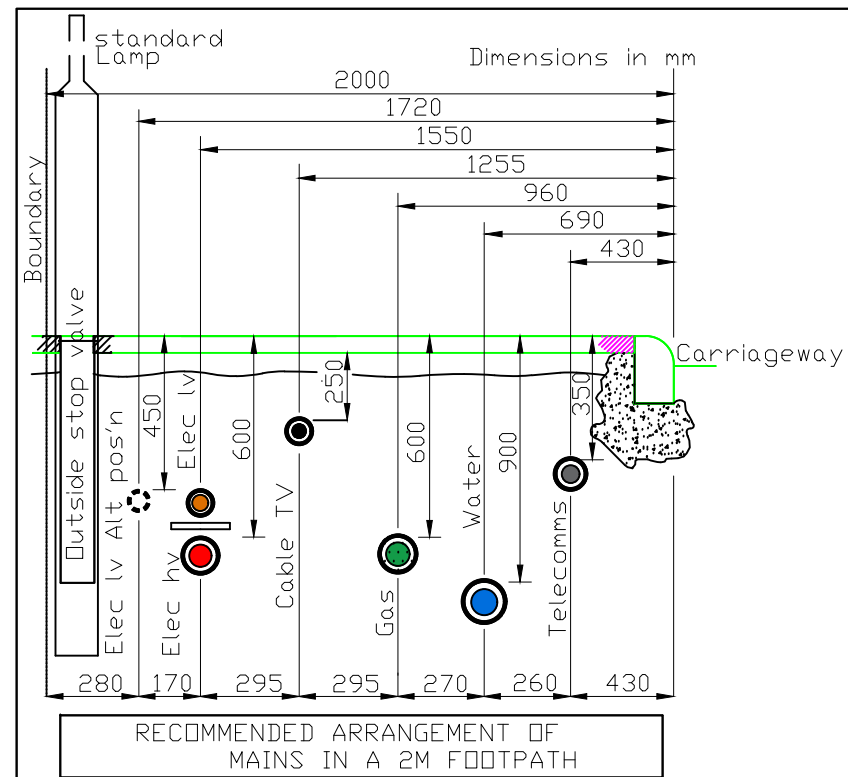

KEY	
LV EXISTING	—
LV PROPOSED	---
EARTH PROPOSED	---
INSULATED EARTH PROPOSED	---
SHORT CAP END/EARTH ROD	—
BOTTLE END	—
DUCTED CABLE	---
POINT OF CONNECTION	—

C1	11.10.23	PW	Issued For Construction	SM
Rev.	Date	R/By	Revisions	D/By

Client				
WATES GROUP LIMITED				
 ameon Utilities Engineering				
Ameon Utilities Olympic Court, Boardmans Way, Whitehills Business Park, Blackpool, FY4 5GU Tel: 01253 760160 E-mail: info@ameon.co.uk				
Job Title				
RODNEY STREET ANCOATS				
Drawing Title				
INCOMING LV SUPPLY (SHEET 3 OF 3)				
Scale		Designed by		
1:25 @ A1		JD		
Date		Drawn by		
AUGUST 2023		JD		
Drawing Number				Revision
AU/2222/E002				C1