


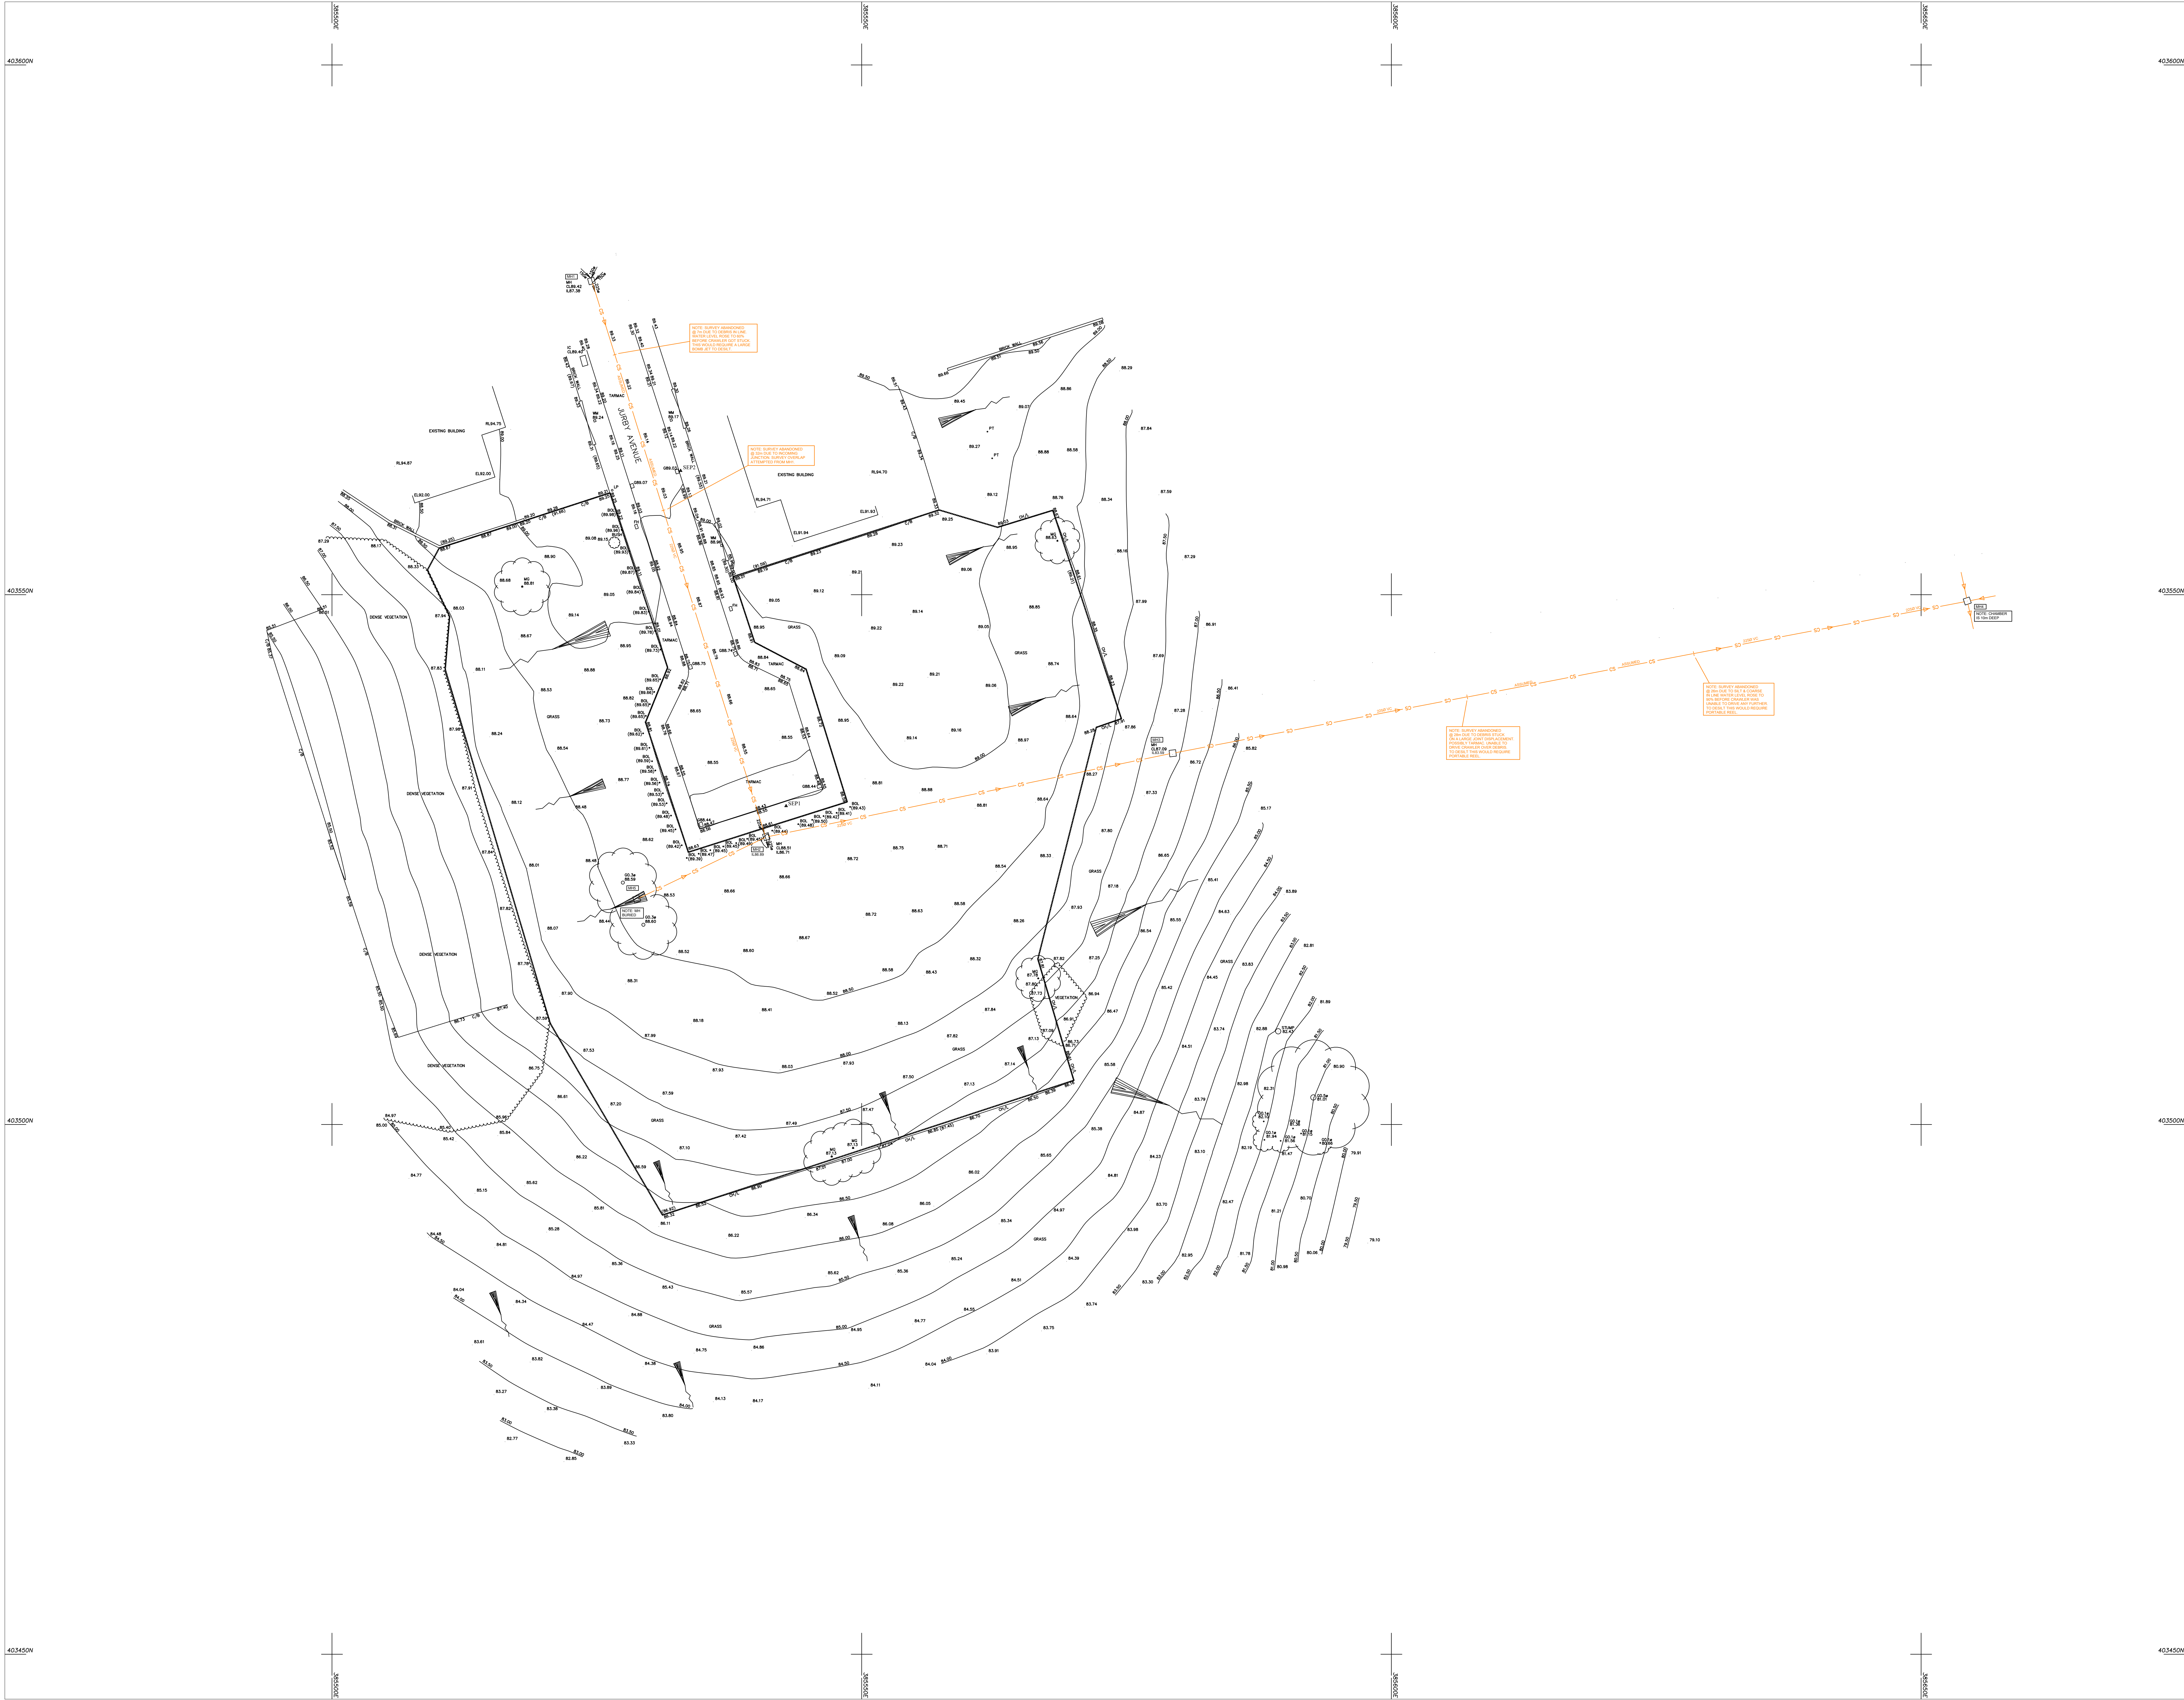

**TEAM
DRAINAGE UK**

Peel House, 2nd Floor
Peel Road, Pimbo,
Skelmersdale,
WNS SPT
Tel: 01695 768 714
WWW.teamdrainageuk.com

Survey Notes

Grid - Local
Levels - Local

Drainage Key:

Foul Water Sewer — FW —
Storm Water Sewer — SW —
Combined Water Sewer — CS —
Taken from Records —
Survey Boundary —
End of Trace —
Cap End —


Assumed Route:

Foul Water Sewer — FW — ASSUMED
Storm Water Sewer — SW — ASSUMED
Combined Water Sewer — CS — ASSUMED

Geo Positioning:

Foul Water Sewer — FW — GPS
Storm Water Sewer — SW — GPS
Combined Water Sewer — CS — GPS

Site Plan

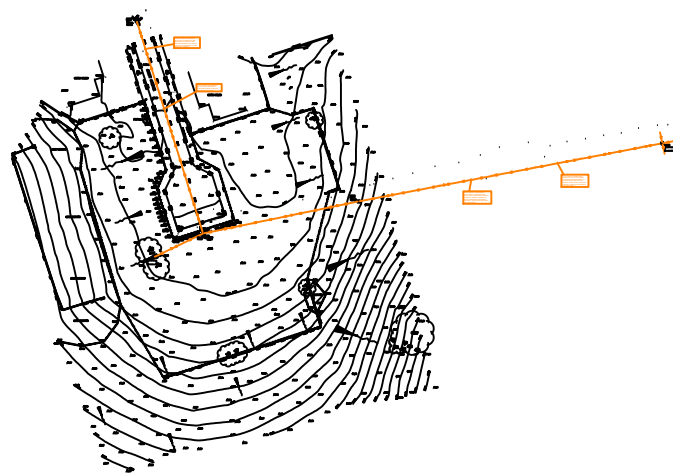

Revision

Revision	Date	Description

Client Name

Shape Consulting Engineers
Southern Office
16 London House, Swinfens Yard
Stony Stratford, Milton Keynes
MK11 1SY

Project Name

Jurby Avenue
Blackley

Drawing Title

Drainage Survey

Drawing No.	TDUK230622	Sheet No.	01	Revision	-
Drawn	AA	Date	23/06/2022		
Checked	SS	Scale	1:200		