
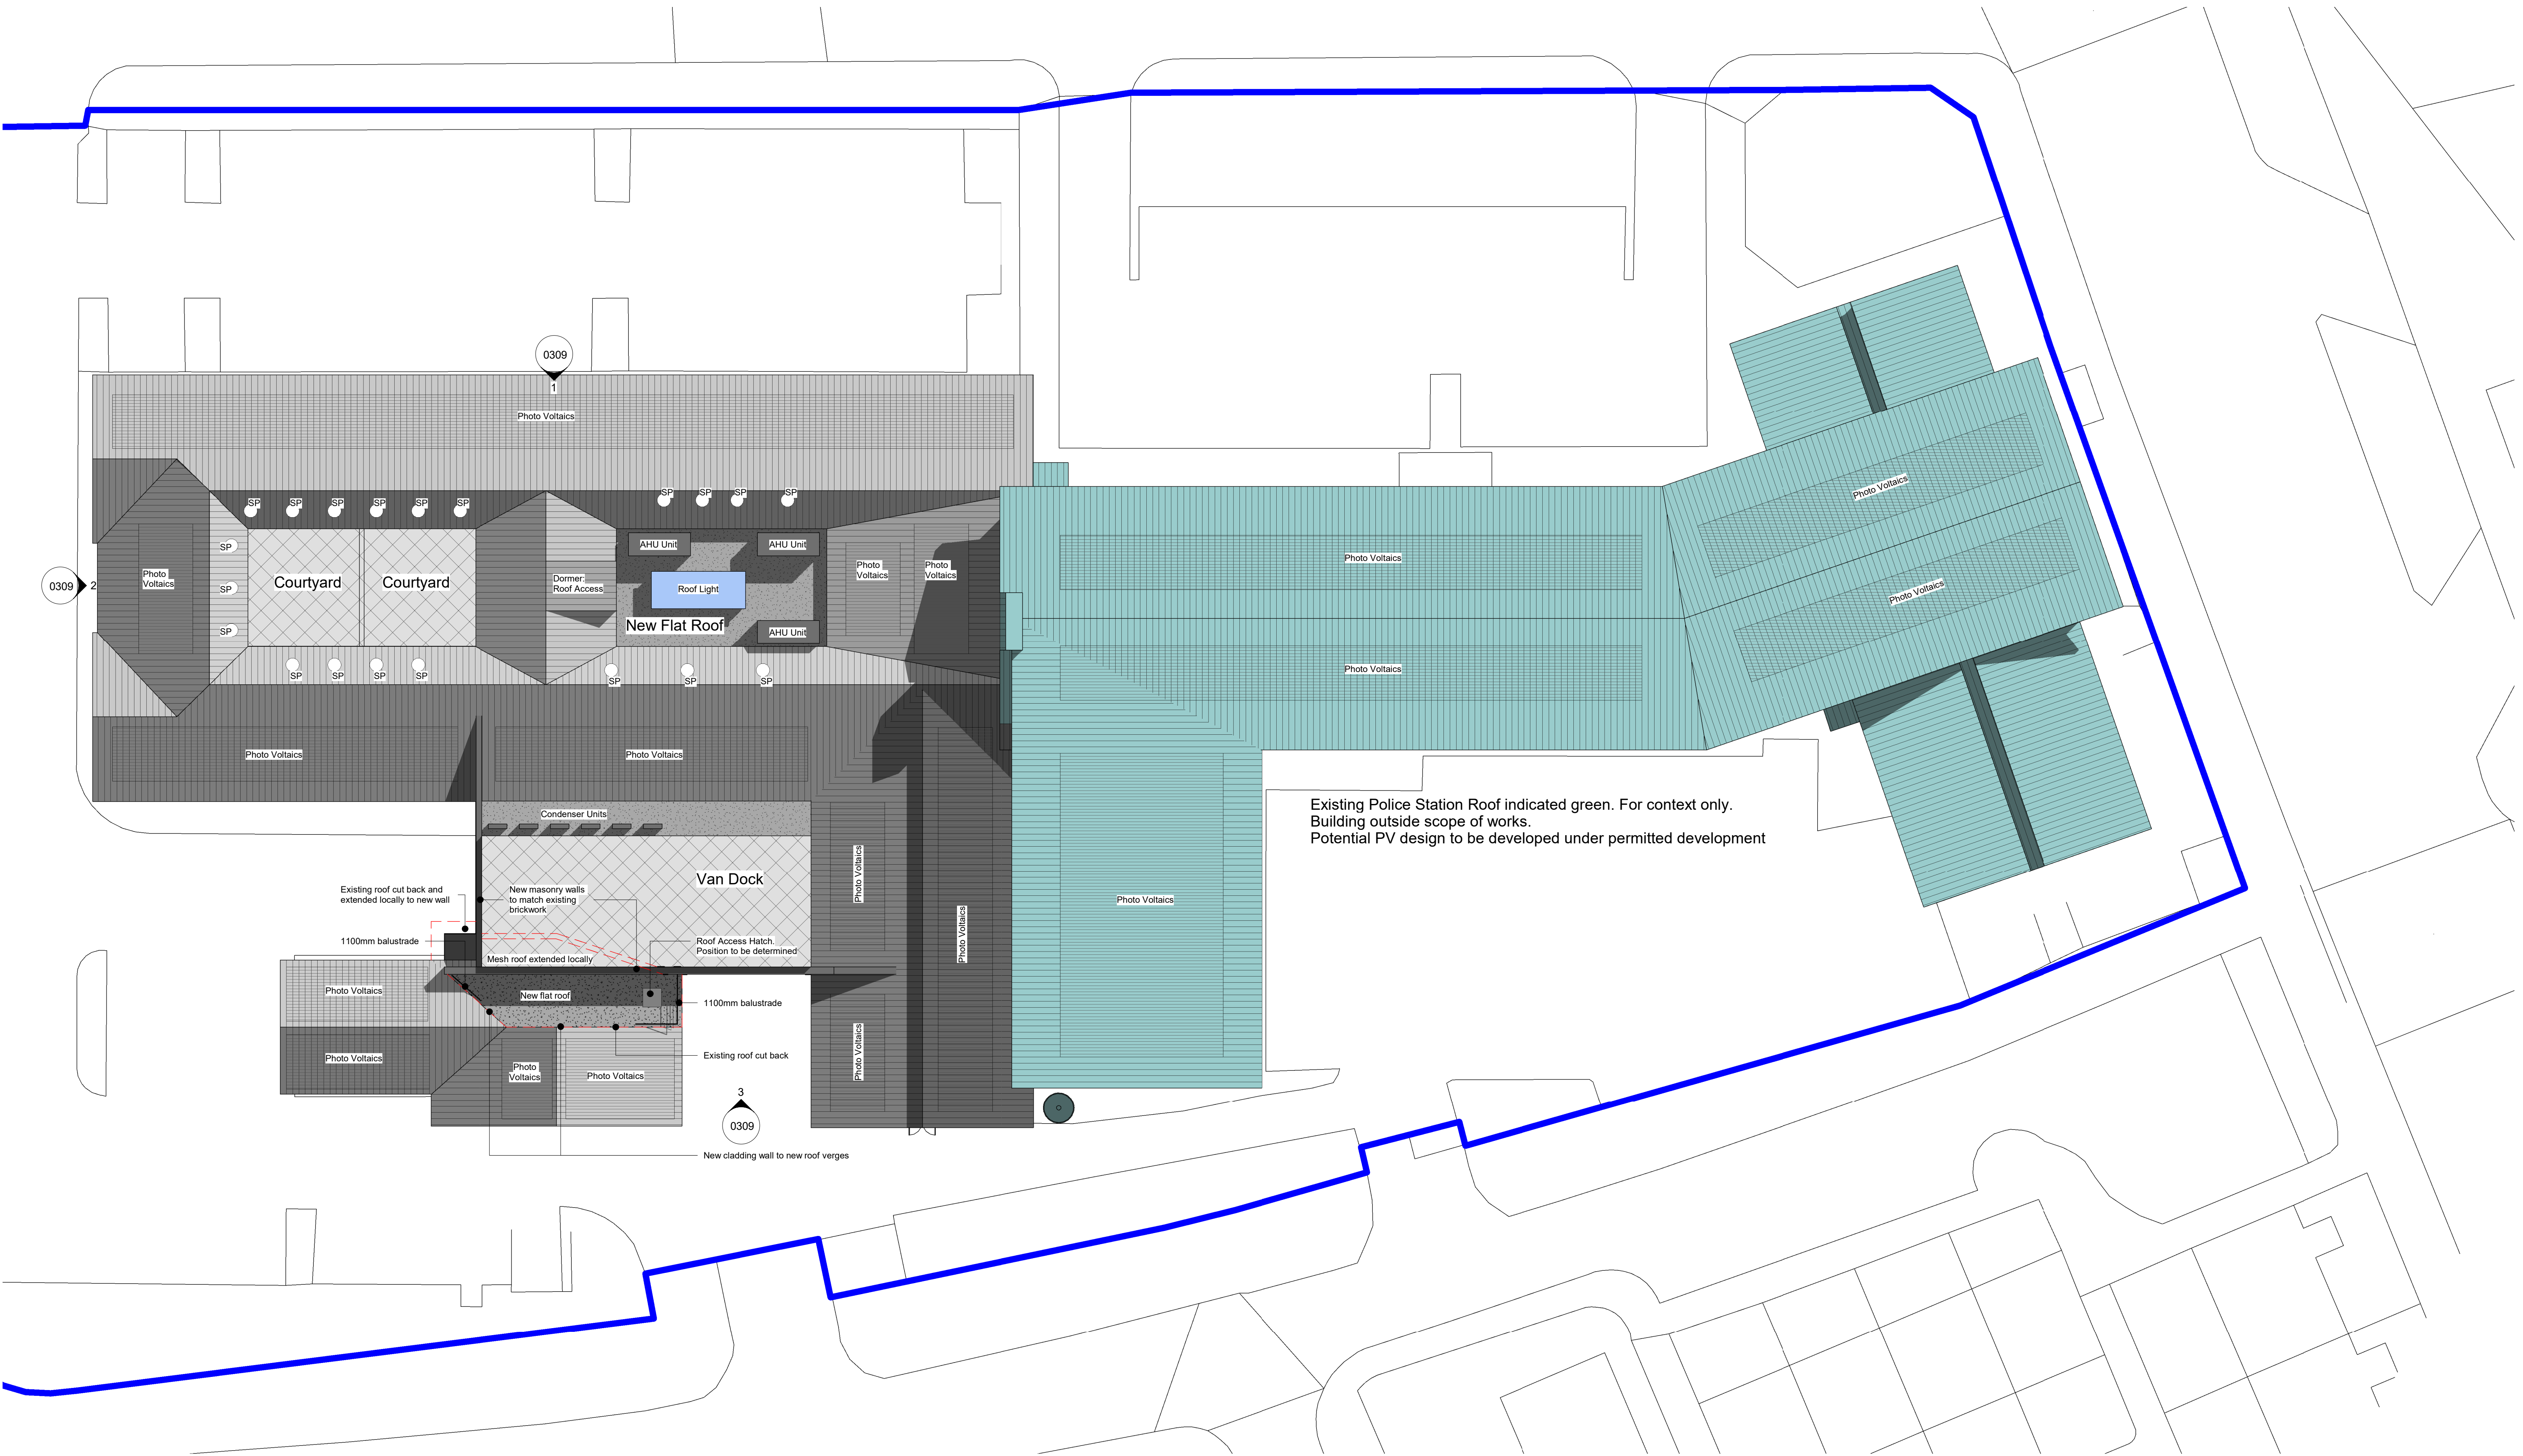


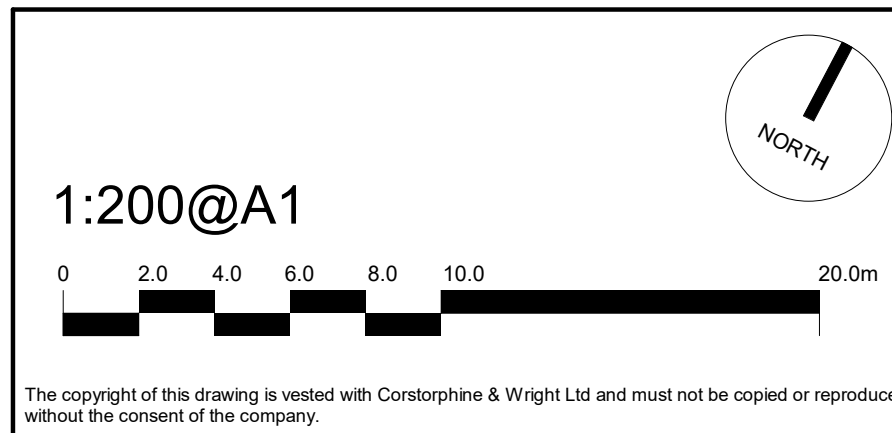

P01 Planning Application Submission		06/03/2024 JAK KE	
Rev.	Description	Date	Drw. / Chk.

Legend	
	Site Ownership Boundary
	Sun Pipe

Planning Drawings / Statement:	
LON-CWA-V1-ZZ-DR-A-0301	- Location Plan
LON-CWA-V1-ZZ-DR-A-0302	- Existing Site Plan
LON-CWA-V1-ZZ-DR-A-0303	- Proposed Site Plan
LON-CWA-V1-00-DR-A-0304	- Existing General Arrangement Plan
LON-CWA-V1-00-DR-A-0305	- Proposed General Arrangement Plan
LON-CWA-V1-RF-DR-A-0306	- Existing Roof Plan
LON-CWA-V1-RF-DR-A-0307	- Proposed Roof Plan
LON-CWA-V1-ZZ-DR-A-0308	- Existing Elevations
LON-CWA-V1-ZZ-DR-A-0309	- Proposed Elevations
LON-CWA-V1-XX-RP-A-0310	- Design and Access Statement

Client: Greater Manchester Police		<div>Corstorphine & Wright</div> <div>Manchester Studio 4th Floor, Tribeca House, 21-27 Dale Street, Manchester, M1 1EY 0161 272 8100 corstorphine-wright.com</div>	
Project: Longsight Custody Suite Refurbishment			
Drawing Title: Proposed Roof Plan		Job No. 23730	
Drawing No. LON-CWA-V1-RF-DR-A-0307		Revision P01	
Drawn JAK	Checked DD	Paper Size A1	Scale As indicated
			Date 14/02/2024