




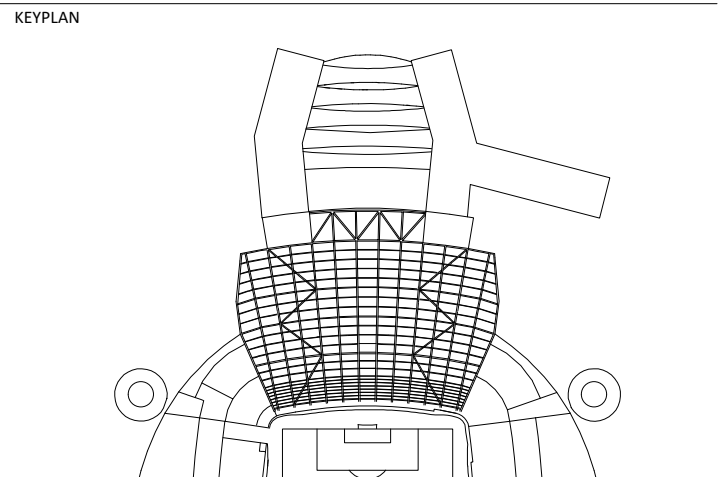

- NOTES
1. THIS DRAWING SHALL BE READ IN CONJUNCTION WITH ALL RELEVANT STRUCTURAL, ARCHITECTURAL AND CONSULTANTS' DRAWINGS.
 2. THIS DRAWING SHALL BE READ IN CONJUNCTION WITH THE EMPLOYER'S REQUIREMENTS AND SERVICES SPECIFICATION.
 3. DO NOT SCALE THIS DRAWING. ALL DIMENSIONS TO BE VERIFIED ON SITE.
 4. THIS DRAWING SHALL ONLY BE USED FOR THE SPECIFIC SERVICES INDICATED.
 5. HANDLE, STORE AND INSTALL ALL EQUIPMENT, APPARATUS AND COMPONENTS OF SERVICES IDENTIFIED ON THIS DRAWING IN ACCORDANCE WITH THE MANUFACTURERS RECOMMENDATIONS. INSPECT ALL EQUIPMENT, APPARATUS AND COMPONENTS ON DELIVERY BEFORE FIXING AND AFTER INSTALLATION AND RECTIFY AND REPLACE ANY WHICH ARE DEFECTIVE.

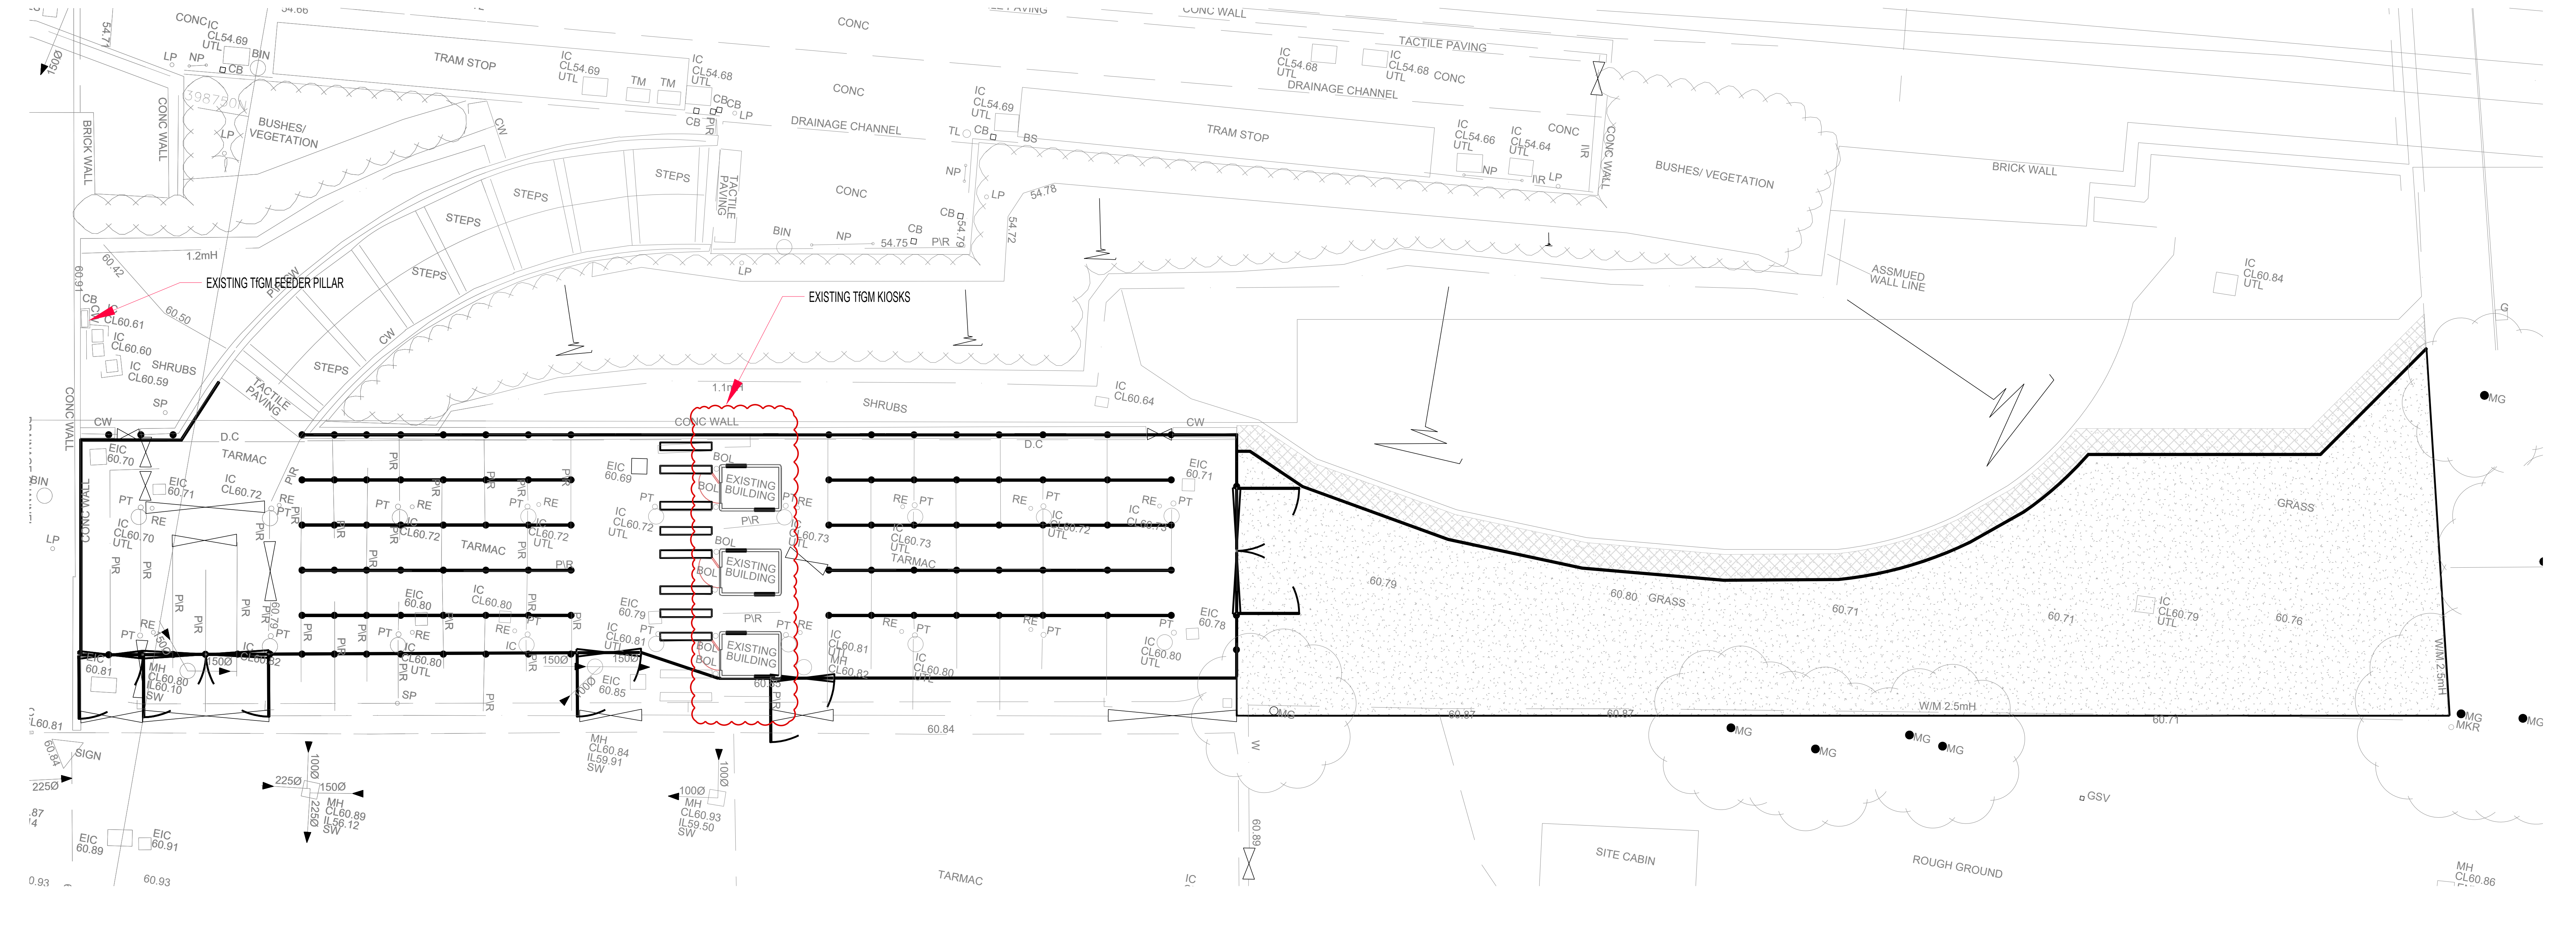

REV	DATE	DESCRIPTION
P01	05.05.23	ISSUED FOR STAGE 4

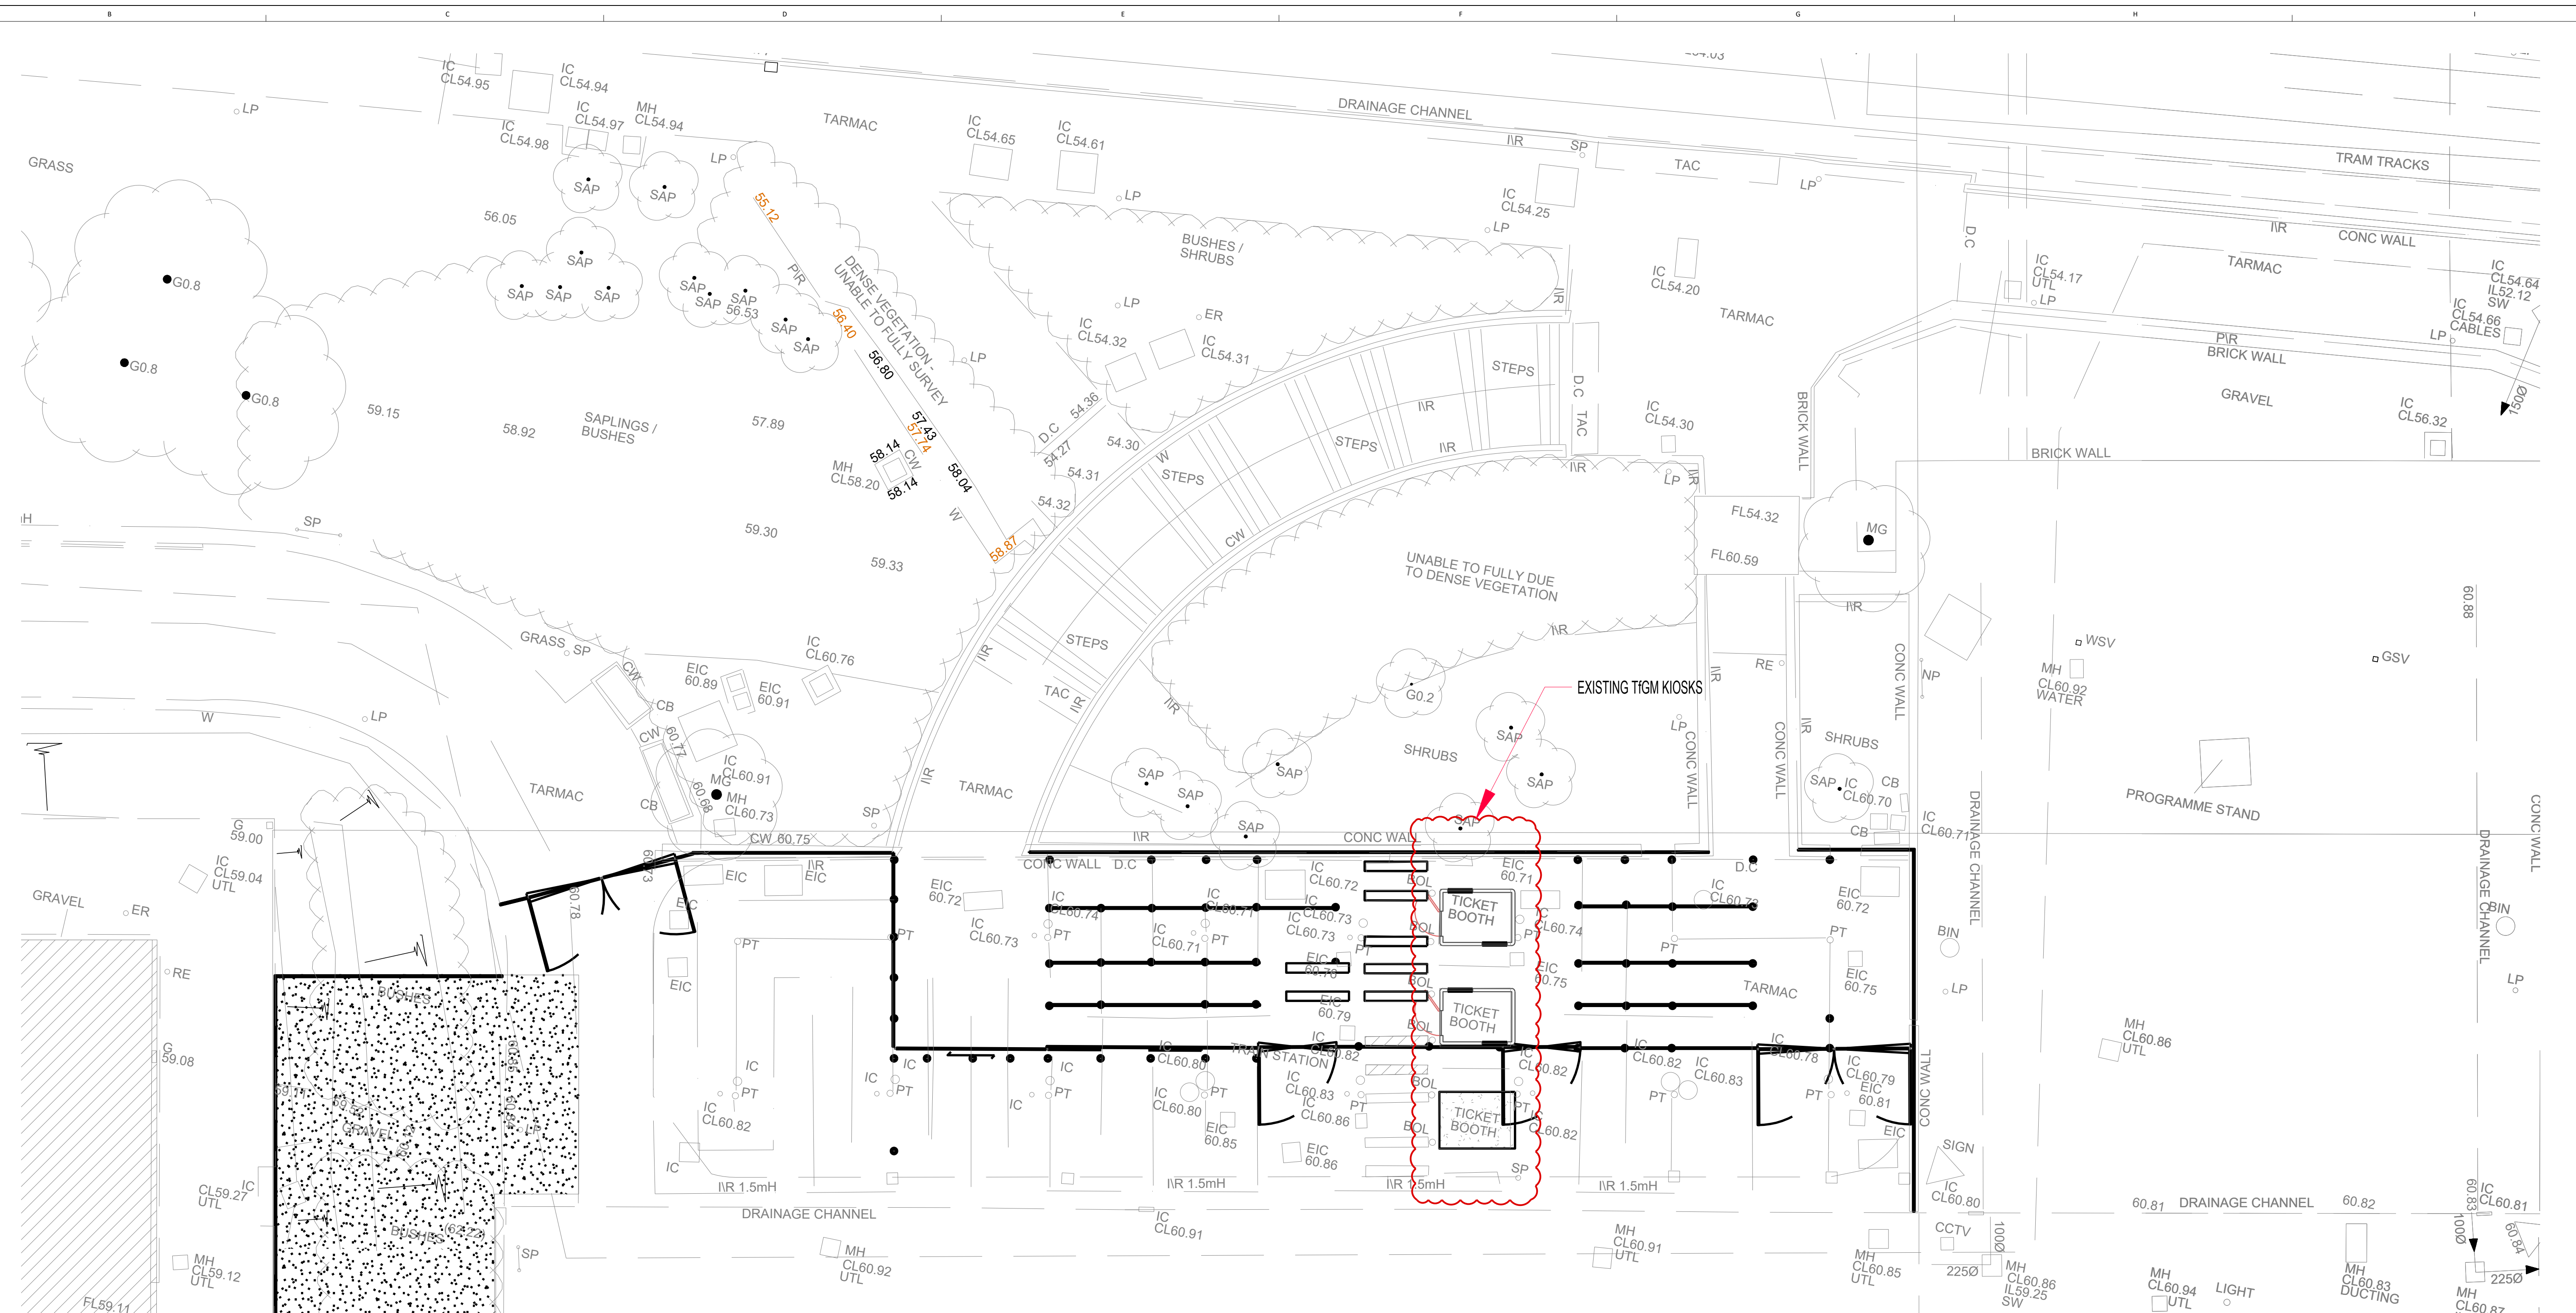

ME Engineers Ltd
Second Floor Europoint Centre
5-11 Lavington Street
London SE1 0NZ
T: +44 (0) 207 401 8382
www.me-engineers.com

PROJECT
MCFC - NORTH EXPANSION

TITLE
TGM METROLINK EXISTING
LV AND SECURITY LAYOUT

REVISION	DATE	DESCRIPTION	BY	CHKD
1	05.05.23	ISSUED FOR STAGE 4	PW	

PROJECT NO: 22005
DESIGNER: PW
DRAWN: PW
REV: P01