

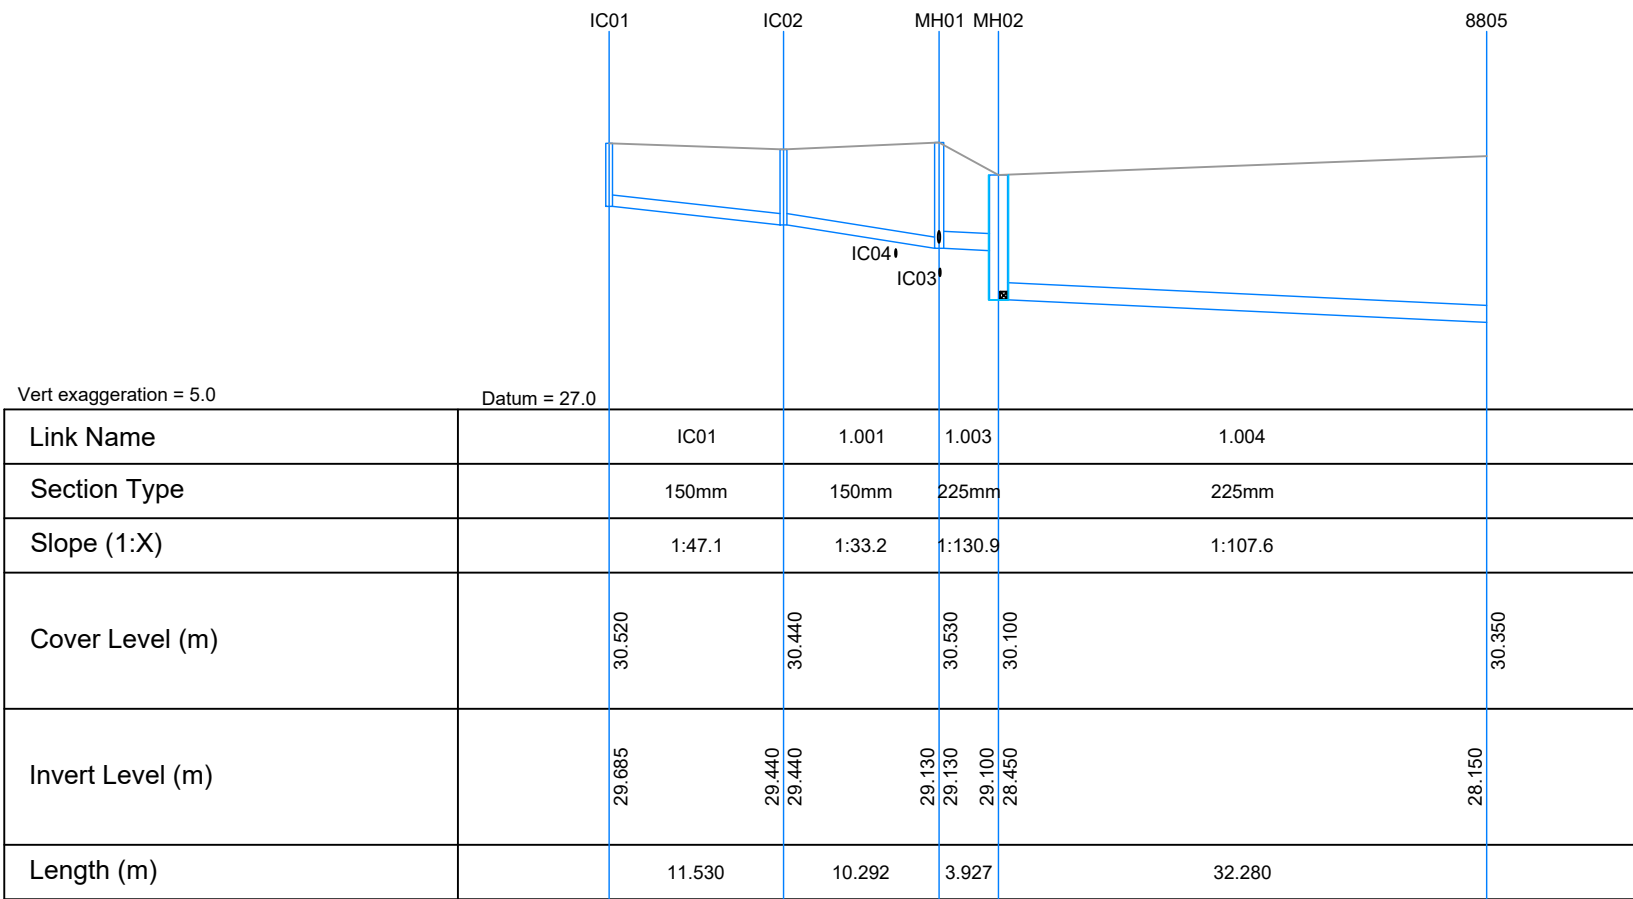


 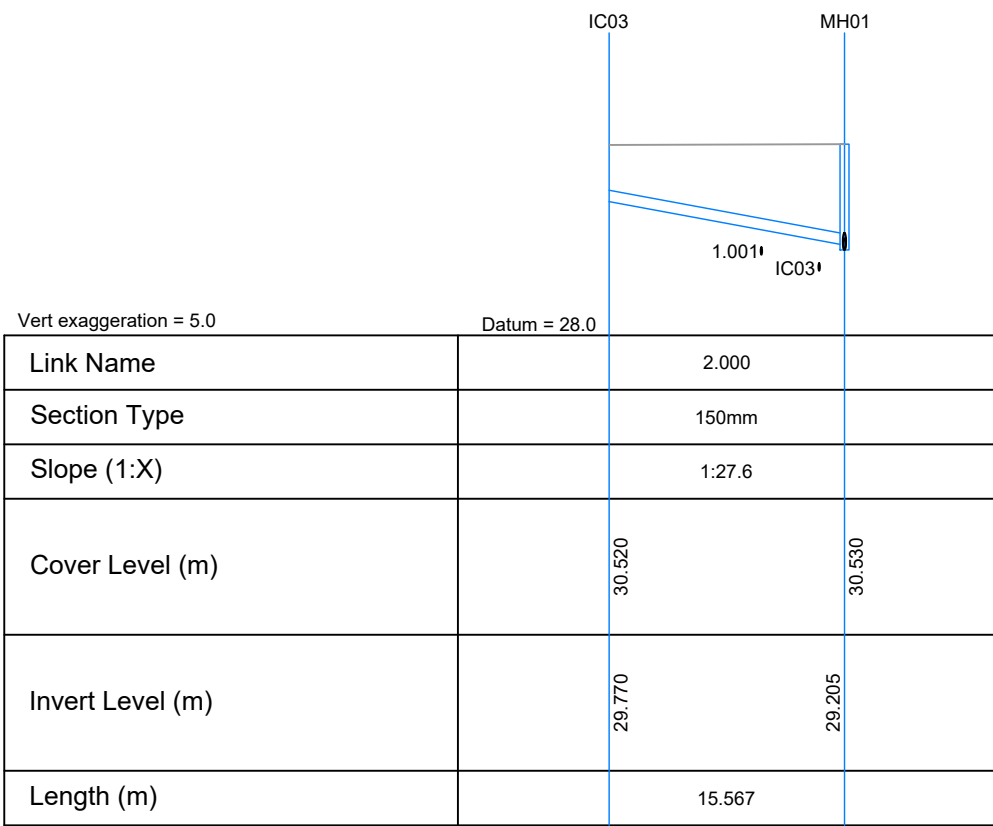


Node ID	Easting (m)	Northing (m)	CL (m)	Depth (m)	Dia (mm)	Width (mm)	Node Type	Manhole Type	Connections	Link ID	IL (m)	Dia (mm)	Link Type
IC03	382826.921	392860.296	30.520	0.750	450		Junction	Plastic Inspection Chamber	0	2.000	29.770	150	Circular
IC01	382799.005	392865.762	30.520	0.835	450		Manhole	Precast Concrete Chamber	0	IC01	29.685	150	Circular
IC02	382806.792	392874.265	30.440	1.000	450		Manhole	Plastic Inspection Chamber	1	IC01	29.440	150	Circular
MH01	382816.735	392871.608	30.530	1.400	600		Manhole	Plastic Inspection Chamber	1	1.001	29.440	150	Circular
MH02	382830.115	392877.090	30.100	1.650	1200		Manhole	Precast Concrete Chamber	1	1.001	29.130	150	Circular
8805	382832.313	392844.885	30.350	2.200	N/A		Junction	Precast Concrete Chamber	1	1.004	28.150	225	Circular

SURFACE WATER MANHOLE SCHEDULE

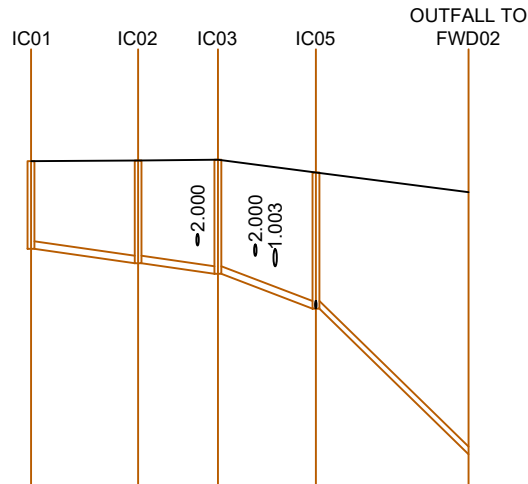

Link Name	1.000	1.001	1.002	1.003
Section Type	100mm	100mm	100mm	100mm
Slope (1:X)	1:37.3	1:37.7	1:14.1	1:5.2
Cover Level (m)	30.520	30.530	30.540	30.370
Invert Level (m)	29.360	29.170	29.030	28.570
Length (m)	7.082	5.277	6.485	10.095



Node ID	Easting (m)	Northing (m)	CL (m)	Depth (m)	Dia (mm)	Width (mm)	Node Type	Manhole Type	Connections	Link ID	IL (m)	Dia (mm)	Link Type
IC05	382815.084	392873.707	30.370	1.800	450		Manhole	Plastic Inspection Chamber	0	2.000	28.570	100	Circular
IC04	382812.677	392870.746	30.510	0.970	450		Manhole	Plastic Inspection Chamber	0	1.003	28.570	100	Circular
OUTFALL TO FWD02	382807.981	392880.881	30.110	3.467	N/A		Junction	Plastic Inspection Chamber	0	2.000	29.540	100	Circular
IC03	382819.205	392868.700	30.540	1.510	450		Manhole	Private	0	1.003	26.643	100	Circular
IC01	382828.048	392860.069	30.520	1.160	450		Manhole	Precast Concrete Chamber	0	1.001	29.030	100	Circular
IC02	382823.047	392865.083	30.530	1.360	450		Manhole	Precast Concrete Chamber	0	1.002	29.030	100	Circular

FOUL WATER MANHOLE SCHEDULE

DO NOT SCALE FROM THIS DRAWING

THIS DRAWING IS TO BE READ IN CONJUNCTION WITH ALL OTHER HBL DRAWINGS ISSUED FOR THIS PROJECT

NOTES

- ALL DIMENSIONS ARE IN MILLIMETRES AND LEVELS IN METERS UNLESS OTHERWISE SPECIFIED.
- THIS DRAWING IS TO BE READ IN CONJUNCTION WITH ALL OTHER RELATED DRAWINGS AND SPECIFICATIONS.
- THE DRAINAGE CONTRACTOR IS RESPONSIBLE TO MAKING AN APPLICATION TO ANY SEWERAGE UNDERTAKER PRIOR TO CONSTRUCTION OF ANY CONNECTION INTO A PUBLIC MANHOLE.
- THE ENGINEER IS TO BE NOTIFIED OF ANY DISCREPANCIES TO THE DETAILS SHOWN ON THE DRAINAGE AND ANY UNRECORDED CONNECTIONS NOT SHOWN ON THE DRAWINGS.
- THE CONTRACTOR IS RESPONSIBLE FOR CHECKING DIMENSIONS AND LEVELS AND FOR CONFIRMING THE GIVEN INVERT LEVEL OF OUTFALL INTO PUBLIC SEWER, WATERCOURSE OR OTHER OUTFALL PRIOR TO CONSTRUCTION WORKS COMMENCING.
- UNTIL TECHNICAL APPROVAL HAS BEEN OBTAINED FROM THE RELEVANT AUTHORITIES ALL DRAWINGS ISSUED ARE AS PRELIMINARY AND NOT FOR CONSTRUCTION. SHOULD THE CONTRACTOR COMMENCE SITE WORK PRIOR TO APPROVAL BEING GIVEN, IT IS ENTIRELY AT THEIR OWN RISK.
- TO PROTECT THE DRAINAGE SYSTEM FROM CONSTRUCTION SITE DERBIES, THE CONTRACTOR SHALL ENSURE THAT STOPPERS ARE SECURELY PLACED IN ALL CONNECTIONS IMMEDIATELY UPSTREAM OF THE TANK, ONLY TO BE REMOVED ONCE THE FINAL CLEANING OF THE ROADS/ DRAINAGE HAS BEEN COMPLETED.
- THE DESIGN IS BASED ON THE INFORMATION AVAILABLE ON THE DATE OF ISSUE FROM OTHER PARTIES (E.G. ARCHITECT AND M&E ENGINEER); IT IS SUBJECT TO CHANGE RESULTING FROM UPDATES TO THE AVAILABLE INFORMATION FROM OTHERS.
- NEW DRAINS AND SEWERS TO BE AS FOLLOWS:
 - CONSTRUCTION AND MATERIALS OF PRIVATE SURFACE, FOUL & COMBINED WATER SEWERAGE SYSTEM TO BE IN ACCORDANCE WITH "BUILDING REGULATIONS - APPROVED DOCUMENT H" & "BS EN 752:2017 DRAIN AND SEWER SYSTEMS OUTSIDE BUILDINGS"
 - CONSTRUCTION AND MATERIALS OF PUBLIC SURFACE, FOUL & COMBINED WATER SEWERS TO BE IN ACCORDANCE WITH "DESIGN & CONSTRUCTION GUIDANCE, SEWERAGE SECTOR GUIDANCE APPENDIX C" AND IN ACCORDANCE WITH LOCAL SEWERAGE UNDERTAKER
 - MINIMUM PIPE SIZE FOR ADAPTABLE SURFACE WATER DRAINAGE IS 150mmDN
 - 100mmDN AT MIN 1:100 FOR 10 DWELLINGS OR LESS
 - 150mmDN AT MIN 1:150 FOR GREATER THAN 10 DWELLINGS
 - MINIMUM PIPE SIZE FOR ADAPTABLE FOUL WATER DRAINAGE IS 100mmDN
 - 100mmDN 1:40 WHERE 10 DWELLINGS OR LESS AND NO WC
 - 100mmDN 1:80 WHERE GREATER THAN 10 DWELLINGS AND AT LEAST 1 WC
 - ALL ROAD GULLY PIPEWORK SPURS TO BE 150mmDN UNLESS OTHERWISE SPECIFIED
- LOAD CLASS SELECTION TO COMPLY WITH BS EN 124.
 - LOAD CLASS A15 - AREAS INACCESSIBLE TO MOTOR VEHICLES
 - LOAD CLASS B125 - FOOTWAYS, PEDESTRIAN AREAS ETC
 - LOAD CLASS D250 - GULLY TOPS IN KERBSIDE CHANNELS OF ROADS
 - LOAD CLASS D400 - CARRIAGEWAYS OF ROADS (HEAVY DUTY)
 - LOAD CLASS E600 - AREAS IMPOSING HIGH WHEEL LOADS
 - LOAD CLASS F900 - AREAS IMPOSING PARTICULARLY HIGH WHEEL LOADS
- ALL FOUL DRAINS BENEATH BUILDINGS AND FROM SOIL VENT PIPES, GULLIES AND WC CONNECTIONS BE 100mmDN AT A GRADIENT NOT LESS THAN OF 1:40.
- ALL FOUL CONNECTIONS TO BE FULLY TRAPPED AND EACH FOUL CONNECTION TO A BRANCH DRAIN TO HAVE FULL RODDING ACCESS (E.G. LOW-LEVEL RODDING ACCESS).
- RAINWATER DOWN PIPES ARE TO CONNECT TO A DRAIN VIA A REST BEND.
- WHERE DRAINAGE IS COMBINED A 'P' TRAP MUST BE PROVIDED ABOVE PROPOSED FLOOR SLAB LEVEL.
- MINIMUM DEPTH OF COVER TO THE CROWN OF GRAVITY PIPES WITHOUT PROTECTION SHOULD BE AS FOLLOWS (IN ACCORDANCE WITH "DESIGN & CONSTRUCTION GUIDANCE, SEWERAGE SECTOR GUIDANCE APPENDIX C")
 - 350mm - DOMESTIC GARDENS AND PATHWAYS WITHOUT ANY POSSIBILITY OF VEHICULAR ACCESS
 - 500mm - DOMESTIC DRIVEWAYS, PARKING AREAS AND YARDS WITH HEIGHT RESTRICTIONS TO PREVENT ENTRY BY VEHICLES WITH A GROSS WEIGHT IN EXCESS OF 7.5 TONNES.
 - 900mm - DOMESTIC DRIVEWAYS, PARKING AREAS AND NARROW STREETS WITH LIMITED ACCESS FOR VEHICLES WITH A GROSS WEIGHT IN EXCESS OF 7.5 TONNES.
 - 900mm - AGRICULTURAL LAND & PUBLIC OPEN SPACE
 - 1200mm - HIGHWAYS AND PARKING AREAS WITH UNRESTRICTED ACCESS TO VEHICLE WITH A GROSS WEIGHT IN EXCESS OF 7.5 TONNES.
- BACKFILL TO DRAINAGE TRENCHES UNDER CARRIAGEWAYS TO BE TYPE 1 SUB-BASE MATERIAL, ELSEWHERE BACKFILL TO BE FREE DRAINING READILY AVAILABLE COMPACTABLE MATERIAL, FREE FROM RUBBISH, ORGANIC MATTER, FROZEN SOIL, CLAY LUMPS AND LARGE STONES. TO BE COMPACTED IN LAYERS NOT EXCEEDING 250mm THICK
- A FLEXIBLE JOINT SHALL BE PROVIDED AS CLOSE AS IS FEASIBLE TO THE OUTSIDE FACE OF ANY STRUCTURE INTO WHICH A PIPE IS BUILT, COMPATIBLE WITH THE SATISFACTORY COMPLETION AND SUBSEQUENT MOVEMENTS OF THE JOINT. LENGTH OF THE NEXT PIPE (ROCKER PIPE) IS TO BE IN ACCORDANCE WITH THE TABLE BELOW
 - 150-600mmDN - 600mm LONG ROCKER PIPE
 - 601-750mmDN - 1000mm LONG ROCKER PIPE
 - 751mmDN AND ABOVE - 1250mm LONG ROCKER PIPE
- PIPE CROSSEOVERS TO HAVE MINIMUM OF 300mm CLEARANCE BETWEEN OUTSIDE TOP OF THE LOWER PIPE AND OUTSIDE BOTTOM OF THE UPPER PIPE, WHERE THIS CANNOT BE ACHIEVED A SEPARATION, CONCRETE SURROUND IS TO BE FORMED WHICH WILL EXTEND NOT LESS THE 1000mm EACH SIDE OF THE CROSSING POINT, THE EXTENT OF THE CONCRETE SHOULD BE WITHIN 150mm OF A FLEXIBLE PIPE JOINT. THE CONCRETE SPECIFICATION SHOULD BE IN ACCORDANCE WITH THE STANDARD DETAILS FOR PIPE BED AND SURROUND AS ISSUED BY THE ENGINEER.
- CONCRETE MIXES INDICATED ON THIS DRAWING ARE DESIGNATED MIXES CONFORMING TO BS 8500-1:2006. ALL CONCRETE TO BE SULPHATE RESISTANT. CONTRACTOR SHOULD ALLOWANCE FOR CARRYING OUT TESTING ONSITE TO CONFIRM SULPHATE LEVEL CLASSIFICATION.
- ALL PRIVATE MANHOLES AND INSPECTION CHAMBERS TO BE CONSTRUCTED IN ACCORDANCE WITH "BUILDING REGULATIONS - APPROVED DOCUMENT H" & "BS EN 752:2017 DRAIN AND SEWER SYSTEMS OUTSIDE BUILDINGS"
- ALL MANHOLES AND INSPECTION CHAMBERS TO BE ADOPTED TO BE CONSTRUCTED IN ACCORDANCE WITH "IN ACCORDANCE WITH" DESIGN & CONSTRUCTION GUIDANCE, SEWERAGE SECTOR GUIDANCE APPENDIX C" AND IN ACCORDANCE WITH LOCAL SEWERAGE UNDERTAKER.
- CCTV SURVEY OF ALL THE DRAINAGE SHOULD BE CARRIED OUT ON COMPLETION OF THE BUILDING WORKS AND PASSED ON TO THE CLIENT.
- ANY EXISTING DRAINAGE INFRASTRUCTURE TO BE RETAINED TO HAVE NEW COVERS AND FRAMES TO SUIT NEW LEVELS AND SURFACING.

C02	FEB'24	AP	AS BUILT ISSUE	AP	AP
C01	JAN'24	AP	UPDATED IN LINE WITH AS BUILT SURVEY	AP	AP
P04	FEB'22	AP	DRAINAGE LAYOUTS REVISED	AP	AP
P03	JULY'21	AP	PLANNING LAYOUT UPDATED	AP	HL
P02	JUNE'21	AP	SW & FV SCHEME UPDATED	AP	HL
P01	MAY'21	AP	FIRST ISSUE	AP	HL
REV.	DATE	DRAWN	DESCRIPTION	CHKD	APPRD

STATUS DESCRIPTION				STATUS	
AS BUILT RECORD				CR	



Brook House
Weybrook Road,
Manchester M19 2QD
+44 (0)161 432 9977 | www.hbl.ltd
Consulting Civil & Structural Engineers

PROJECT

NEW APARTMENTS
NELL LANE, CHORLTON

DRAWING TITLE

AS BUILT FOUL & SURFACEWATER DRAINAGE
LONG SECTIONS & MANHOLE SCHEDULES

CLIENT

SOUTHWAY HOUSING

HBL REF.	DATE	SCALE(S)	
8796	MAY 2021	1:500h - 1:100v	A1

DRAWN	CHECKED	APPROVED
A. PRINCE	A. PRINCE	H. LONG

DRAWING No.	REV.
8796-HBL-XX-XX-DR-D-0507	C01

AS BUILT DRAWING

THIS DRAWING IS A TRUE REPRESENTATION OF THE AS-BUILT INFORMATION HBL ASSOCIATES HAVE BEEN PROVIDED WITH. WE DO NOT ACCEPT ANY LIABILITY FOR THE DESIGN OR CONSTRUCTION OF THE SURFACE AND/OR FOUL DRAINAGE SYSTEMS AS THESE DEVIATED FROM THE PROPOSED DESIGN