


THE COPYRIGHT OF THIS DRAWING IS HELD BY TeDS
(ELECTRICAL) LTD, AND NO REPRODUCTION IS ALLOWED
WITHOUT PRIOR WRITTEN AND SIGNED PERMISSION.

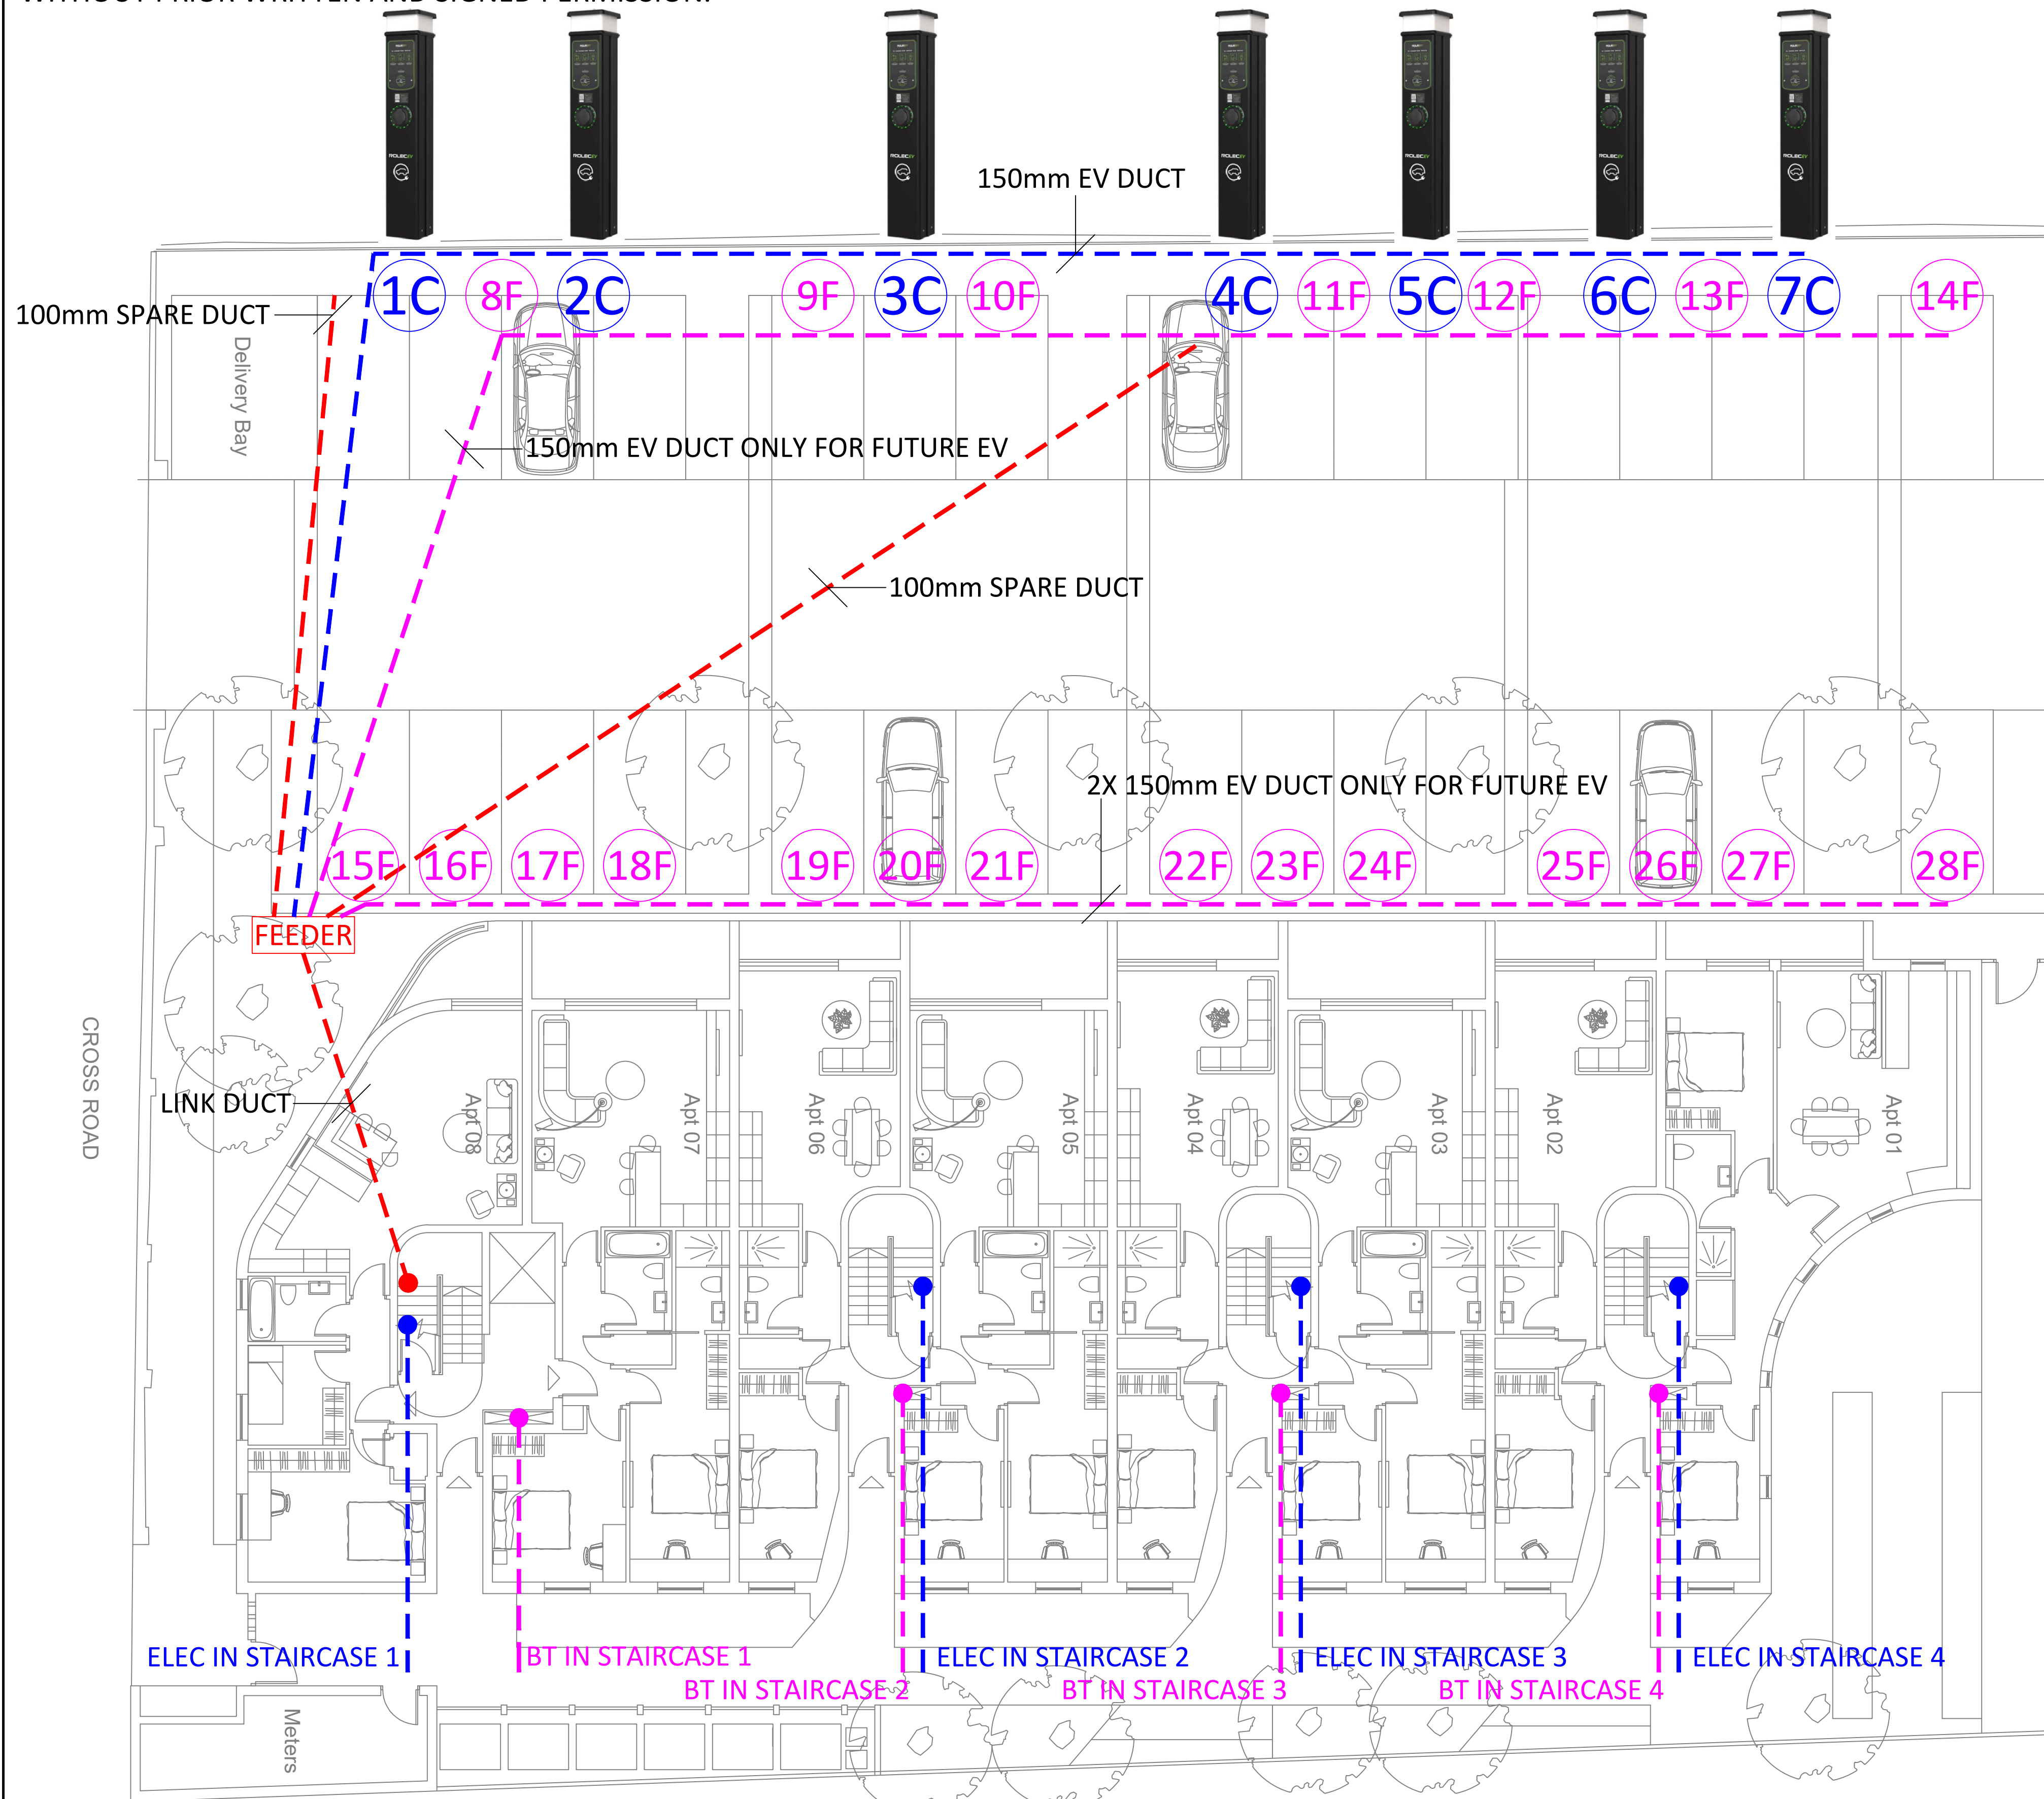

C

**ROLEC0211B EV CHARGER 7.4KW BLK -
SINGLE OUTLET FREESTANDING (7No.)**

F

DUCT ONLY FOR FUTURE USE (21No.)

FEEDER

FEEDER PILLAR FOR EV CHARGERS & FUTURE DUCTING. SUPPLY ORIGIN FROM STAIRCORE 1 LANDLORDS SUPPLY

ROLEC0211B EV CHARGER 7.4KW BLK



DATA SHEET

ROLEC*EV*

Product features

- Plug & charge, mobile app or RFID controlled charging
- Charging from 1c or 2c universal charging socket(s)
- Up to 7.4kW or 22kW charging outputs(s)
- IP66: full protection (no earth not required)
- Supports dynamic load balancing & static load management
- OCPP 1.6 compliant (can integrate with any back-office)
- Over-the-air firmware / software updates
- Built-in AC overvoltage & fault current protection (OCBO)
- Built-in EMC/DC leakage protection
- Dual tamper and breach security notifications
- Cable lock security feature (can be permanently locked by user)
- Integrated RFID reader
- LED anytime lighting (hard Protocol controlled)
- 4G / 3G / 2G / GSM / Ethernet connectivity
- 800 impact resistant design
- Surface or rack mountable
- C529 grant fundable
- Designed & manufactured in the UK




OCPP 1.5 compliant

Ability to integrate with any OCPP compliant back-office management system and app.



Easy to operate

 Three quick and easy ways to operate: mobile app, PC and tablet or plug & play



Eligible for grant funding

This range is approved for grant funding via the OZEV Workplace Charging Scheme (WCS).



4G / Wi-Fi / Ethernet enabled



Branding & colour options available



No earth rod required

Equipped with built-in PME fault detection, saving installation time and costs.

REV	DESCRIPTION	DATE
-	-	-
<u>ISSUE</u>		
PRELIMINARY		
<u>CLIENT</u>		
		
<u>PROJECT</u>		
CROSS ROAD, CHORLTON		
<u>TITLE</u>		
SITE PLAN & EV CHARGING		
<u>SCALE:</u>	1:100@A1	<u>DRAWN:</u> SG
<u>DATE:</u>	FEB 2024	<u>CHECKED:</u> MM
<u>DRAWING No.</u>	P0244/EV	<u>REV:</u> -
		
TeDS (ELECTRICAL) LTD ST MARK'S HOUSE, 29 WEST STREET, DUKINFIELD, CHESHIRE, SK16 4PL TEL: 0161 330 7506 EMAIL: design@tedsltd.co.uk		

BARRIER & SIGN FOR EV CHARGING BAYS

