




Proposed Module Layout Plan 1:350 @ A2:

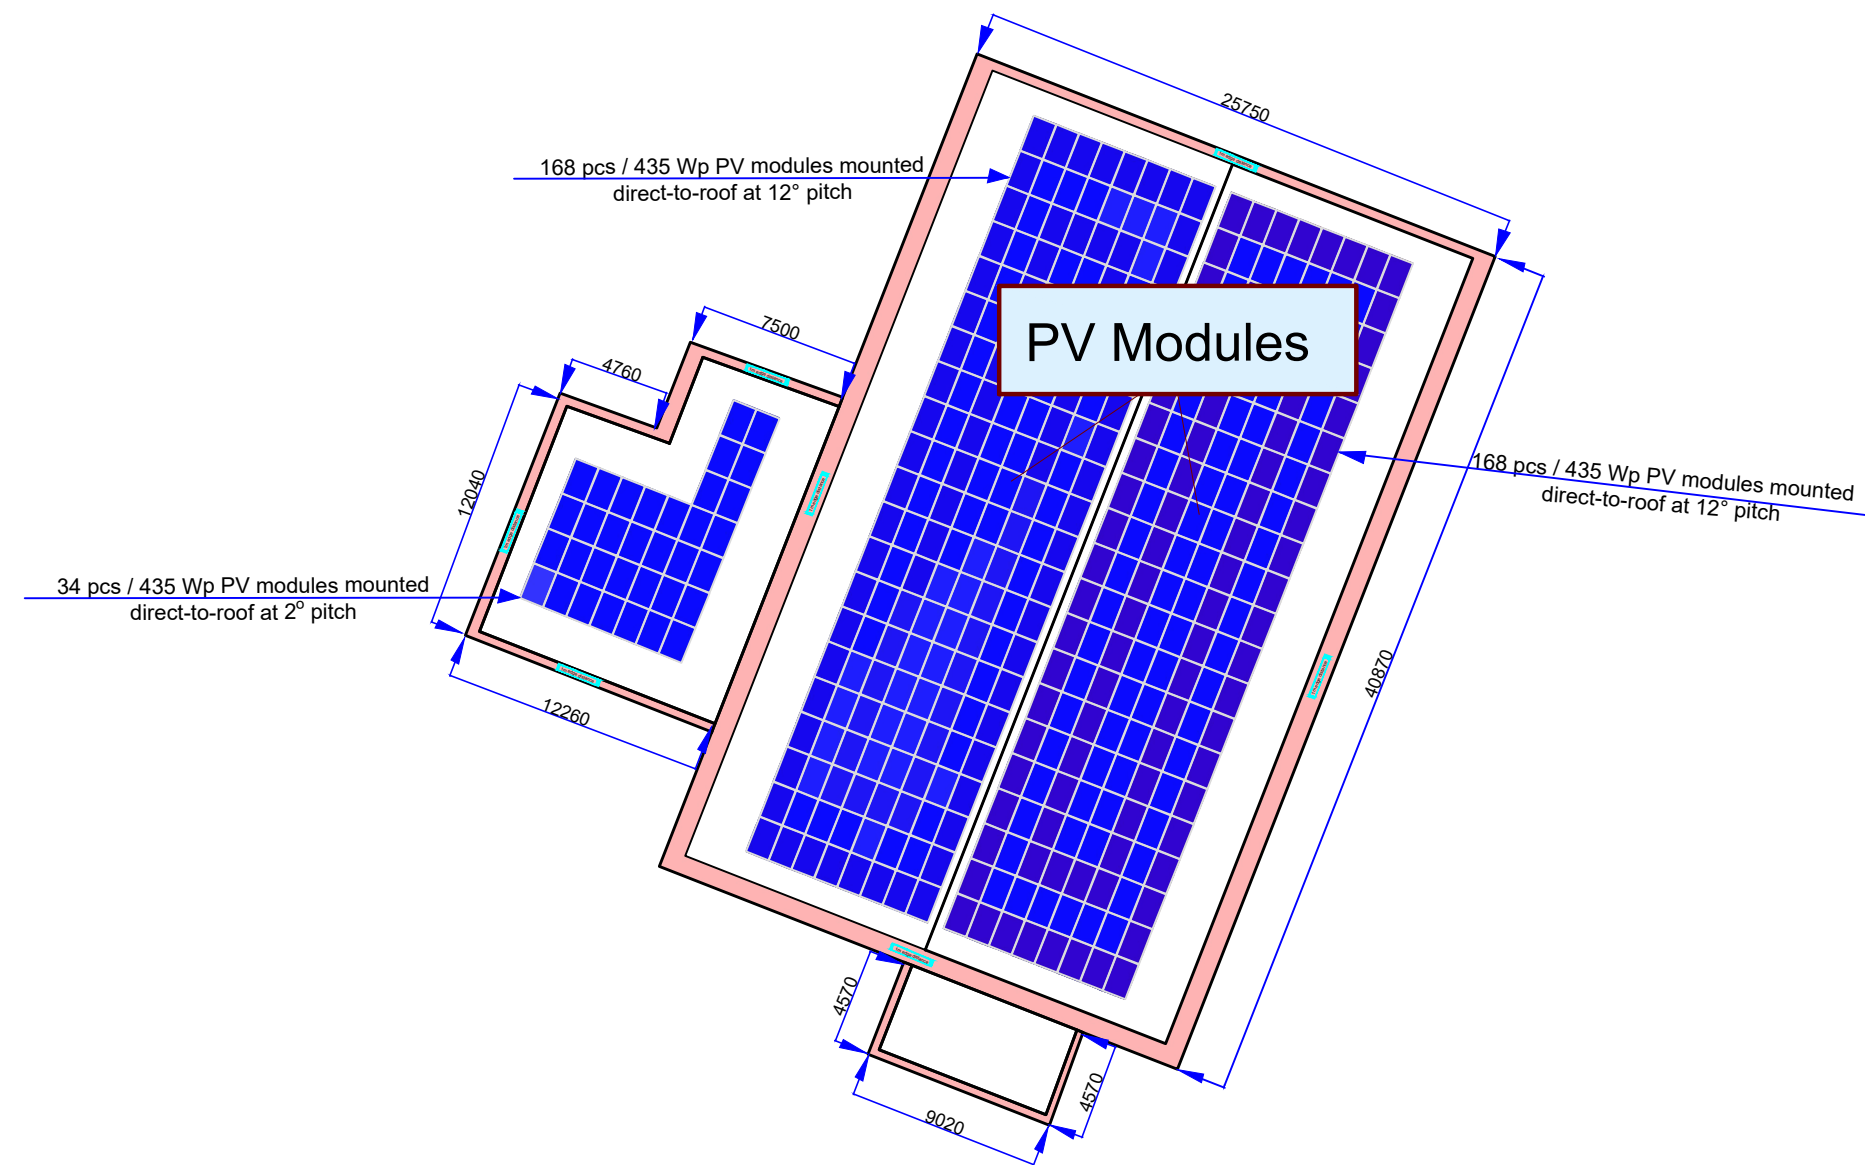


Proposed Northwest Elevation 1:200 @ A2:

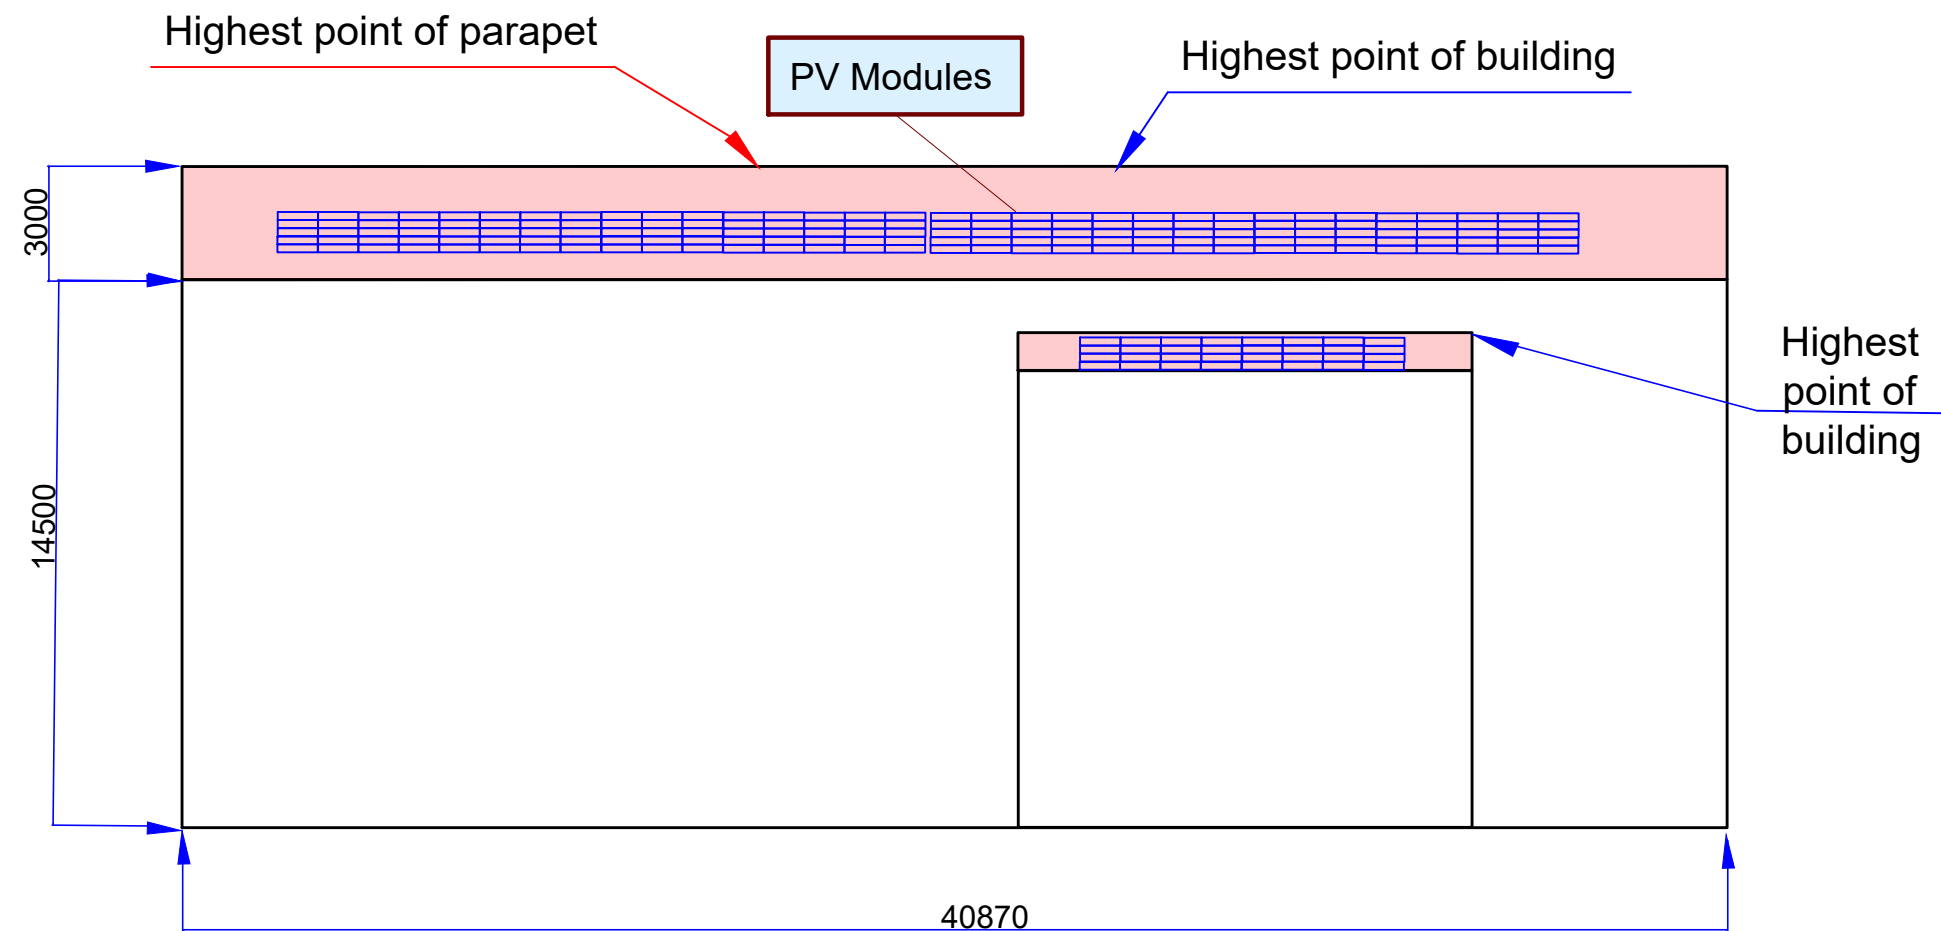

Proposed South Elevation 1:250 @ A2:

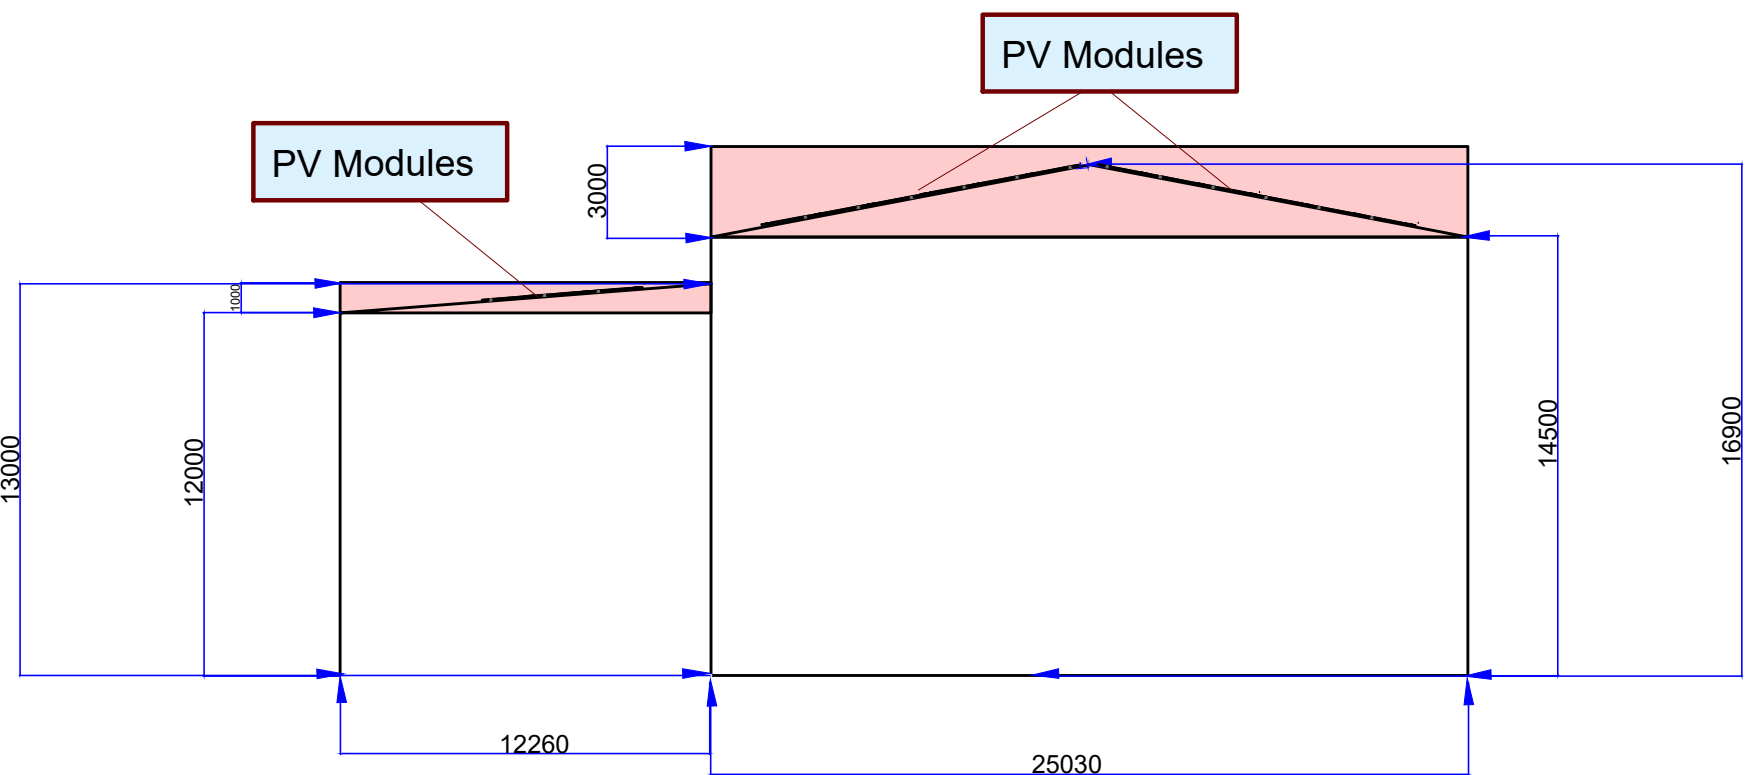

Proposed Solar Panel Elevation 1:5 @ A2:

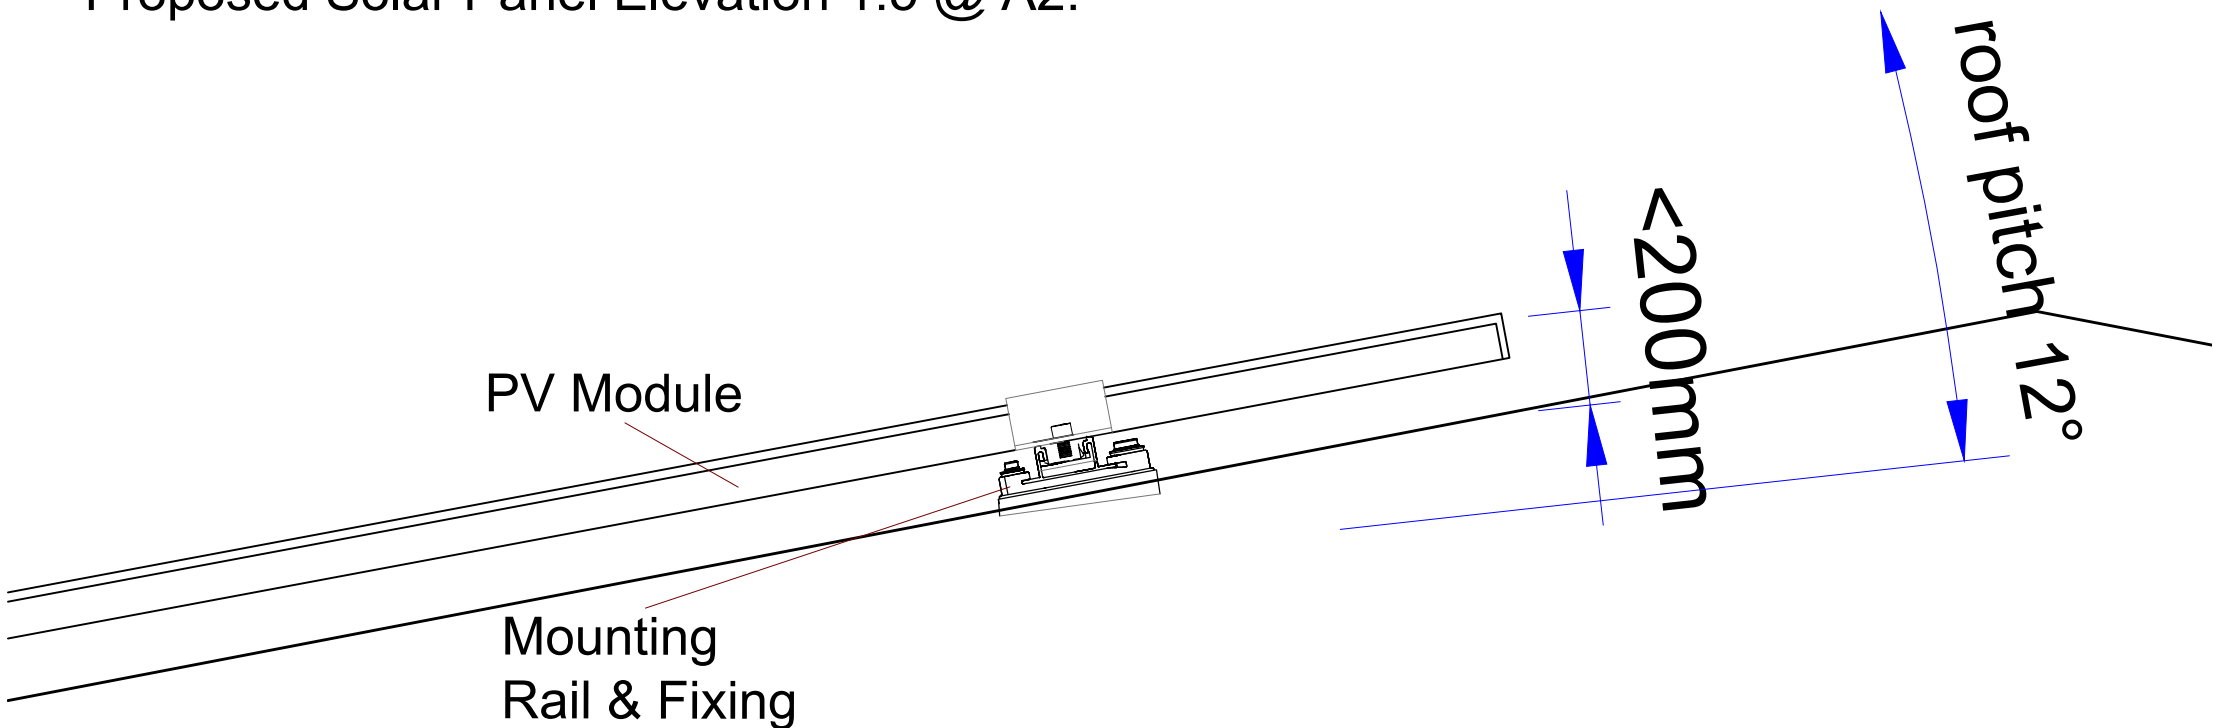

Notes:
1. All details are indicative only
2. All equipment designed, and to be installed in accordance with BS 7671:2018.

INECO ENERGY Ltd is a limited company registered in England and Wales.
Company Registration No. 10477244.
Registered Office: Sceptre House, 4 Bessemer Road, Cardiff, CF118BA.
This drawing or any part of it may not be reproduced without prior consent. Do not scale.
Always cross check dimensions on site. Always check you are viewing the latest version.

Module Qty:	370 pcs
Module rating:	435Wp
Module type:	LONGI LR5-54HTH
Optimizer Qty:	185 pcs
Optimizer type:	SE S1000
Inverter Qty:	1 pcs
Inverter type:	SE100K

DC capacity (PV):	160.95 kW
AC capacity (PV):	99.90 kW

CLIENT:	YMCA	DATE:	12/02/24
LOCATION:	Manchester YMCA, Castlefield Hotel, Liverpool Road, Manchester, M3 4JR	SCALE:	1:350, 1:200, 1:250 & 1:5 @ A2
PROJECT:	Manchester YMCA	DWG NO:	IE-M502-P03
DRAWING TITLE:	IE-M502-YMCA-2.3-Proposed Module Layout Plan	REVISION NO:	D1
CONTRACTOR:	Ineco Energy Limited	DEVELOPMENT	
TELEPHONE/EMAIL:	02920021777/info@inecoenergy.com		
WEBSITE:	www.inecoenergy.com		