
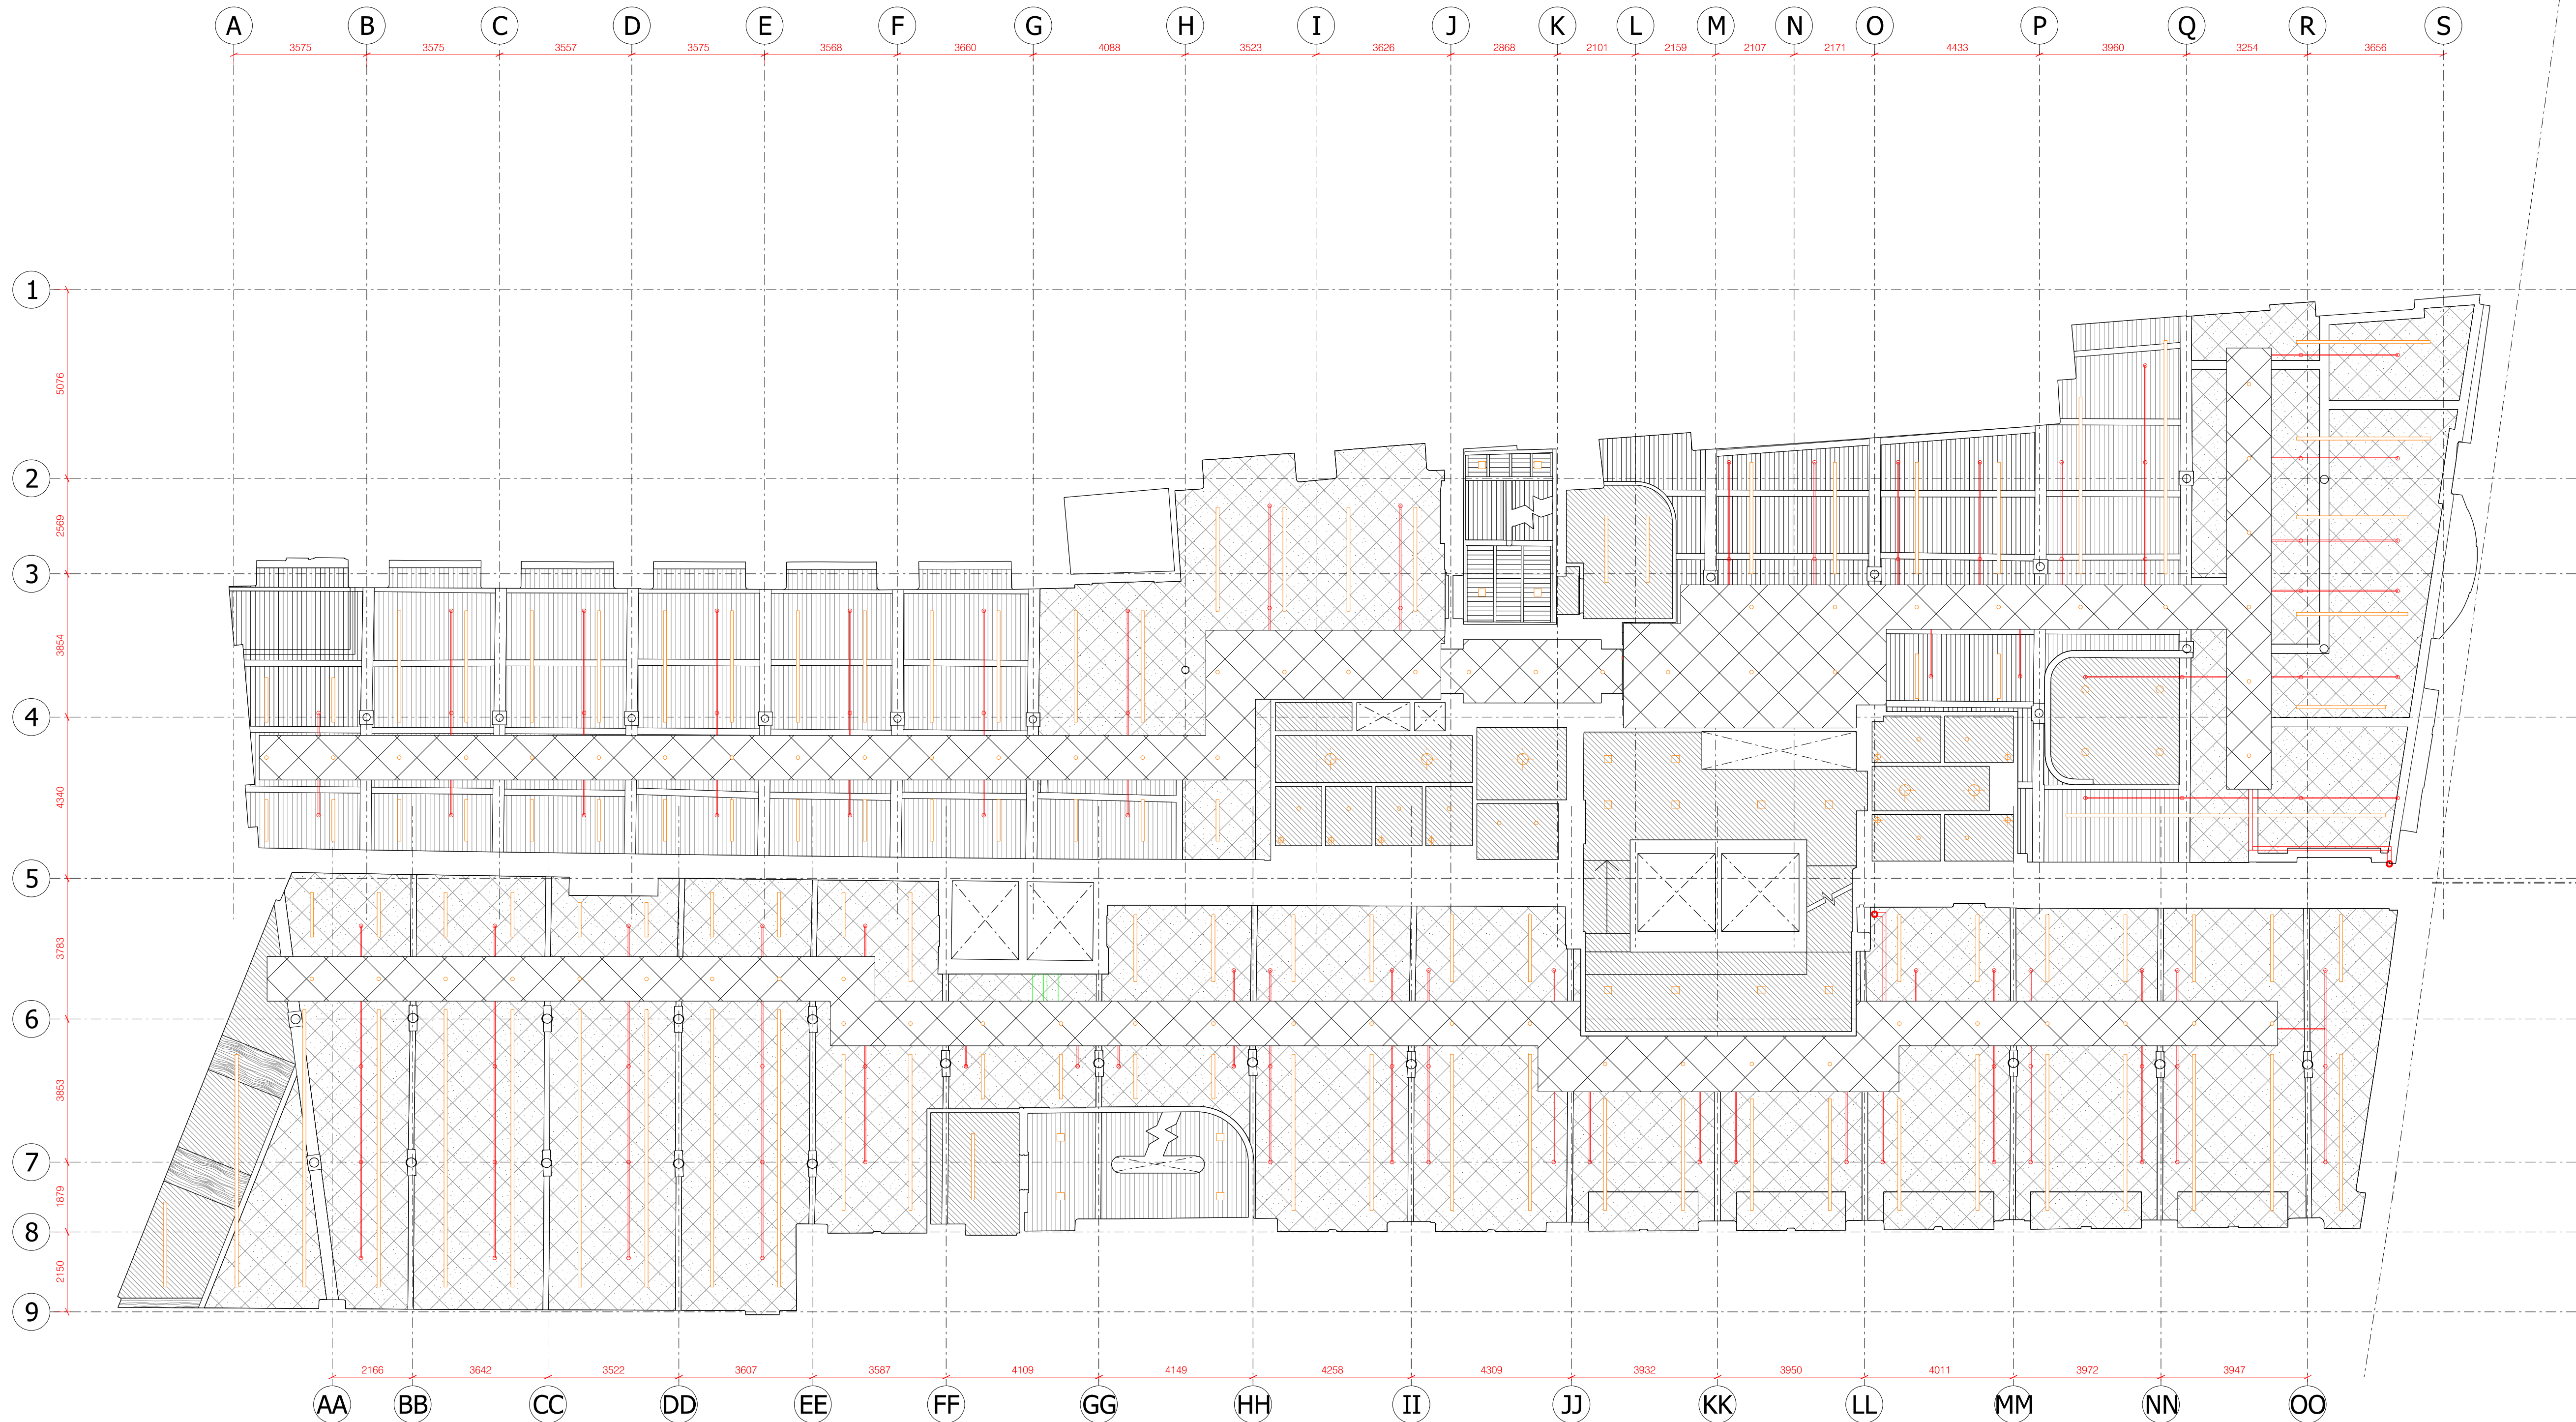


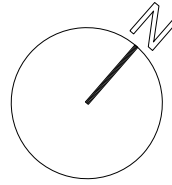

LEVEL 02 (Eastern Building)
LEVEL 01 (Langley Building)

PROPOSED REFLECTED CEILING PLAN - LEVEL 01 & 02 (1:100)

Proposed Ceiling Plan - Key

Original timber beam and joists to be retained. Cleaned subject to sample area. Overpainted with limewash subject to sample area.

Original floorboards/millboards to be retained. Minor areas of repair required - refer to SE plans. Cleaned (underside only) subject to sample area. Overpainted (u/side only) with limewash subject to sample.

Original concrete slab ceiling retained - no works

Void

Original lath and plaster ceiling retained in situ and overboarded with single additional layer of FR plasterboard below

New insulated plasterboard ceiling to underside of original timber rafters

2 layers of FR plasterboard to provide 60mins fire protection

Non original plasterboarded ceiling retained

Original brick vault ceiling retained - tanking system to be installed

New FR board protection to existing beams (basement level only)

Non original rooflights to be replaced with conservation rooflights

Original ornate cast column head retained - cleaned and intumescent painted

Original painted timber boarding to underside of staircase retained - overpainted only

Original ornate plaster coving (retained in situ) (level -01 and 02 only) See section right for approx section at level -01 adjacent to external doors to Princess Street (Langley Building).

Original lost plaster coving to be replaced with new to match existing (level 02 only)

New plasterboard ceiling

New sloped p/board ceiling at levels 09 and 10. 2 x layers 12mm p/board on new MF frame with 100mm mineral wool behind

Linear suspended linear light

approx 150x150x150mm black, square surface mounted downlight

directional suspended spotlight - approx 200 diameter x 300mm long

200mm diameter globe fitting

exposed bulb lights on ropes on horizontal steel bar

small pendant fitting adjacent mirrors in superloos

white recessed spotlight

suspended drum light fitting with flood diffuser (level 10 only)

directional spot lights on track mounted to timber beam (level 10 only)

sprinkler pipe

suspended plasterboard bulkhead

PPC oval duct with side vents (reception only)

electrical distribution tray

mechanical distribution tray

supply air duct with drum diffuser

supply air duct

extract air duct with bellmouth

FCU

bridge
architects

address 14 Old Mill Street, Manchester, M4 6DZ
directors Russell Bridge RIBA ARB Victoria Hilton ARB

phone 0161 679 2828 web www.bridgearchitects.com
company # 07793934 email info@bridgearchitects.com

revision notes
rev P02 - 2021-05-24 - Key note descriptions revised

project 40-46 Princess Street
client Wittington Investment Properties
job no. 0247
drawing no. al(45)023

drawing title
drawing scale
drawing rev

Proposed RCP Plan: Level 01 & 02
1:100 @ A1; 1:200 @ A3
Jan 2021
P02

FOR: PLANNING

bridge
architects

Do not scale from this drawing - use figured dimensions only
This design and drawing is the copyright of bridge architects Ltd and
may not be reproduced in any form without prior written consent.
Issue of the drawing does not impart any liability or implied copyright warranty.